


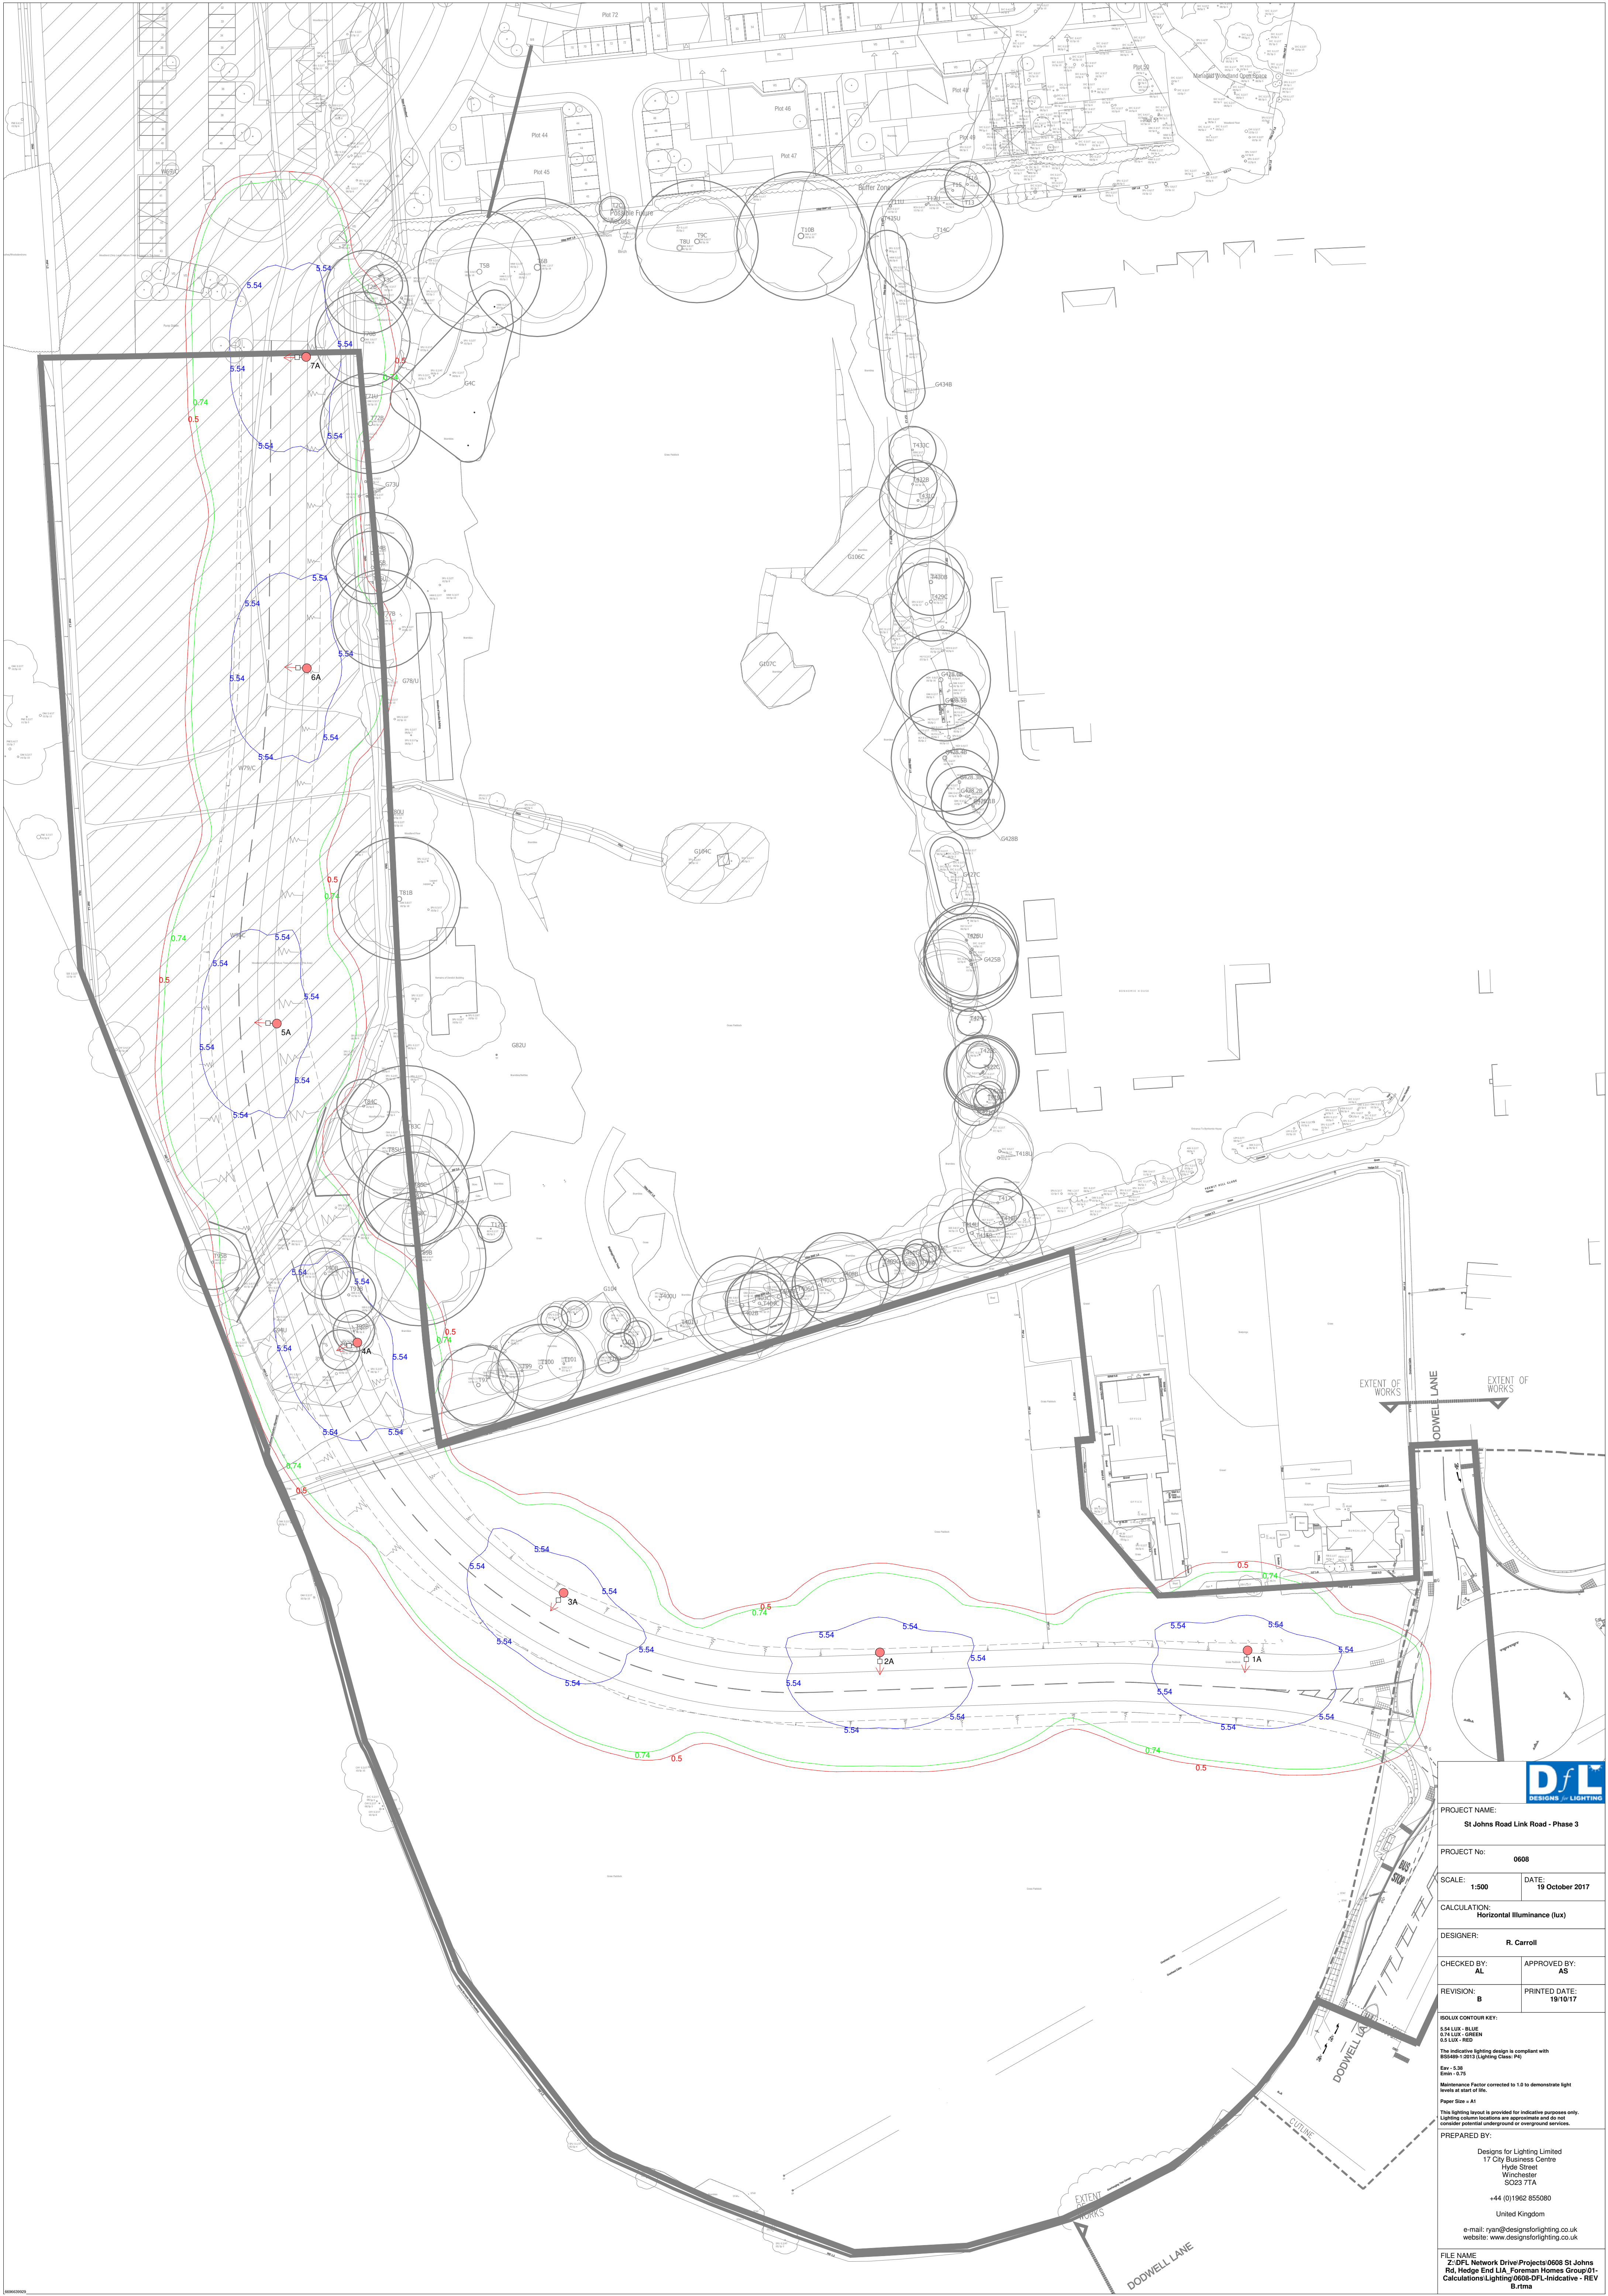

PROJECT NAME: St Johns Road Link Road - Phase 3	
PROJECT No:	0608
SCALE: 1:500	DATE: 19 October 2017
CALCULATION: Horizontal Illuminance (lux)	
DESIGNER: R. Carroll	
CHECKED BY: AL	APPROVED BY: AS
REVISION: B	PRINTED DATE: 19/10/17
SOLID CONTOUR KEY: 5.54 LUX - BLUE 0.74 LUX - GREEN 0.5 LUX - RED The Indicative lighting design is compliant with BS5489-2:2013 (Lighting Class: P4) E _{av} = 5.38 E _{min} = 0.75 Maintenance Factor corrected to 1.0 to demonstrate light levels at start of life. Paper Size = A1 This lighting layout is provided for indicative purposes only. Lighting column locations are approximate and do not consider potential underground or overground services.	
PREPARED BY: Designs for Lighting Limited 17 City Business Centre Hedge Street Winchester SO23 7TA +44 (0)1962 855080 United Kingdom e-mail: ryan@designsforlighting.co.uk website: www.designsforlighting.co.uk	
FILE NAME: Z:\DfL Network Drive\Projects\0608 St Johns Rd, Hedge End LIA, Foreman Homes Group\01. Calculations\Lighting\0608-DfL-Indicative - REV B.rvtm	