


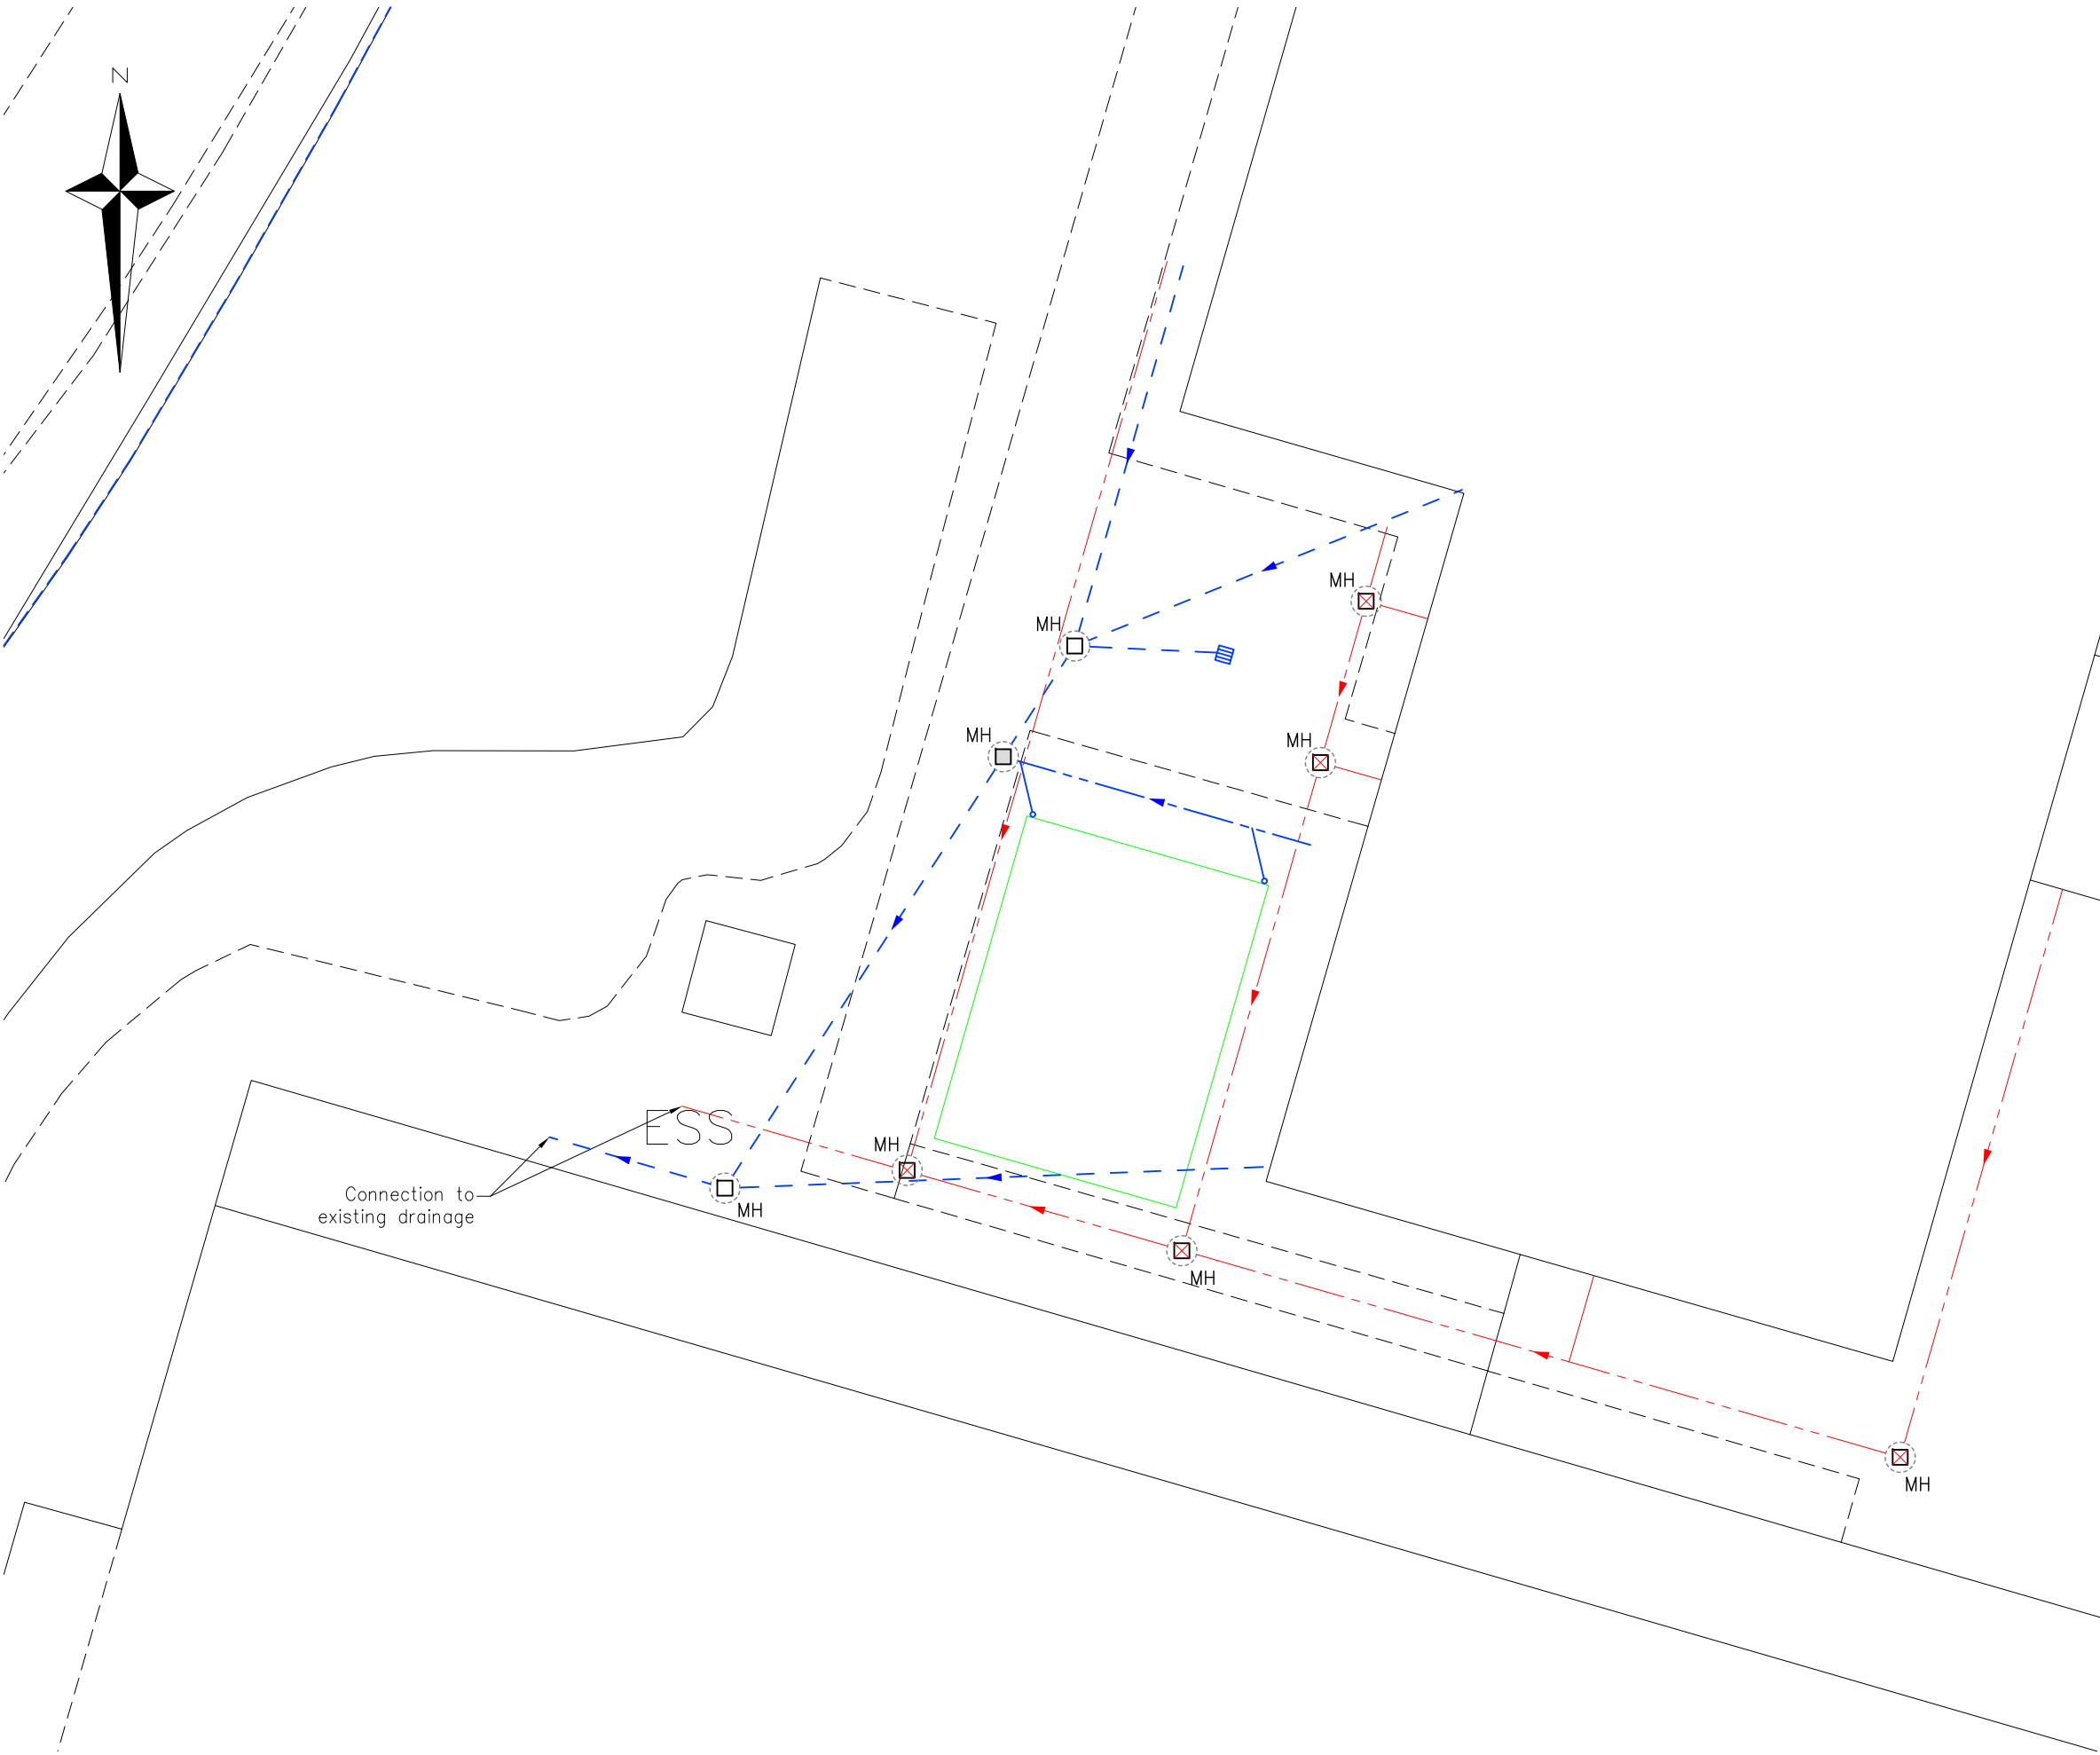


Key:

- MH Existing Surface Water Man Hole
- MH Existing Foul Water Man Hole
- MH Proposed Surface Water Man Hole
- MH Proposed Foul Water Man Hole
- Gully
- Existing Surface Water Pipe
- New Surface water 150mmØ PVC-U pipe
- Existing Foul Pipe
- New Foul water 150mmØ PVC-U pipe

Notes:

1. All existing drainage lines to be rodded prior to the proposed works and any damaged sections should be repaired at this time.
2. All new pipes to be 150mm Ø PVC-U pipes with a minimum fall of 1 in 80.
3. All drainage works to comply with BS EN 1610:1998, BS EN 752-4:1998, BS EN 752-3:1997 and BS EN 12056-1 2000
4. Foul drainage pipes to be in accordance with BS EN 12056-2 2000.
5. All new drains to be tested in accordance with BS EN 1610:1998
6. re denotes rodding eye

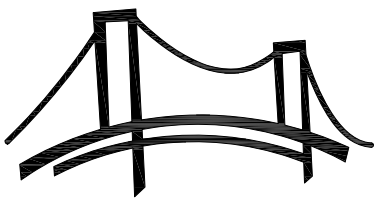

ARVdesign

Rev	Comment	Date
Designer: Ross Vinter		

Client:	Smart-Space Instant Buildings
Project:	New Classroom at Stoneham Lane Football Complex
Title:	Drainage Plan

Job No.	35134
Drawing No.	PLN03
Revision No.	00
Scale:	1:200 @ A3

© ARV Design
15 Eastwood Avenue, Giffnock, G46 6LS
www.arvdesign.co.uk ross@arvdesign.co.uk
07921 993 680