


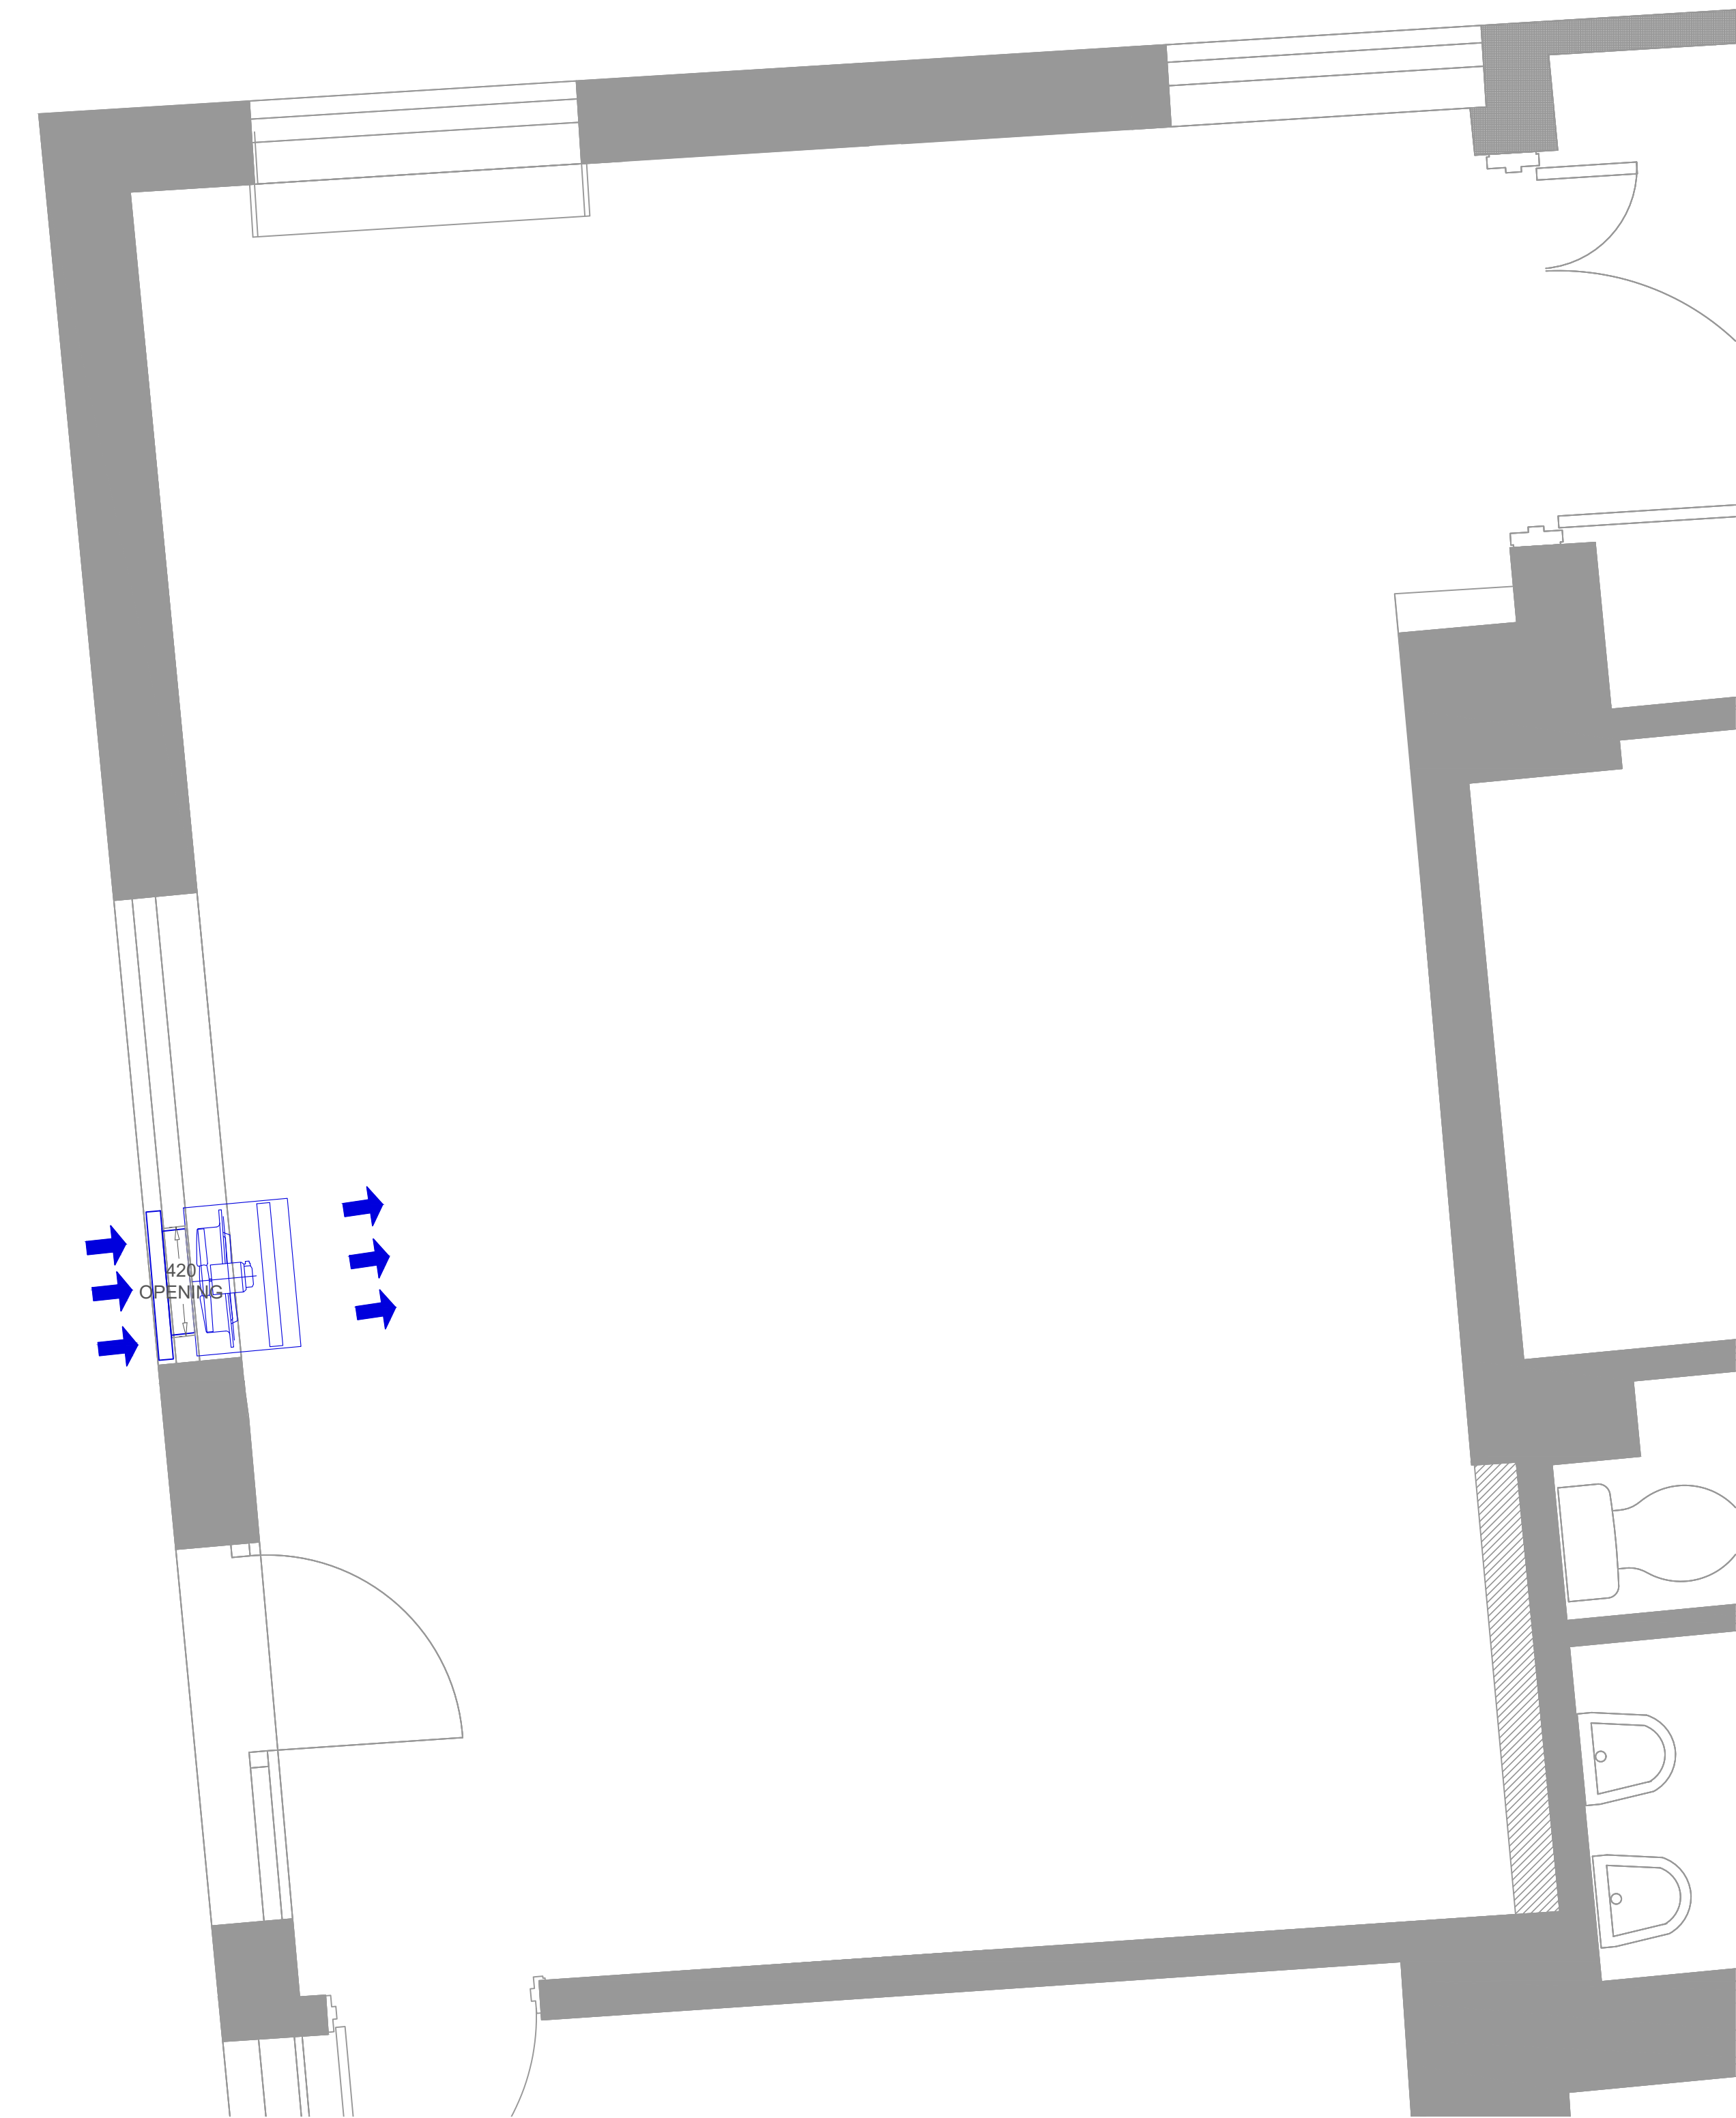

Fan Details	
Kitchen Make-Up Air	
Model	450 plate fan
Air Flow Rate	1.10m3/s
Spigots Air Flow Rate	N/A

- INSTALLATION NOTES**
- REVIEW ALL DETAILS BEFORE STARTING INSTALLATION
 - ALL DUCTING SUPPORTS TO TO HAVE ANTI VIBRATION MOUNTS FITTED

BASED ON THE DRAWING PROVIDED AND STRICTLY SUBJECT TO A FULL SITE SURVEY AND DESIGN MEETINGS.



Tel: 01733 230378
Email: info@ckdirect.co.uk Web: www.ckdirect.co.uk

This drawing and all information herein is confidential and belongs to CK Direct Duct and Maintenance LTD. It is disclosed in confidence on terms that it will not be disclosed to any third party, used, sold, loaned, licensed, or reproduced in whole or in any part in any manner or form for manufacturing, tendering or for any other purpose without the written permission of CK Direct Duct and Maintenance LTD. The copyright is retained by CK Direct Duct and Maintenance LTD.

© CK Direct Duct and Maintenance LTD

Colour Line Legend

- Kitchen Extract
- Kitchen Ambient MUA
- Kitchen Tempered MUA
- General Extract
- General Supply Air
- Toilet Extract
- Toilet Supply

Key Parts Legend

- VCD - Volume Control Damper
- KEF - Kitchen Extract Fan
- KMF - Kitchen MUA Fan
- MUF - MUA Filter
- ACP - Access Cleaning Panel
- FDP - Fire Damper
- ATT - Attenuator
- FDC - Flexible Duct Connector
- AVM - Anti-Vibration Mounts

Revision Information

Revision No	Revision Date
R1	16-11-21
R2	14/03/2022
R3	03/04/2022
R4	18/05/2022
R5	24/05/2022
R6	26/07/2022
R7	28/07/2022

Drawing No and Revision

Revision Information

- First Issue
- To Suit internal setting out
- Added elevations drawings
- Updated title
- Added internal ductwork
- Updated removing extract system and adding make-up air fan box within window
- Updated make-up air fan box within window

TR174814-DRG-001-R7

APPROVAL

Client

TAG Catering Equipment

Drawing Title

Proposed floor plan and proposed elevations

Project Address

Southampton

Project Title

Purbani Southampton

Issue Date

16-11-21

Scale - Paper Size

1:20 - A1

Drawn By

SLW