

| Drawing Revisions |          |                                    |    |
|-------------------|----------|------------------------------------|----|
| ISSUE             | DATE     | REVISION                           | BY |
| Rev A             | 06/06/22 | Garage and room over walls updated | GS |
| Rev B             | 21/06/22 | Updated to Clients comments        | GS |
| Rev C             | 12/07/22 | Furniture and M&E Shown            | GS |
| Rev D             | 25/08/22 | Updated to Clients comments        | GS |
| Rev E             | 12/09/22 | RWP's Added and WC Boxing removed  | GS |

General Notes

This drawing is to be read in conjunction with the standard technical specification and other documentation as deemed necessary.

SETTING OUT:  
All dimensions are taken from brickwork / blockwork face and plasterboard face of stud partitions

## CONSTRUCTION

Drawing produced for:



Do Not Scale!  
All Dimensions Are In Millimetres Unless Otherwise Stated  
If In Doubt Ask!

PROJECT:  
The Hermitage  
Netley - The Paddock

DRG TITLE:  
PLOTS 3, 4, 5 and 6  
First Floor Plan


|                        |                      |           |
|------------------------|----------------------|-----------|
| JOB NO:<br>GS222601-02 | DRG NO:<br>THNBR 024 | REV:<br>E |
| SCALE:<br>1:50 (A1)    | DRN BY:<br>GWS       |           |
| DATE:<br>05/2022       | CKD BY:              |           |

Drawing produced for:

Jon Dale Architect Ltd.

Jon Dale RIBA 12 Crestwood View, Eastleigh, Hampshire, SO50 4NF  
Tel: 07787 575126 E-mail: jondalearchitect@gmail.com

This drawing is copyright ©

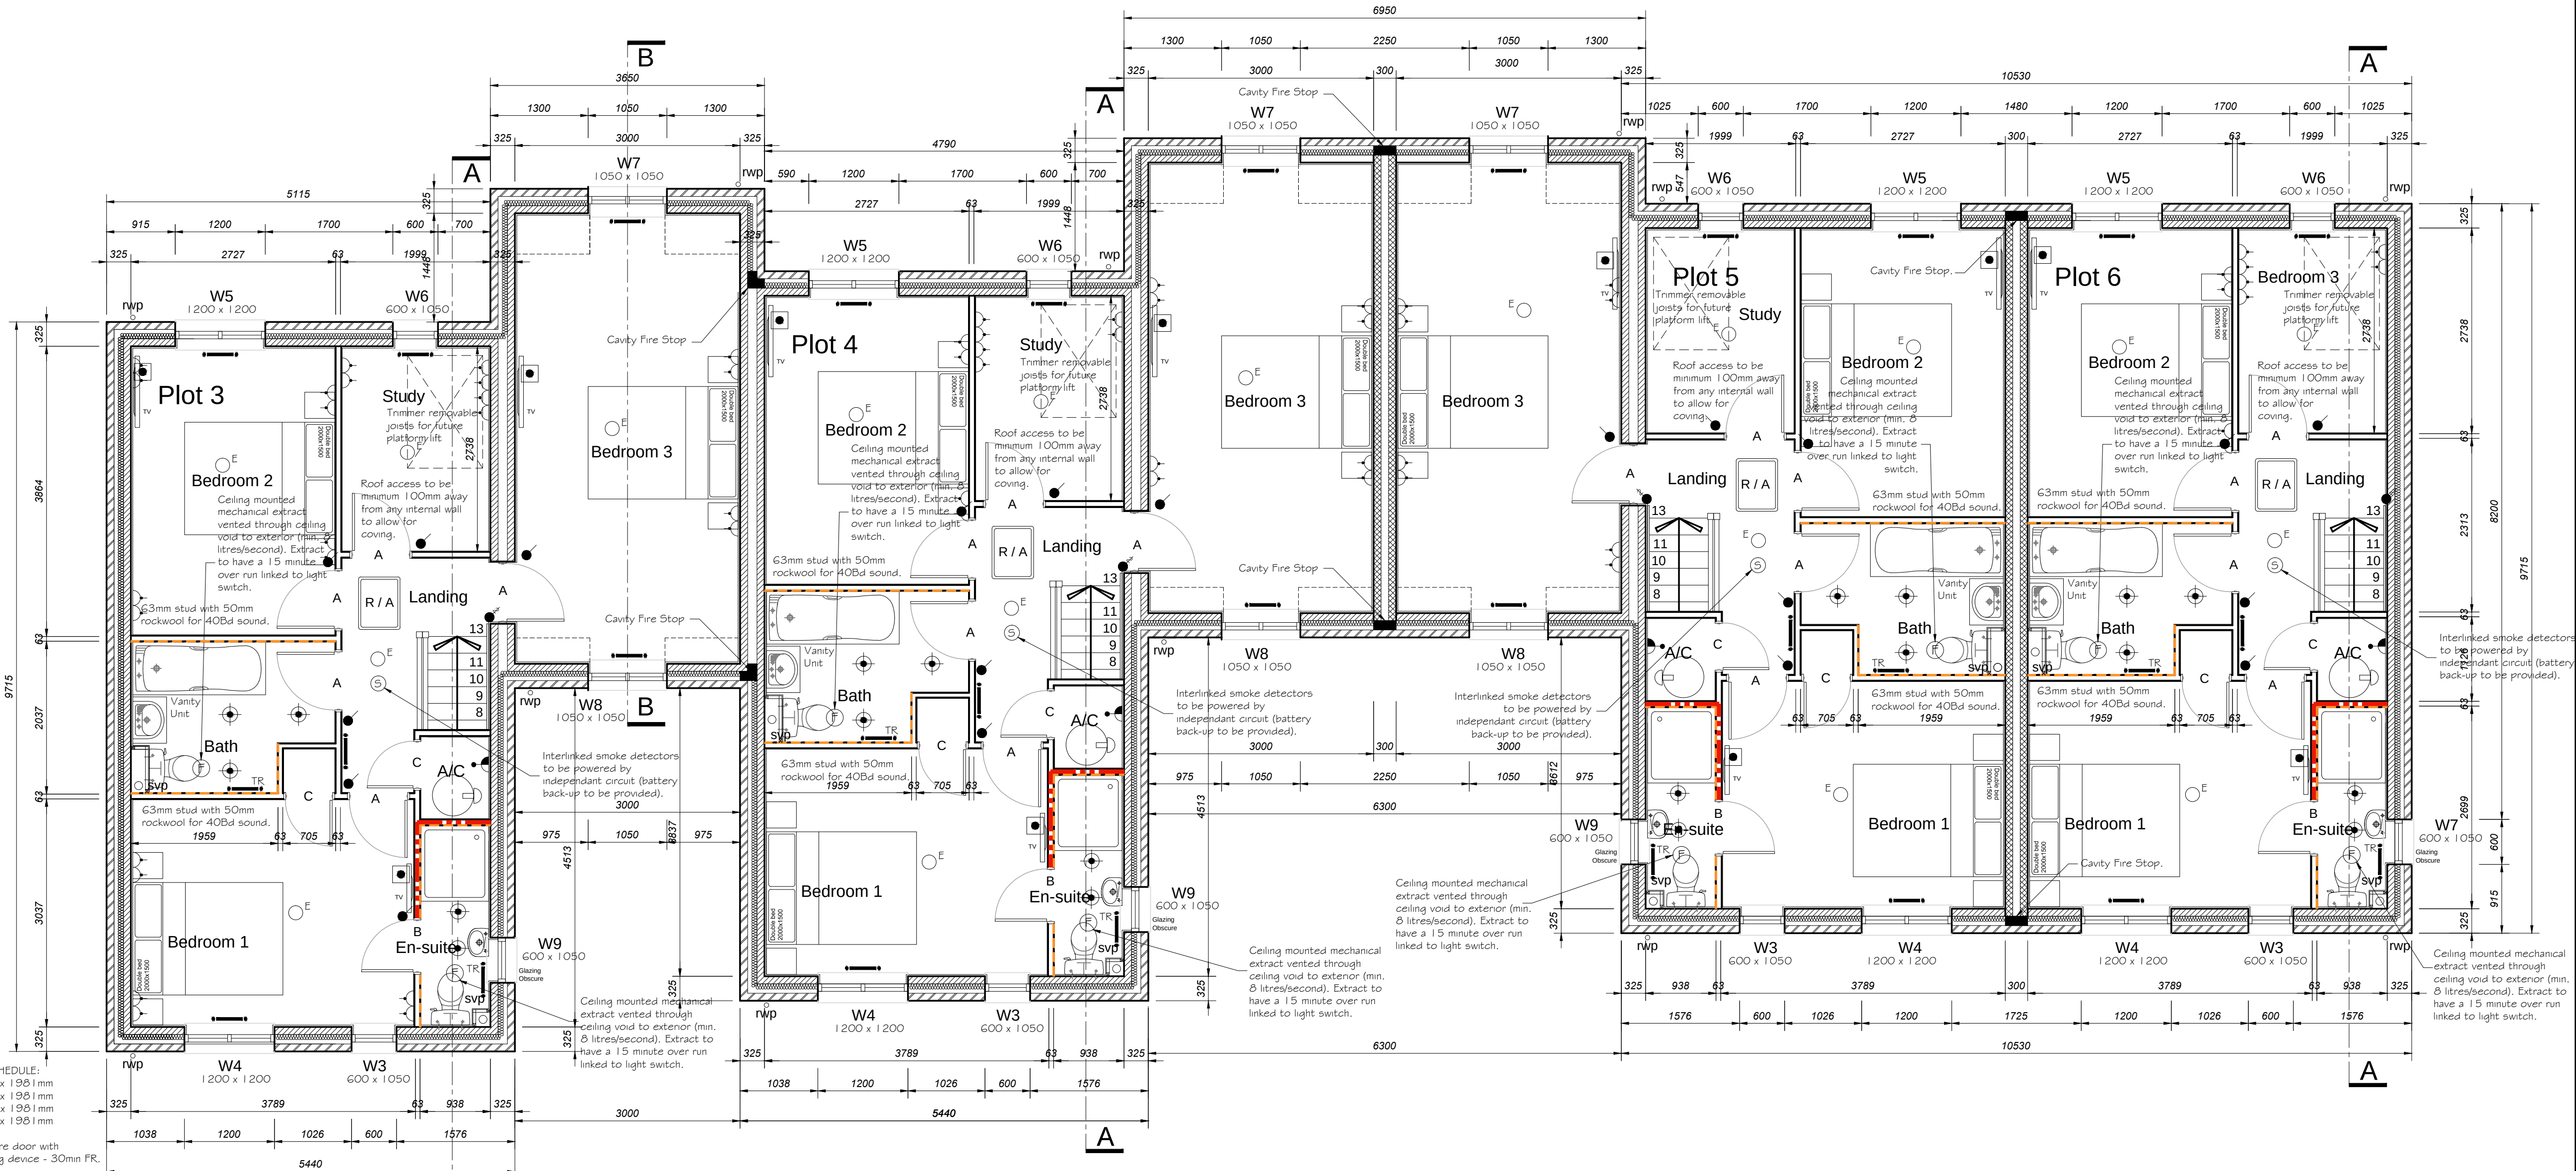

### First Floor Plan

Wall lined with 12mm Ply for future Doc M fixing.  
Stud walls around shower to be 400mm Centres

### Legend

|  |                                                    |
|--|----------------------------------------------------|
|  | Dense blockwork 100mm thick unless noted otherwise |
|  | Block 140mm thick Density 1350 - 1600kg/m cube     |
|  | Durox supaloc 100mm thick                          |
|  | Facing Brickwork 102.5mm thick                     |

### Electrical Symbols Legend

|  |                                                                                           |
|--|-------------------------------------------------------------------------------------------|
|  | Consumer unit                                                                             |
|  | Pendant light fitting E denotes efficient lighting                                        |
|  | Batten holder fixing                                                                      |
|  | External light fitting                                                                    |
|  | Light switch 1 way, 1 gang mounted 1950 above f.f.l.                                      |
|  | Light switch 2 way, 1 gang mounted 1050 above f.f.l.                                      |
|  | Light switch 2 way, 2 gang mounted 1050 above f.f.l.                                      |
|  | Dimmer switch mounted 1050 above f.f.l.                                                   |
|  | Fan isolator switch mounted 2100 above f.f.l.                                             |
|  | Single switched socket outlet 13A mounted 450 above f.f.l.                                |
|  | Twin switched socket outlet 13A mounted 450 above f.f.l.                                  |
|  | Blanked off power point for future use mounted 1650 above f.f.l.                          |
|  | 3A switched connection for boiler mounted 1050 above f.f.l.                               |
|  | Room thermostat for central heating mounted 1050 above f.f.l.                             |
|  | Television coax aenal socket mounted 450 above f.f.l.                                     |
|  | Smoke detector                                                                            |
|  | Shaver socket no light mounted 1050 above f.f.l.                                          |
|  | Ceiling mounted fan                                                                       |
|  | Telephone point mounted 450 above f.f.l.                                                  |
|  | Recessed downlighter with intumescent cover                                               |
|  | 20 amp, dual switch with pilot light 20 amp, triple                                       |
|  | Indicative position radiators, exact location & quantity to be determined by M&E engineer |
|  | TR = Towel Rail                                                                           |
|  | KS = Kitchen Kickspace Heater                                                             |
|  | Underfloor Heating Manifolds                                                              |
|  | Bell sounder                                                                              |
|  | Bell push                                                                                 |
|  | Alarm Control Panel Position (wiring only)                                                |
|  | Alarm keypad Position (wiring only)                                                       |

### General Specification & Construction Notes

#### Ground Floor

Ground Floor: Beam and Block on Traditional foundations to Engineers depth with 150mm Celotex XR4000 Floor insulation (Or similar approved) on 5000 gauge DPM with 75mm Fibre cement screed to finish.

#### Wall Construction Below DPC

Load bearing bricks to be FL Grade and have a minimum crushing strength of 21 N/mm<sup>2</sup>. Mortar mix to be 1:1:4 cement:lime:sand, with Naylor R2 100 x 145mm beams to span over any drainage.

#### DPC

Horizontal DPC to all walls to be 100mm wide 2000 Gauge black polythene. Laps to be 150mm minimum.

#### Wall Construction

External wall construction from Facing 102.5mm Brickwork with 125mm cavity, Filled with 75mm Celotex or other similar approved. Internal and external leaves tied together with stainless steel wall ties, spaced at maximum 900mm horizontally and 450mm vertical (225mm at openings/reveals) centres. To give a U-Value of 0.21 W/sq.mK.

Internal finish to external walls to be 12.5mm taper edge plasterboard on 12.5mm adhesive dabs, Tape and Joint

Mortar mix to be 1:3 - cement:sand. Stainless steel wall ties to BS 1243 (as amended) spaced at 900mm c/c horizontally and 450mm c/c vertically and staggered. Wall ties to be provided at 225mm c/c at openings and reveals.

Internal stud partitions to be 63mm timber studs @ 600mm centres (400mm Centres around showers) with facings of 12.5mm wallboard, with all joints taped and finished with tape and joint with 50mm Rockwool inside to achieve a weighted sound reduction index not less than 40dB over the frequency range 100-3150 Hz.

#### Windows

External windows to achieve a U-value of 1.55 W/sq.mK or a centre-pane value of 1.2W/sq.mK. All glazing to be 24mm overall thickness (16mm air gap) Low E soft coat, argon filled double glazed units (Pilkington K glass or similar) to achieve an overall U-value of 1.8W/sq.mK. All glass fitted within 800mm of the finished floor level to be toughened safety glass. Glass to rooflights to be toughened safety glass.

#### Roof

Pitch roof to Specialist Design. Ceiling to be insulated using 400mm mineral wool quilt laid in two layers between rafters, 200mm first layer and 200mm second layer crosslaid over and finished with 15mm Standard Wallboard.

#### Sloping Ceiling

15mm Duplex Plasterboard under, 100mm Rafters with 150mm, 1No. layer of 100mm Between and 1No. Layer 50mm Celotex (Or similar approved) under rafters, with Tyvek Supro over, with 25mm battens and tiles.

#### First Floor

Timber floor to Specialist Design, with 100mm mineral wool insulation between joists & 15mm Plasterboard under.

#### Ventilation

Trickle vents in the head of the frame with a minimum area of 8000mm<sup>2</sup>. Kitchen area to be provided with a cooker hood to extract at a rate of not less than 30/s.

#### Electric Work

All wiring and electric work to be designed, installed, inspected and tested in accordance with the requirements of BS 7671, the IEE 18th Edition wiring guidance and Building Regulations Part P (electrical safety) by a competent person registered with an electrical self-certification scheme authorized by the Secretary of State. The competent person is to send to the Local Authority a self-certification certificate within 30 days of the 'electrical works' completion. The client must receive a copy of the self certification certificate and a BS7671 Electrical Installation Test Certificate.

Smoke detectors to be mains operated, self contained and permanently wired to a separate circuit at the distribution board.

#### Drainage

Sanitary pipework to be 100mm diameter uPVC. New underground drainage to be 100mm dia uPVC drains laid and surrounded with 100mm pea shingle. Falls to be 1:40 if possible but in any event not to be less than 1:80. Reinforced PC lintels (where appropriate) to be provided above any drains passing through or under walls. All foul and rainwater drainage to be in accordance with Approved Document H1, Section 2 and H3, Section 2.

#### Structural Steelwork

All structural steelwork to be clean, rust free. Beams to be laid in on length without splices and encased.

#### Foundations

Foundations to be constructed as detailed by SE and to the approval of the approved inspector.