



1. Do not scale from this drawing
2. All dimensions in metres; all levels relate to Ordnance Datum.
3. The level & location of all existing services shall be verified and marked on site by the Contractor prior to commencing any construction work.
4. This drawing is to be read in conjunction with all other relevant drawings including engineering layouts, drainage plans and longitudinal sections along with lower or higher authority specifications. The contractor is to satisfy themselves with there are no discrepancies between the design and the drawings. There shall be no discrepancies.
5. If the Contractor is proposing to use the "Perfect Manhole System", then they shall inform the engineers prior to placing orders to confirm that the drawings are to the latest approved designs and current revision.
6. All adoptable foul & storm manholes, pipework and associated works shall be constructed in accordance with the current form of Sewers for Adoption latest Design & Construction (DCG) and any other relevant Water Authority specification or addendum.
7. Typically all pipework to be adopted for adoption should be as follows:  
DN100 to DN225 shall be Extra/High strength vitrified clay, DN300 and above shall be Extra/High strength vitrified clay or for the Contractor wishes to use a structural wall plastic pipe as an alternative then approval must be gained from the adopting authority prior to works being undertaken.
8. For sewer construction and manhole specification, refer to standard construction details and water authority addendum.

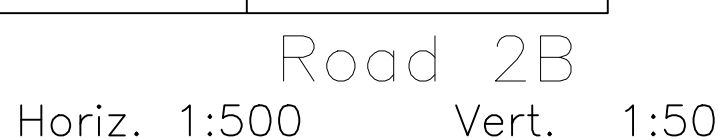

|      |          |                                                                                        |             |       |         |
|------|----------|----------------------------------------------------------------------------------------|-------------|-------|---------|
| C2   | 22.03.22 | As built surface water sewer invert levels added.                                      |             | TC    | TC      |
| C1   | 21.03.22 | Construction Issue.                                                                    |             | TC    | TC      |
| P3   | 21.02.22 | Notes updated in line with S104 comments..                                             |             | WJ    | TC      |
| P4   | 04.11.21 | Surface water sewer through R42 & 2A added, Long Section drainage amended accordingly. |             | RJC   | TC      |
| P2   | 23.08.21 | FW07, FW08 added to Road 4.                                                            |             | RJC   | TC      |
| P1   | 25.06.21 | First Issue.                                                                           |             | WJ    | TC      |
| REV. | NO.      | DATE                                                                                   | DESCRIPTION | DRAWN | CHECKED |

Client: **Vistry Group**

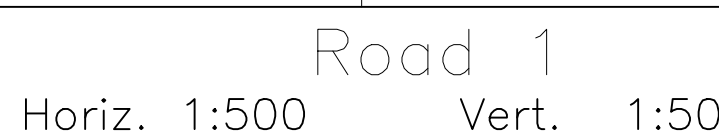

**MJA CONSULTING  
CIVIL & STRUCTURAL ENGINEERS**

Ipsium Court, 2 The Quadrant,  
Abingdon Science Park, Abingdon  
Oxon, OX14 3YS  
Tel: 01235 555173  
Email: mail@mjaconsulting.co.uk

---

Project: **Boorley Green,  
Parcel C6**

Title: \_\_\_\_\_ Scale: As shown @ A0 Status: CONSTRUCTION

Drawn: WJ Project Engineer TC MJA Project No: 6470 Date: 14/05/2021

Longitudinal Sections Drawing Number: B1015-MJA-P6-XX-DR-C-100 Rev: C2