



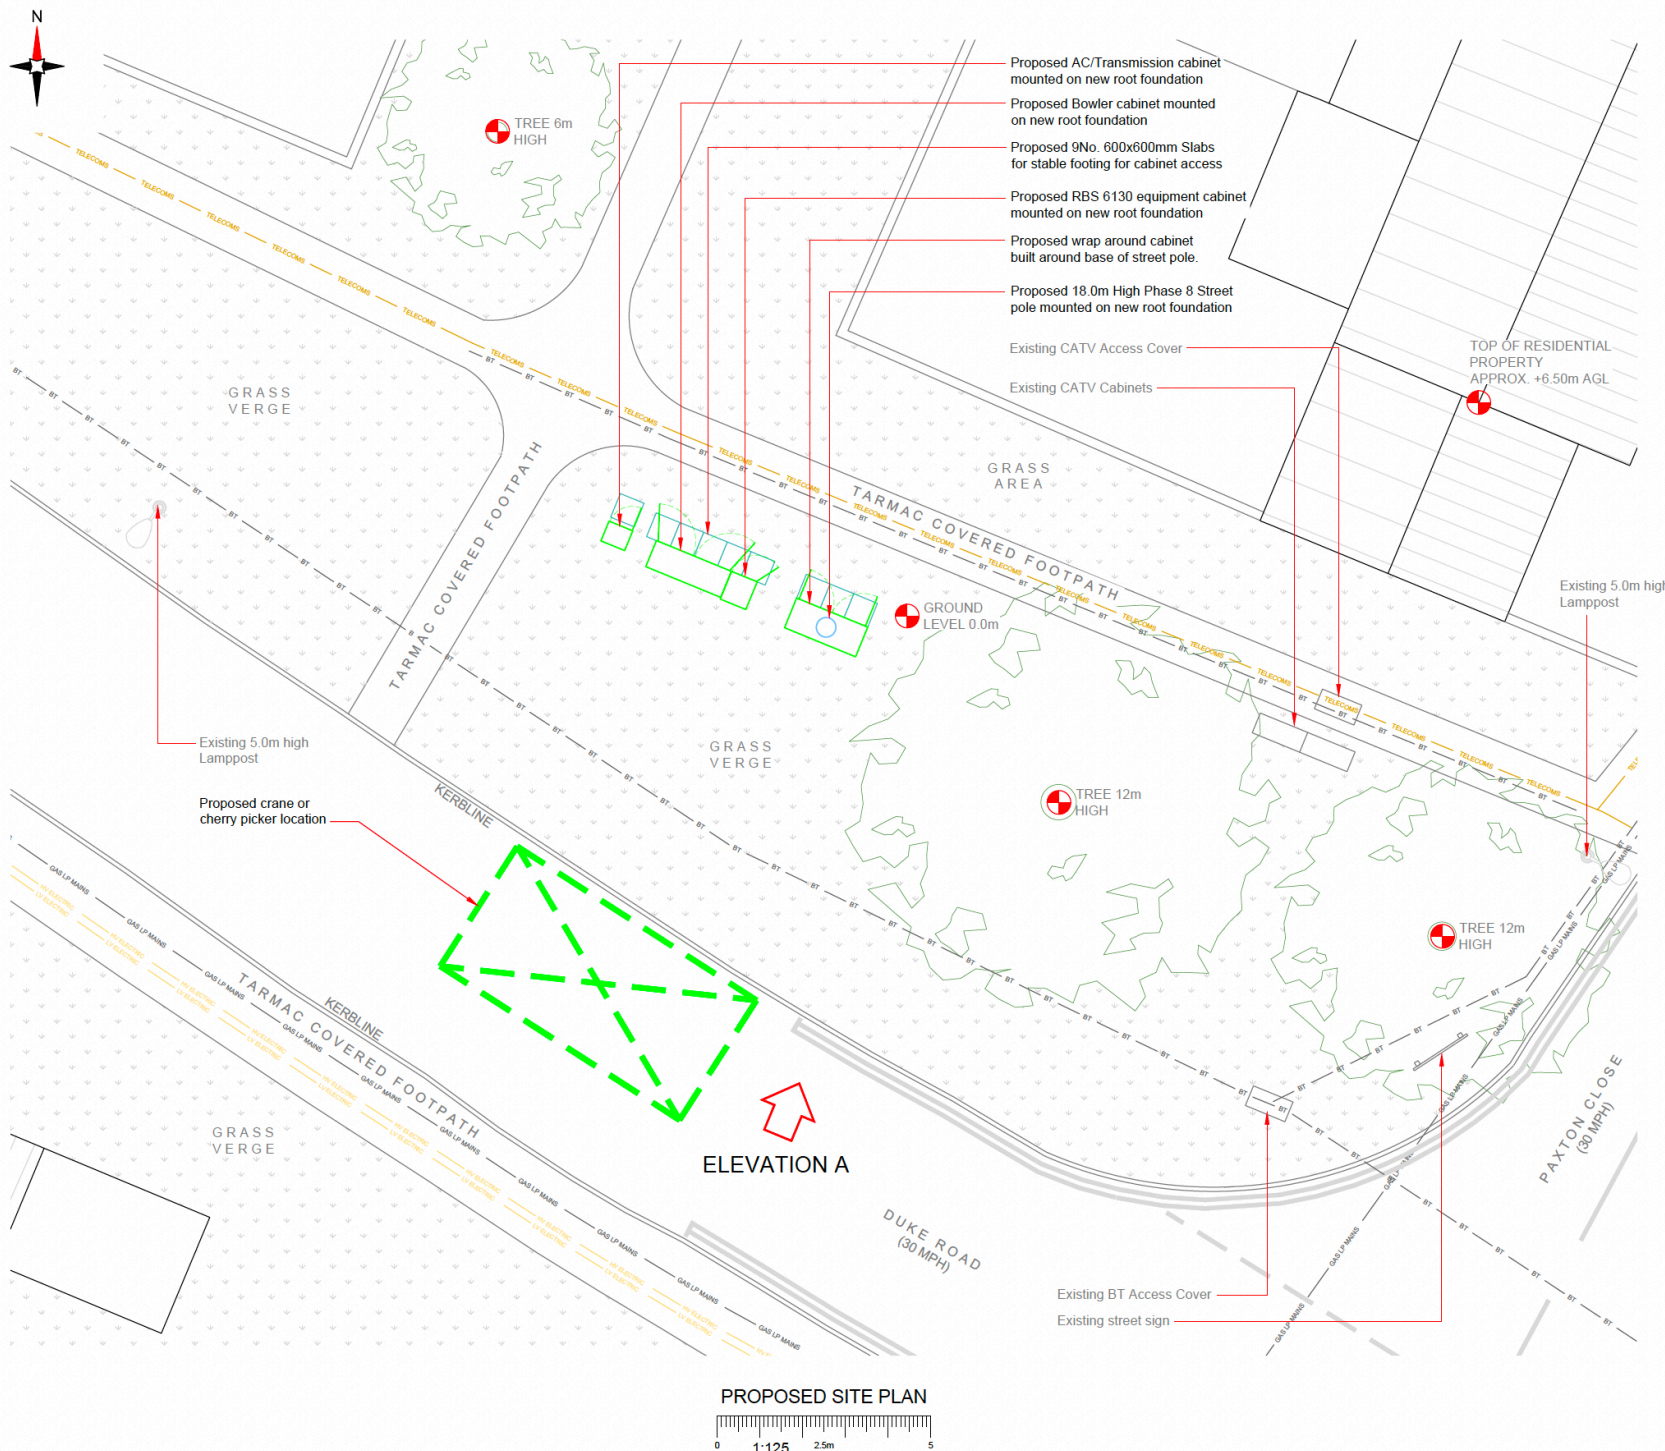

NOTES:

- ALL DIMENSIONS IN MM UNLESS OTHERWISE NOTED.

SERVICES LEGEND

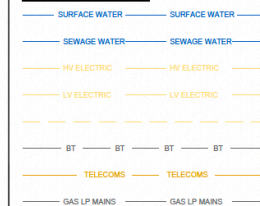

Master:	MBNL / EE / H3G:	Project:	Purpose of Issue:	Issue:
M001	H3G	DENSIFICATION SW	Planning	A
Date:	13/10/2022	Revision / Upgrade Description:		
Drawn:	M Niblock	First Issue - Site nomination dated: TBC		
Checked:	D Fieldhouse			
Approved:	G Thomas			



Hutchison 3G UK Limited
Green Park, 450 Longwater Avenue
Reading, RG30 3UR
Tel: 01628 765 000
Fax: 01628 765 001

H3G Base Station Information line:
0845 6043000
Available 8am-5pm Monday to Friday

Design Consultant & Principal Contractor:

CLARKE
telecom
Unit E, Madison Place, Northampton Road,
Manchester, M40 5AG
Tel: 0161 785 4500 Fax: 0161 785 4501
Web: www.clarke-telecom.com

Site Name: DUKE ROAD

Site ID: ELH25447

Address:
DUKE ROAD
EASTLEIGH
HAMPSHIRE
SO30 0PB

Title: 210 PROPOSED H3G SITE PLAN

Project: H3G DENSIFICATION STREETWORKS

Purpose of Issue: PLANNING

MBNL Cell ID: ELH075
3UK Cell ID: SO0714

Master Drawing No: ELH25447_M001_H3G_DNSW_GA
Issue: A