
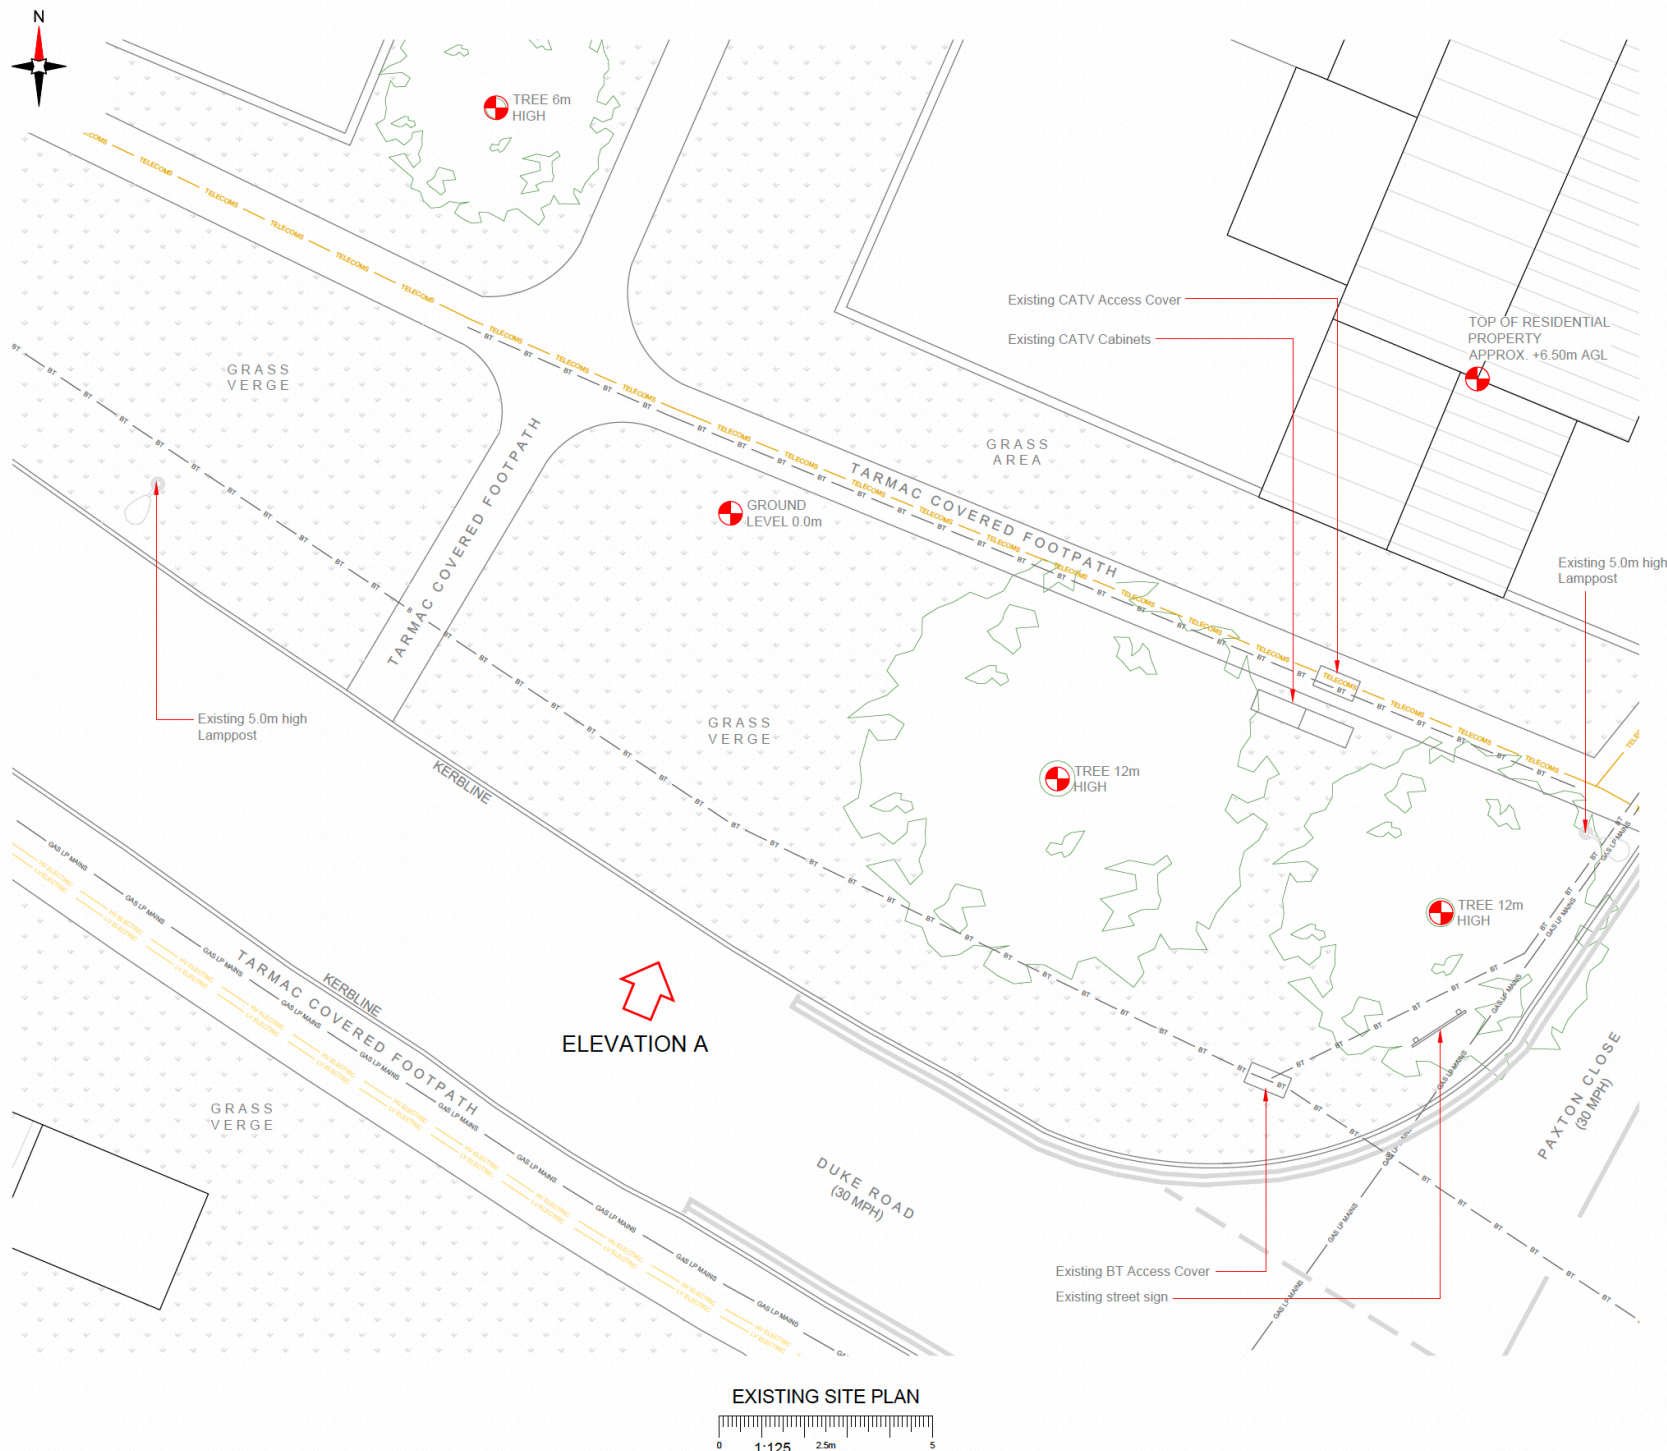


**NOTES:**

1. ALL DIMENSIONS IN MM UNLESS OTHERWISE NOTED.

SERVICES LEGEND

Master: MBNL / EE / H3G:		Project:	Purpose of Issue:	Issue:
M001	H3G	DENSIFICATION SW	Planning	A
Date:	13/10/2022	Revision / Upgrade Description:		
Drawn:	M Niblock	First Issue - Site nomination dated: TBC		
Checked:	D Fieldhouse			
Approved:	G Thomas			

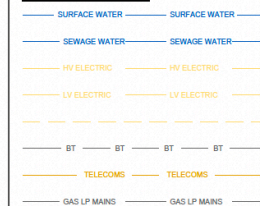

Hutchison 3G UK Limited
Green Park, 450 Longwater Avenue
Reading, RG30 3UR
Tel: 01628 765 000
Fax: 01628 765 001

H3G Base Station Information line:
0845 6043000
Available 8am-8pm Monday to Friday

Design Consultant & Principal Contractor:

CLARKE
telecom
Unit E, Madison Place, Northampton Road,
Manchester, M40 5AG
Tel: 0161 785 4500 Fax: 0161 785 4501
Web: www.clarke-telecom.com

Site Name: **DUKE ROAD**

Site ID: **ELH25447**

Address: **DUKE ROAD
EASTLEIGH
HAMPSHIRE
SO30 0PB**

Title: **100 EXISTING H3G SITE PLAN**

Project: **H3G DENSIFICATION STREETWORKS**

Purpose of Issue: **PLANNING**

MBNL Cell ID: **ELH075** 3UK Cell ID: **SO0714**

Master Drawing No: **ELH25447_M001_H3G_DNSW_GA** Issue: **A**