
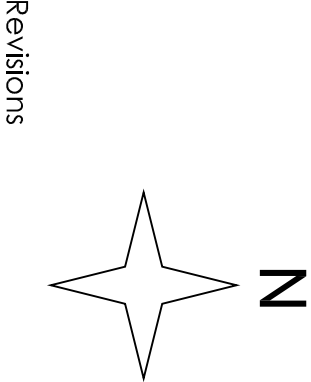


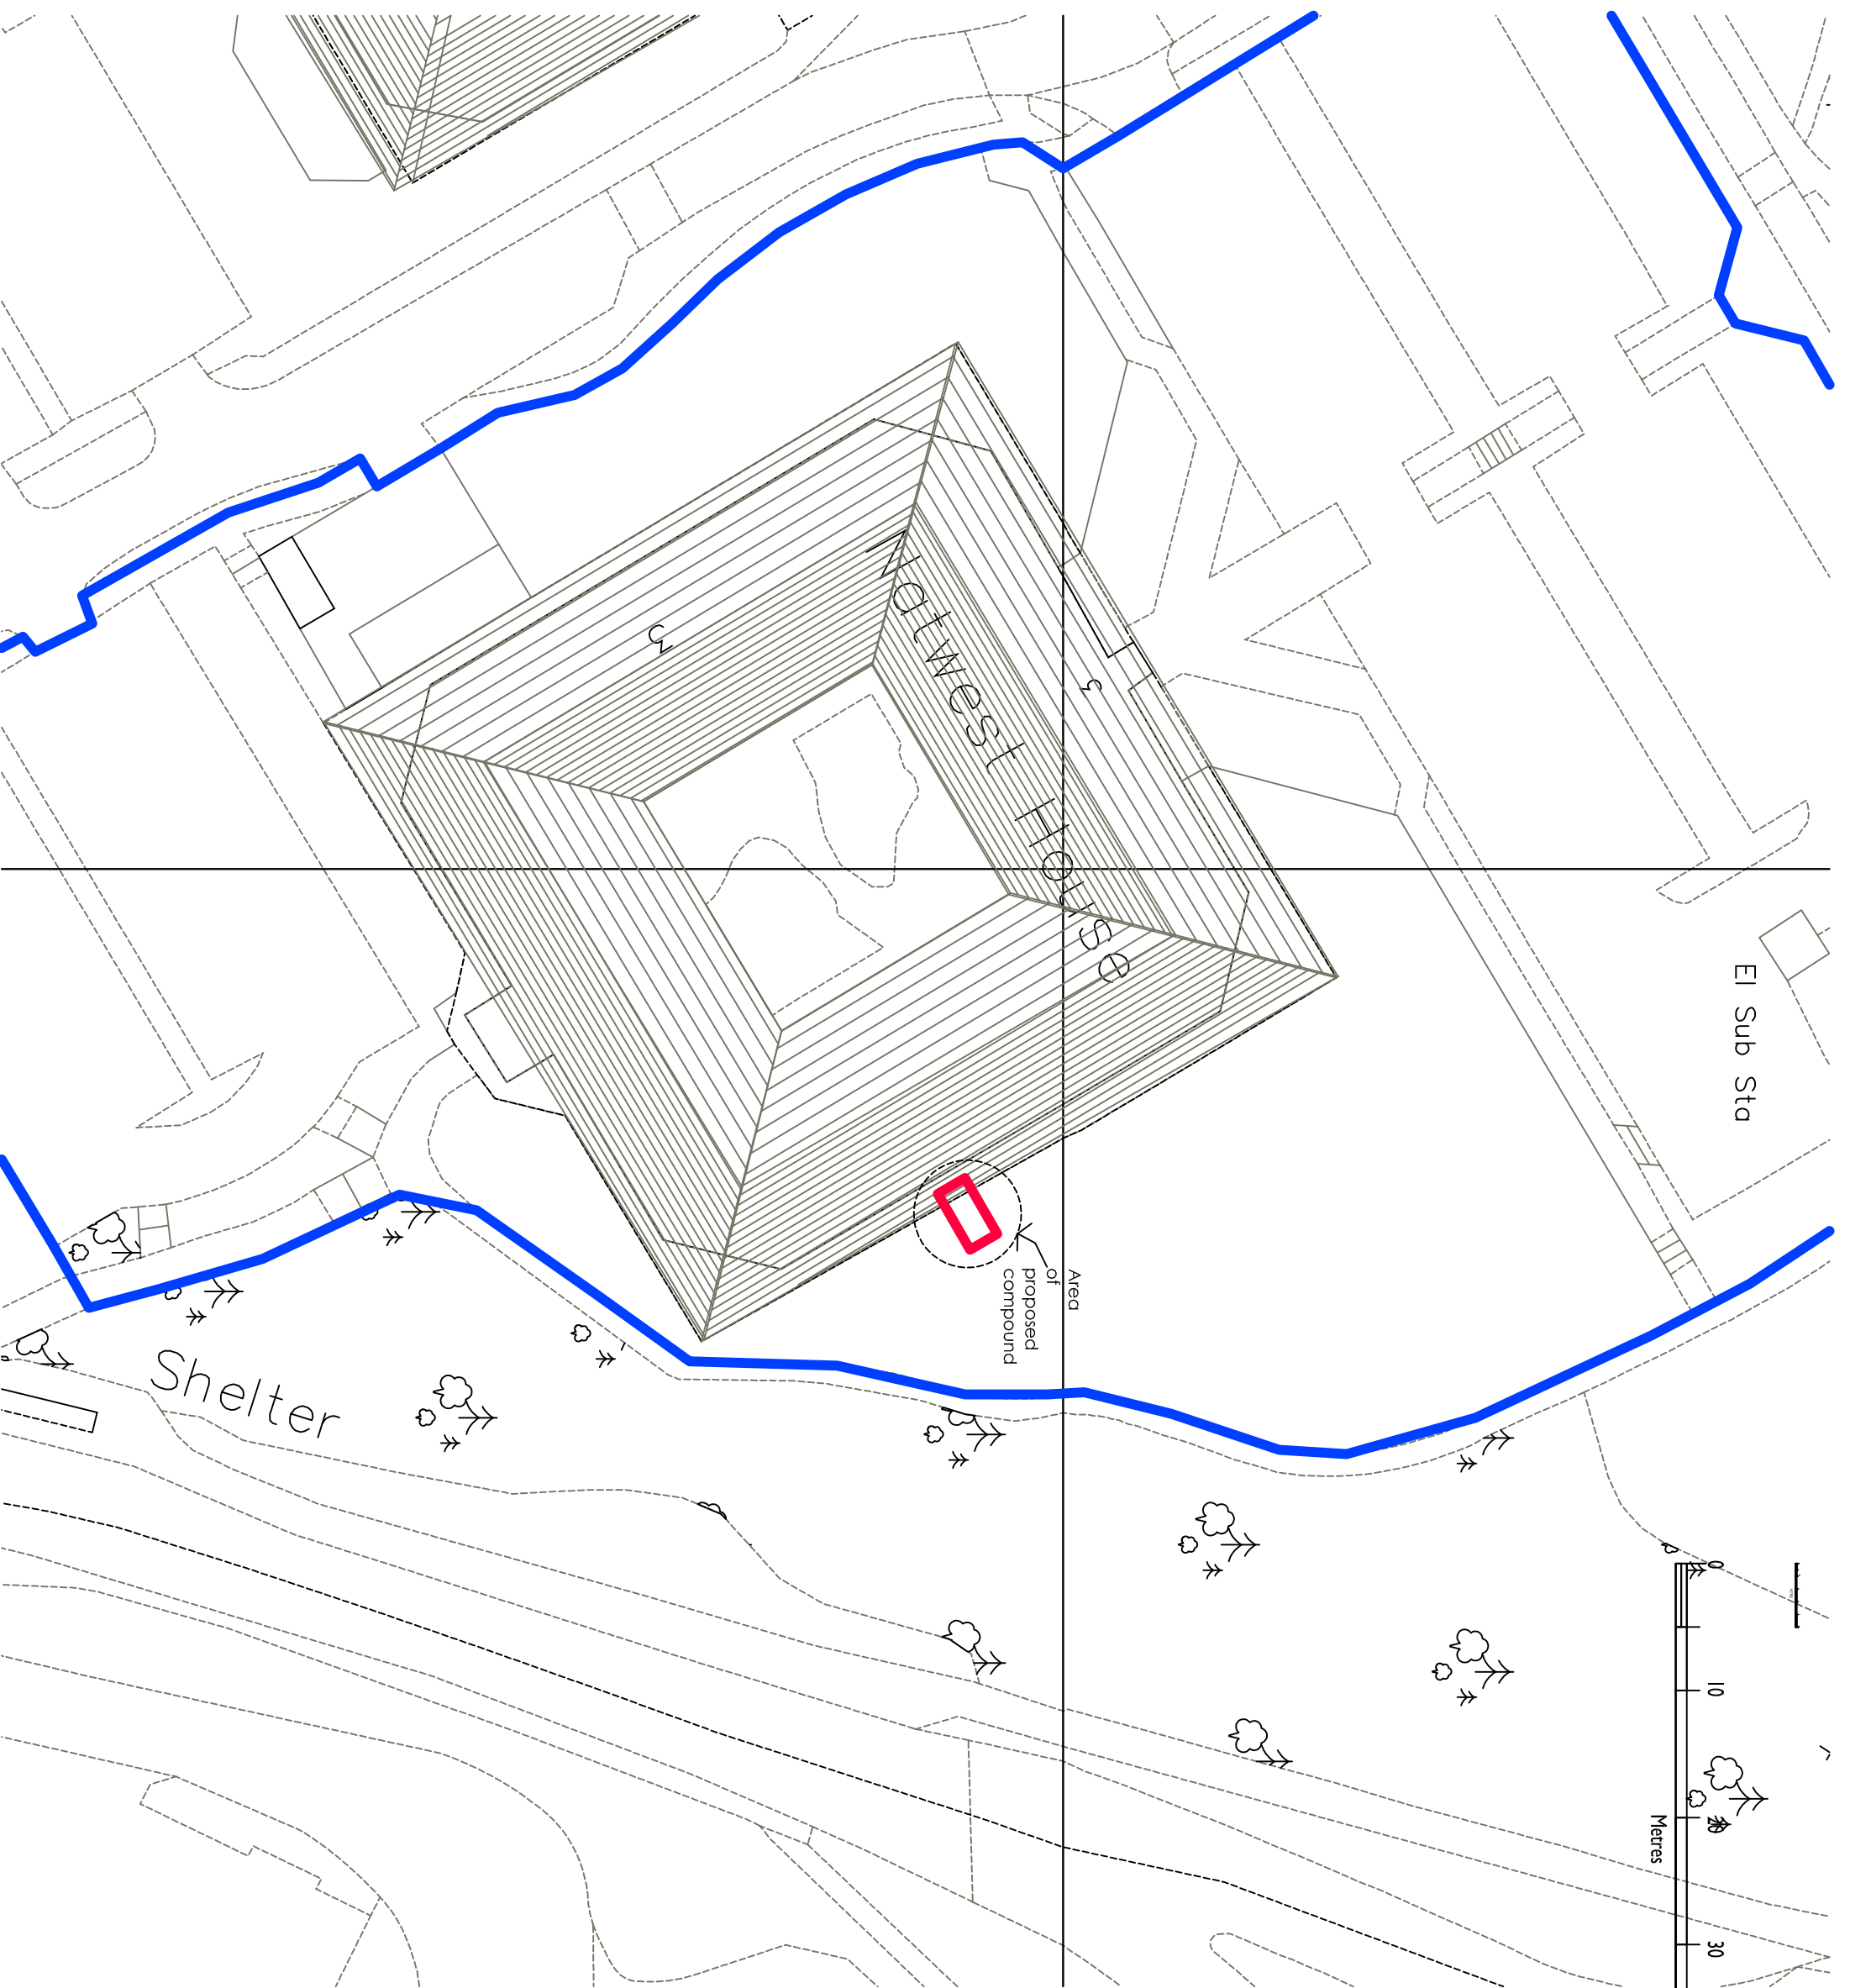

K+HC
KRYPTON HEALTH CONSULTING LTD

THE OLD VICARAGE,
31 CHURCH STREET, FORDHAM,
CAMBRIDGESHIRE. CB7 5NJ

tel 07798 768130 email d.worth@kryptonhc.co.uk

Contract
COMPLETE FERTILITY LTD
IVF FACILITY

Title
HAMPSHIRE HOUSE, EASTLEIGH SO53 3RY
SITE PLAN

Date	Scale
Dec 2022	1 : 200@ A3
Drawing No	J1030 - 501