

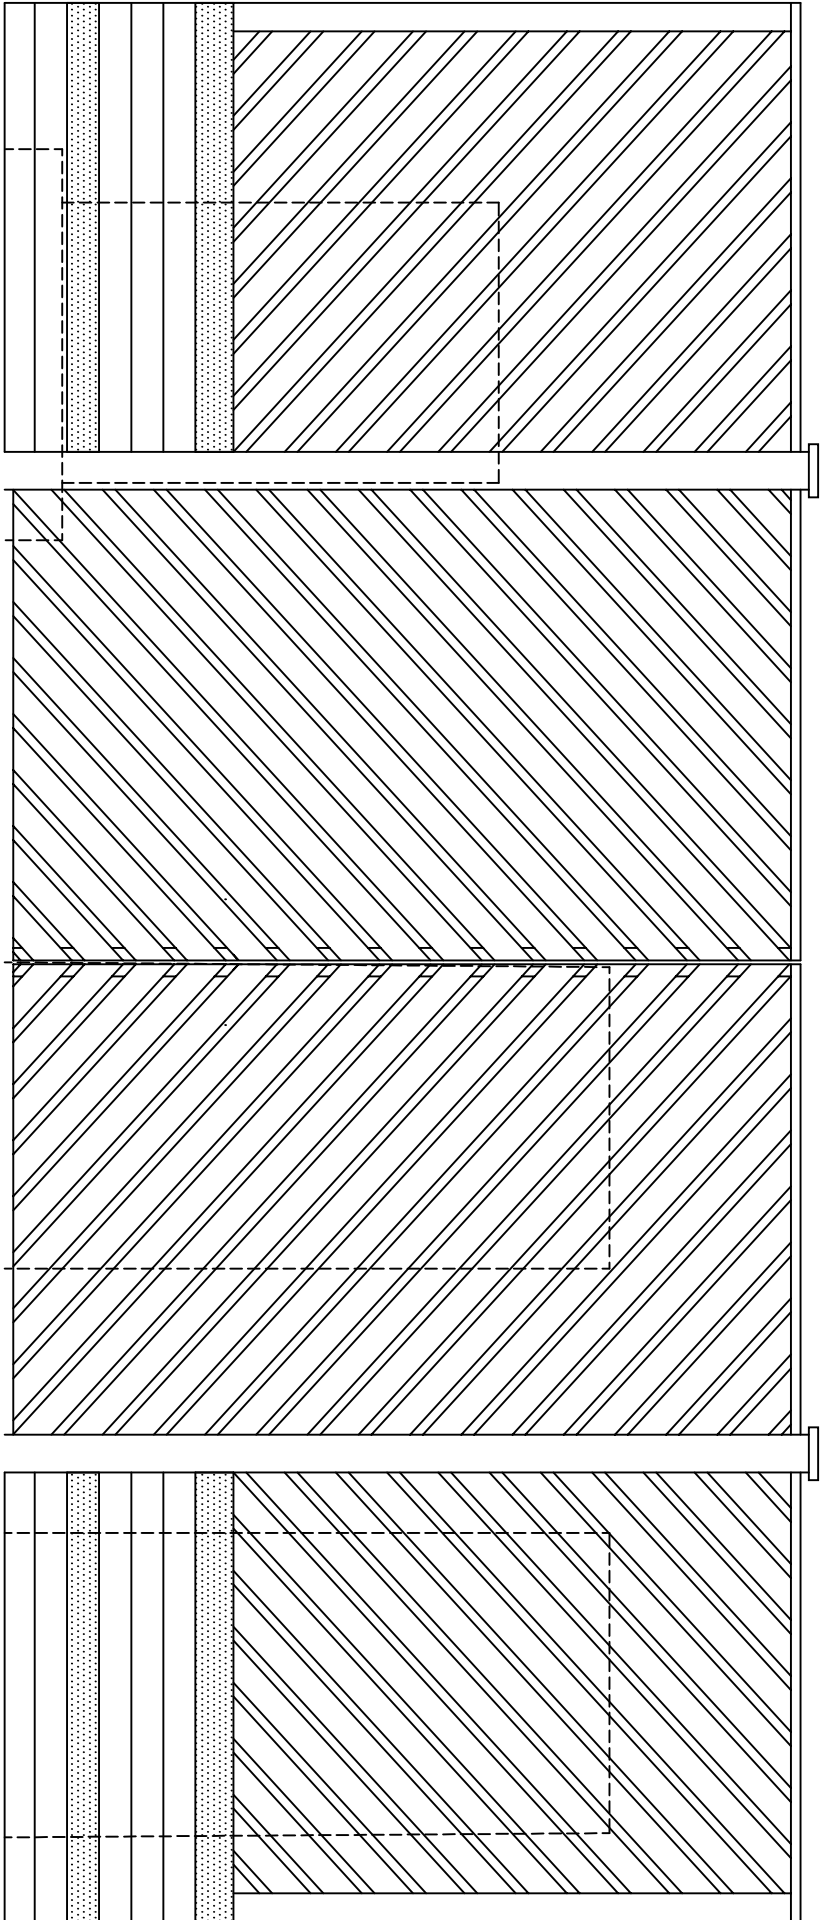


Marine ply service duct
to high level ground floor
all to match existing on opposite
side of building


Diagonal timber fence to match
existing all on timber posts with
matching gates

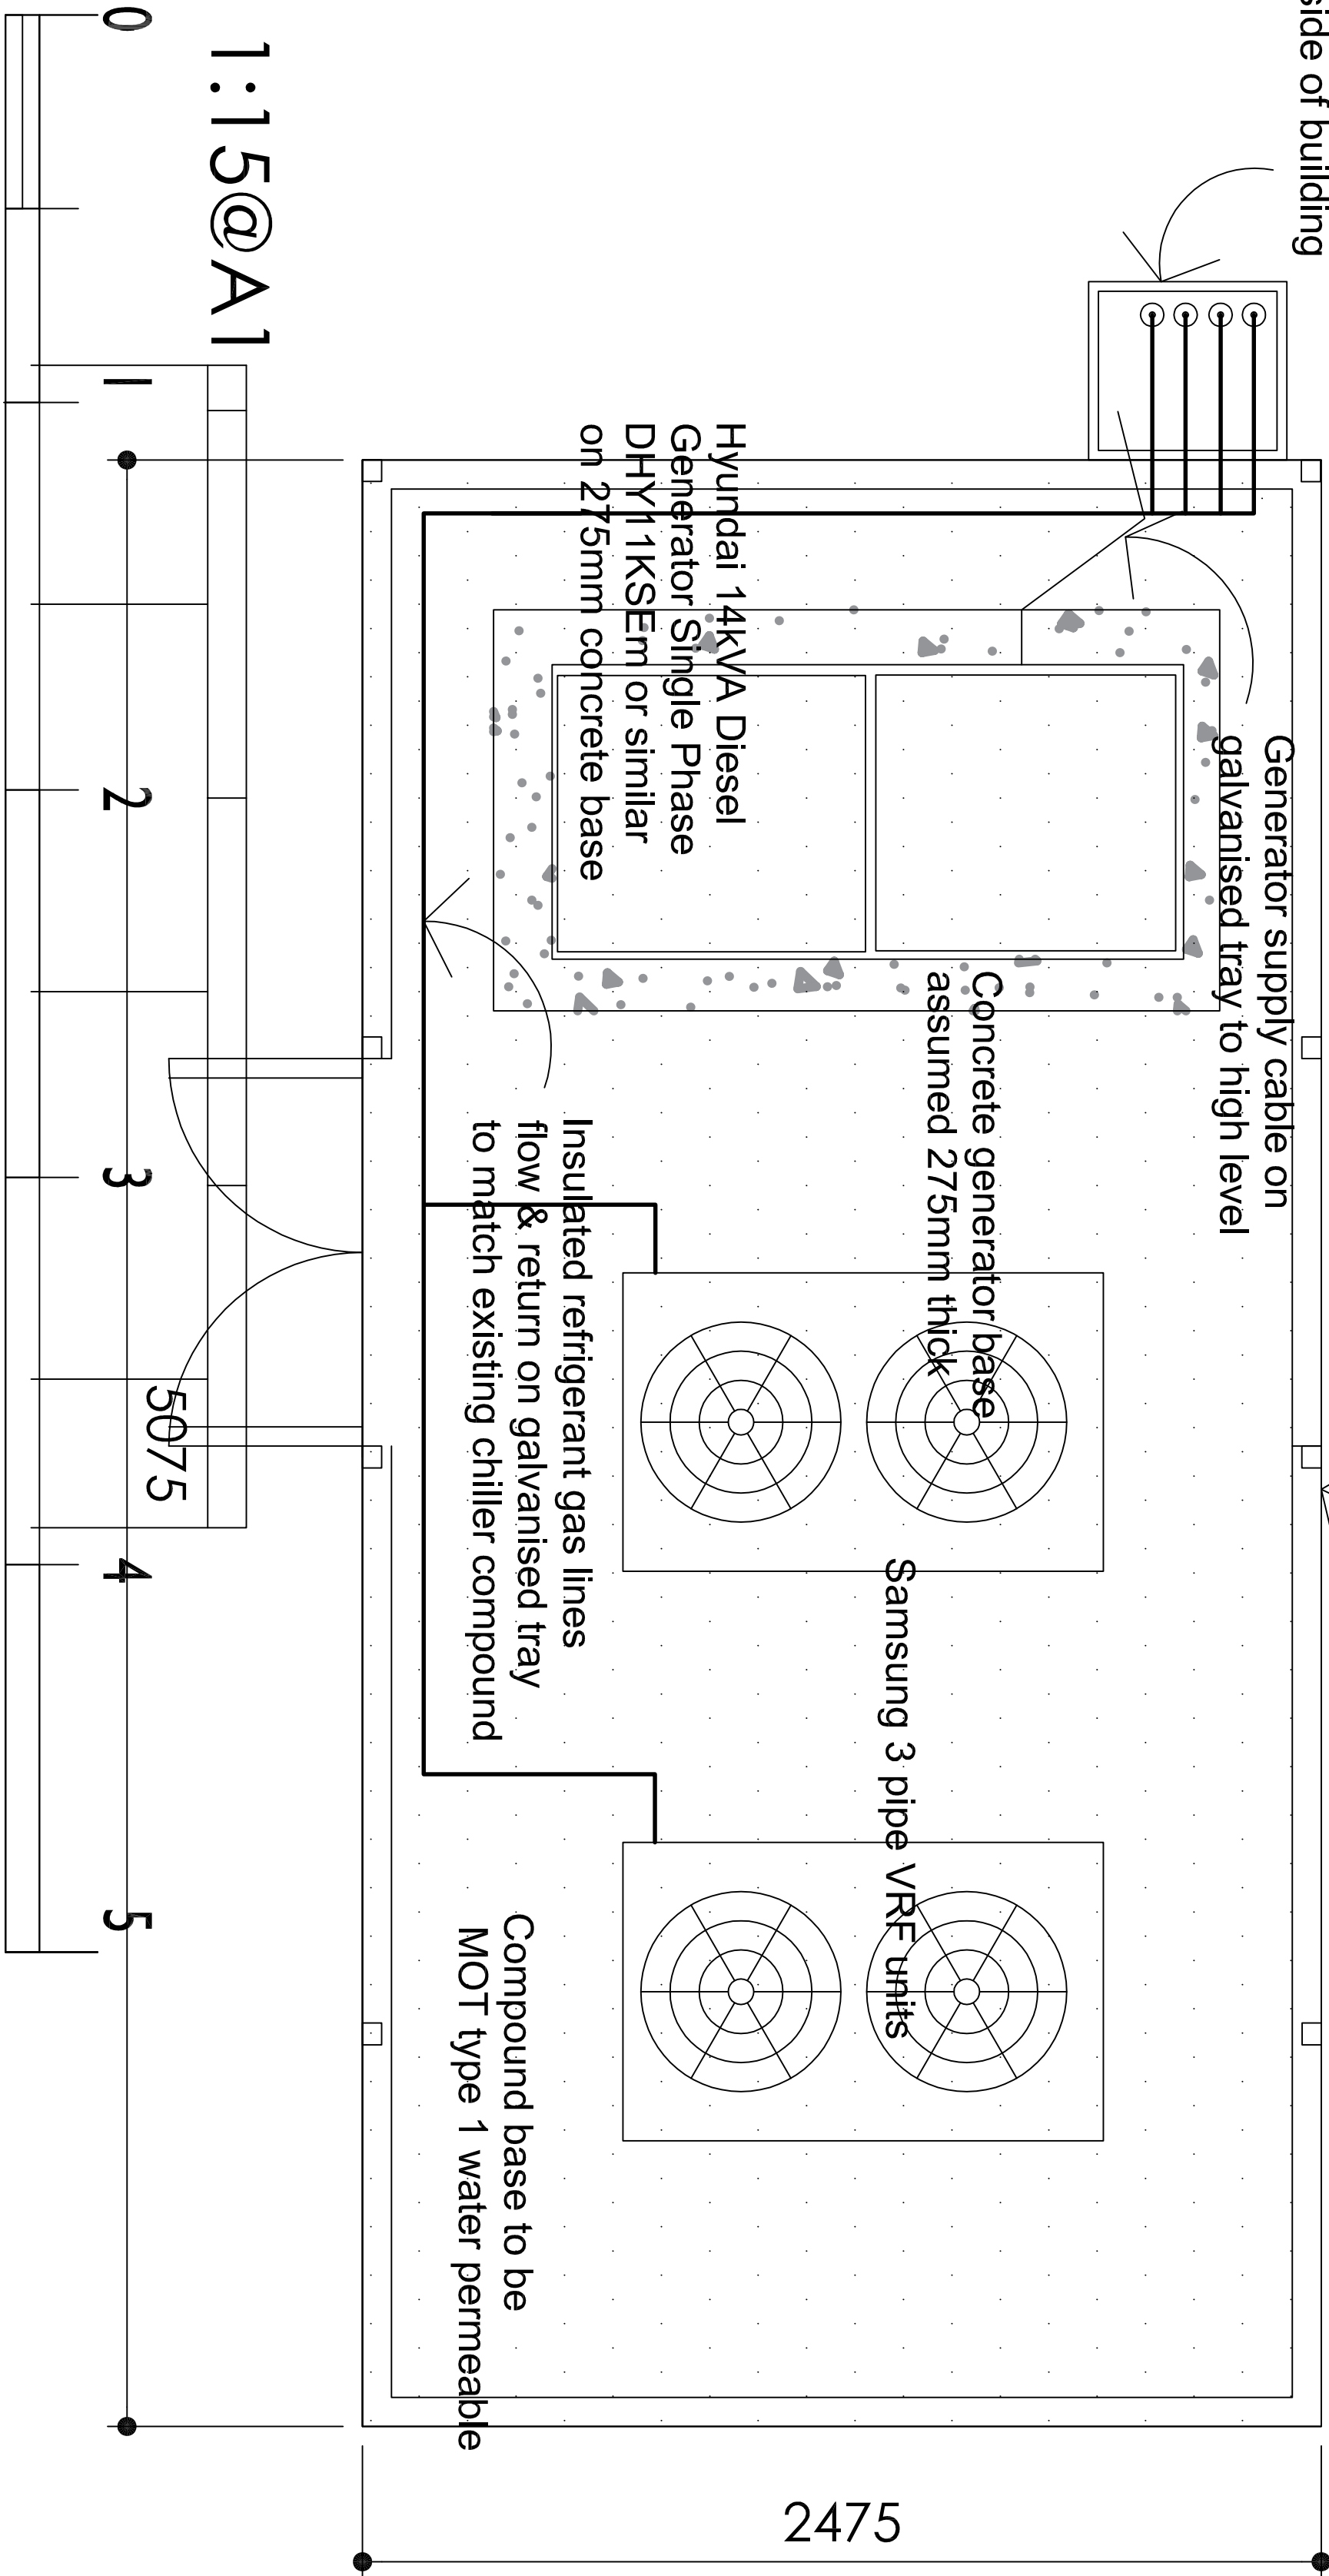


South Elevation

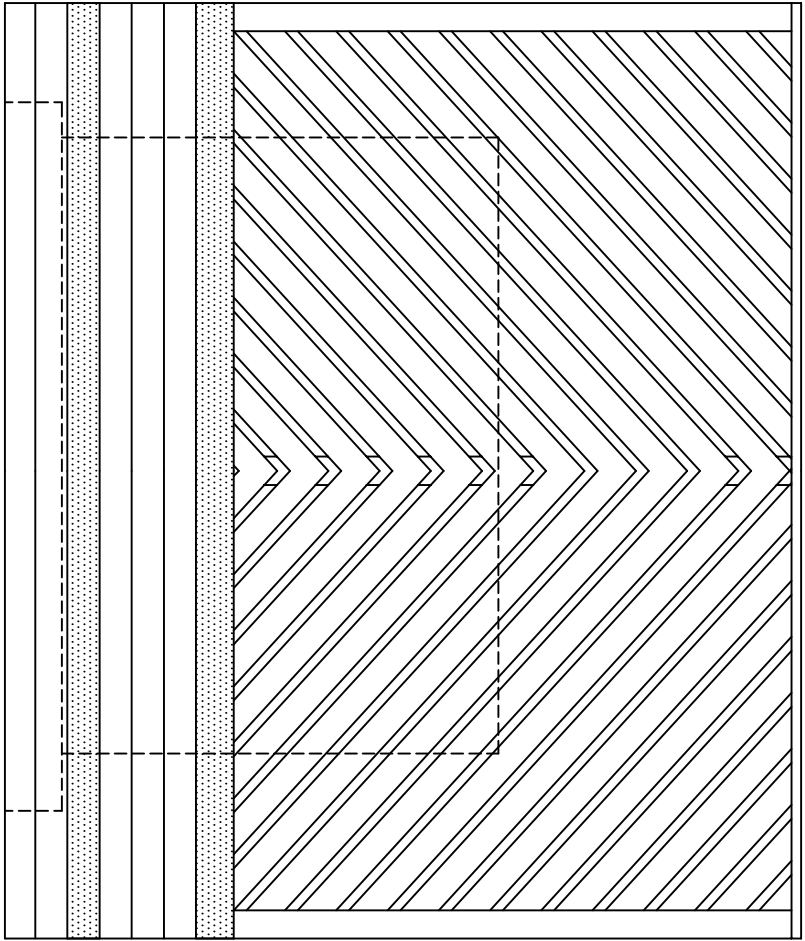

East Elevation

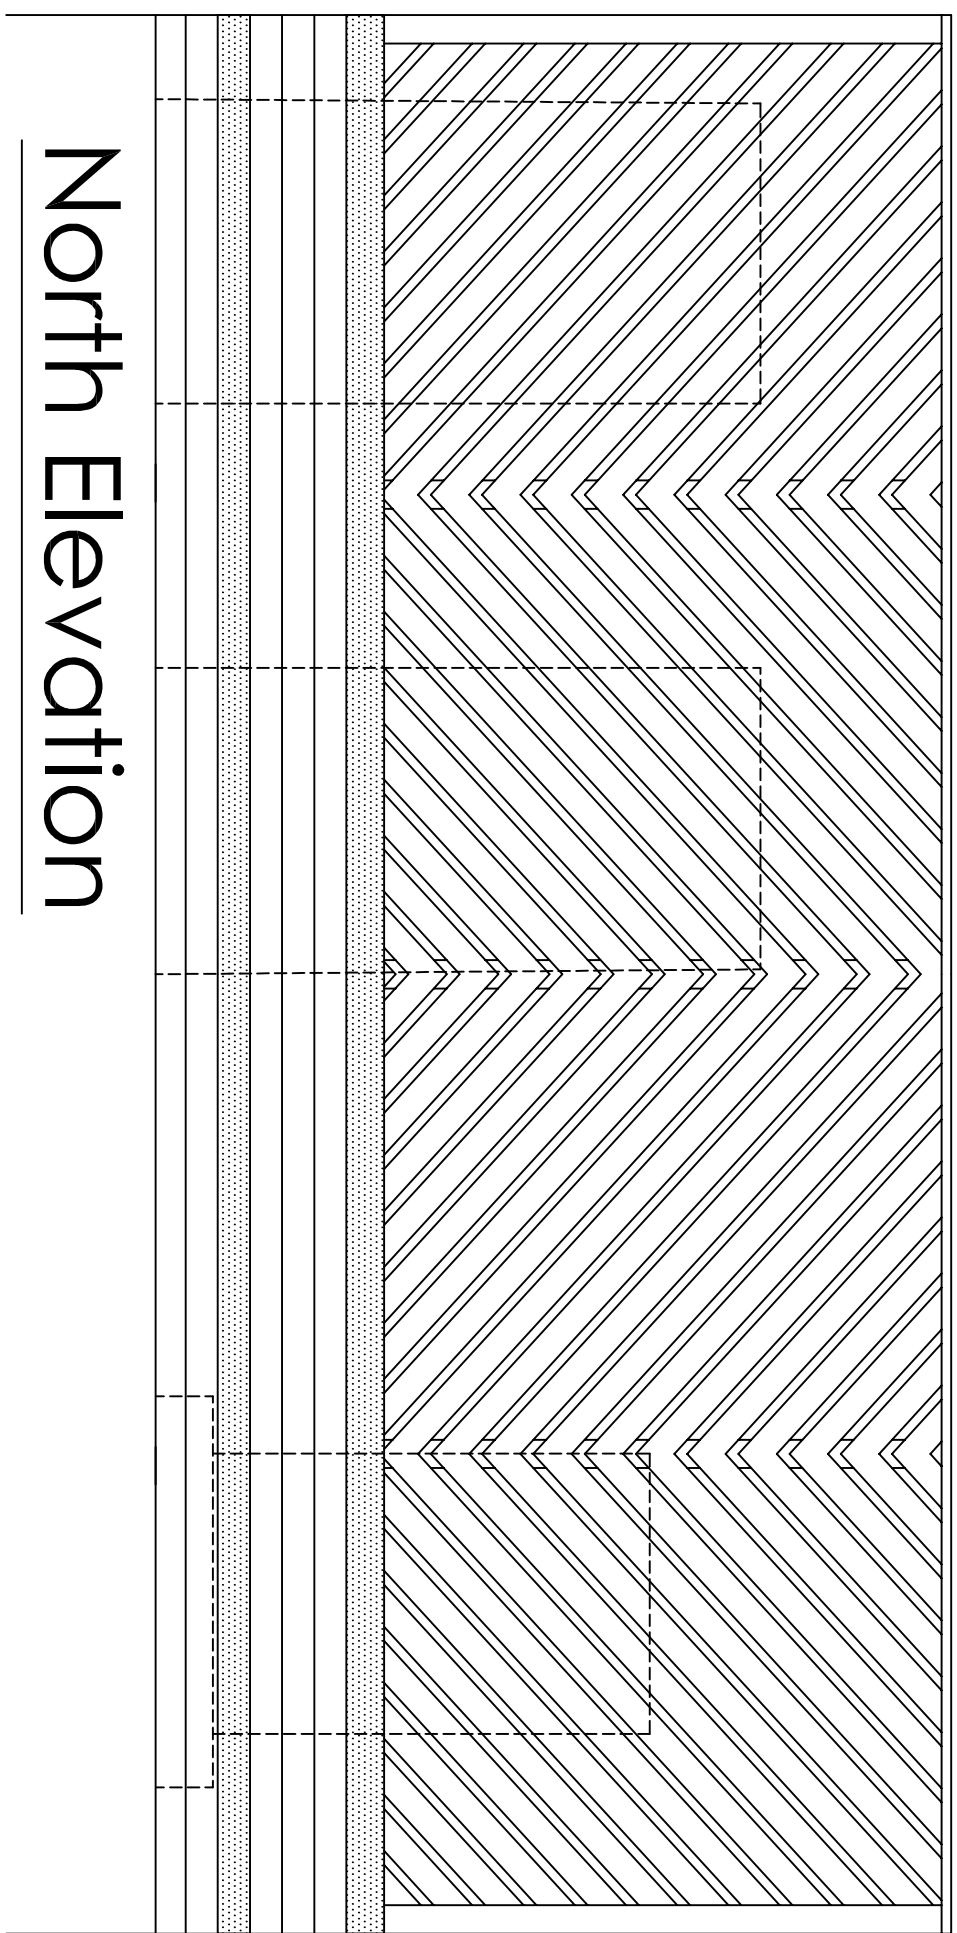

North Elevation

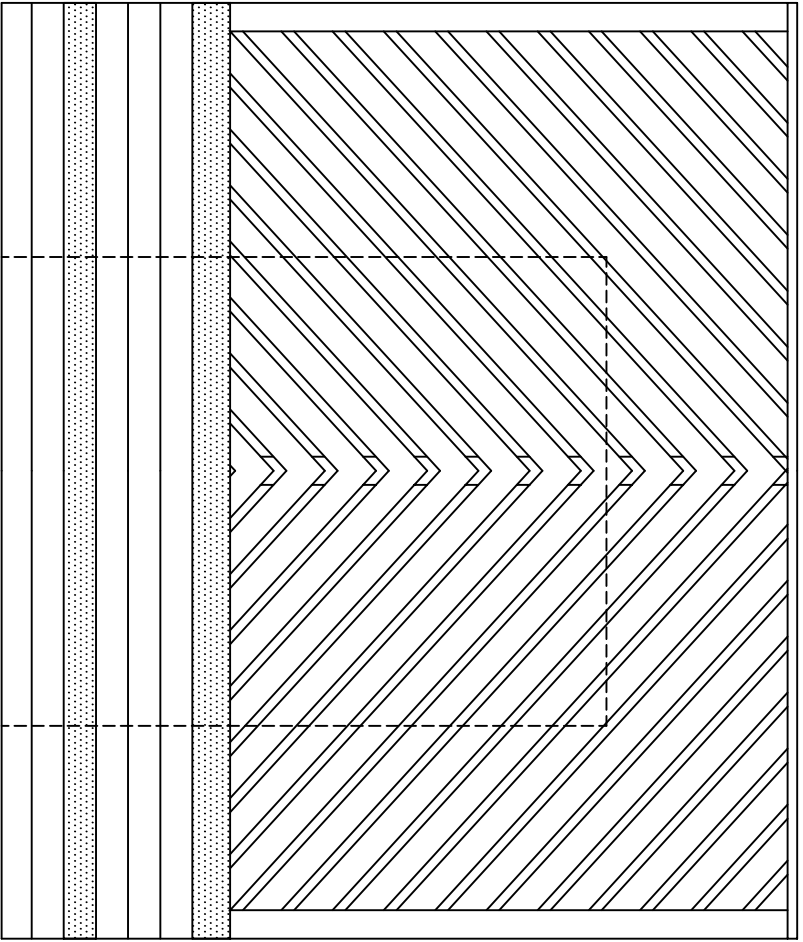

West Elevation



Revisions

- Diesel generating set rated at 13.0KVA (prime) 14.5KVA (standby) @ 0.8pf,
1 phase, 230V, 50Hz 1500RPM.
Powered by KD388, 3 cylinder, water cooled diesel engine directly coupled to a single bearing alternator.
1. Heavy duty folded steel skid type base-frame incorporating anti-vibration mounting pads.
 2. Electric starting system with heavy duty lead acid type starting batteries and battery charging system
 3. High capacity air, fuel and oil filters
 4. Engine Glow plug to aid cold starting
 5. Exhaust silencer
 6. Fuel feed and return lines from engine to base frame fuel tank (65L 11hr)
 7. Automatic engine shutdown protection equipment with LED indicator lights for low oil pressure, high engine temperature.
 8. Automatic main failure control system
 9. Set mounted control panel with flush mounted automatic start control module

75mm wide diagonal; boarding
fixed to timber posts etc
all over faced banded brickwork
all to match existing



KRYPTON HEALTH CONSULTING LTD

THE OLD VICARAGE, 31 CHURCH STREET,
FORDHAM, CAMBRIDGESHIRE. CB7 5NJ

Tel: 01798 768130 Email: info@kryptonhc.co.uk

Contract
COMPLETE FERTILITY LTD
HAMPSHIRE HOUSE, SOUTHAMPTON

Title

GROUND FLOOR
NEW PLANT AREA

Date
Dec 2022

Scale
Verticals @ A1

Drawing No

J1303 - 504