



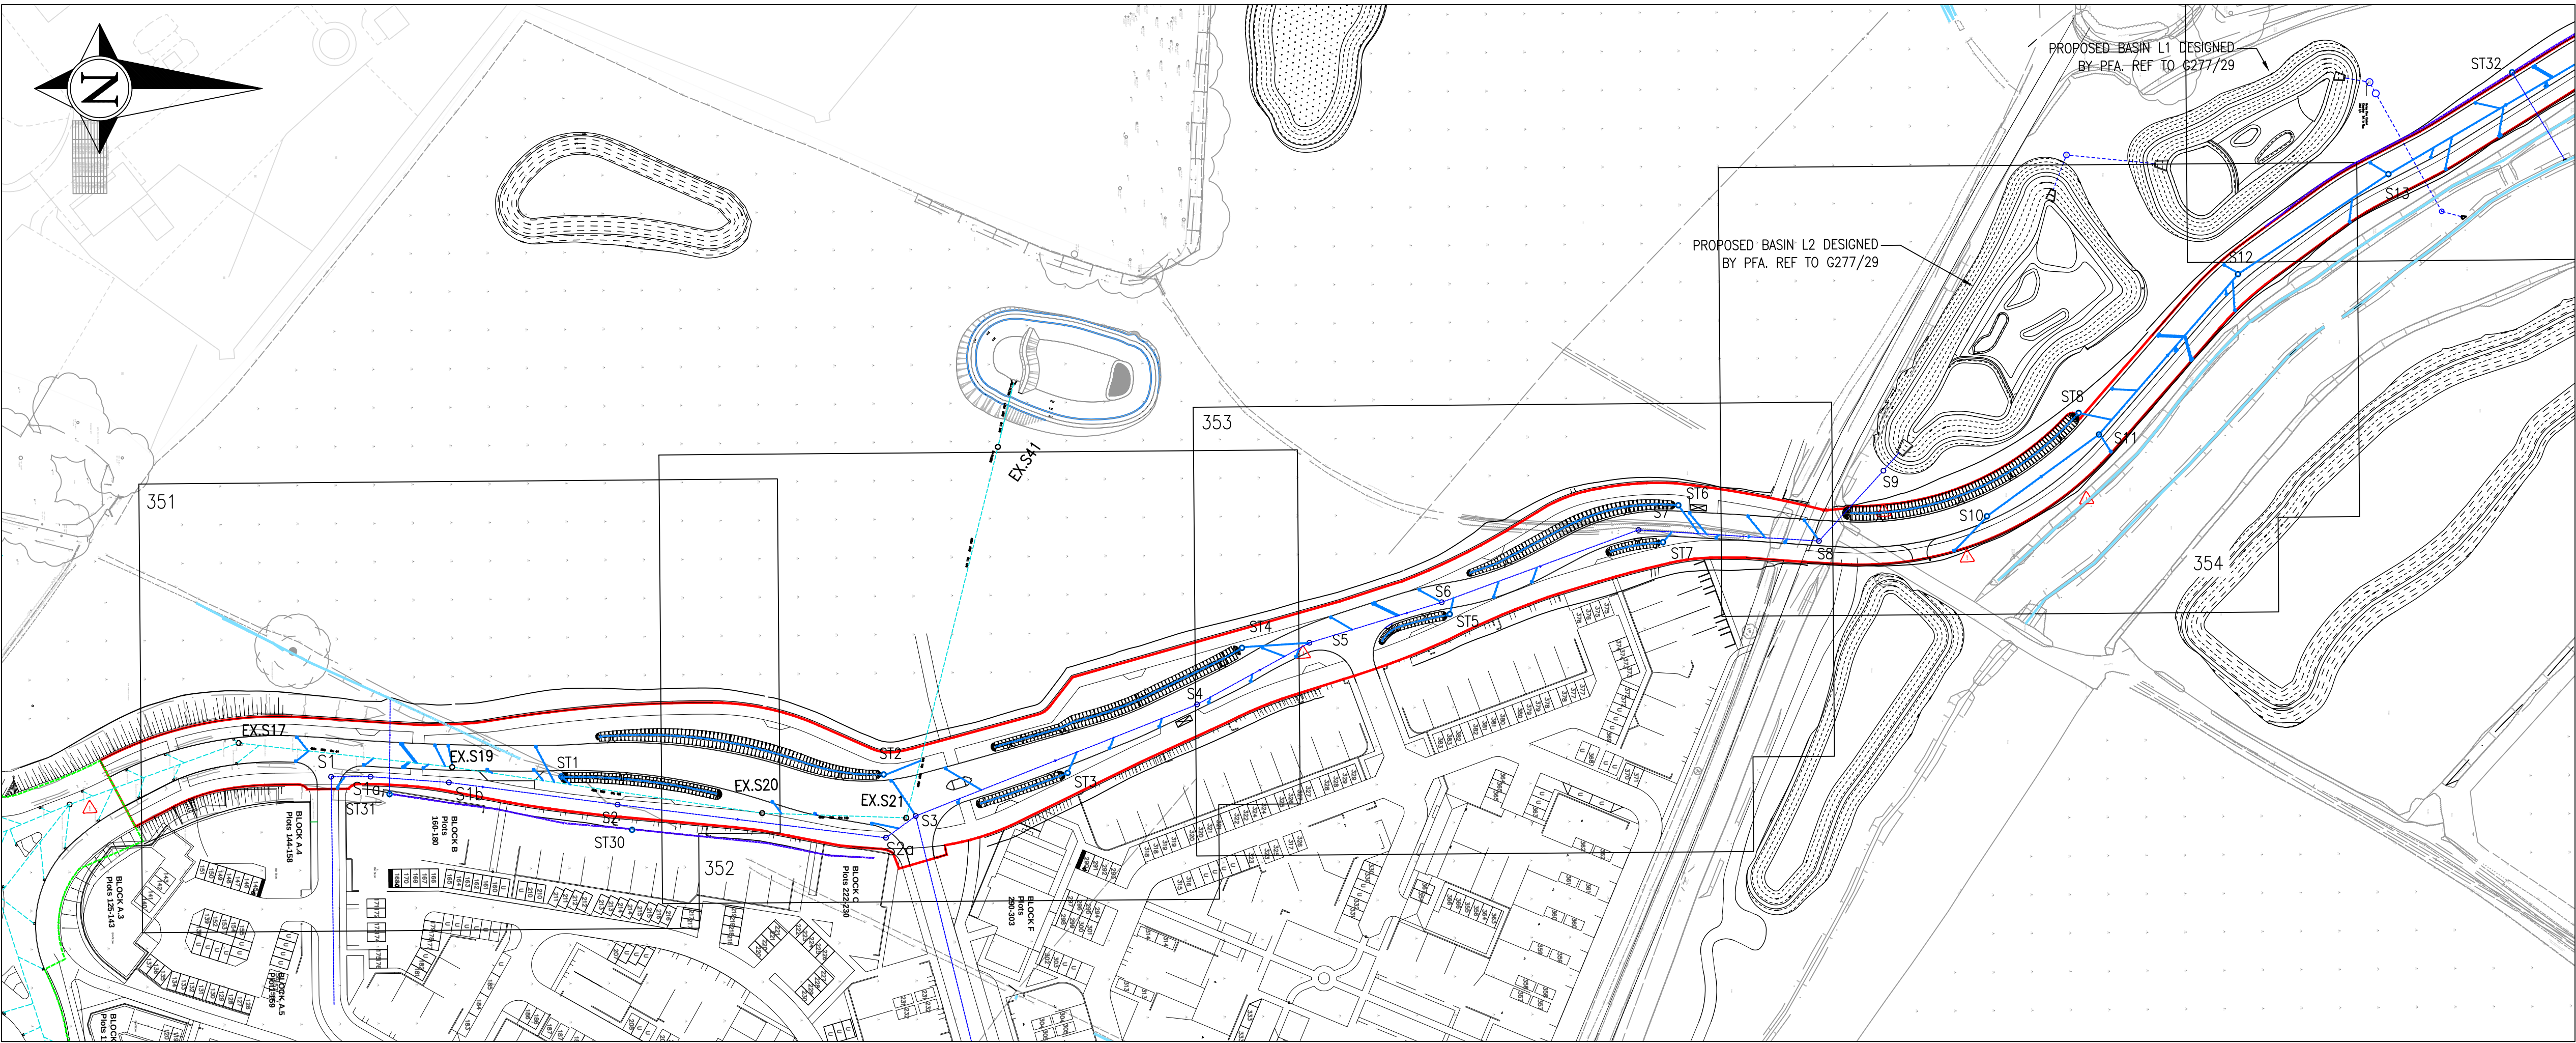

FOR CONTINUATION SEE BELOW

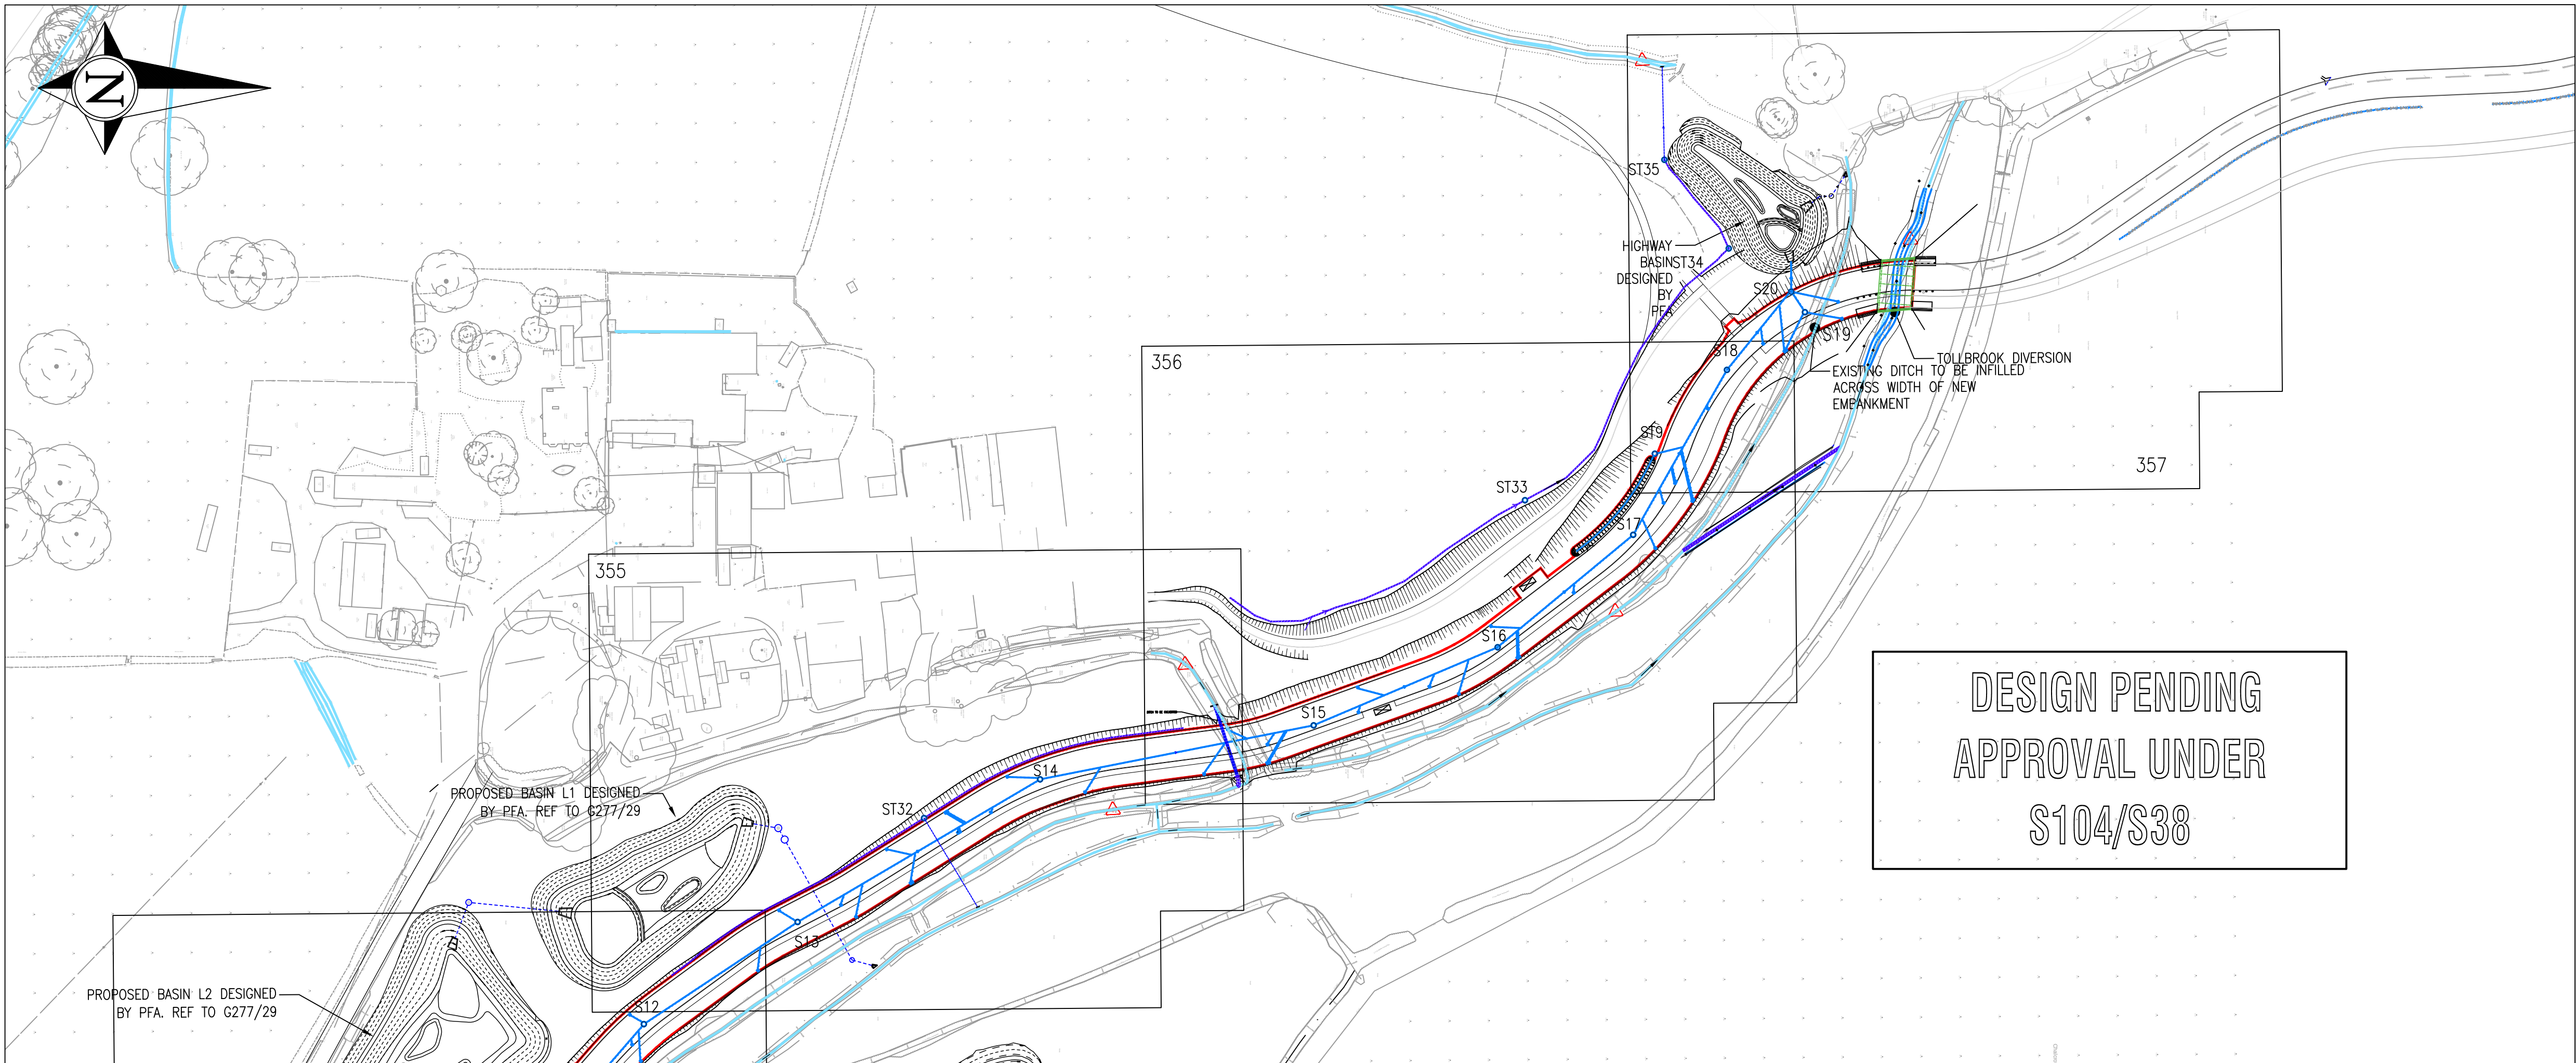

FOR CONTINUATION SEE ABOVE

NOTES

1. THIS DRAWING IS COPYRIGHT.
2. THE CONTRACTOR AND HIS SUBCONTRACTOR ARE TO VERIFY ALL DIMENSIONS ON SITE PRIOR TO MAKING SHOP DRAWINGS OR COMMENCING MANUFACTURE.
3. DO NOT SCALE THIS DRAWING. THE CONTRACTOR IS TO BRING TO THE NOTICE OF THE ENGINEER ANY DISCREPANCIES CONTAINED IN THIS DRAWING PRIOR TO WORK COMMENCEMENT.
4. ALL 150mm AND 225mm DIAMETER PIPES TO BE EXTRA STRENGTH VITRIFIED CLAY PIPES (SEE NOTE 15).
5. ALL PIPES OF 300mm DIAMETER OR GREATER TO BE CLASS M CONCRETE.
6. ALL PIPE MATERIALS TO BE CONSISTENT BETWEEN MANHOLES.
7. ALL WORK IS TO BE CARRIED OUT IN ACCORDANCE WITH DESIGN AND CONSTRUCTION GUIDANCE(DCG)/SEWER FOR ADOPTION 7TH, HAMPSHIRE COUNTY COUNCIL STANDARDS (FOR HIGHWAY DRAINAGE ONLY) AND THE SPECIFICATION FOR HIGHWAY WORKS 1998 AND ALL SUBSEQUENT AMENDMENTS. WHERE THERE IS CONFLICT BETWEEN THESE DOCUMENTS THE MATTER SHALL BE REFERRED TO THE ENGINEER.
8. FOR CONSTRUCTION DETAILS OF MANHOLES AND SEWERS REFER TO DESIGN AND CONSTRUCTION GUIDANCE/SEWERS FOR ADOPTION 7TH, HCC STANDARD DETAILS(FOR SEWERS ADOPTED BY HCC HIGHWAYS) AND
9. UNDERTAKERS STANDARD DETAILS WHICH CAN BE OBTAINED FROM THE LOCAL OFFICE FOR SEWERS ADOPTED BY SOUTHERN WATER
10. INVERT LEVELS OF EXISTING SEWERS TO BE CONFIRMED ON SITE BEFORE ANY SEWER WORK UNDERTAKEN. ANY DISCREPANCIES FOUND SHOULD BE NOTIFIED TO ENGINEERS.
11. WHERE SEWERS HAVE LESS THAN 1.2m OF COVER UNDER ROADS AND 0.9m COVER ELSEWHERE PIPES ARE TO HAVE A 150mm CONCRETE BED AND SURROUND.
12. PLASTIC CHAMBERS AND RINGS SHALL COMPLY WITH BS EN 13598-1 AND BS EN 13598-2 OR HAVE EQUIVALENT INDEPENDENT APPROVAL TO TABLE 11 OF APPROVED DOCUMENT H1 OF THE BUILDING REGULATIONS 2010.
13. ALL BELOW GROUND DRAINAGE TO BE 150mmØ UNLESS OTHERWISE INDICATED WITH A MIN. GRADIENT AS FOLLOWS:-

S.W : 150mm Dia. 1:150
14. ALL ADAPTABLE DRAINAGE MATERIALS SHOULD COMPLY WITH THE REQUIREMENTS OF PART E CIVIL ENGINEERING SPECIFICATION INCLUDED WITH CGD/SEWERS FOR ADOPTION 7TH EDITION WHICH IS DRAWN FROM CESWI 7TH EDITION BUT IS NOT A FULL REPRODUCTION AND OR HAMPSHIRE COUNTY COUNCIL REQUIREMENTS.
15. JETTING OF NEW DRAINAGE RUNS MUST BE CARRIED OUT AT END OF CONTRACT, IN ORDER TO ENSURE ALL NEW PIPE-WORK IS FREE OF DEBRIS AND FREE RUNNING

HEALTH & SAFETY:

ALL WORKS TO BE CARRIED OUT BY A CONTRACTOR COMPETENT TO UNDERTAKE THE CONSTRUCTION OF WORKS AS INDICATED ON THIS DRAWING. THIS DRAWING IS TO BE READ IN CONJUNCTION WITH THE JOB SPECIFIC RISK ASSESSMENT. THE HAZARDS NOTED ARE IN ADDITION TO THE NORMAL HAZARDS AND RISKS FACED BY A COMPETENT CONTRACTOR WHEN DEALING WITH THE TYPE OF WORKS DETAILED ON THIS DRAWING.

T2	EBC COMMENTS. SURFACE WATER RUN BETWEEN S1 AND S3 AMENDED	05/10/22	PN		
T1	TENDER ISSUE. S38 COMMENTS	16/09/22	PN		
Rev.	Description	Date	Initial		
Drawing Status:	TENDER				
RS REUBY & STAGG LTD.					
CONSULTING CIVIL & STRUCTURAL ENGINEERS					
Dewey House 55 High Street, Ringwood Hampshire BH24 1AE T: 01425 484400 F: 01425 484409 Email: admin@reuby-stagg.co.uk					
ONE HORTON HEATH					
Eastleigh Borough Council Eastleigh House Upper Market Street Eastleigh SO50 9YN www.eastleigh.gov.uk					
Site:	ONE HORTON HEATH				
Address:	SEGMENT 3				
Org Title:	OVERALL DRAINAGE LAYOUT "THE AVENUE" SOUTHERN SECTION				
Scale:	1:2000	Page Size:	A1		
Drawn:	JP	Checked:	PN		
Date:	DEC 20	Revision:			
Drawing No:	10413-SEG3-350				
	T2				