


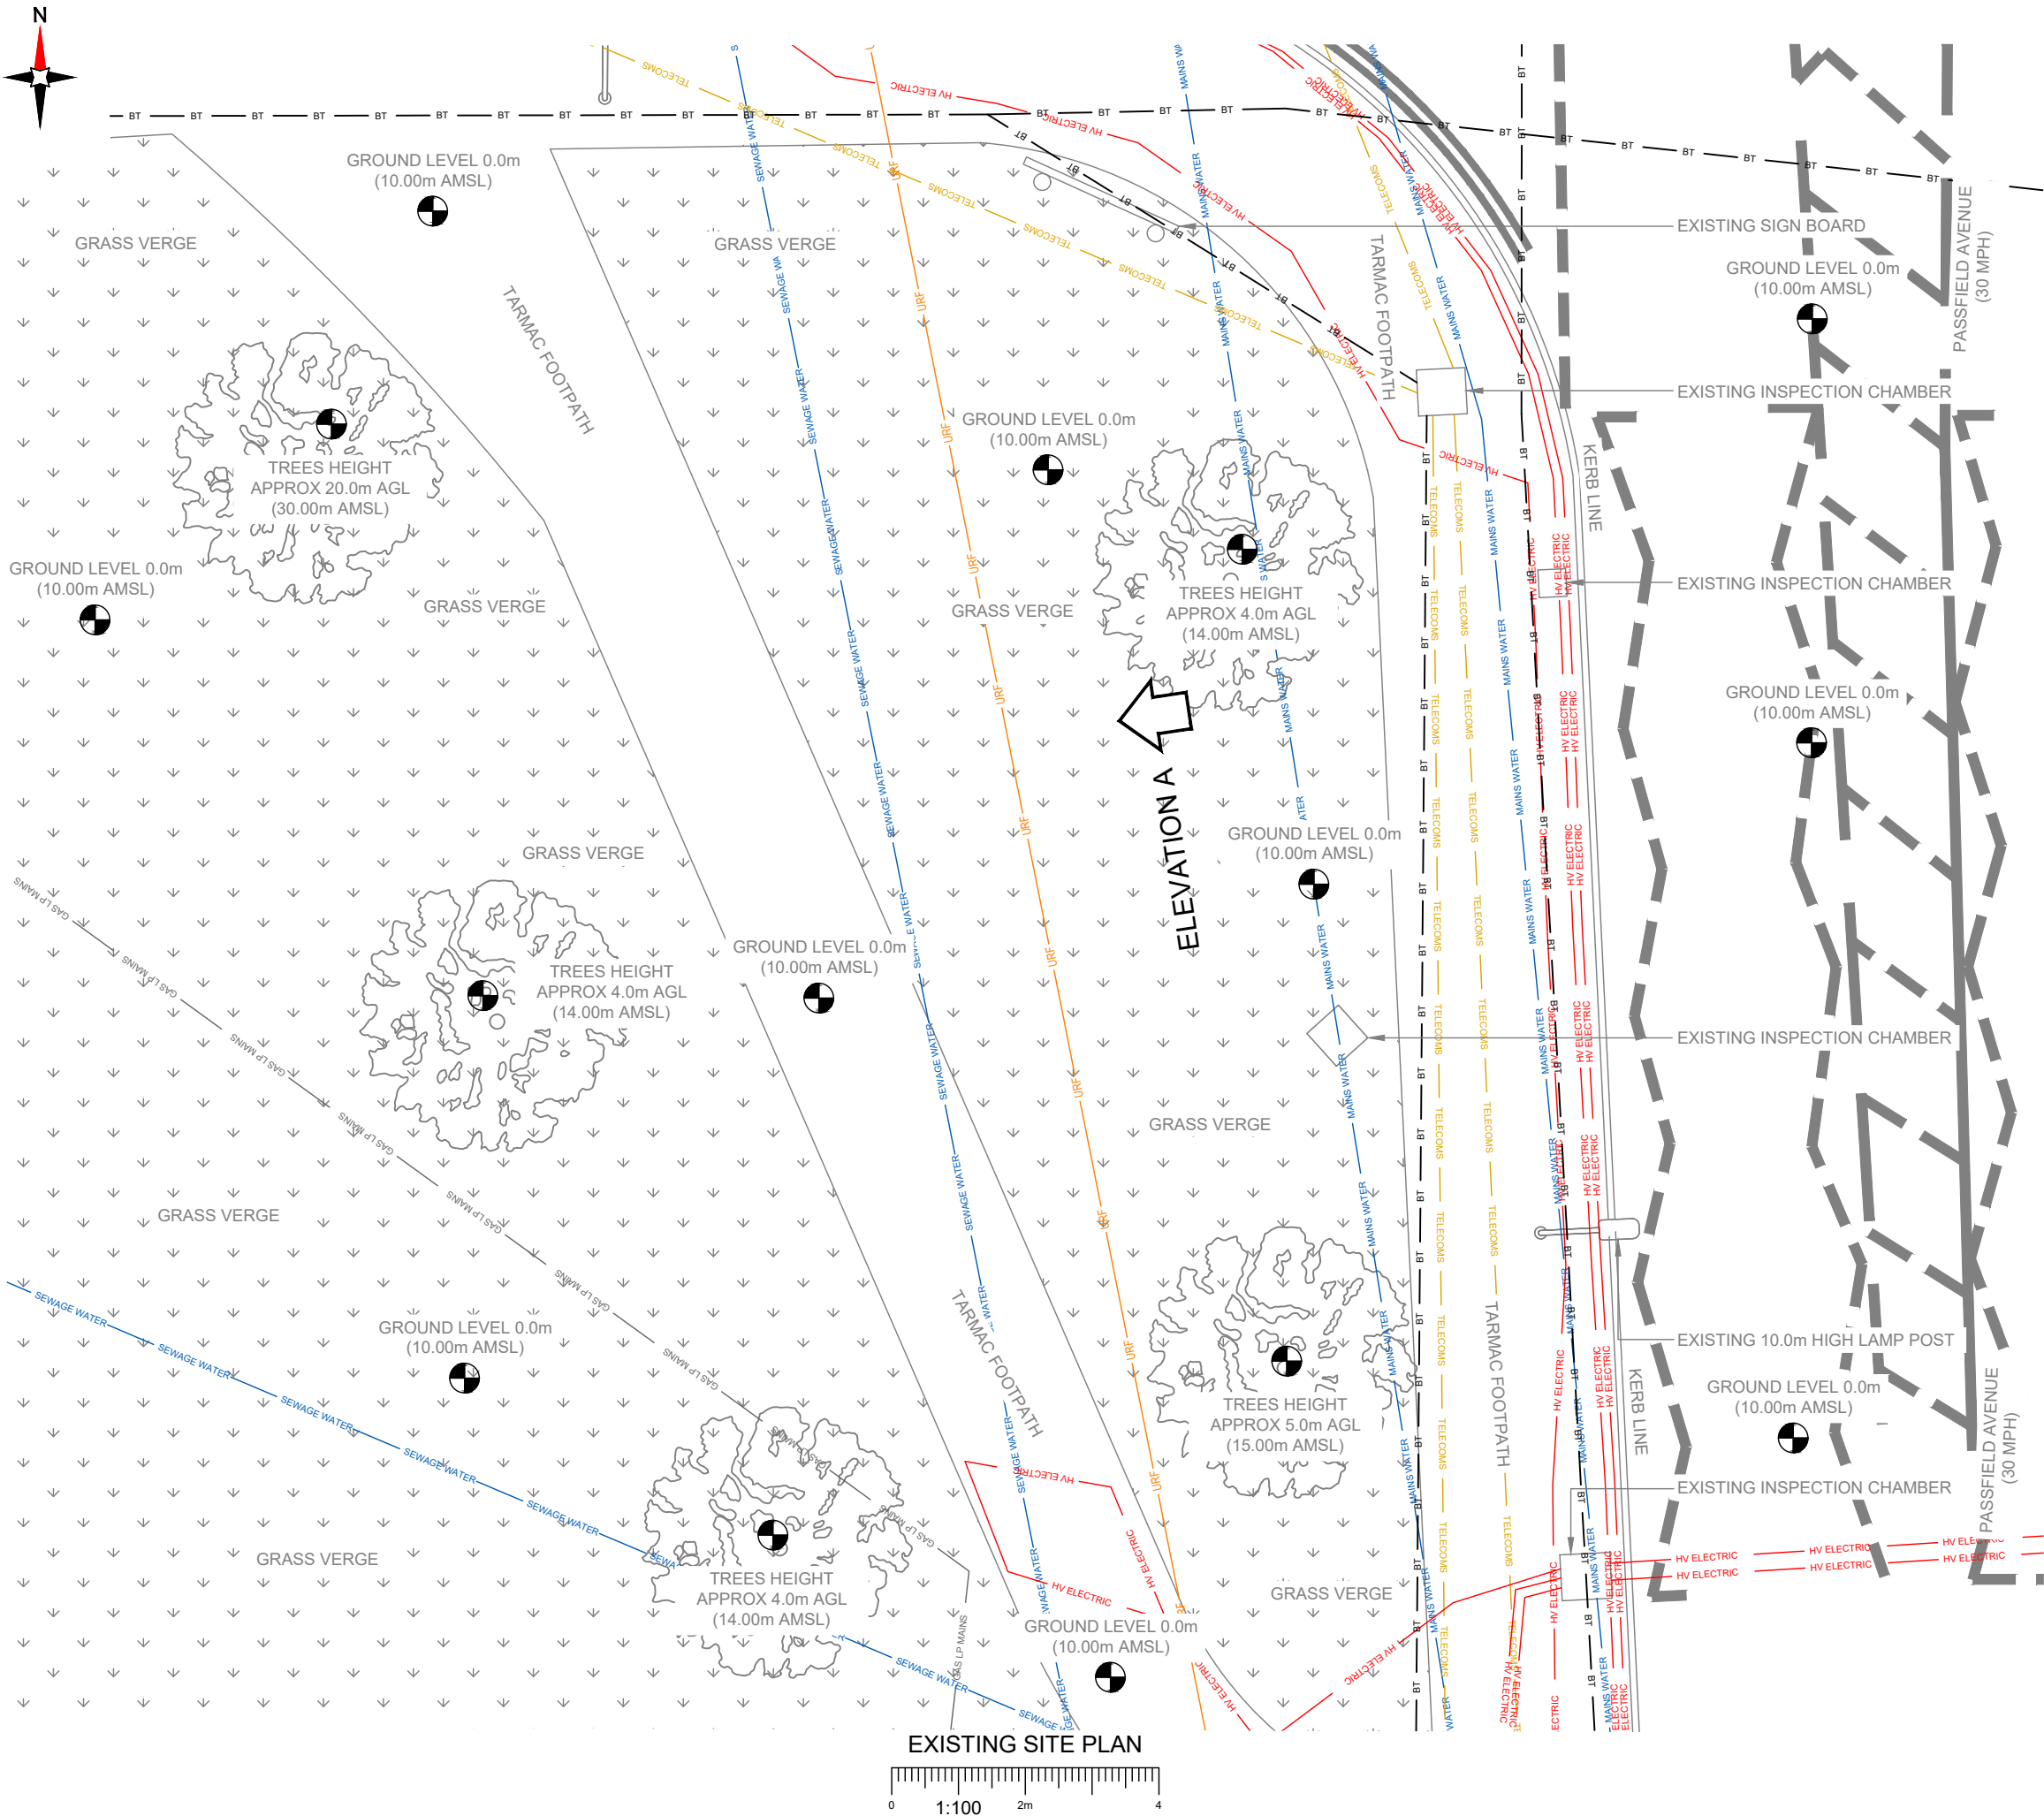

NOTES:

1. ALL DIMENSIONS IN MM UNLESS OTHERWISE NOTED.

SERVICES:

- HV ELECTRIC
- LV ELECTRIC
- ELECTRIC
- GAS LP MAINS
- MAINS WATER
- SEWAGE WATER
- TELECOMS
- GPR

Master:	MBNL / EE / H3G:	Project:	Purpose of Issue:	Issue:
M001	H3G	DENSIFICATION SW	Planning	A
Date:	06/04/2023	Revision / Upgrade Description:		
Drawn:	M.Bagya	First Issue		
Checked:	R.Brown			
Approved:	R.Brown			



Hutchison 3G UK Limited
 Green Park, 450 Longwater Avenue
 Reading, RG30 3UR
 Tel: 01628 765 000
 Fax: 01628 765 001

H3G Base Station Information line:
 0845 6043000
 Available 8am-8pm Monday to Friday

Design Consultant & Principal Contractor:

CLARKE telecom

Unit E, Madison Place, Northampton Road,
 Manchester, M40 5AG
 Tel: 0161 785 4500 Fax: 0161 785 4501
 Web: www.clarke-telecom.com

Site Name:	PASSFIELD AVENUE		
Site ID:	ELH26940		
Address:	PASSFIELD AVENUE HAMPSHIRE EASTLEIGH SO50 9PY		
Title:	100 EXISTING SITE PLAN		
Project:	H3G DENSIFICATION STREETWORKS		
Purpose of Issue:	PLANNING		
	MBNL Cell ID:	3UK Cell ID:	
	N/A	N/A	
Master Drawing No:	ELH26940_NA_NA_M001_H3G_DNSW_GA_A		Issue:
			A