
 


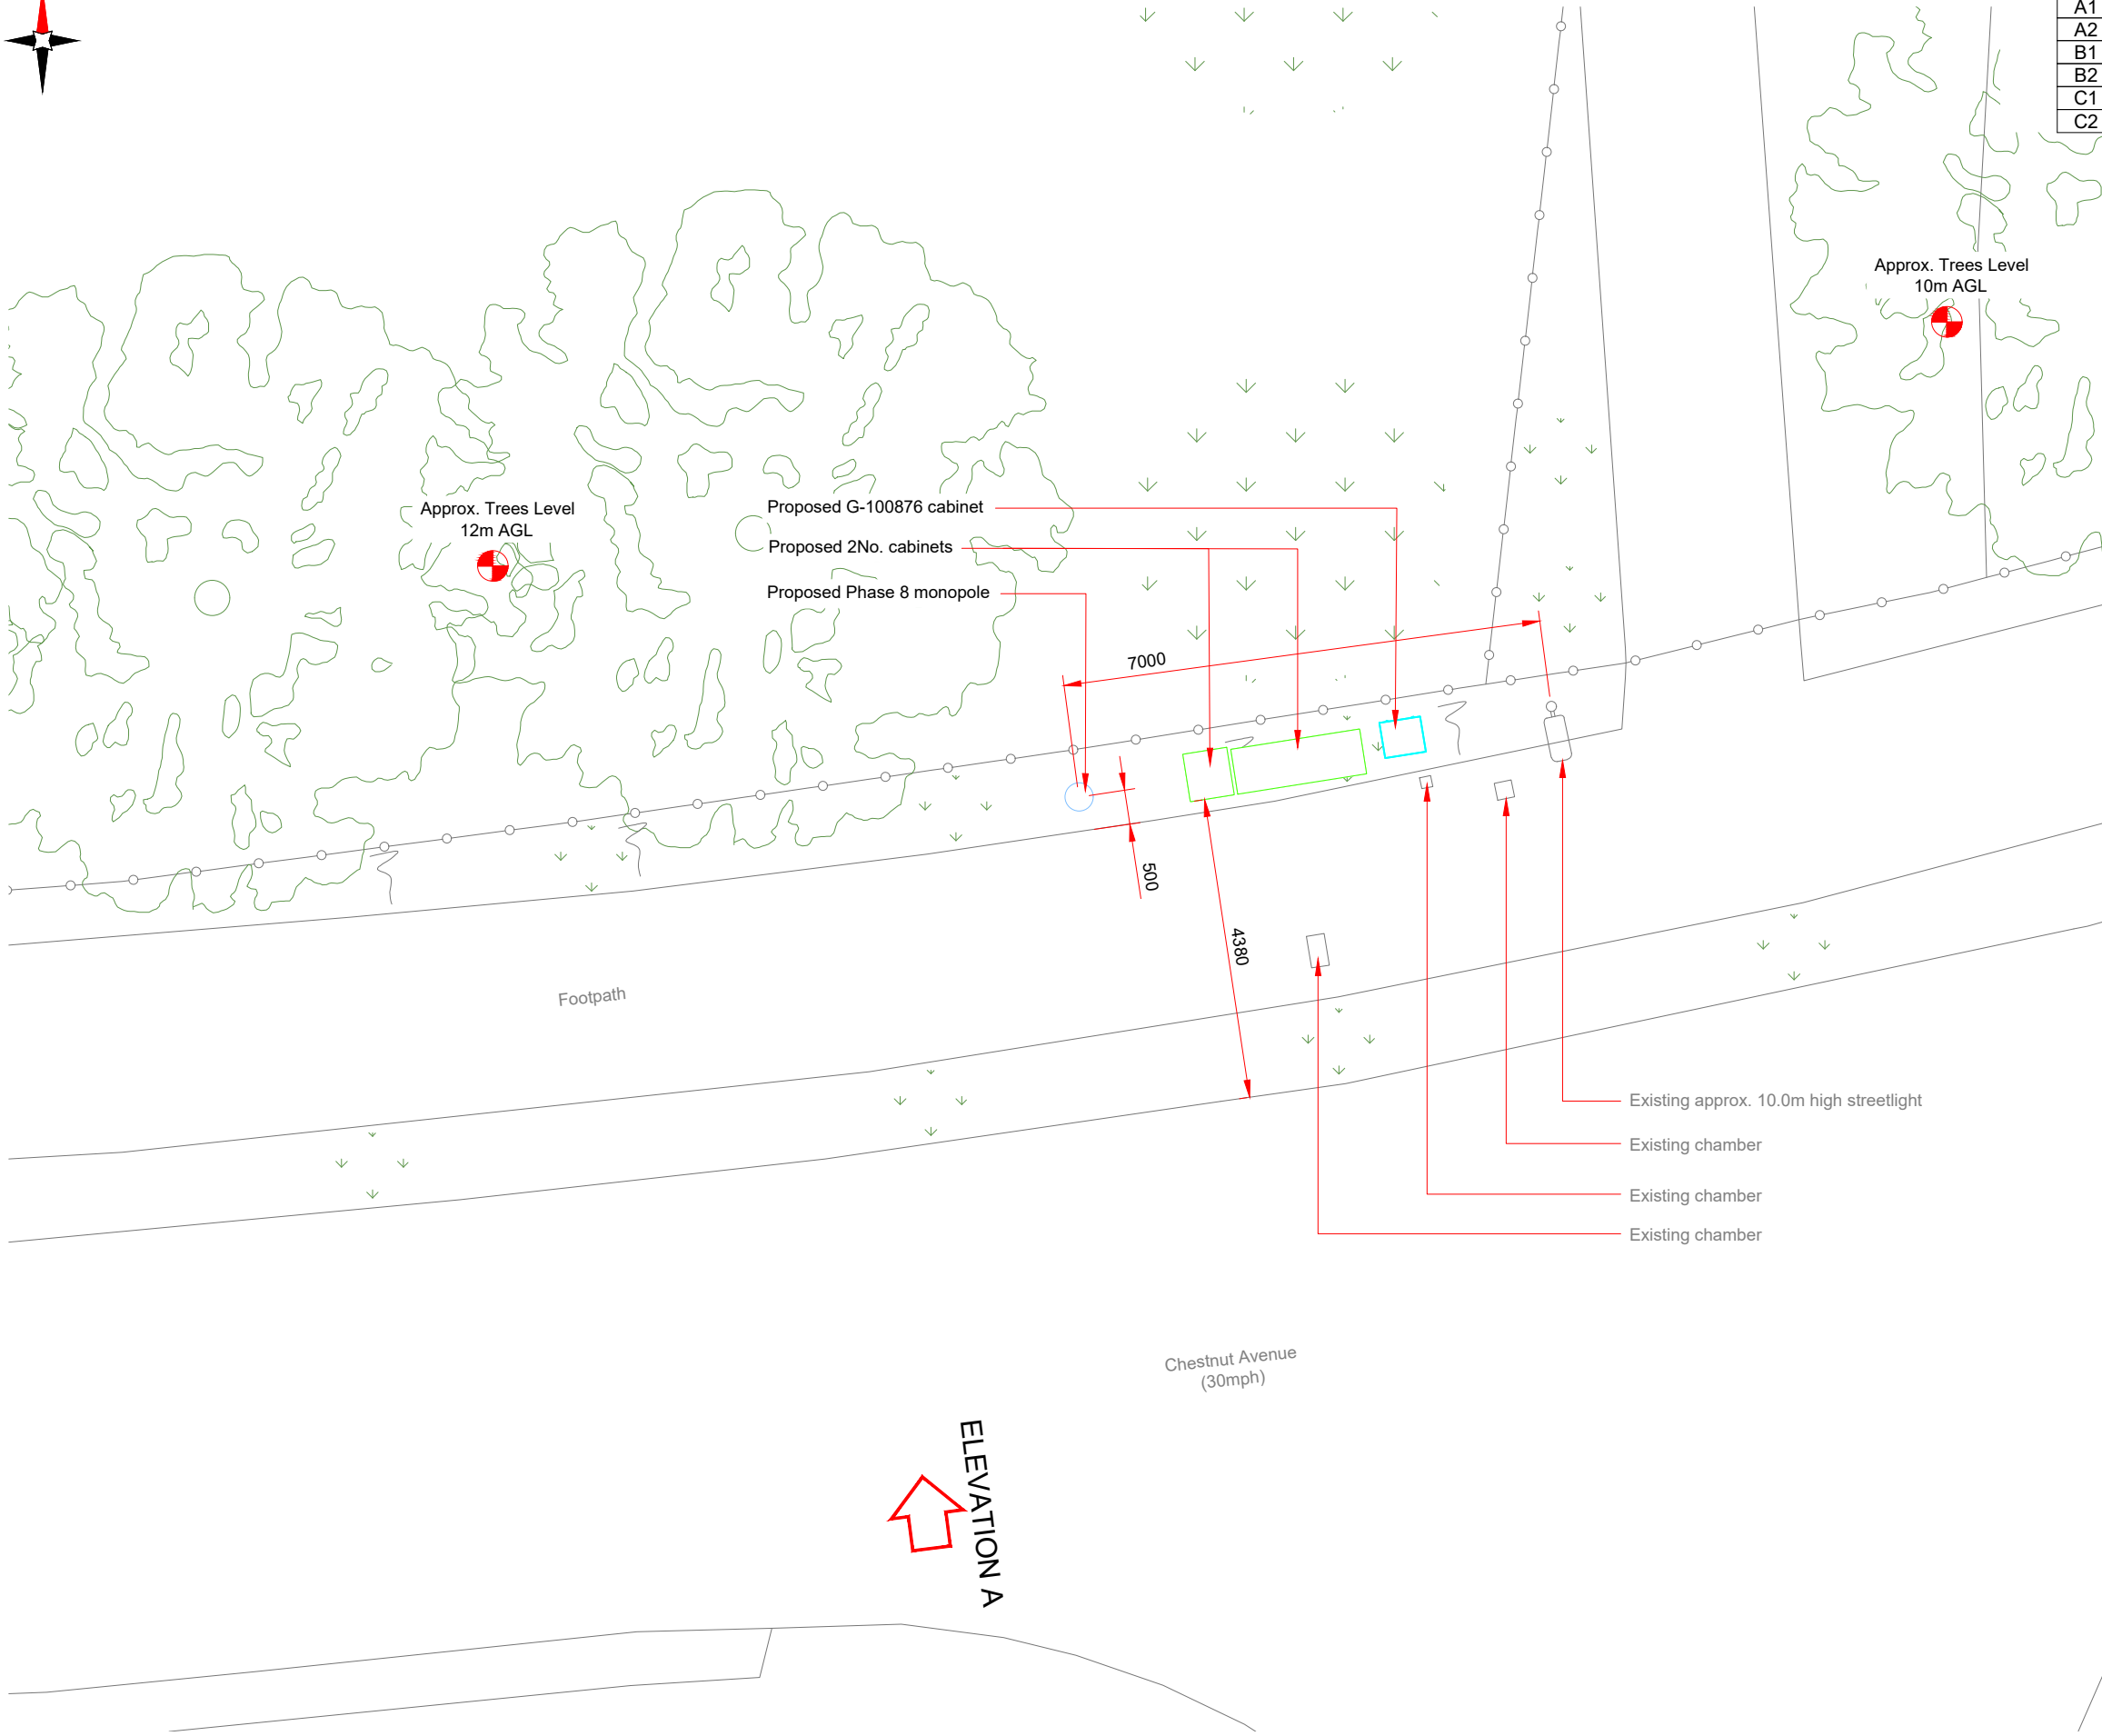

PROPOSED SITE PLAN



Antenna Aperture ID	Proposed 4G/5G Bearing
A1	0°
A2	0°
B1	120°
B2	120°
C1	240°
C2	240°

- NOTES:
- ALL DIMENSIONS IN MM UNLESS OTHERWISE NOTED.

Master: M002	MBNL / EE: MBNL	Project: 3UK DNSW	Purpose of Issue: Planning	Issue: B
Date: 23/06/2023	Drawn: CDN	Revision / Upgrade Description: Cabinets location amended		
Checked: DH	Approved: SD			
Master: M001	MBNL / EE: MBNL	Project: 3UK DNSW	Purpose of Issue: Planning	Issue: A
Date: 14/03/2023	Drawn: CDN	Revision / Upgrade Description: First Issue - Site nomination dated: TBC		
Checked: DH	Approved: SD			

CK Hutchison Networks (UK) Limited

Green Park
450 Longwater Avenue
Reading
RG30 3UR

Design Consultant & Principal Contractor:



WHP Telecoms

Unit 1 Maple Park,
Low Fields Avenue, Leeds
LS12 6HH

Tel: 01133023550
e-mail: info@whptelecoms.com

Site Name:
CHESTNUT AVENUE STREETWORKS

Site ID:
ELH26124

Address:
CHESTNUT AVENUE, NORTH STONEHAM,
EASTLEIGH, HAMPSHIRE, ENGLAND,
SO50 5EL

Title:
210 PROPOSED SITE PLAN

Project:
3UK DNSW

Purpose of Issue:
PLANNING

EE Cell ID: 95887	MBNL Cell ID: ELH078	Cell ID: SO0719
----------------------	-------------------------	--------------------

Master Drawing No: ELH26124_M002	Issue: B
-------------------------------------	-------------