



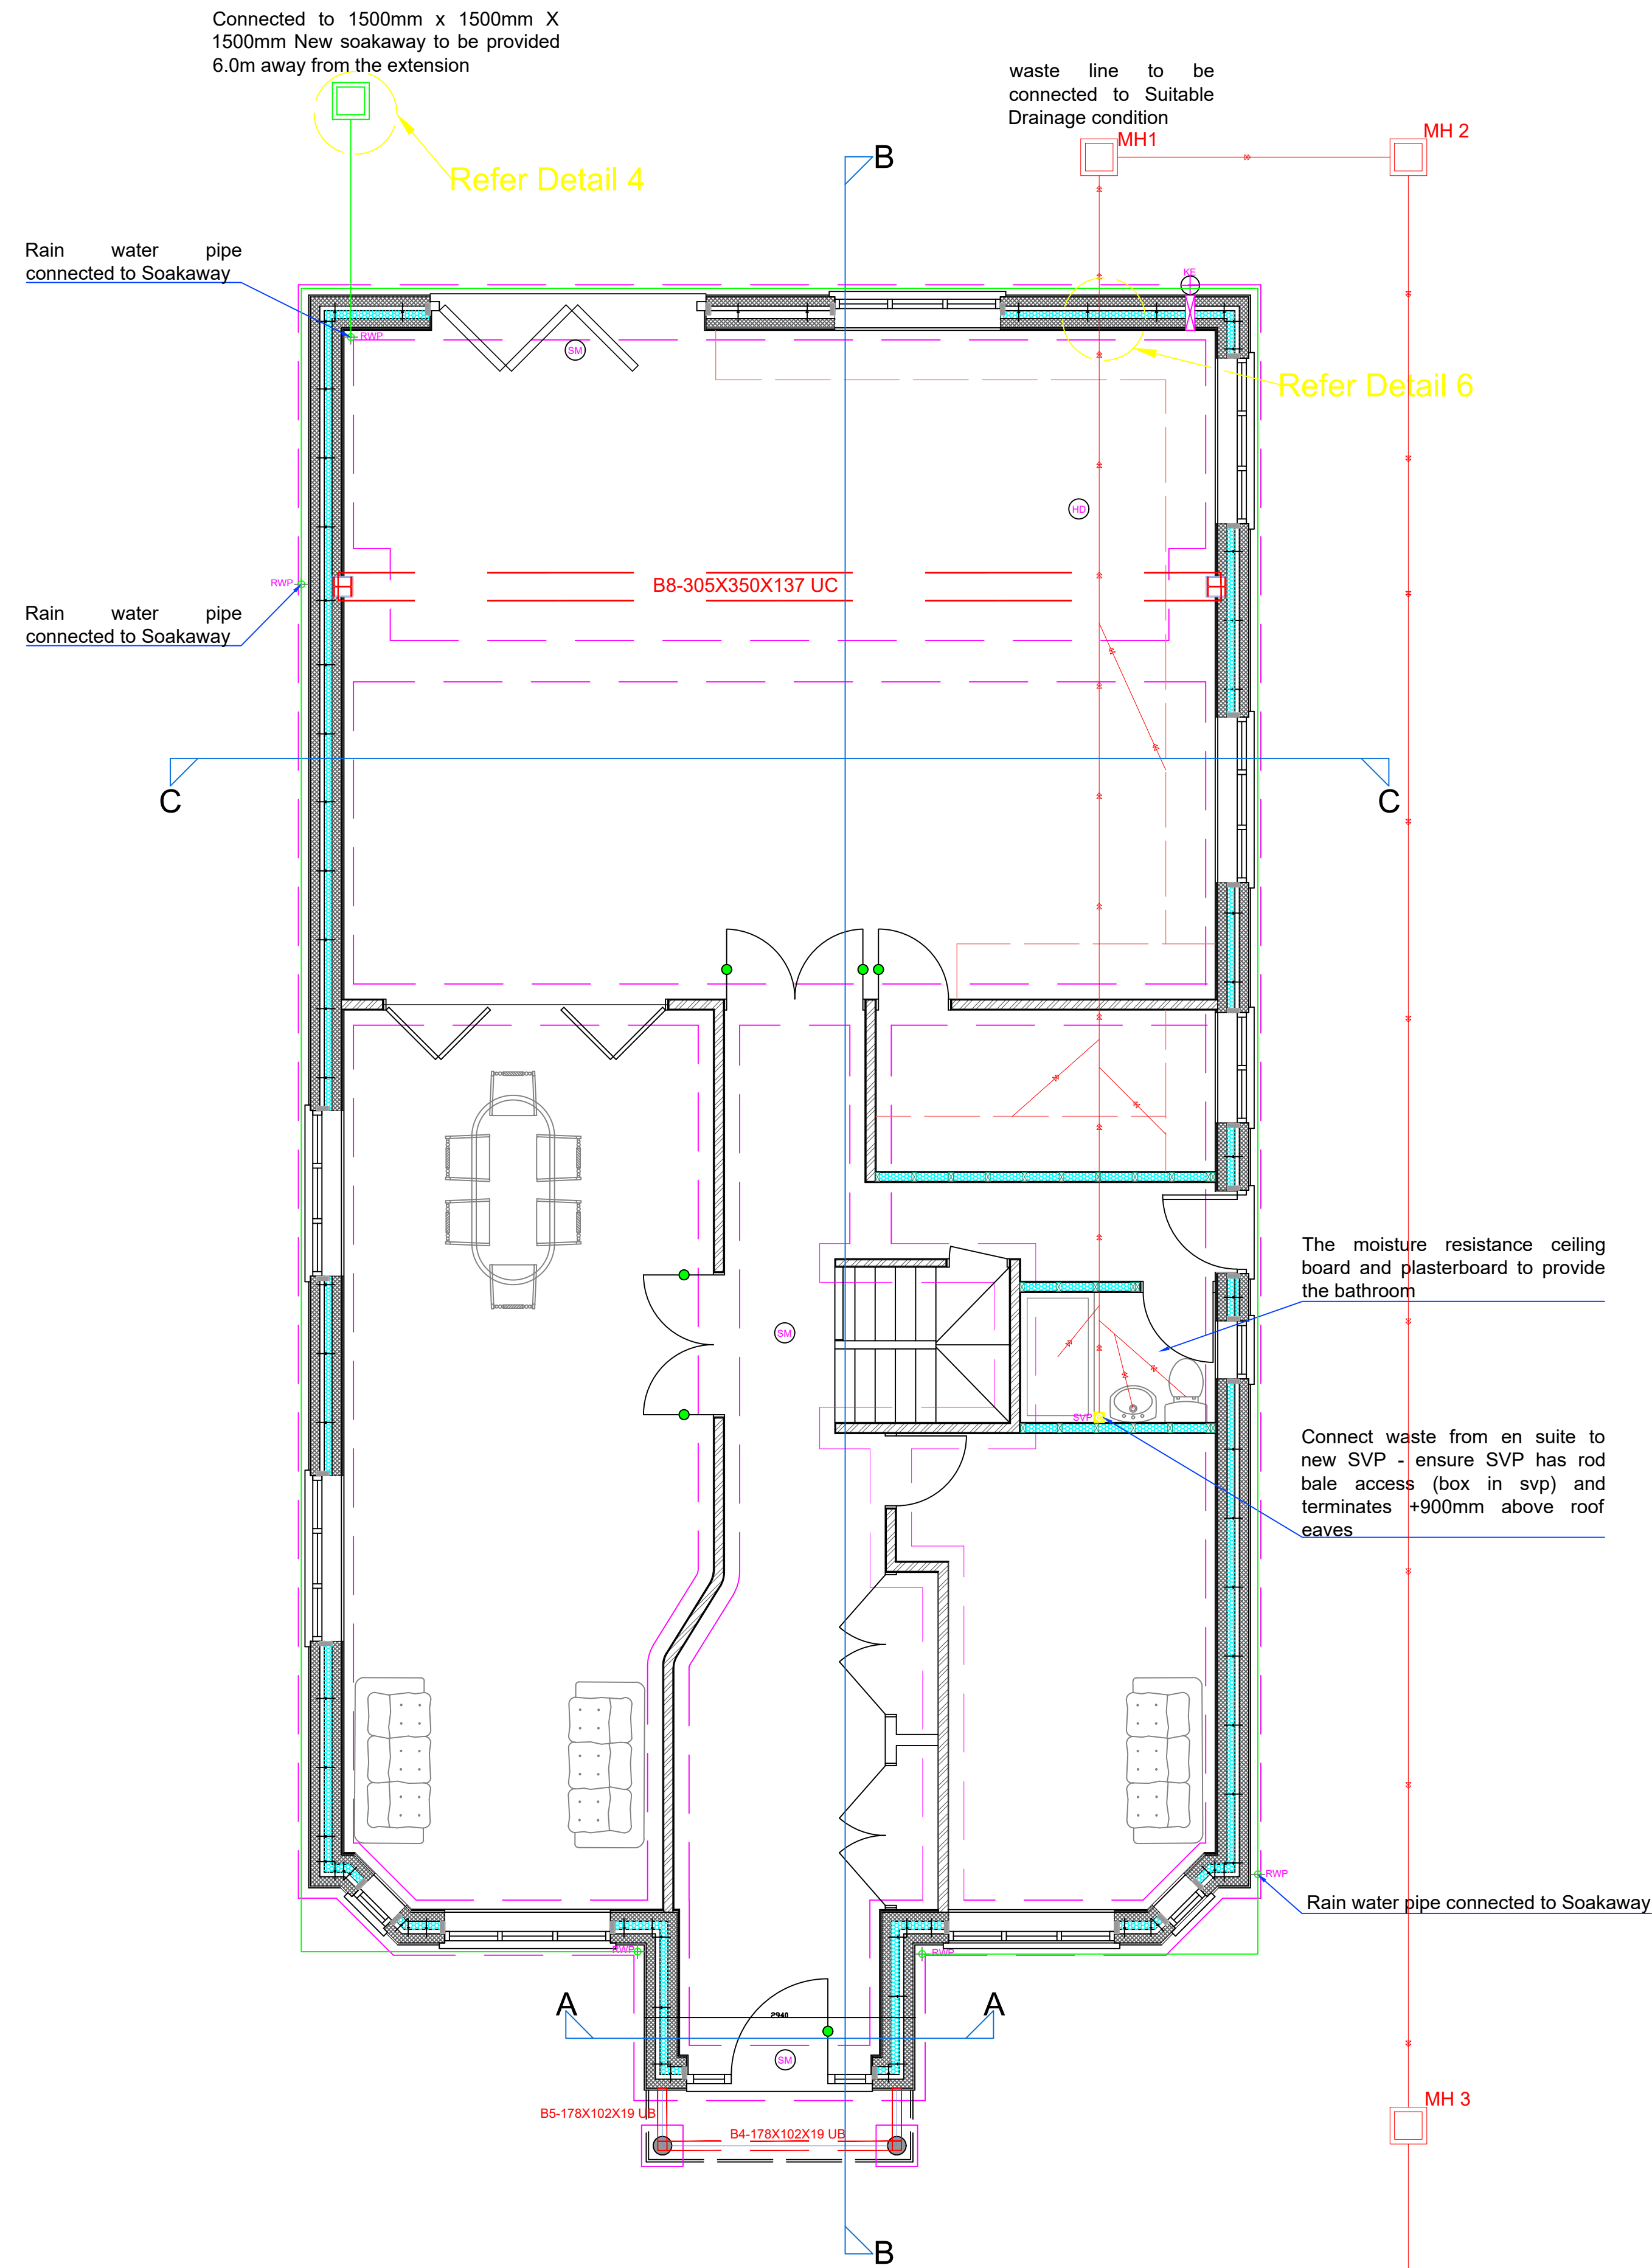

PROPOSED GROUND FLOOR
SEWER LINE PLAN

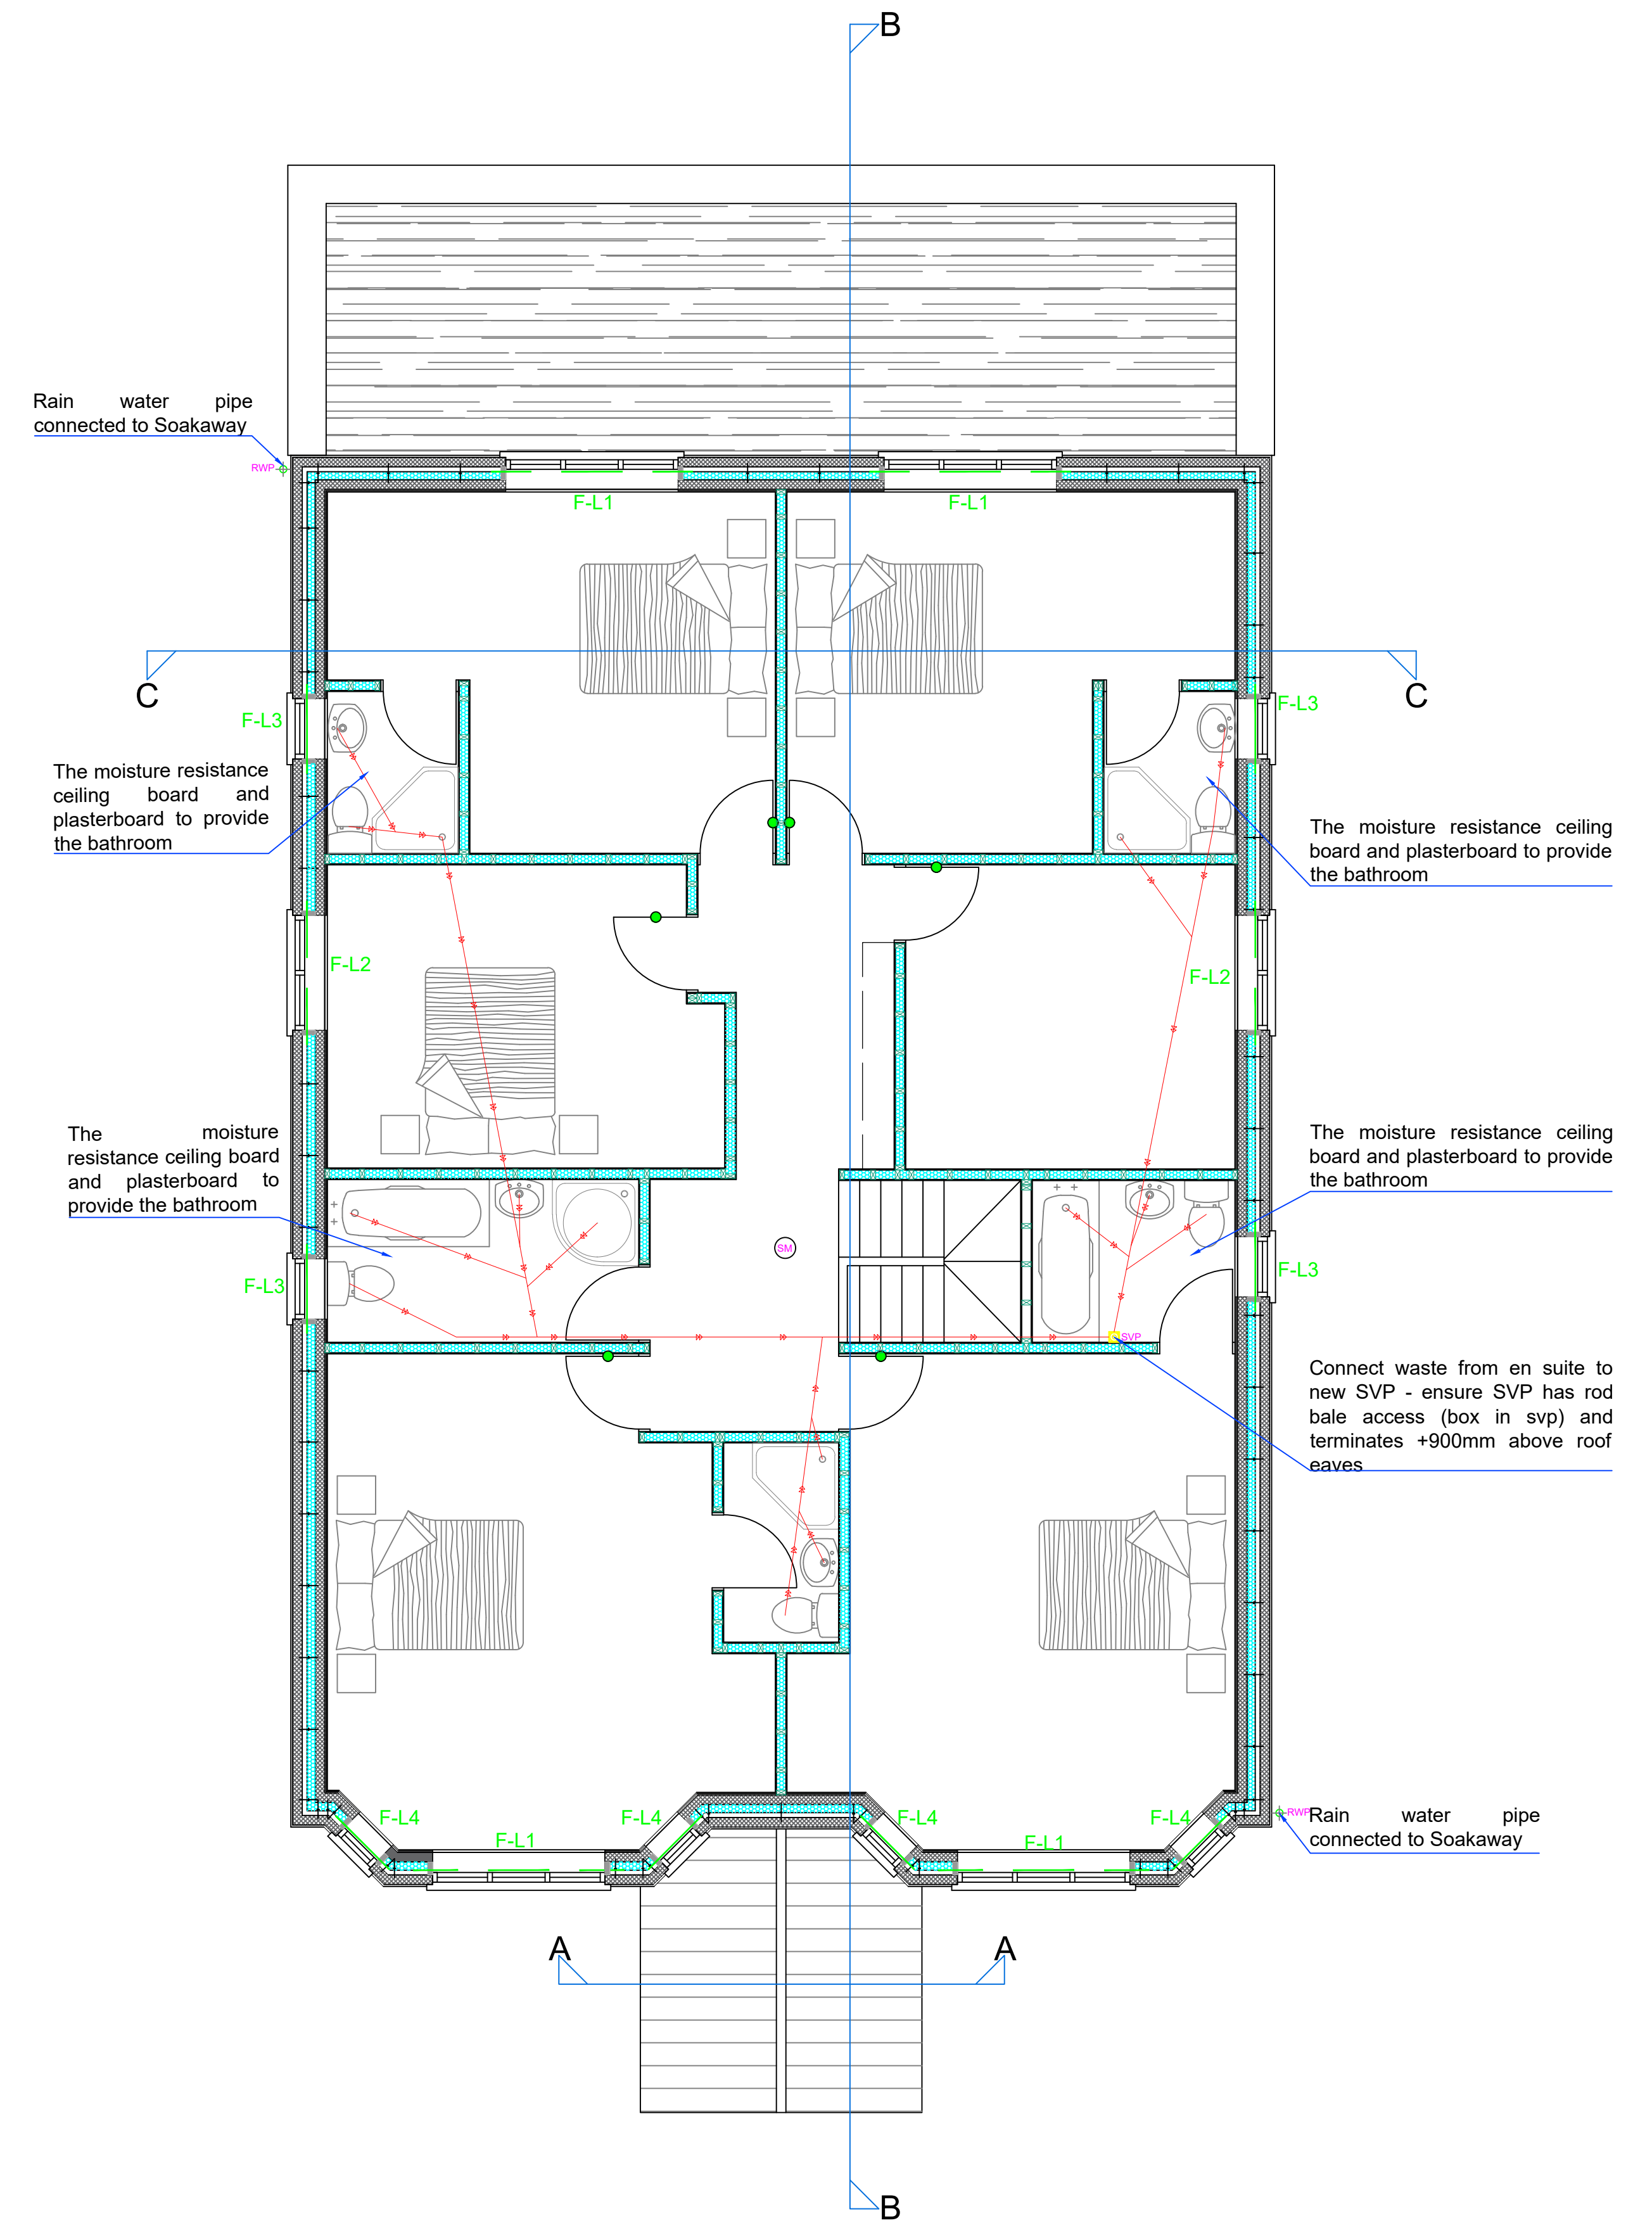

PROPOSED FIRST FLOOR
SEWER LINE PLAN

Filename: A1/BR3	Date: APRIL 2023	Scale: A1 - 1:50
Drawing Name: DRAINAGE PLANS		