


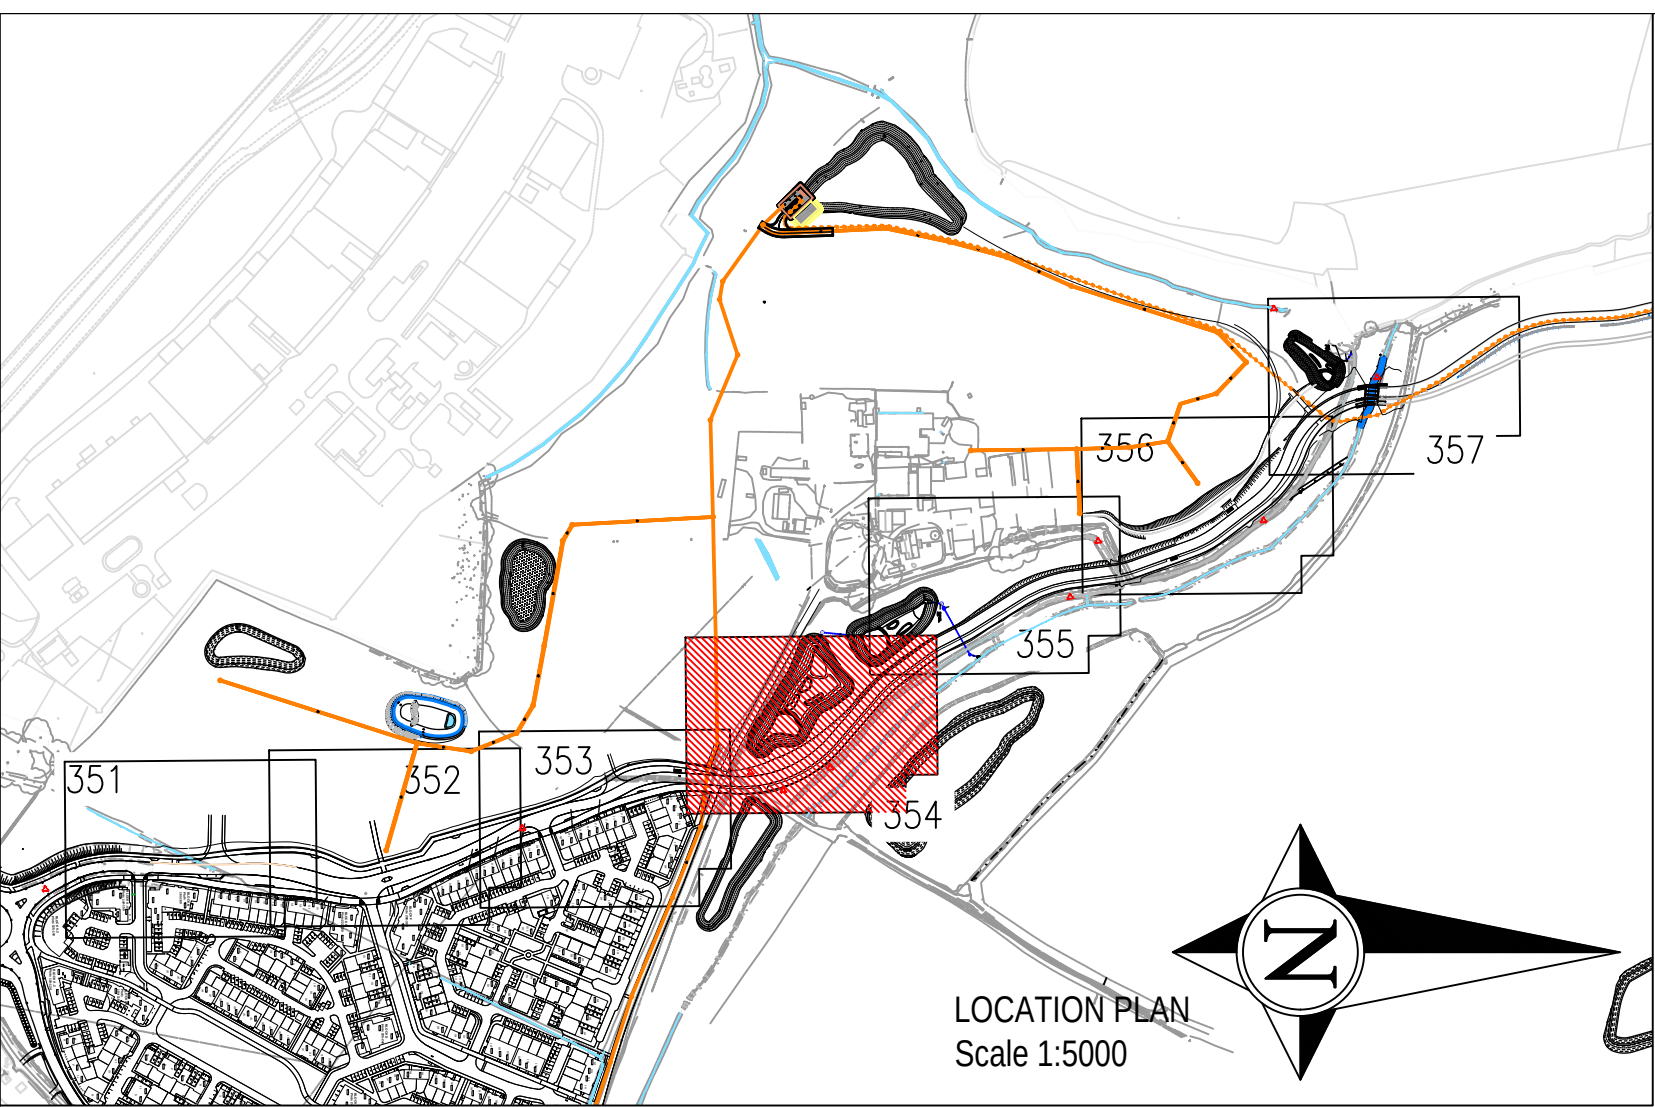

RISK SCHEDULE	
ITEM	DESCRIPTION OF RISK OF ACTION
	SPECIFIC HEALTH AND SAFETY RISKS ASSOCIATED WITH THESE WORKS ARE HIGHLIGHTED WITH THE CAUTION SYMBOL ADJACENT TO THE ITEM OF RISK. PLEASE REFER TO RISK SCHEDULE CONTAINED ON INDIVIDUAL DRAWINGS.
	UNLESS HIGHLIGHTED THERE ARE NO SPECIFIC HEALTH AND SAFETY RISKS ASSOCIATED WITH THESE WORKS, AS A DIRECT RESULT OF OUR DESIGN, APART FROM THE COMMON ISSUES ASSOCIATED WITH CONSTRUCTION THAT WILL NEED TO BE ASSESSED BY A COMPETENT CONTRACTOR PRIOR TO THE UNDERTAKING OF ANY WORKS.
	THE CONTRACTOR SHOULD BE AWARE OF DEEP EXCAVATIONS FOR SEWERS
	THE CONTRACTOR SHOULD BE AWARE OF THE EXISTING HV CABLED
	THE CONTRACTOR SHOULD BE AWARE OF THE EXISTING HIGHWAYS ADJACENT TO THE SITE.
	THE CONTRACTOR SHOULD BE AWARE OF EXISTING SERVICES REMAIN LIVE DURING CONSTRUCTION

NOTES

- THIS DRAWING IS COPYRIGHT.
- THE CONTRACTOR AND HIS SUBCONTRACTOR ARE TO VERIFY ALL DIMENSIONS ON SITE PRIOR TO MAKING SHOP DRAWINGS OR COMMENCING MANUFACTURE.
- DO NOT SCALE THIS DRAWING. THE CONTRACTOR IS TO BRING TO THE NOTICE OF THE ENGINEER ANY DISCREPANCIES CONTAINED IN THIS DRAWING PRIOR TO WORK COMMENCEMENT.
- ALL 150mm AND 225mm DIAMETER PIPES TO BE ADOPTED BY SOUTHERN WATER TO BE EXTRA STRENGTH VITRIFIED CLAY PIPES AND ALL 150mm AND 225mm DIAMETER PIPES NON ADOPTABLE OR TO BE ADOPTED BY HAMPSHIRE COUNTY COUNCIL TO BE PLASTIC PIPES COMPLYING WITH HCC TECHNICAL REQUIREMENTS AND DESIGN AND CONSTRUCTION GUIDE FOR FOUL AND SURFACE WATER SEWERS OFFERED FOR ADOPTION
- ALL PIPES OF 300mm DIAMETER OR GREATER TO BE ADOPTED BY SOUTHERN WATER TO BE CLASS M CONCRETE AND ALL PIPES OF 300mm DIAMETER OR GREATER NON ADOPTABLE OR TO BE ADOPTED BY HAMPSHIRE COUNTY COUNCIL TO BE PLASTIC PIPES COMPLYING WITH HCC TECHNICAL REQUIREMENTS AND DESIGN AND CONSTRUCTION GUIDE FOR FOUL AND SURFACE WATER SEWERS OFFERED FOR ADOPTION.
- ALL PIPE MATERIALS TO BE CONSISTENT BETWEEN MANHOLES.
- ALL WORK IS TO BE CARRIED OUT IN ACCORDANCE WITH DESIGN AND CONSTRUCTION GUIDANCE(DCG)/SEWER FOR ADOPTION 7TH, HAMPSHIRE COUNTY COUNCIL STANDARDS (FOR HIGHWAY DRAINAGE ONLY) AND THE SPECIFICATION FOR HIGHWAY WORKS 1998 AND ALL SUBSEQUENT AMENDMENTS. WHERE THERE IS CONFLICT BETWEEN THESE DOCUMENTS THE MATTER SHALL BE REFERRED TO THE ENGINEER.
- FOR CONSTRUCTION DETAILS OF MANHOLES AND SEWERS REFER TO DESIGN AND CONSTRUCTION GUIDANCE/SEWERS FOR ADOPTION 7TH, HCC STANDARD DETAILS(FOR SEWERS ADOPTED BY HCC HIGHWAYS) AND UNDERTAKERS STANDARD DETAILS WHICH CAN BE OBTAINED FROM THE LOCAL OFFICE FOR SEWERS ADOPTED BY SOUTHERN WATER
- INVERT LEVELS OF EXISTING SEWERS TO BE CONFIRMED ON SITE BEFORE ANY SEWER WORK UNDERTAKEN. ANY DISCREPANCIES FOUND SHOULD BE NOTIFIED TO ENGINEERS.
- WHERE SEWERS HAVE LESS THAN 1.2m OF COVER UNDER ROADS AND 0.9m COVER ELSEWHERE PIPES ARE TO HAVE A 150mm CONCRETE BED AND SURROUND.
- PLASTIC CHAMBERS AND RINGS SHALL COMPLY WITH BS EN 13598-1 AND BS EN 13598-2 OR HAVE EQUIVALENT INDEPENDENT APPROVAL, TO TABLE 11 OF APPROVED DOCUMENT H1 OF THE BUILDING REGULATIONS 2010.
- ALL BELOW GROUND DRAINAGE TO BE 150mmØ UNLESS OTHERWISE INDICATED WITH A MIN. GRADIENT AS FOLLOWS:-
S.W : 150mm Dia. 1:150
- ALL ADOPTABLE DRAINAGE MATERIALS SHOULD COMPLY WITH THE REQUIREMENTS OF PART 7 CIVIL ENGINEERING SPECIFICATION INCLUDED WITH CGD/SEWERS FOR ADOPTION 7TH EDITION WHICH IS DRAWN FROM CESWI 7TH EDITION BUT IS NOT A FULL REPRODUCTION AND OR HAMPSHIRE COUNTY COUNCIL REQUIREMENTS.
- JETTING OF NEW DRAINAGE RUNS MUST BE CARRIED OUT AT END OF CONTRACT, IN ORDER TO ENSURE ALL NEW PIPE-WORK IS FREE OF DEBRIS AND FREE RUNNING

HEALTH & SAFETY:

ALL WORKS TO BE CARRIED OUT BY A CONTRACTOR COMPETENT TO UNDERTAKE THE CONSTRUCTION OF WORKS AS INDICATED ON THIS DRAWING. THIS DRAWING IS TO BE READ IN CONJUNCTION WITH THE JOB SPECIFIC RISK ASSESSMENT. THE HAZARDS NOTED ARE IN ADDITION TO THE NORMAL HAZARDS AND RISKS FACED BY A COMPETENT CONTRACTOR WHEN DEALING WITH THE TYPE OF WORKS DETAILED ON THIS DRAWING.

TOTAL CATCHMENT AREA:2.48HA

OUTFALL TO STRATEGIC SUDS FEATURE/ L2 DESIGNED BY PFA REFER TO DRAWING G277/29

DESIGN PENDING
APPROVAL UNDER
S104/S38

LEGEND

- S38 BOUNDARY
- EXISTING MANHOLE
- EXISTING GULLY
- EXISTING SURFACE WATER SEWER
- EXISTING SURFACE WATER DITCH
- EXISTING DRAINAGE DITCH TO BE REMOVED
- PROPOSED LAND DRAIN/DITCH
- PROPOSED HIGHWAY SURFACE WATER
- 1500 @ 1:225 - DENOTES BELOW GROUND HIGHWAY WATER DRAINAGE
- S1 1500 @ 1:225 - DENOTES PROPOSED SURFACE WATER MANHOLE
- 1500 @ 1:225 - DENOTES BELOW GROUND SURFACE WATER DRAINAGE
- DENOTES EXISTING SURFACE WATER MANHOLE
- DENOTES EXISTING GULLY CONNECTED TO SURFACE WATER SYSTEM
- DENOTES PROPOSED GULLY CONNECTED TO SURFACE WATER SYSTEM AS PER HCC11/D/015
- DENOTES PROPOSED FOUL WATER DRAINAGE DESIGNED BY OTHERS. REF TO PFA PACKAGE
- DENOTES PROPOSED RISING MAIN DESIGNED BY OTHERS. REF TO PFA PACKAGE
- DENOTES PROPOSED ATTENUATION BASIN. REFER TO PFA PACKAGE FOR DETAILS
- DENOTES ROAD SWALE
- DENOTES LATERAL FROM RESIDENTIAL PARCEL. FOR DETAILS REFER TO RIDGE AND PARTNERS LLP DESIGN DRAWINGS

C3 MANHOLES S28, S4, S7, S12 RELOCATED 17/07/23 PN
C2 NOTE 4 AND 5 UPDATED TO SPECIFY PLASTIC PIPES FOR PRIVATE DRAINAGE OR DRAINAGE TO BE ADOPTED BY HCC 17/05/23 PN

C1 ISSUED FOR CONSTRUCTION 21/03/23 PN
Rev. Description Date Initial

Drawing Status: CONSTRUCTION

RS REUBY & STAGG LTD.

CONSULTING CIVIL & STRUCTURAL ENGINEERS
Devey House
55 High Street, Ringwood
Hampshire BH24 1AE
T: 01425 484400 F: 01425 484409
Email: admin@reuby-stagg.co.uk

ONE HORTON HEATH

SEGMENT 3

DRAINAGE LAYOUT SHEET 4 OF 7

"THE AVENUE" SOUTHERN SECTION

Scale: 1:200 Page Size: A1 Date: DEC 20
Drawn: JP Checked: PN

Drawing No: 10413-SEG3-354 C3