

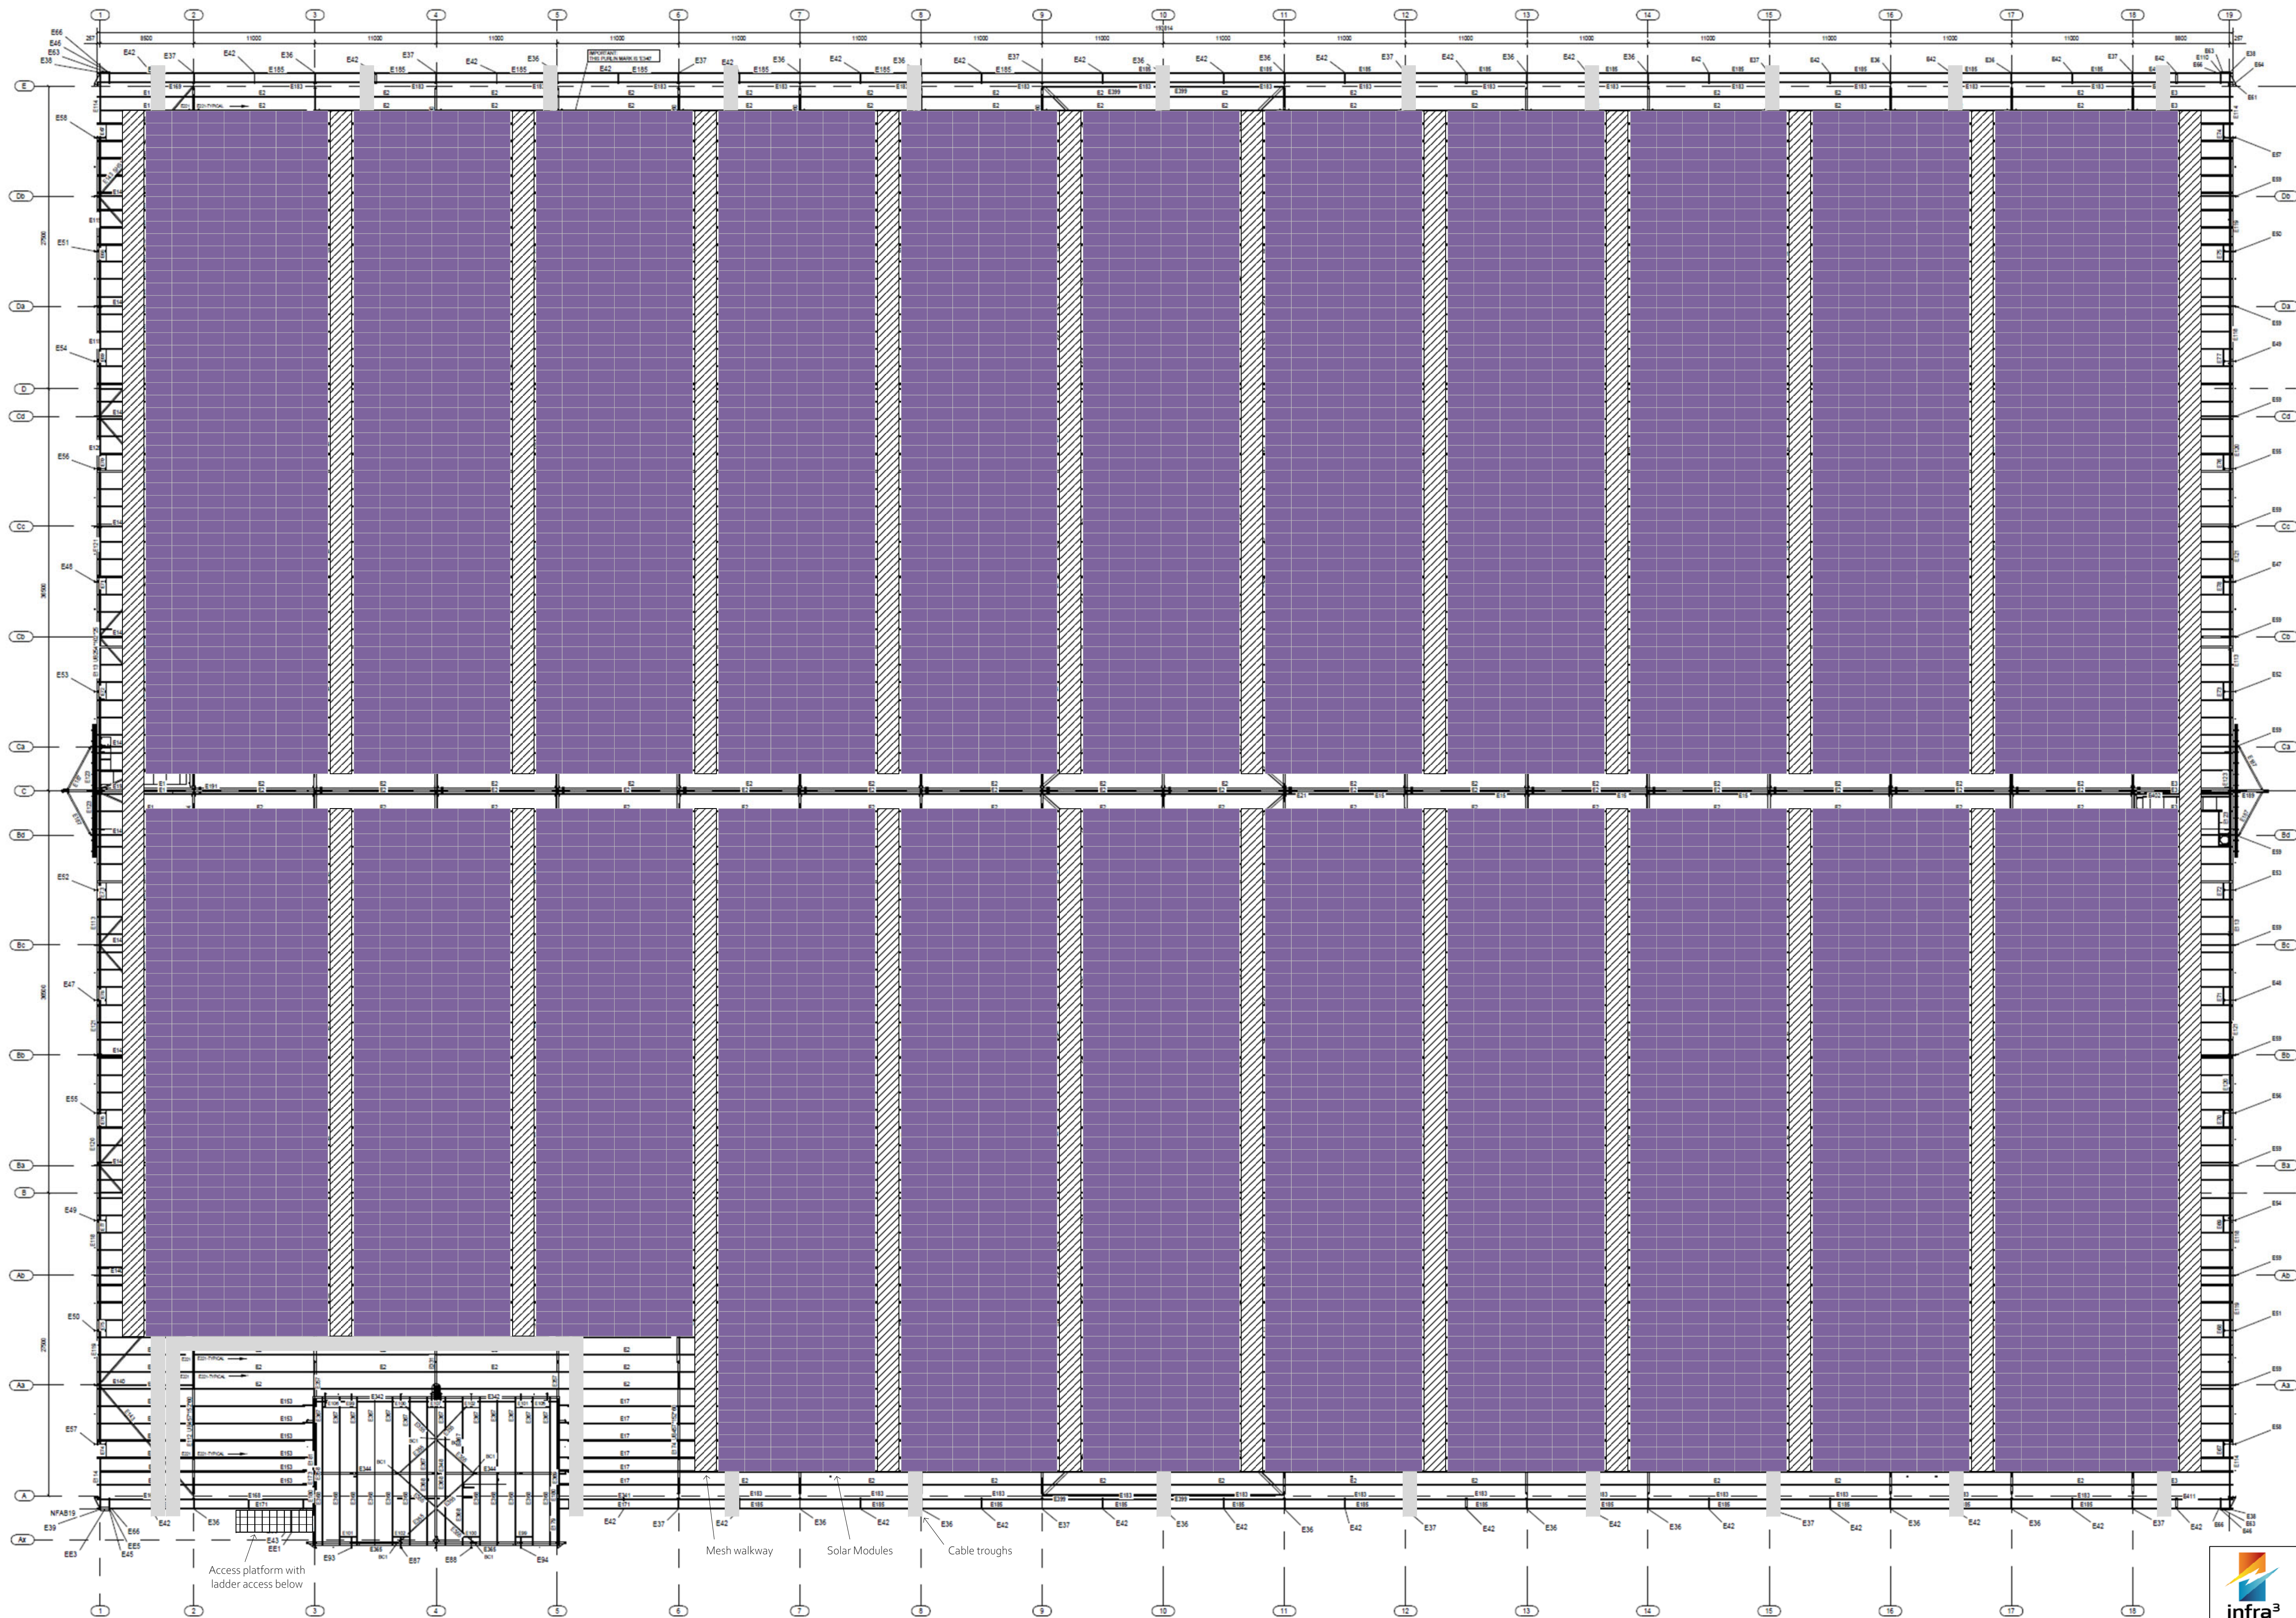


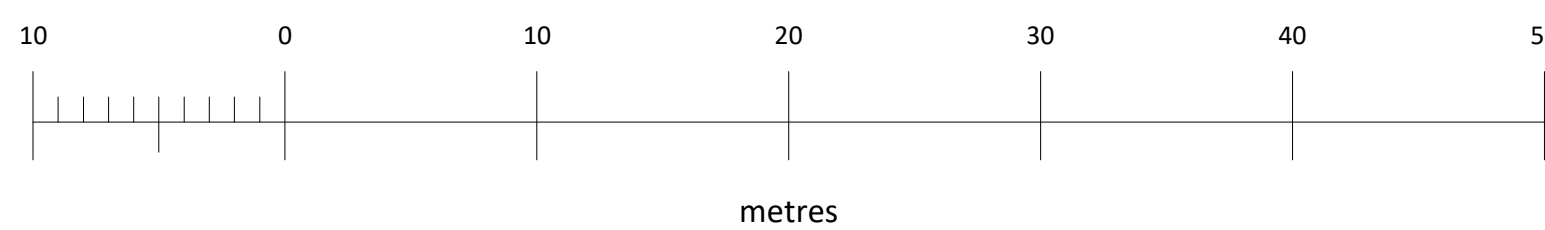

ROOF PLAN

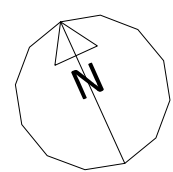

Client: Portsmouth Water  
Project: Proposed 4.1MWp Solar Farm on High Wood Reservoir  
Title: Solar/Roof layout - Proposed  
Ref No: I3/23-007-001 REV B

Scale:  
1:300 @ A1  
Date:  
15/11/2023  
Drawn by:  
RO'C