


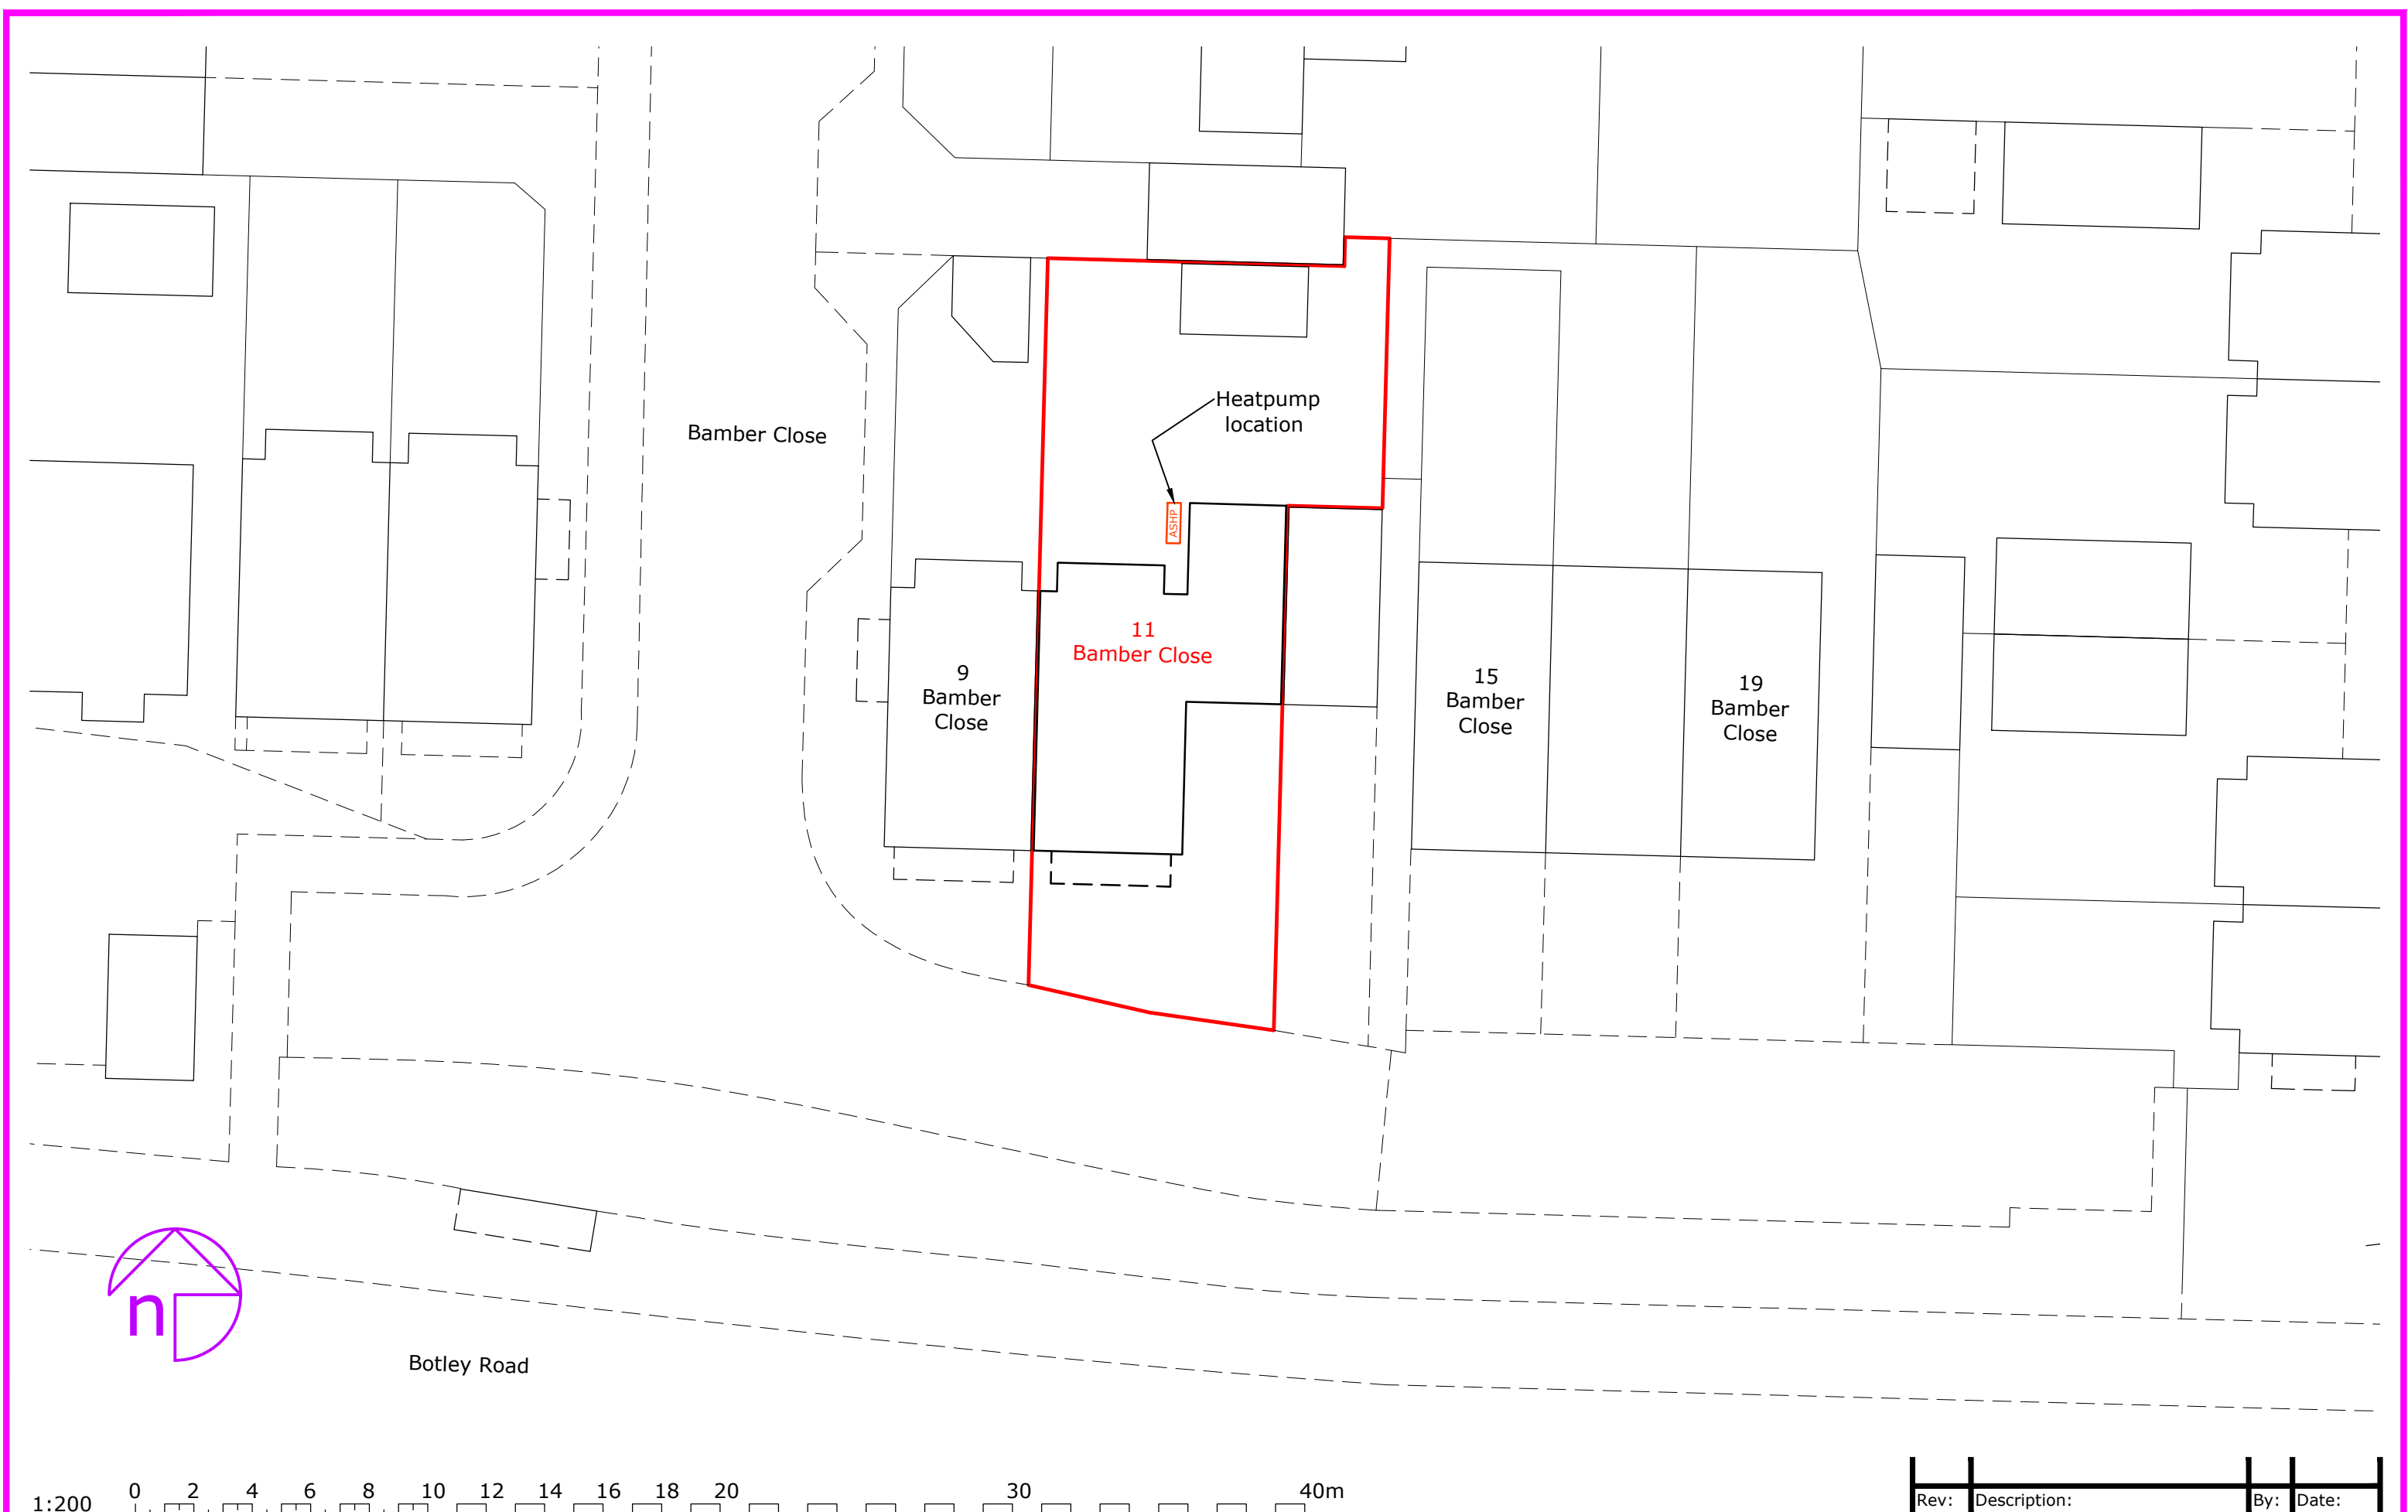

1:200

0

2

4

6

8

10

12

14

16

18

20

30

40m

Rev:	Description:	By:	Date:
Scale:	Paper Size:	Drawn:	Checked:
1:200	A3	D. Rodriguez	
Project ID:	Drawing No:	Revision:	Date:
J-F033DA16	03	-	05.12.2023



Accredited by:



Client/Project:

Peter Lyon-Marrian

11, Bamber Close

West End, SO30 3HW

Project status:

PLANNING

Drawing title:

Site plan as proposed

© Octopus Energy 2023