

KEY TO HEALTH AND SAFETY SYMBOLS

THESE NOTES ARE BASED ON THE USE OF EXPERIENCED AND COMPETENT CONTRACTORS CARRYING OUT THE WORK USING AN APPROVED SAFE METHOD OF WORKING

- INDICATES A RESIDUAL RISK REQUIRING A COMPULSORY ACTION
- INDICATES A RESIDUAL RISK REQUIRING A PROHIBITIVE ACTION
- INDICATES A RESIDUAL RISK AS A WARNING
- INDICATES A RESIDUAL RISK FOR INFORMATION

NOTES

This drawing is the copyright of ARCH Associates Limited. It may not be copied, altered or reproduced without their written authority. This drawing must not be scaled. IF IN DOUBT ASK.

GENERAL NOTES

- THIS DRAWING IS TO BE READ IN CONJUNCTION WITH ALL RELEVANT ARCHITECTS, ENGINEERS AND SPECIALISTS DRAWINGS AND DETAILS.
- ALL FIGURED DIMENSIONS TO BE TAKEN IN PREFERENCE TO SCALED DIMENSIONS.
- ANY DISCREPANCIES BETWEEN THIS DRAWING AND OTHER INFORMATION IS TO BE BROUGHT TO THE ATTENTION OF THE ENGINEER PRIOR TO THE COMMENCEMENT OF THE WORKS ON SITE.
- THE MAIN CONTRACTOR SHALL BE RESPONSIBLE FOR THE SETTING OUT AND ACCURACY OF ALL DIMENSIONS. THE CONTRACTOR IS TO ENSURE THE STABILITY AND STRUCTURAL INTEGRITY OF THE EXISTING PROPERTY AT ALL TIMES DURING WORKS AND IS TO BE RESPONSIBLE FOR ALL PROPPING AND SHORING AS REQUIRED.
- MAIN CONTRACTOR TO PROVIDE AND FIX SUITABLE BRACING AND PROPPING FOR ALL ELEMENTS IN THE TEMPORARY CONDITION DURING CONSTRUCTION STAGE, SUCH AS TO ENSURE STRUCTURE STABILITY AT ALL TIMES.
- IT IS THE CONTRACTORS SOLE RESPONSIBILITY FOR ASCERTAINING SAFE DISPOSAL OF ANY OFF-SITE EXCAVATED SPOIL. NO CLAIM RESULTING FROM ABNORMAL TIP REQUIREMENTS WILL BE ENTERTAINED.

HIGHWAYS

- ALL WORKS TO COMPLY WITH RELEVANT COUNTY COUNCIL OR LOCAL AUTHORITY SPECIFICATION, AS REQUIRED.
- ALL DRAINAGE WORKS IN ADAPTABLE AREAS TO BE IN ACCORDANCE WITH WATER AUTHORITY ASSOCIATION 'SEWERS FOR ADOPTION' - 7th EDITION.

COLOURED
DRAWING

REQUEST A COLOURED COPY IF
THIS STAMP IS NOT RED

DRAINAGE LEGEND

- EXISTING SURFACE / STORM WATER SEWER / MANHOLE
- EXISTING FOUL WATER SEWER / MANHOLE
- SURFACE WATER MANHOLE / INSPECTION CHAMBER / ACCESS CHAMBER
- SURFACE WATER CATCHPIT MANHOLE
- 100mm Dia. PVCu, SN8 STORM WATER DRAIN (U.N.O.)
- RAIN WATER DOWNPIPE (LOCATION AS ARCHITECTS DRGS.)
- ROAD GULLY
- RODDING EYE.
- ATTENUATION TANK / SOAKAWAY OUT OF PROPRIETARY CRATE SYSTEM
- FOUL WATER MANHOLE / INSPECTION CHAMBER / ACCESS CHAMBER
- 100mm Dia. PVCu, SN8 FOUL WATER DRAIN (U.N.O.)
- FOUL WATER RISING MAIN BY SPECIALIST
- SOIL VENT PIPE / STUB STACK (LOCATION AS ARCHITECTS DRGS.)

P01	17.10.2023	PRELIMINARY ISSUE FOR COMMENT	TA
Rev.	Date	Description	By

ARCH ASSOCIATES

01489 890004
admin@archassociates.co.uk
www.archassociates.co.uk

Client
FOREMAN HOMES

Architect
KSA ARCHITECTS LTD.


Project title
TOYNBEE ROAD, EASTLEIGH.

Drawing title
**DRAINAGE LAYOUT,
GENERAL ARRANGEMENT,
SHEET 3.**

Scale	Paper size	Date	Drawn by	Checked by	Status
1:200	A1	OCT 2023	TA	CH	S3

Name
Project code
Originator | Functional | Spatial | Form | Detail | Number | Revision

FHL014 - AAL - ED - XX - DP - C -5010- P01

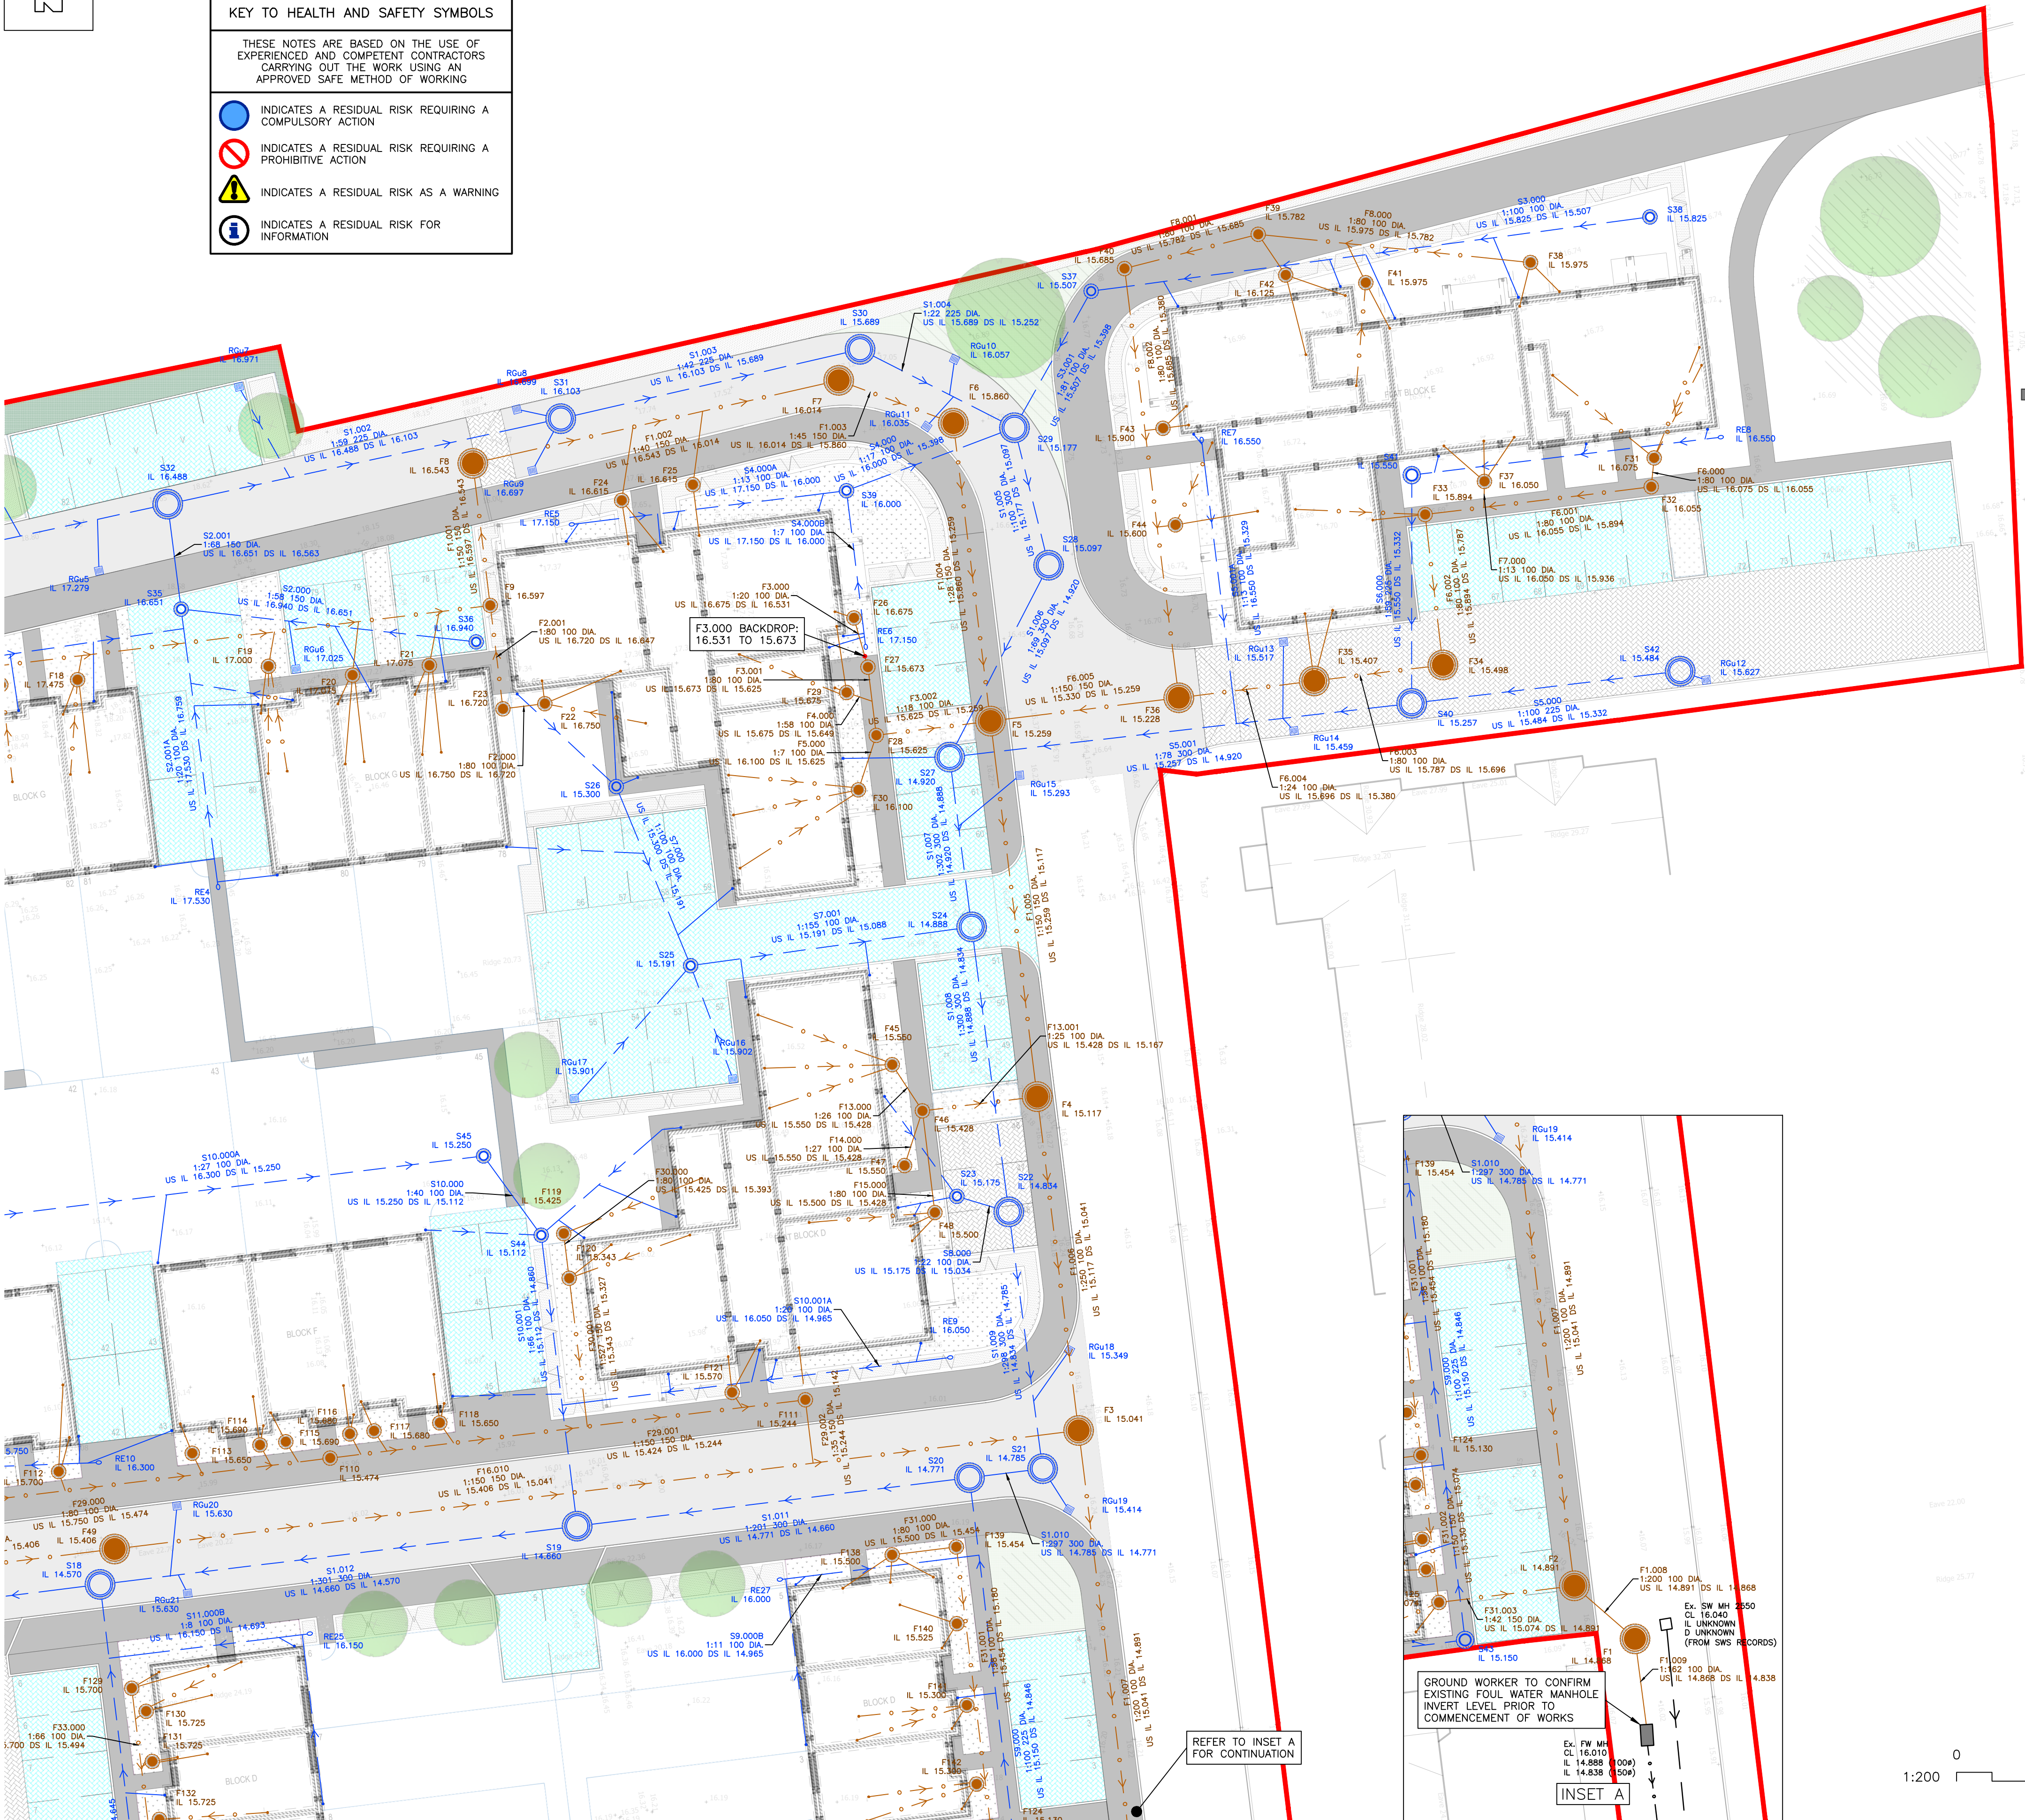

REFER TO INSET A
FOR CONTINUATION

GROUND WORKER TO CONFIRM
EXISTING FOUL WATER MANHOLE
INVERT LEVEL PRIOR TO
COMMENCEMENT OF WORKS

INSET A

0 20m
1:200