


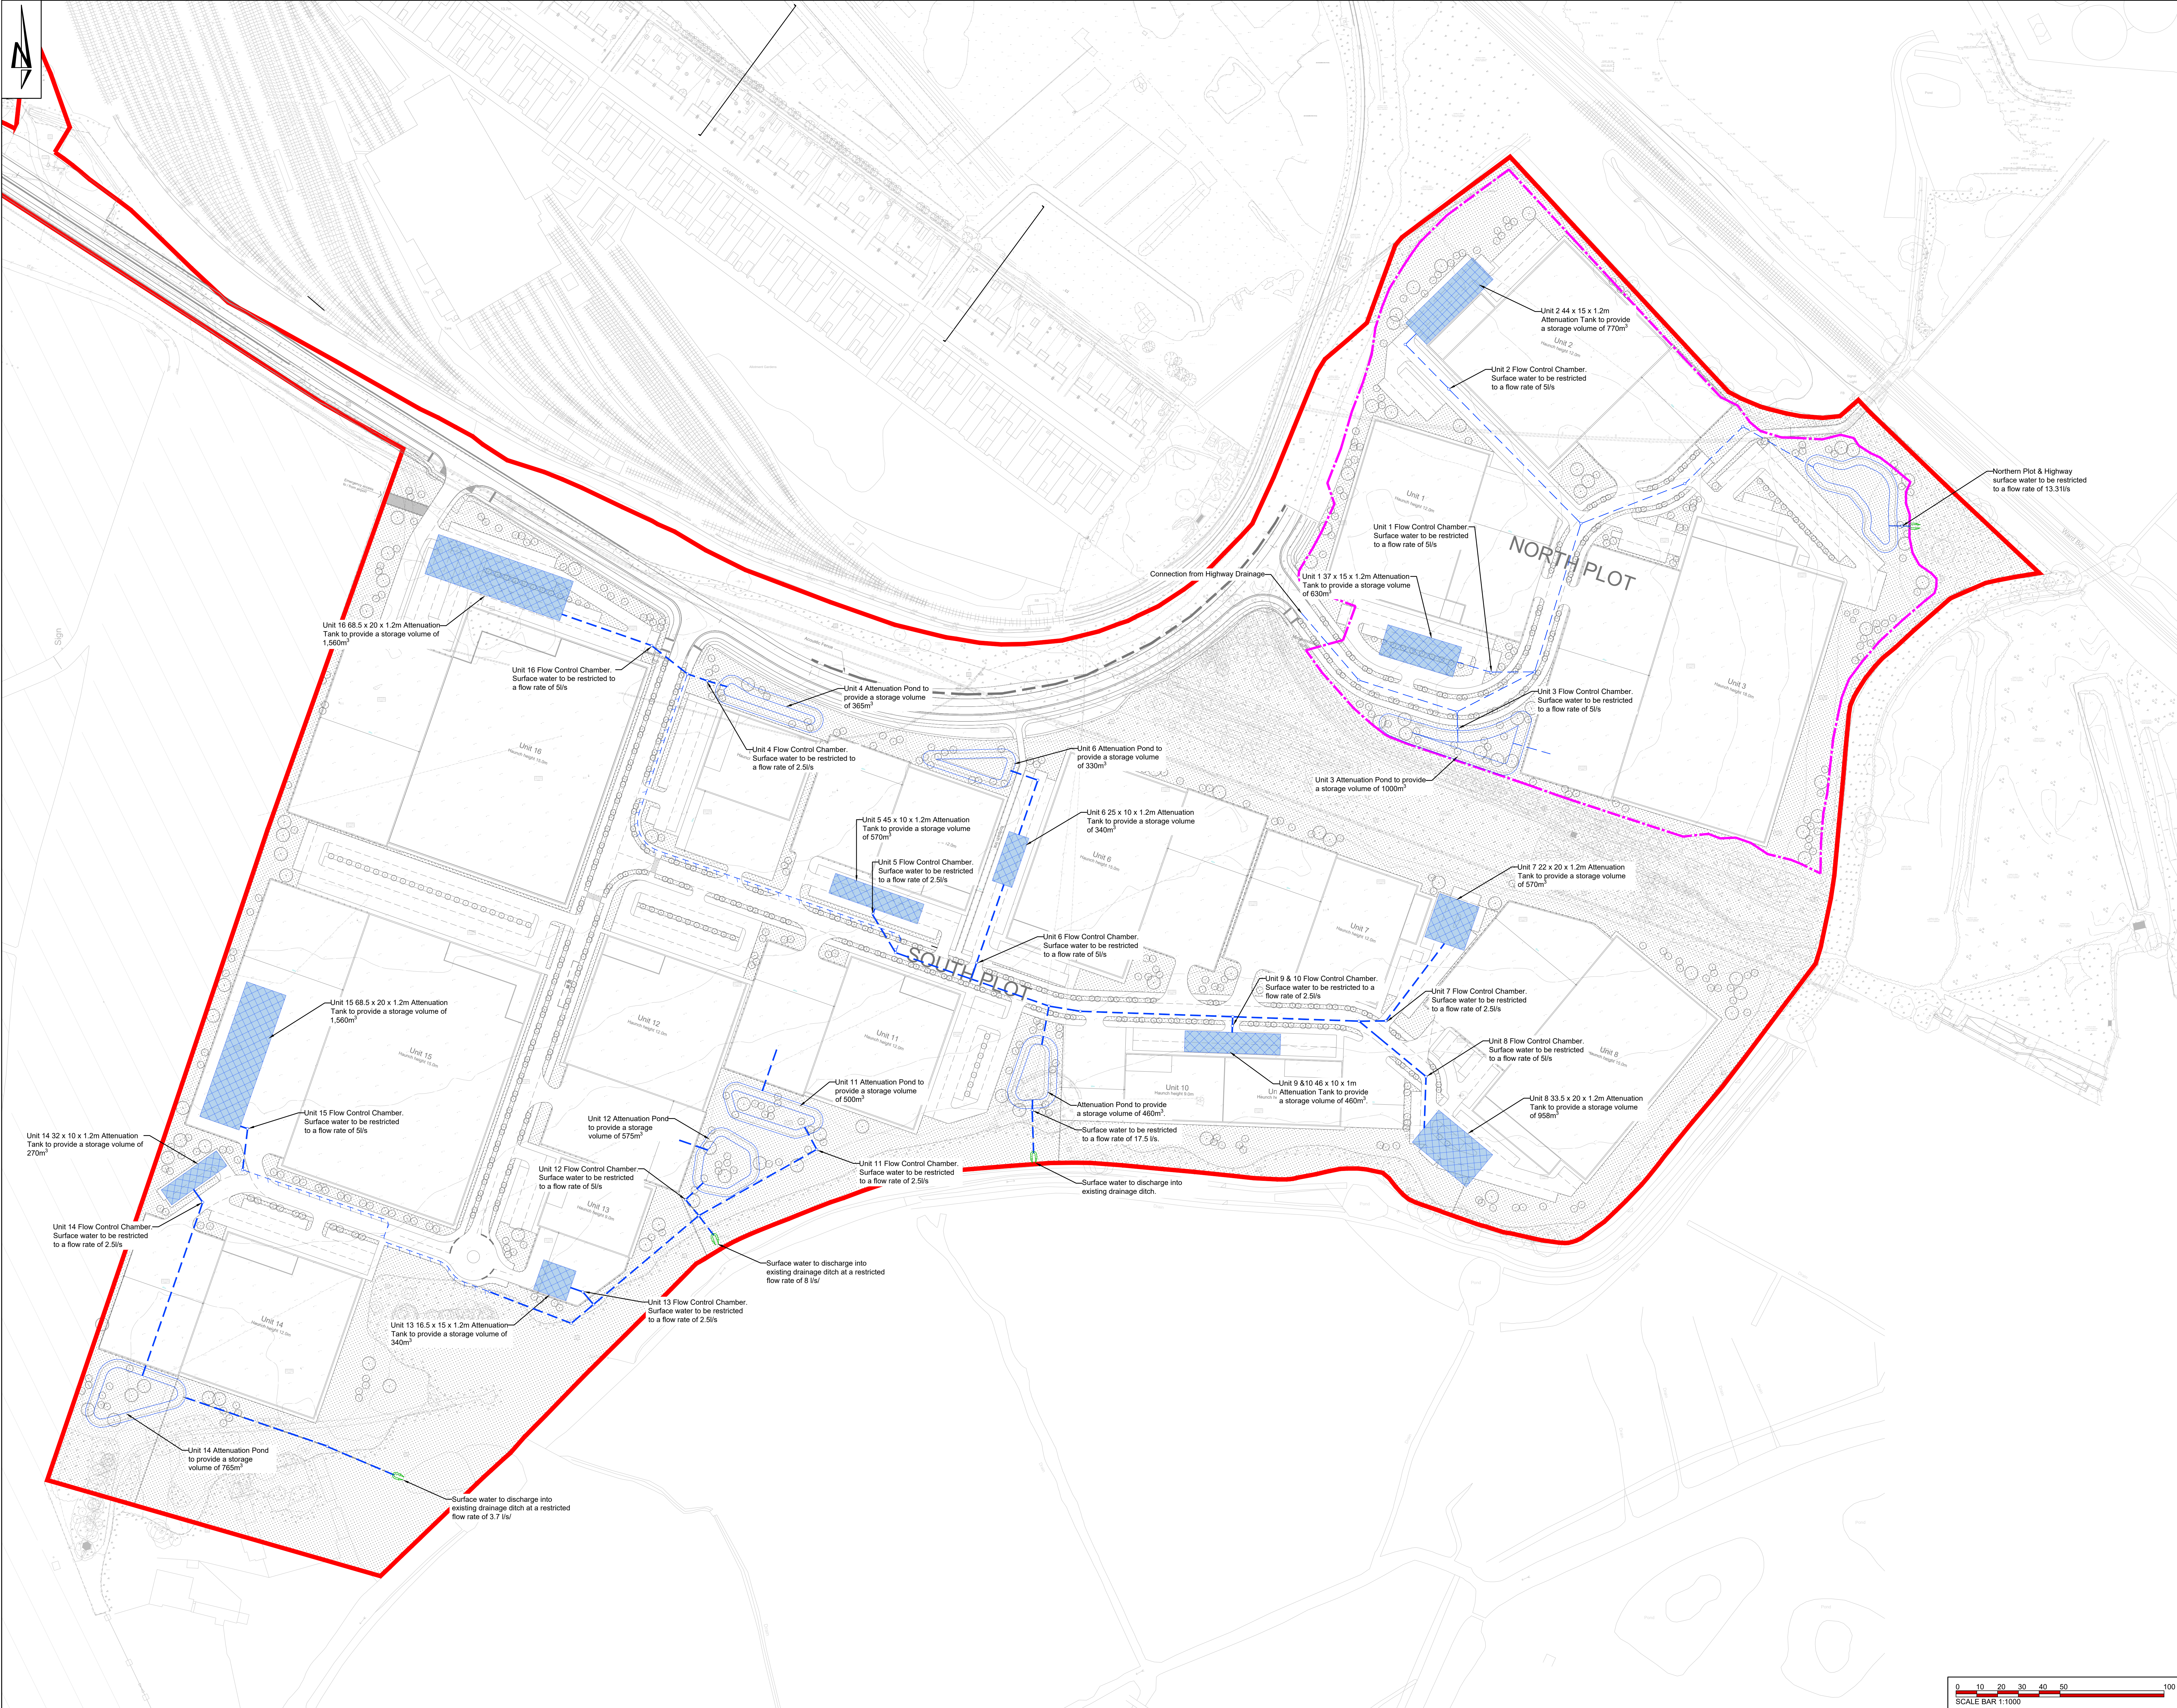

THIS DRAWING IS THE COPYRIGHT OF BURROWS GRAHAM LIMITED.

SAFETY, HEALTH AND ENVIRONMENTAL INFORMATION

IN ADDITION TO THE HAZARDS/RISKS NORMALLY ASSOCIATED WITH THE TYPES OF WORK DETAILED ON THIS DRAWING, NOTE THE FOLLOWING:

CONSTRUCTION

MAINTENANCE

DEMOLITION

IT IS ASSUMED THAT ALL WORKS WILL BE CARRIED OUT BY A COMPETENT CONTRACTOR WORKING, WHERE APPROPRIATE, TO AN APPROVED METHOD STATEMENT

GENERAL NOTES:

1. This drawing shall be read in conjunction with all the relevant architects, engineers' and service engineers drawings & specifications.

2. All units in millimeters U.O.N. on the drawing.

3. Do Not Scale off the drawing.

LEGEND

Surface Water Drainage

Surface Water Rising Main

Attenuation Tank

Attenuation Pond

Plot Boundary

Site Boundary

1. This drawing shall be read in conjunction with all the relevant architects, engineers' and service engineers drawings & specifications.

2. All units in millimeters U.O.N. on the drawing.

3. Do Not Scale off the drawing.

LEGEND

Surface Water Drainage

Surface Water Rising Main

Attenuation Tank

Attenuation Pond

Plot Boundary

Site Boundary

P11	10.04.26	MM	Updated to suit MSA Layout	JW
P10	17.02.26	MM	Updated to suit MSA Layout	JW
P09	30.01.26	MM	Updated to suit Ecologist comments	JW
P08	23.01.26	MM	Southern plots discharge rate amended	JW
P07	22.12.25	MM	Updated to suit MSA layout	JW
P06	04.12.25	JB	Swale to southern plot omitted	JW
P05	03.12.25	JB	Surface Water outfall locations amended	JW
P04	20.08.25	MM	Surface Water flow rates amended	JW
P03	06.05.25	MM	Updated to suit planning requirement	JW
P02	30.04.25	JB	Southern plot drainage amended to suit latest Architect layout	JW
P01	05.02.25	JB	Issued for information	JW
REV	DATE	BY	DESCRIPTION	CHKD

Burrows Graham

North Office:
5 Ambassador Place, Stockport Road,
Altrincham WA15 6DN
Tel: +44 (0)161 804 8046
South Office:
Buckingham House, Dover Mews,
High Street, Bathurst HPA 2BL
Tel: +44 (0)1422 506 402

CLIENT
BLOC GROUP

PROJECT
BLOC NAVIGATION QUARTER
SOUTHAMPTON

DRAWING TITLE
INDICATIVE DRAINAGE LAYOUT

BGL PROJECT NUMBER 30228	DRAWING STATUS PRELIMINARY	OFFICE NORTH
SCALE @ A0 1:1000	DATE 05.02.2025	DRAWN BY JB
DRAWING No 30228-BGL-XX-XX-SK-C-00012	CHECKED BY JW	REV P11