
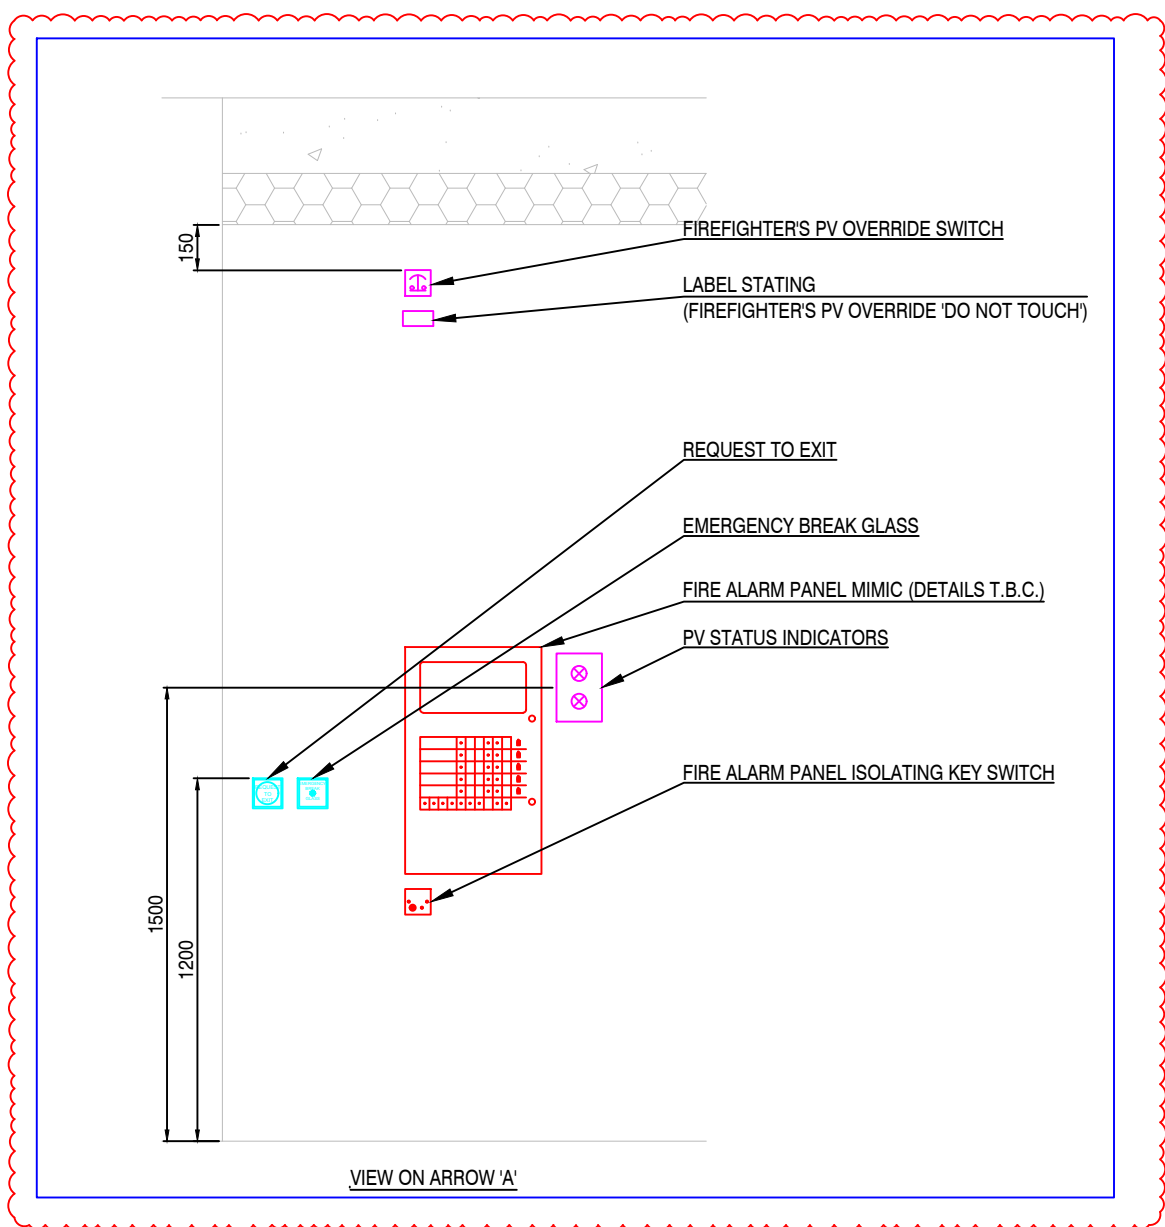
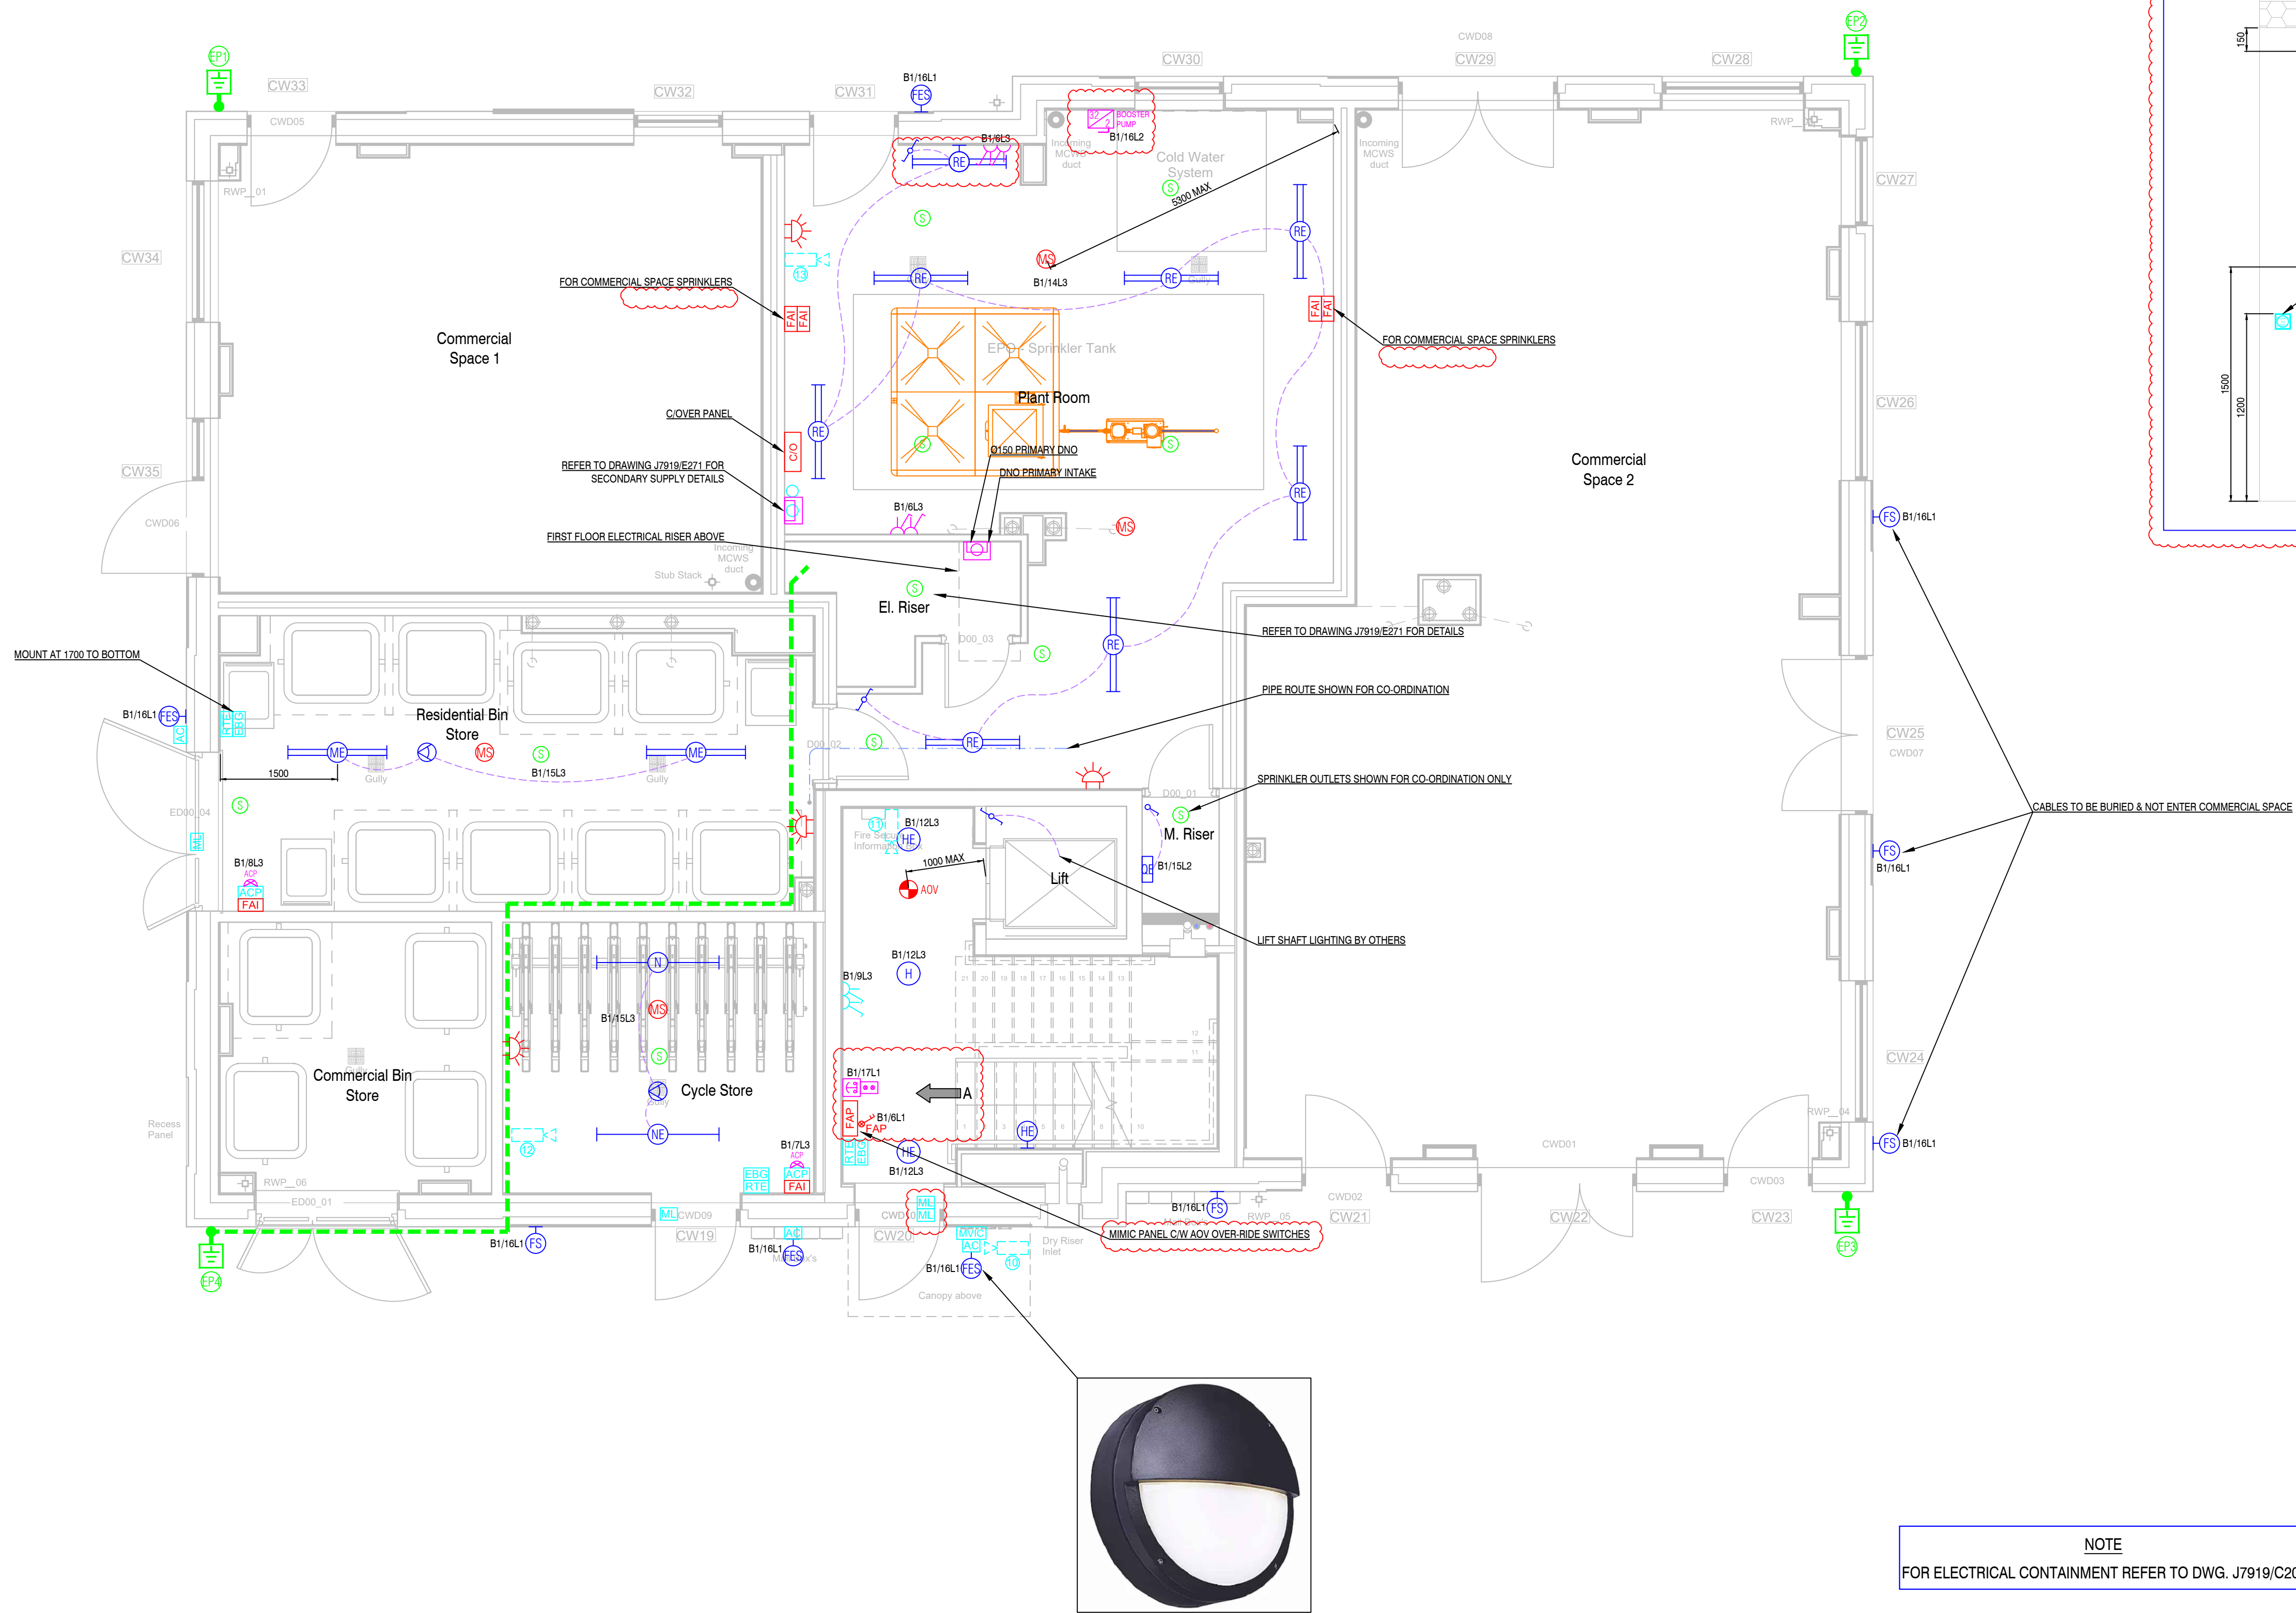


SEE DRAWING No J7919/E401  
FOR LEGEND, NOTES AND DETAILS

# FOR CONSTRUCTION

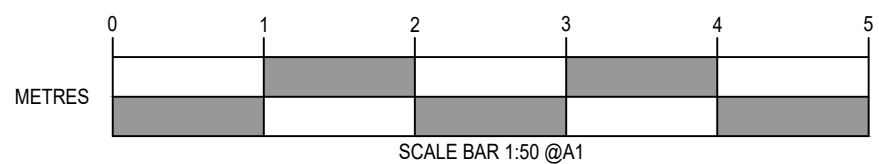

NOTE

FOR ELECTRICAL CONTAINMENT REFER TO DWG. J7919/C201

DISTANCES FROM EDGE OF SPRINKLERS


DOWN LIGHT - 152mm

DETECTOR - 500mm

|     |      |            |                                                           |
|-----|------|------------|-----------------------------------------------------------|
|     |      |            |                                                           |
| D   | A.P. | 20-12-2023 | EQUIPMENT POSITIONS UPDATED                               |
| C   | A.P. | 06-09-2023 | GENERAL UPDATE, CIRCUIT REFERENCES & FIRST FIX CCTV ADDED |
| B   | A.P. | 02-12-2022 | CONTAINMENT UPDATED                                       |
| A   | T.H. | 28-04-2022 | COORDINATED WITH SPRINKLER LAYOUT                         |
| REV | DRN  | DATE       | DESCRIPTION                                               |

SCHEME EASTLEIGH BOROUGH COUNCIL  
EASTLEIGH POST OFFICE

|       |                                                                  |
|-------|------------------------------------------------------------------|
| TITLE | BLOCK B<br>GROUND FLOOR - COMMUNAL<br>ELECTRICAL SERVICES LAYOUT |
|-------|------------------------------------------------------------------|

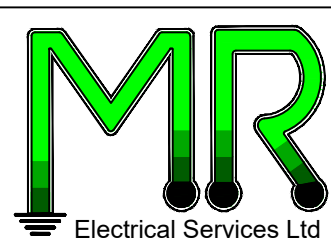

1.2 CENTRAL POINT, KIRPAL ROAD  
PORTSMOUTH, PO3 6FH  
Tel: (023) 9281 6666 Fax: (023) 9281 6666  
E-mail: [enquiry@rmelectrical.co.uk](mailto:enquiry@rmelectrical.co.uk)



© This design is the property of MR Electrical Services Limited and shall not be reproduced or copied in any way or conveyed to a third party without the owners written permission

|          |             |         |                |
|----------|-------------|---------|----------------|
| SCALE    | 1:50 @ A1   | DATE    | FEBRUARY 2022  |
| DRAWN    | TOM HEPPELL | CHECKED | GRAHAM WIGGINS |
| DRG. NO. | J7919/E201  |         | REVISION<br>D  |