
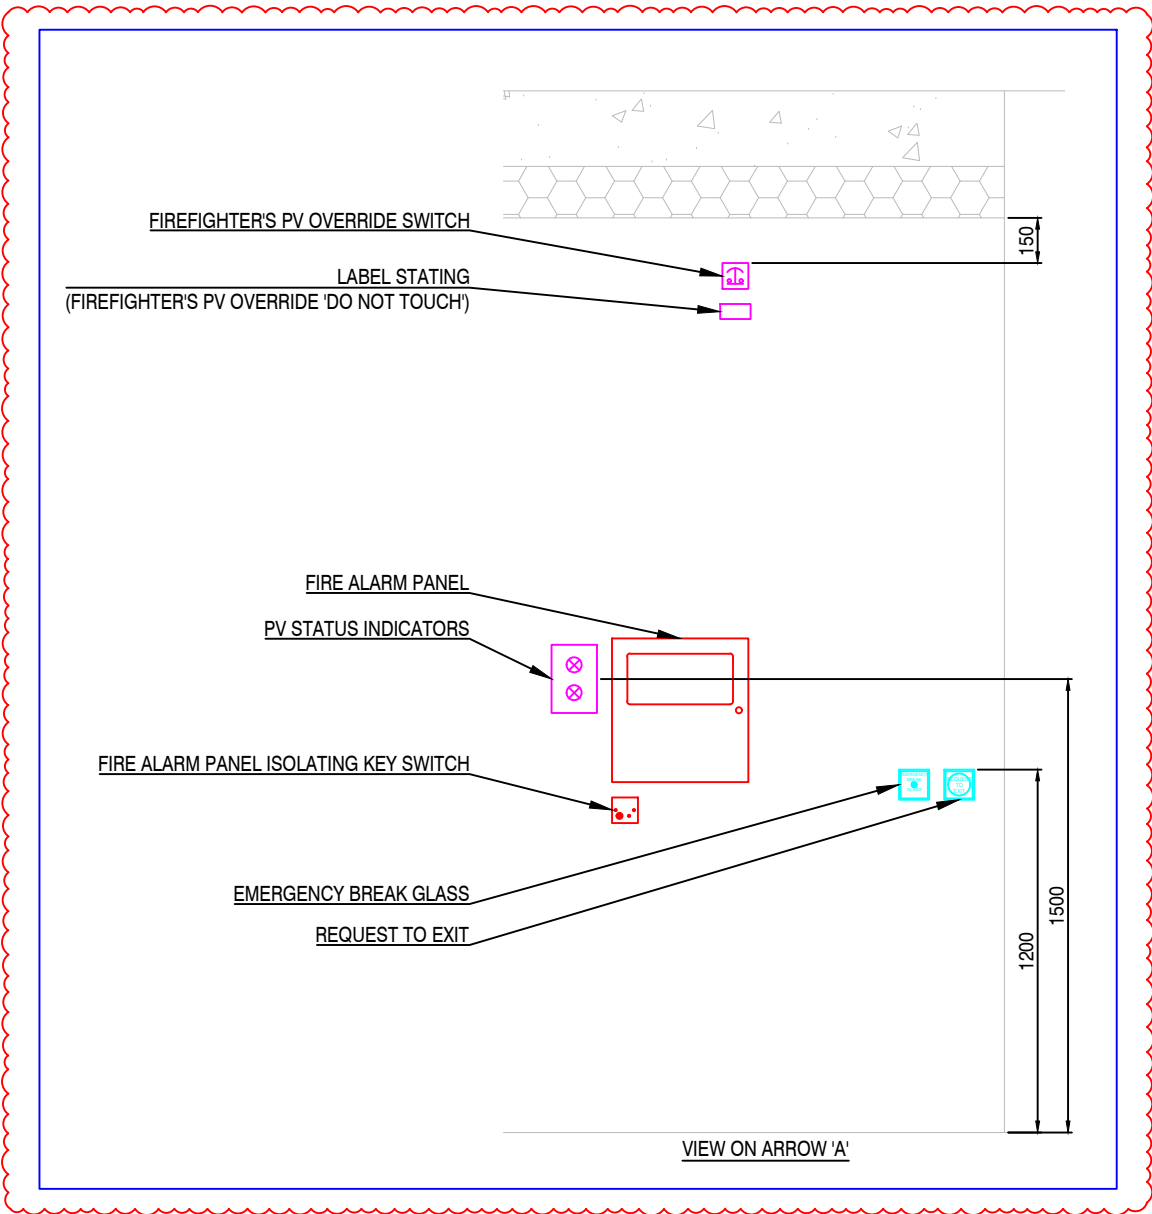


SEE DRAWING No J7919/E401
FOR LEGEND, NOTES AND DETAILS

FOR CONSTRUCTION

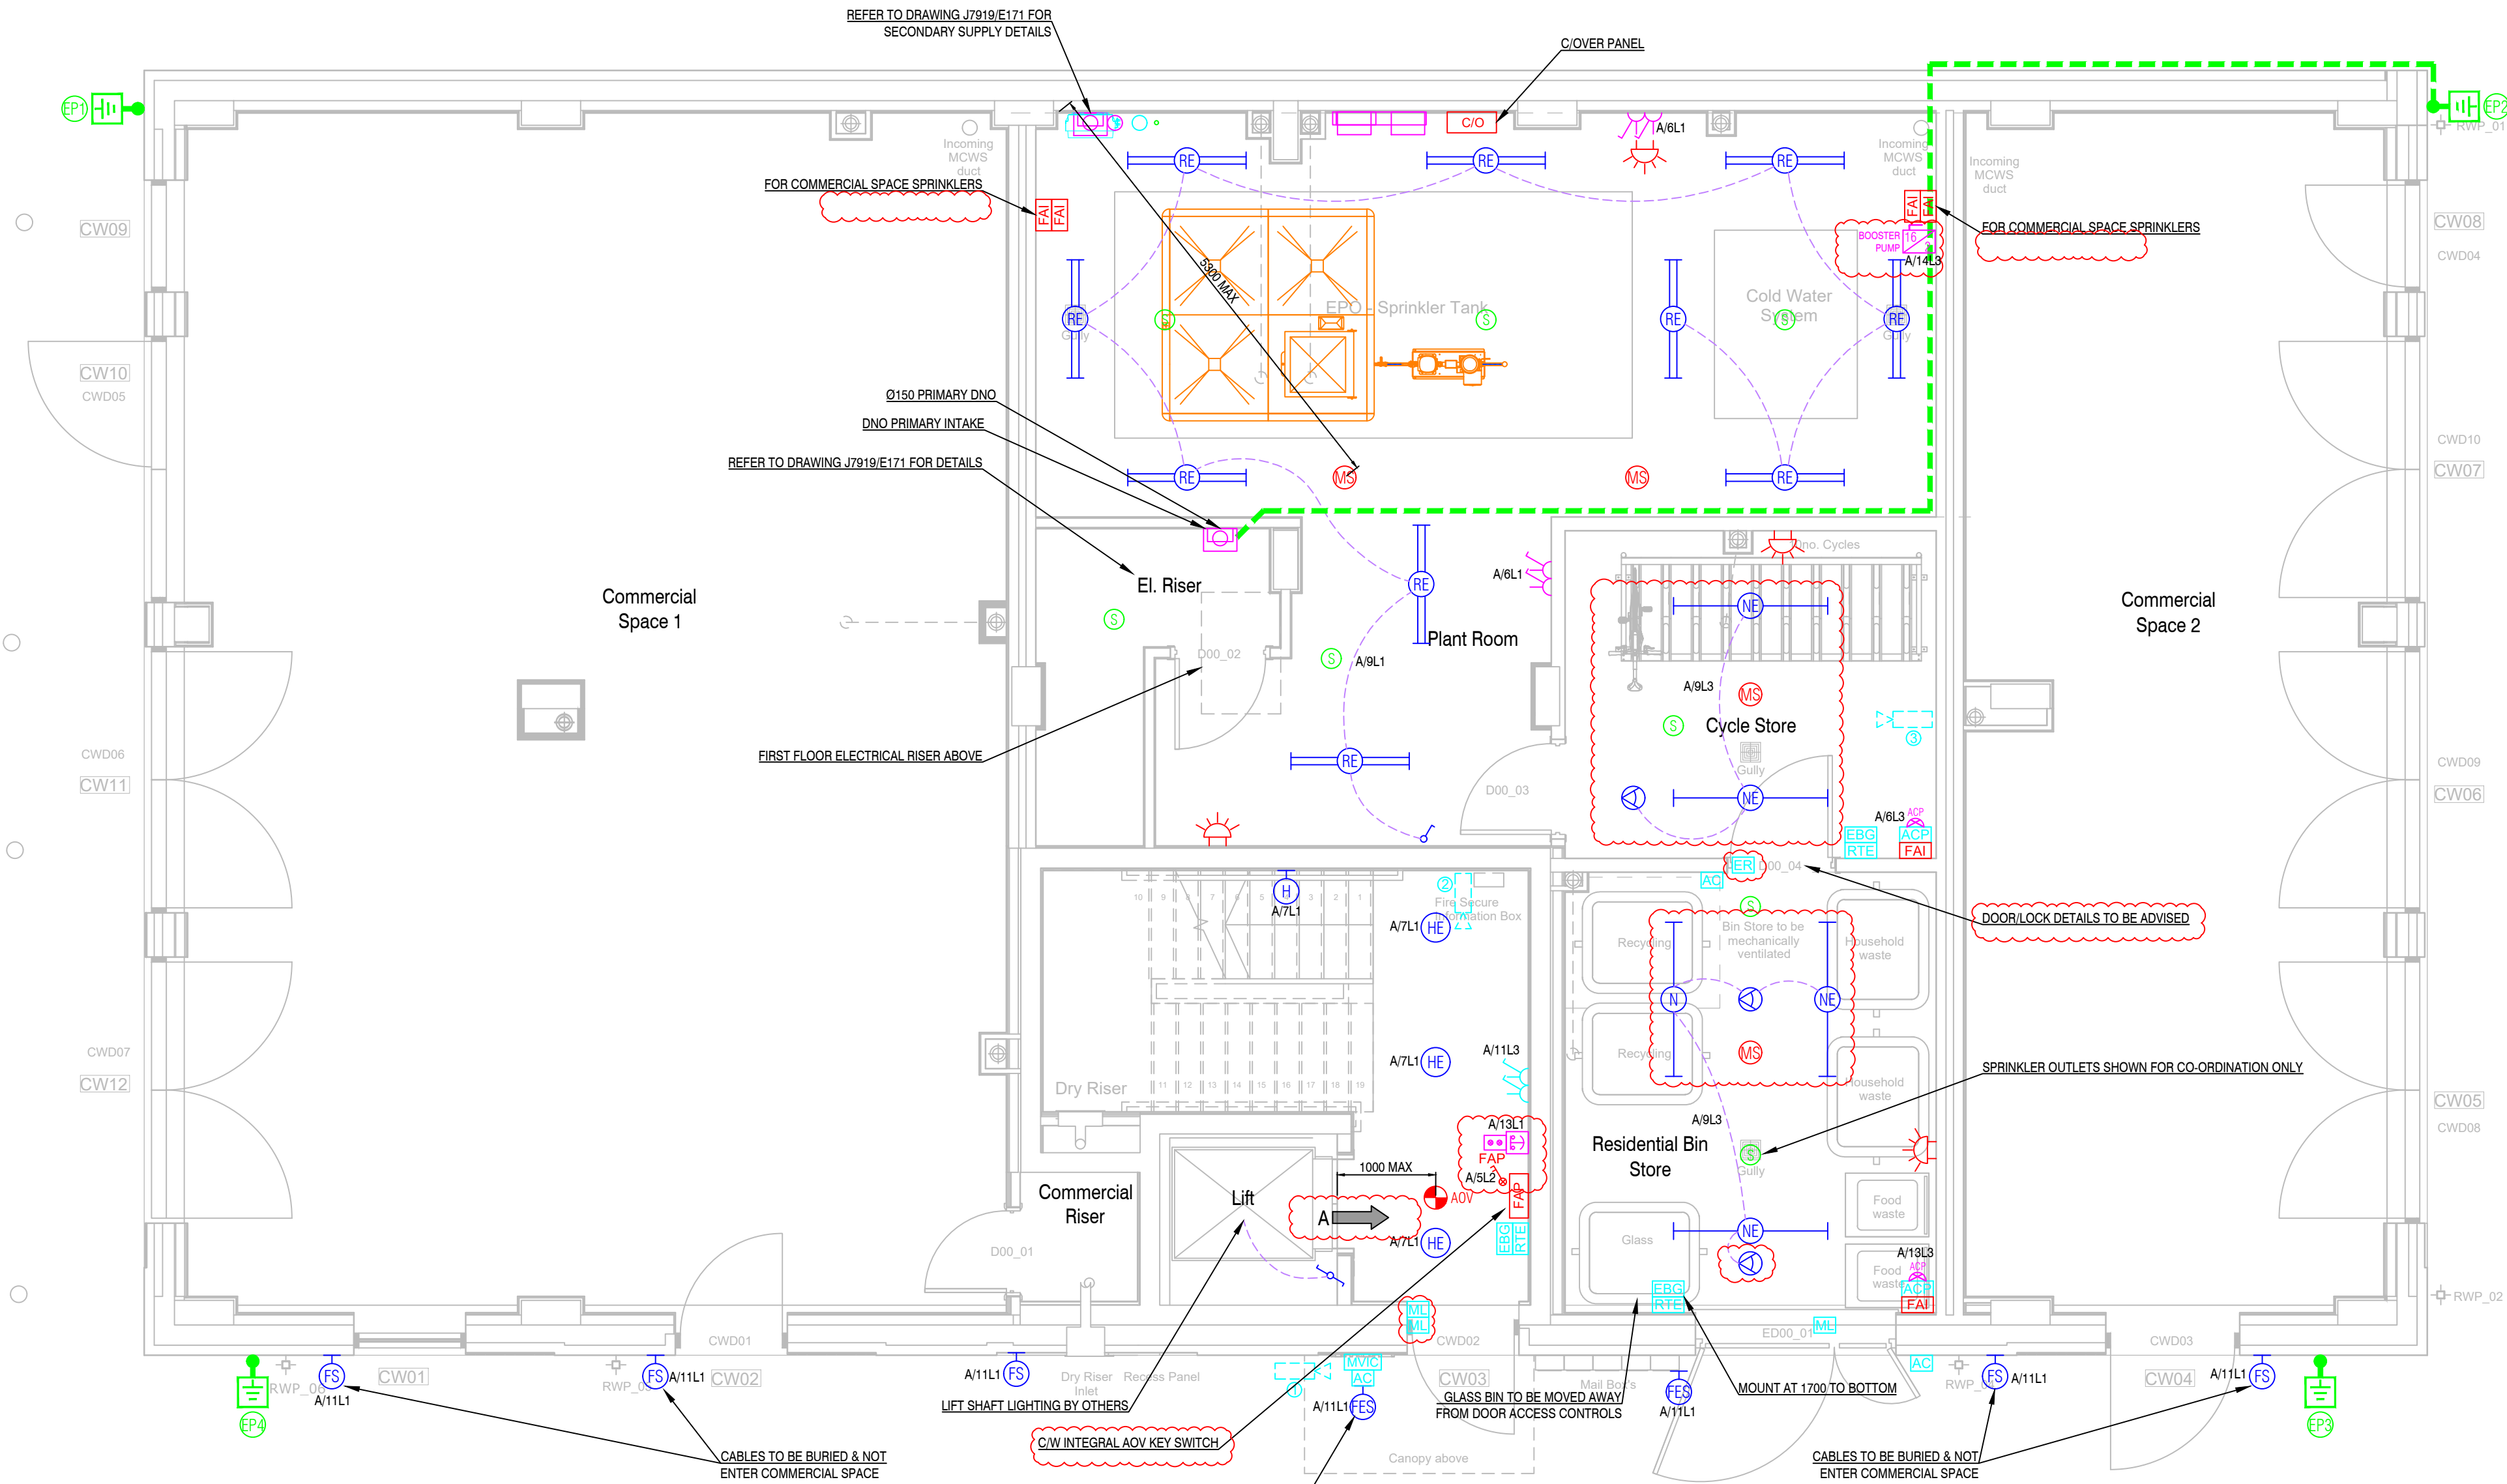

NOTE
FOR ELECTRICAL CONTAINMENT REFER TO DWG. J7919/C101

DISTANCES FROM EDGE OF SPRINKLERS
DOWN LIGHT - 150mm
DETECTOR - 500mm
PENDANTS - 500mm

D	A.P.	20-12-2023	EQUIPMENT POSITIONS UPDATED
C	A.P.	06-09-2023	GENERAL UPDATE, CIRCUIT REFERENCES & FIRST FIX CCTV ADDED
B	A.P.	02-12-2022	CONTAINMENT UPDATED
A	T.H.	26-04-2022	COORDINATED WITH SPRINKLER LAYOUT
REV	DRN	DATE	DESCRIPTION
SCHEME			
EASTLEIGH BOROUGH COUNCIL EASTLEIGH POST OFFICE			
TITLE			
BLOCK A GROUND FLOOR - COMMUNAL ELECTRICAL SERVICES LAYOUT			
1:2 CENTRAL POINT, KIRPAL ROAD PORTSMOUTH, PO5 4PH Tel: (023) 9291 9999 Fax: (023) 9291 9998 E-mail: enquiry@mr-electrical.co.uk			
This design is the property of MR Electrical Services Limited and shall not be reproduced or copied in any way or conveyed to a third party without the owners written permission			
SCALE	1:50 @ A1	DATE	FEBRUARY 2022
DRAWN	TOM HEPELL	CHECKED	GRAHAM WIGGINS
DRG. NO.	J7919/E101	REVISION	D