


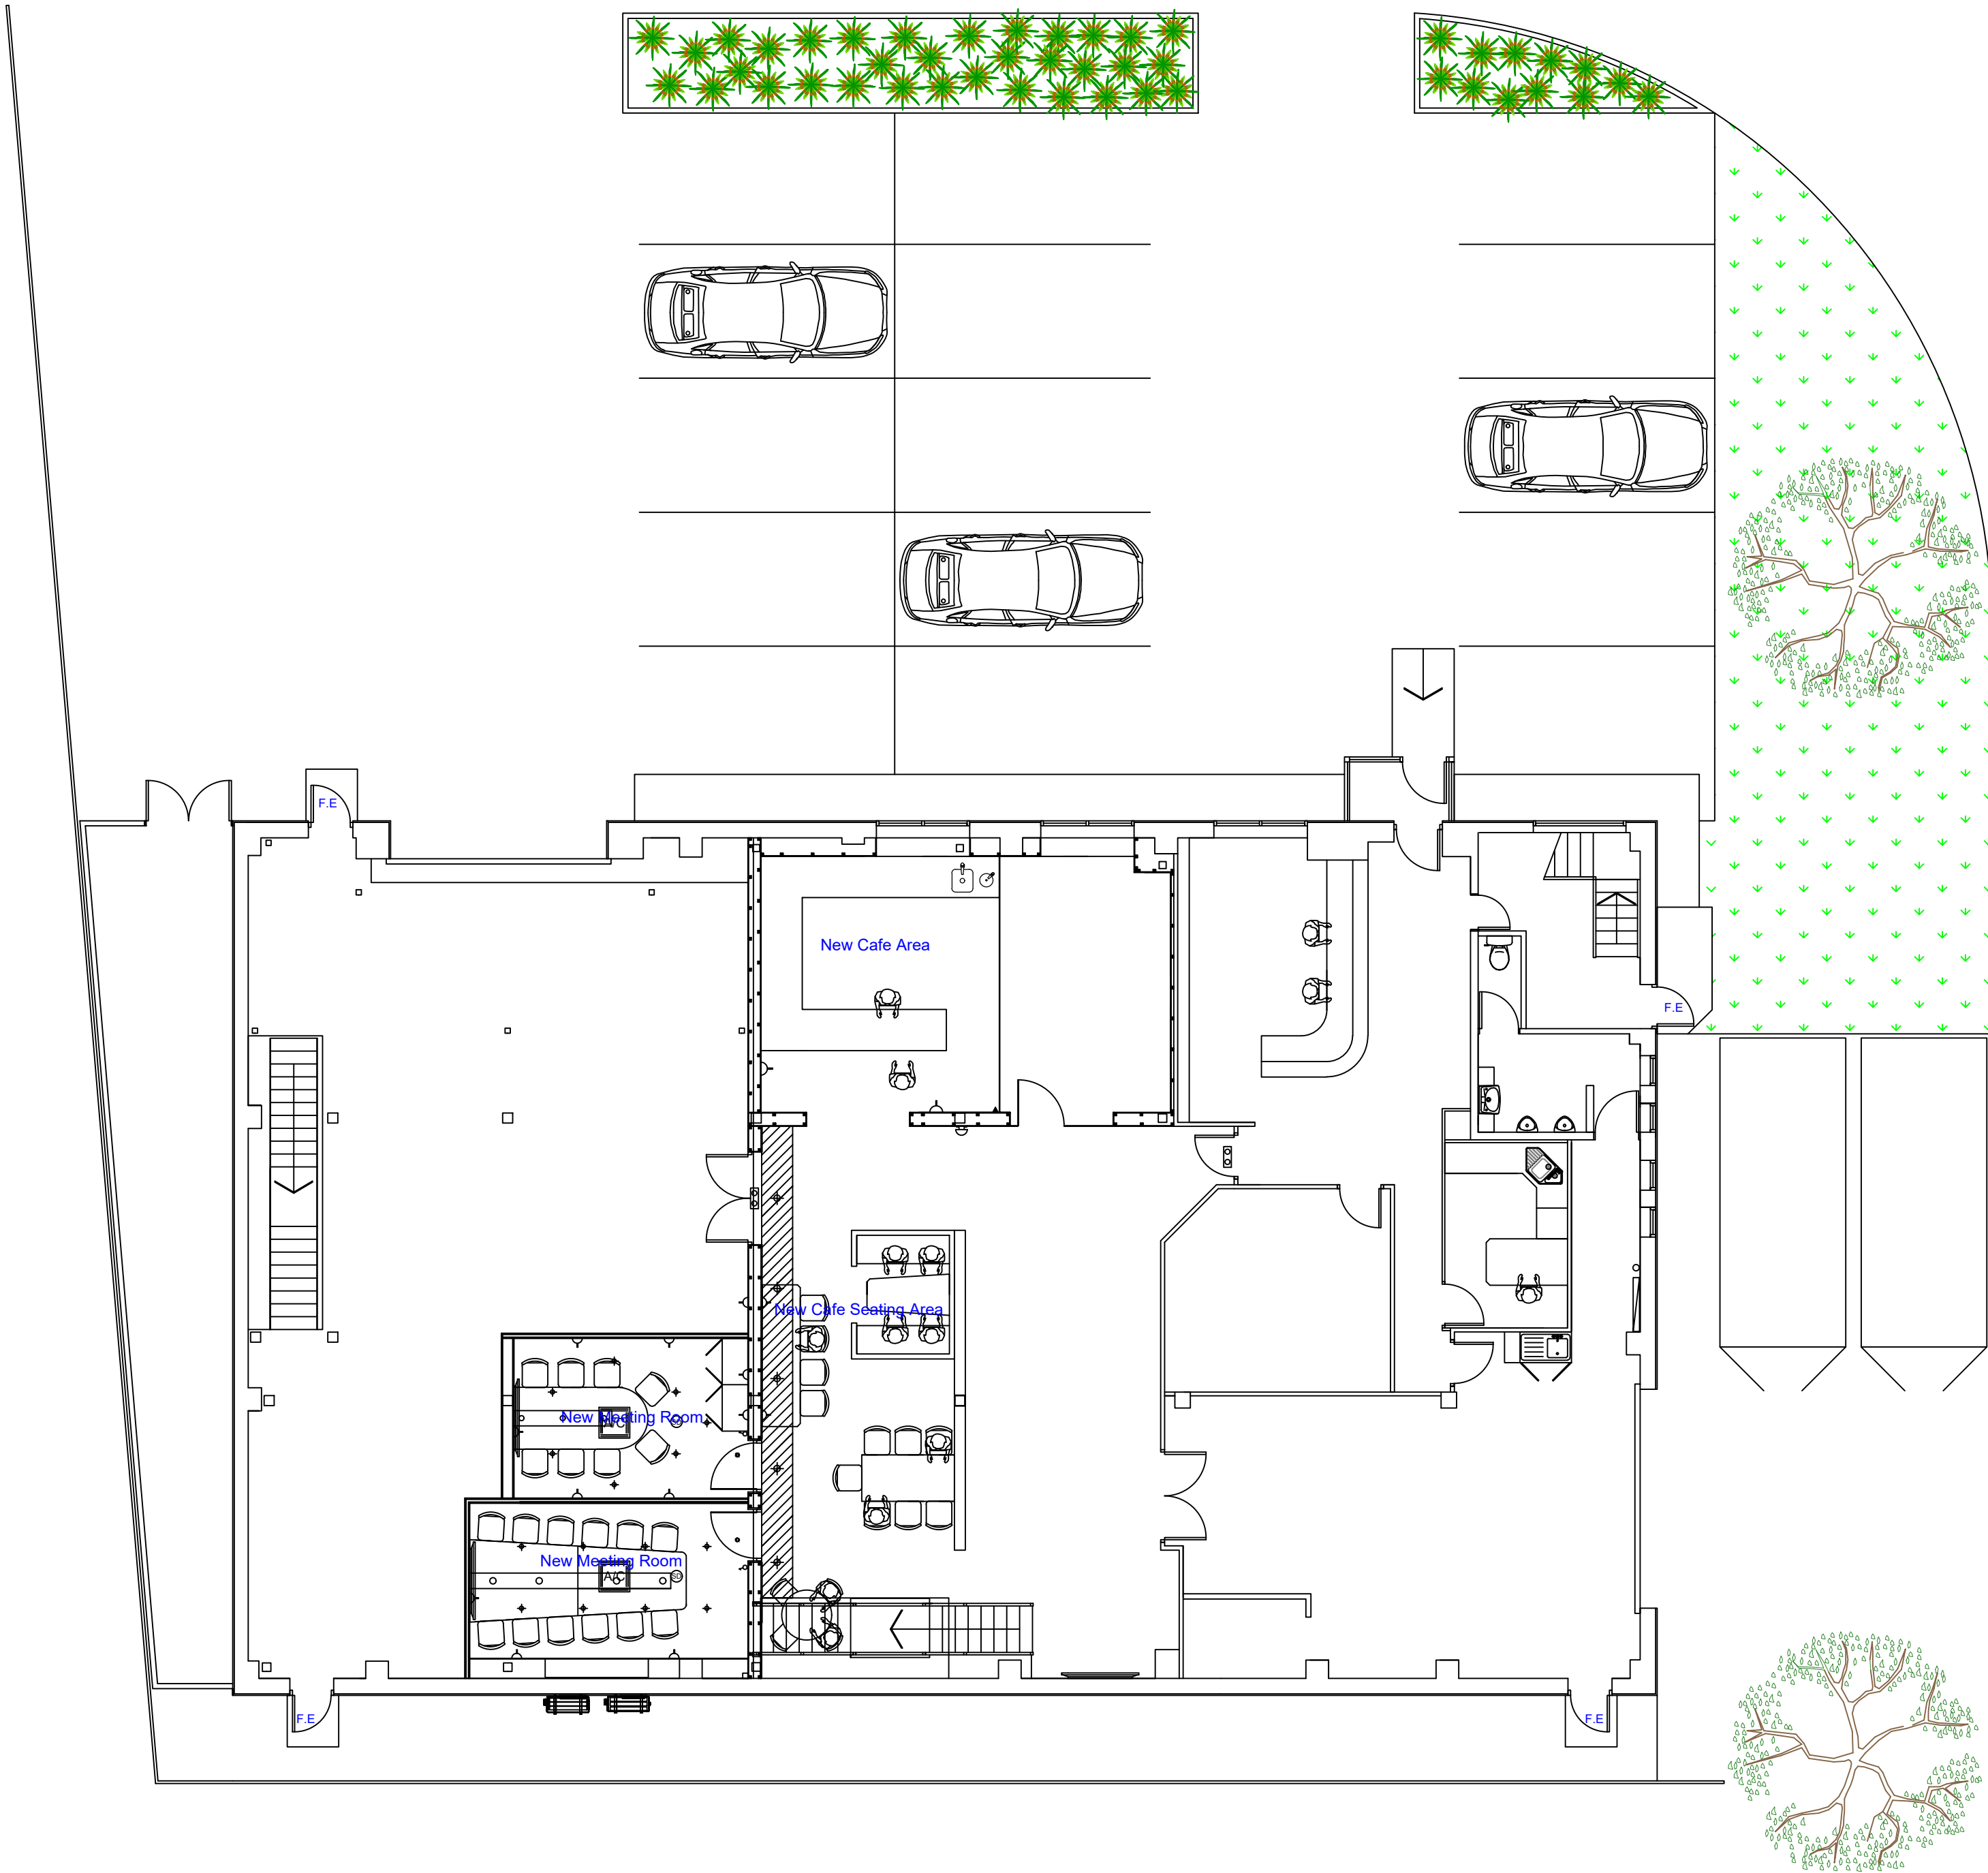

Proposed Ground Floor Plan

Notes:
All dimensions must be checked on site and not scaled from this drawing. This drawing is property of Wessex Interiors Ltd and in no circumstances should this drawing be used without prior notice given to Wessex Interiors Ltd

Legend	
Symbol	Denotes
	600 x 600 x 4 Tube Recessed Modular Light
	1200 x 600 x 4 Tube Recessed Modular Light
	3hr Non Maintained Bulkhead Emergency Light
	Smoke Detector
	3hr Non Maintained Emergency Light c/w euro running man legend
	Double 13amp switched socket
	Spotlight
	Bulkhead Light
	6" Twin Fluorescent Tube
	Ceiling Mounted Air Conditioning Unit
	Wall Mounted Heater Unit
	Wall Mounted Air Conditioning Unit
	Telephone point / Data Point
	3 Compartment Floor Boxes
	Fire Alarm Call Point
	Fire Alarm Sounder
	Radiator
	Switch
	Handrail and Handrail Posts
	Sliding Gate
	Suspended Ceiling
	Perlins
	Main Beams
	Mezzanine Floor Line
	Partitioning
	Mezzanine Floor Columns

Rev	Date	Description
-----	------	-------------

© copyright
Client
HAYWOOD OFFICE SERVICES LTD

Address
**Trafalger Close
Chandlers Ford Indusrtrial Estate
Eastleigh
SO53 4BW**

Contact
Mark Haywood

Tel.
02380 254454


Drawing Title
Proposed Refurbishment Project

Scale
1:100

Date
29.01.2024

Drawn by
Gary

Dwg. No HO8440	Rev. 0
--------------------------	------------------

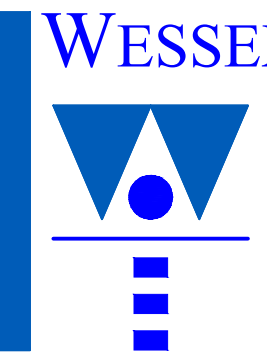

WESSEX INTERIORS
Wessex Interiors Limited
Unit 4, Rushington Court
Chapel Lane, Totton
Southampton, SO40 9NA
Telephone: 023 8066 3100
Fax: 023 8066 3191
Website: www.wessexinteriors.co.uk
Email : info@wessexinteriors.co.uk