
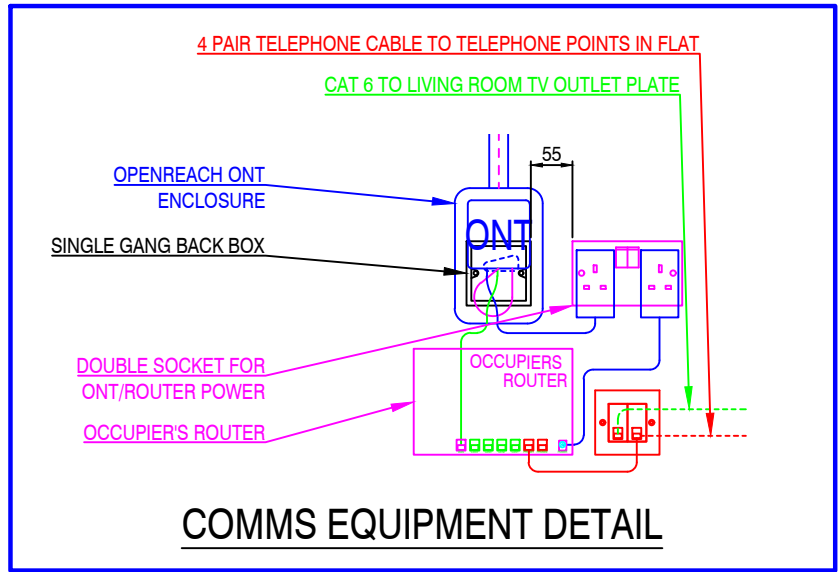
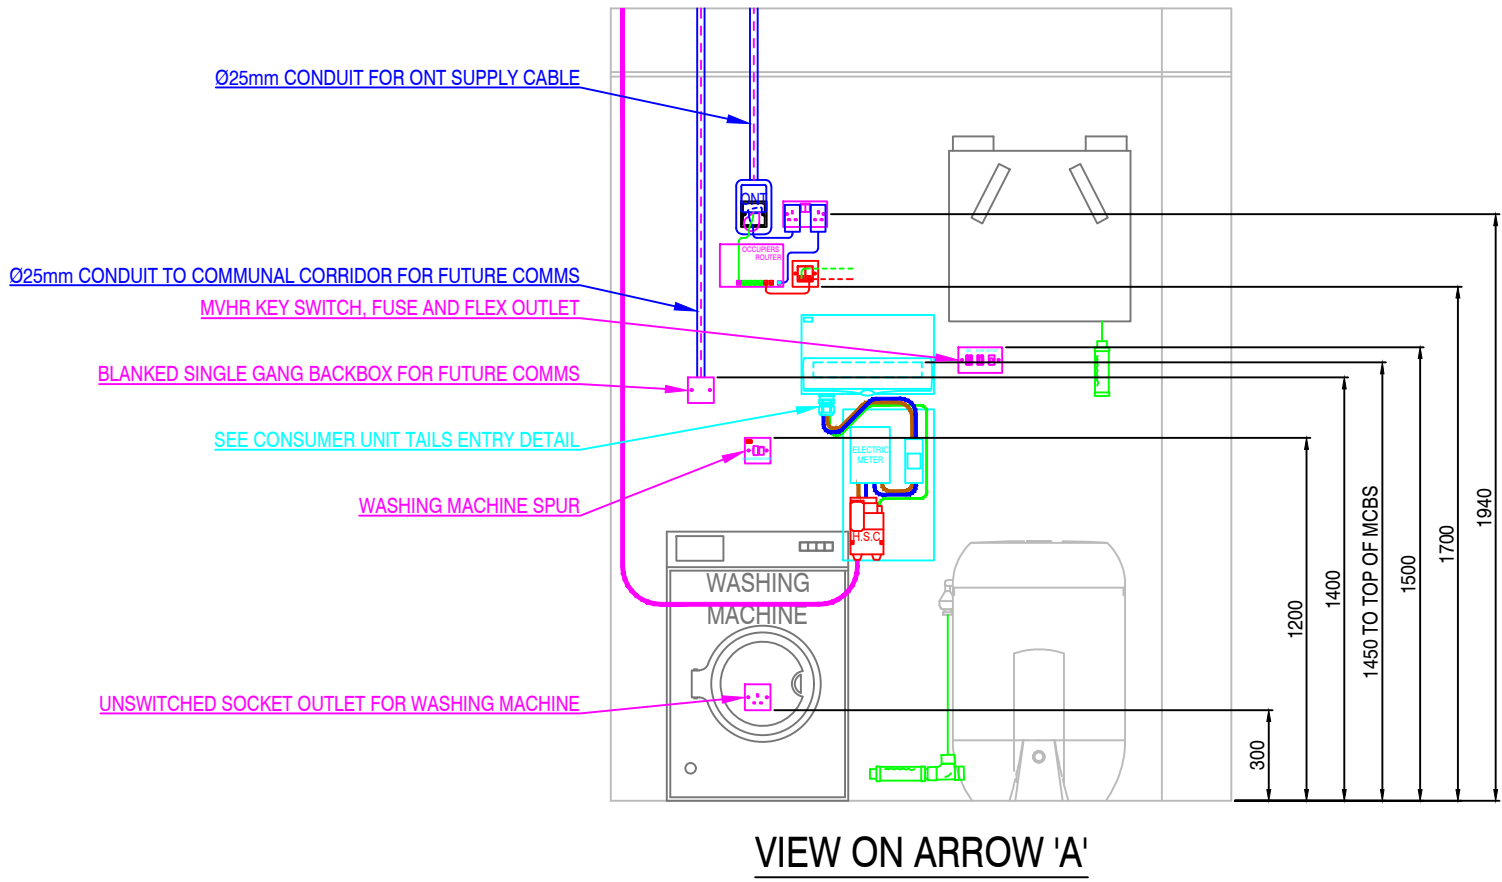
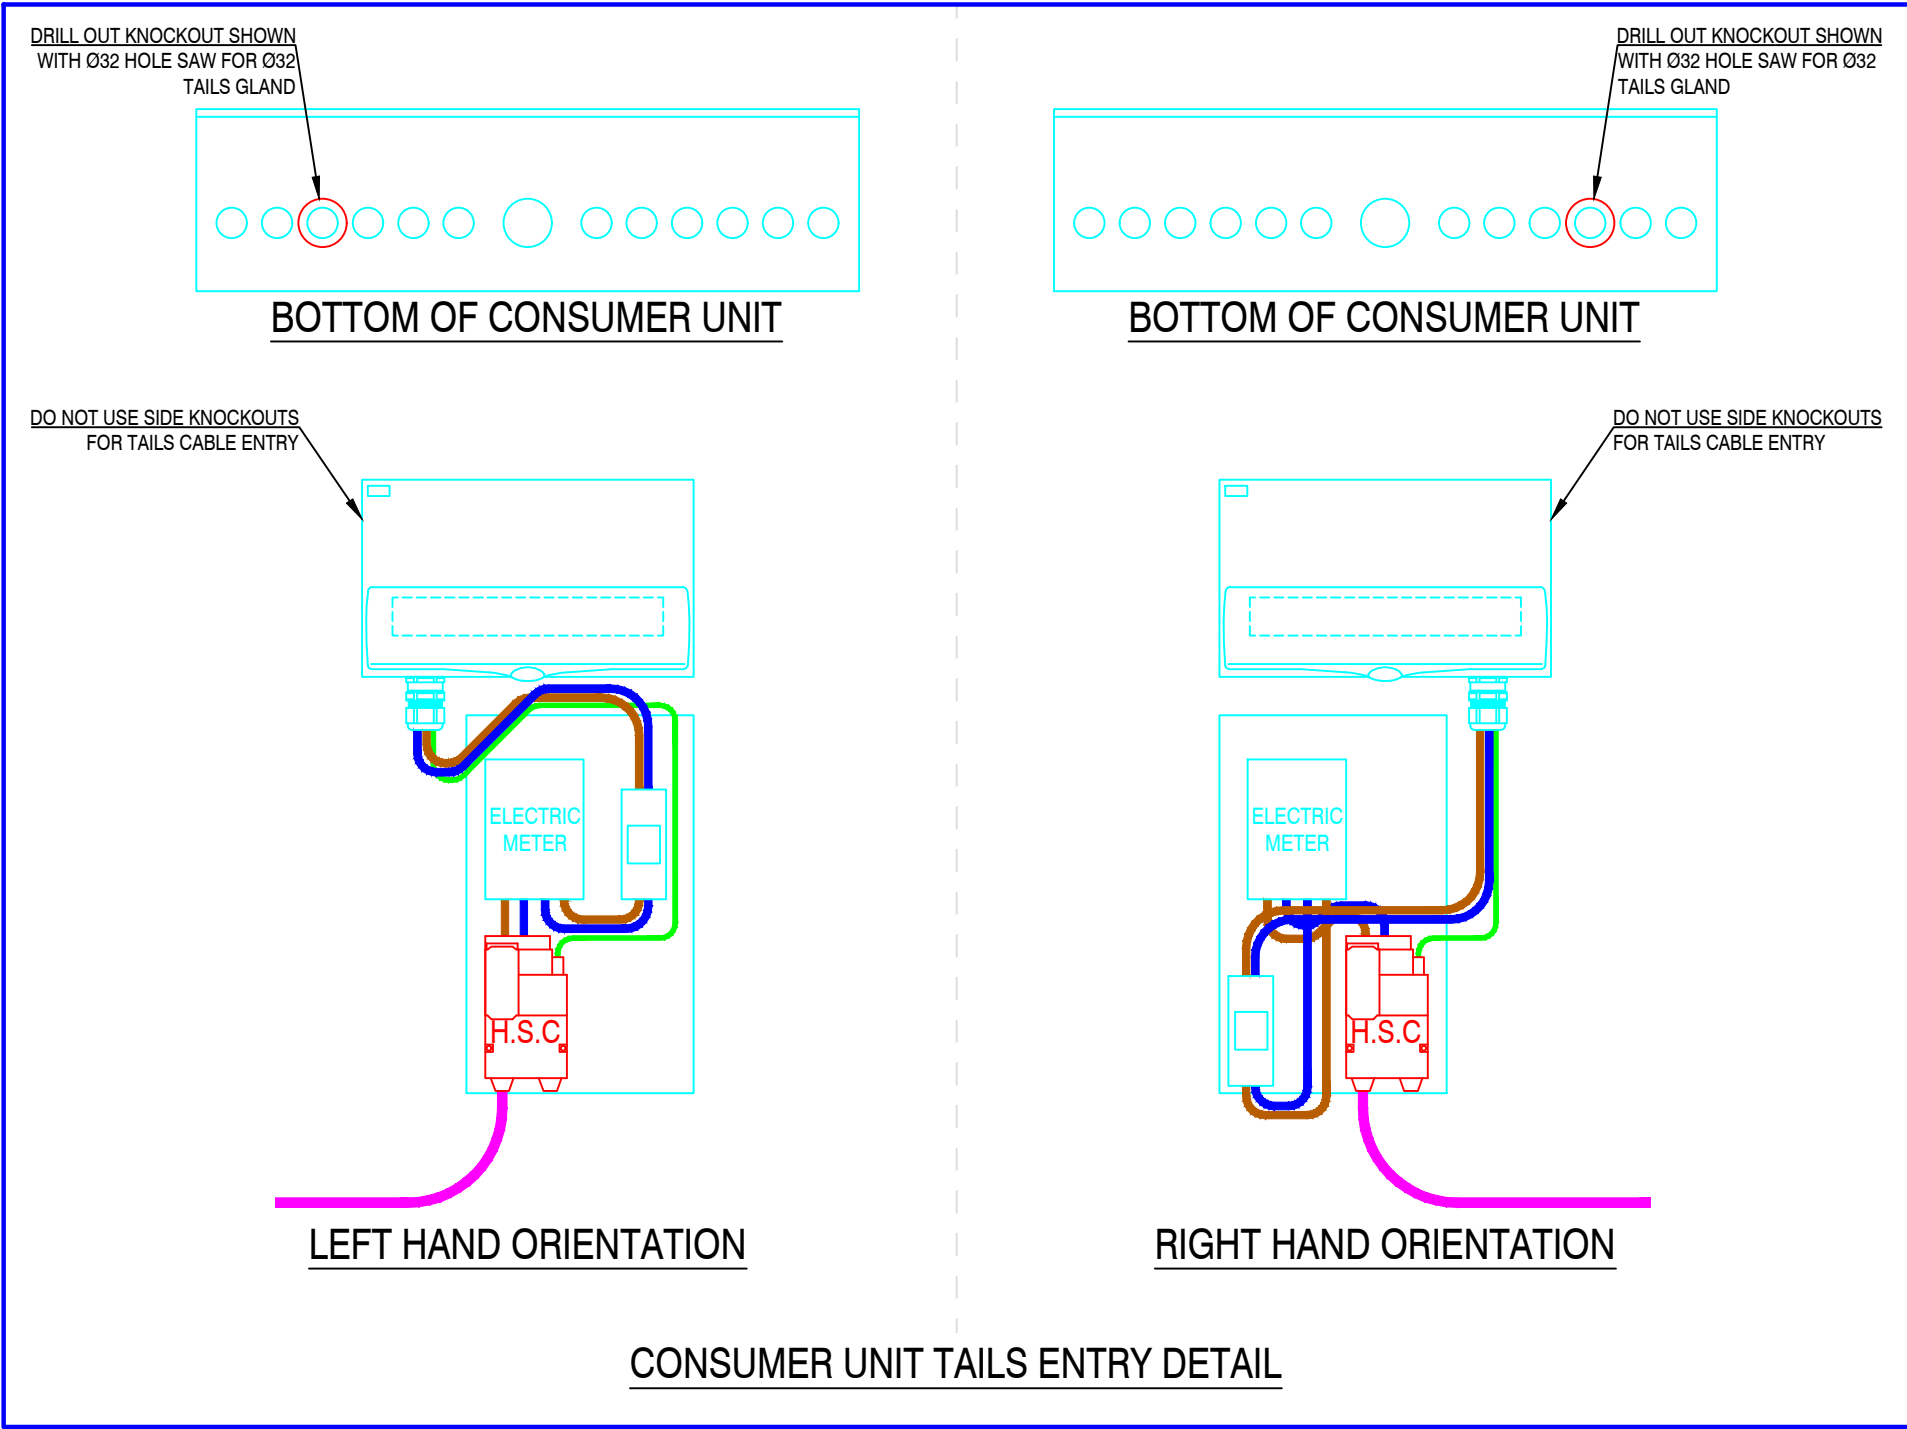


SEE DRAWING No J7919/E401
FOR LEGEND, NOTES AND DETAILS

FOR CONSTRUCTION

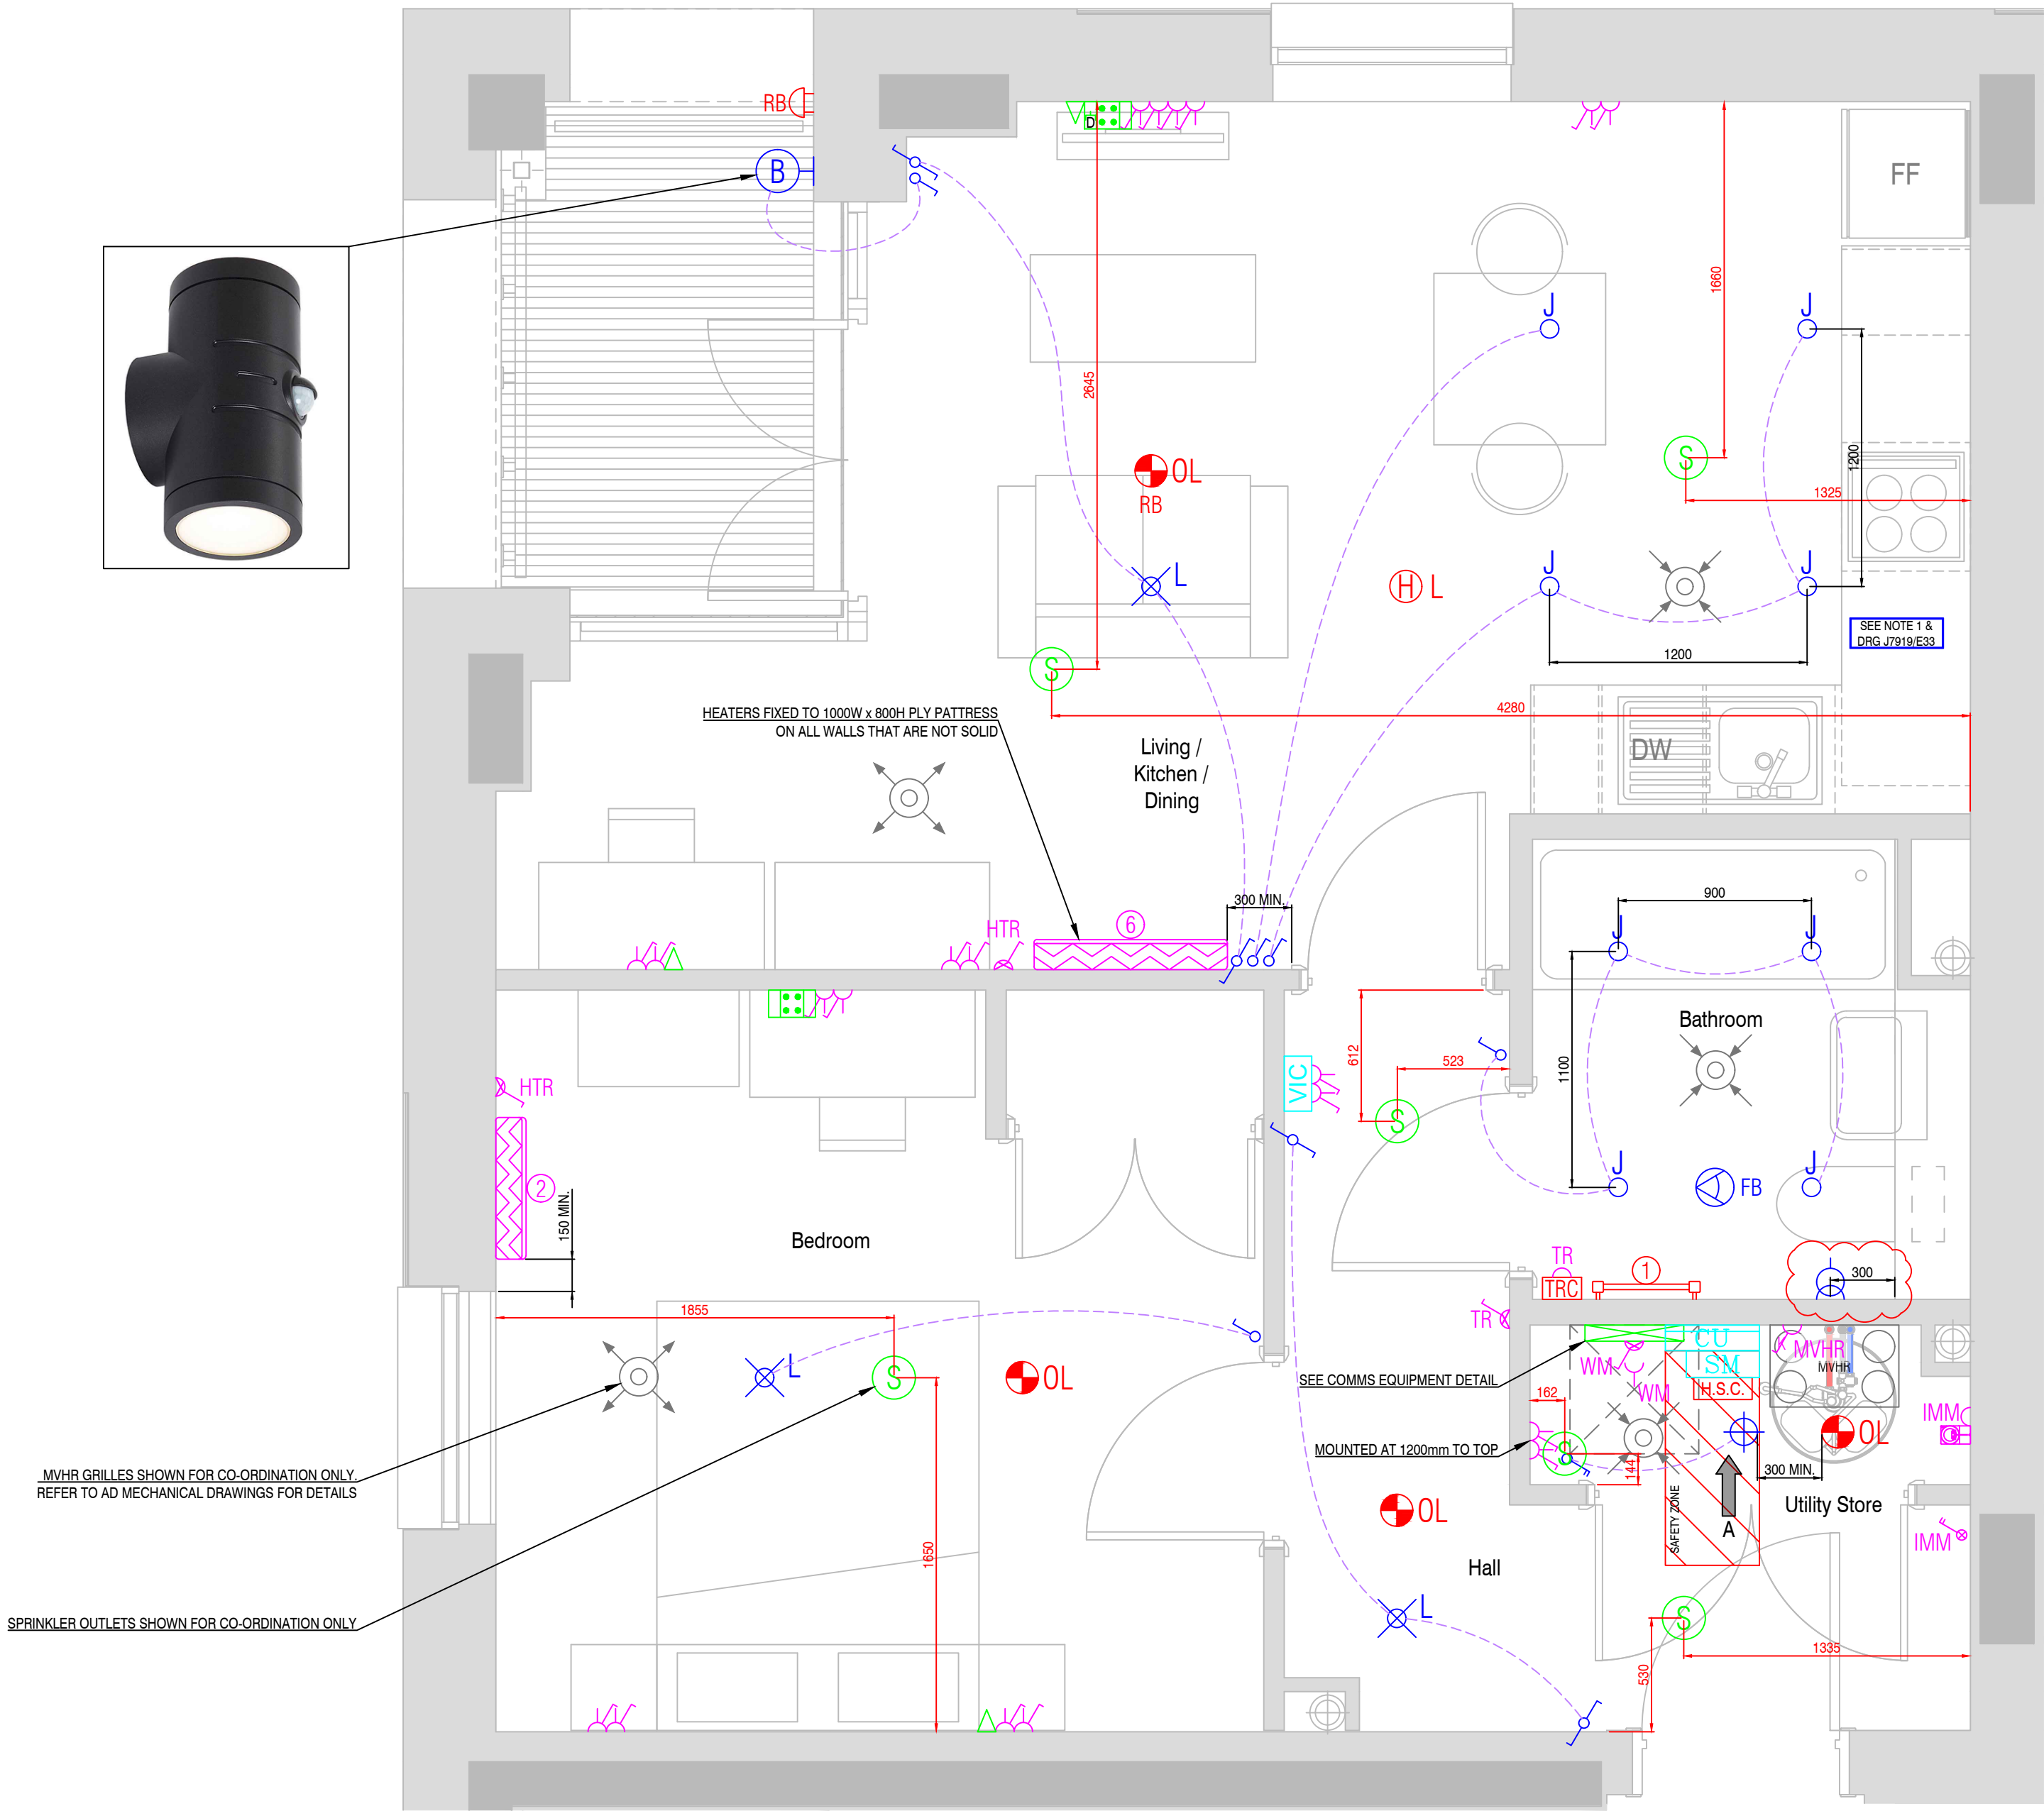

FURNITURE LAYOUTS ARE INDICATIVE ONLY, ALL FURNITURE & OBSTRUCTIONS (e.g. SHELVES) MUST BE KEPT A MINIMUM OF 150mm AWAY FROM ELECTRIC HEATERS. REFER ALSO TO THE HEATER'S INSTRUCTION MANUAL FOR FURTHER GUIDANCE.

DISTANCES FROM EDGE OF SPRINKLERS	
DOWN LIGHT -	150mm
DETECTOR -	500mm
PENDANTS -	500mm

F	A.P.	14-12-2023	SHOWER OUTLET POSITION UPDATED
E	T.H.	30-11-2023	HEATER PHYSICAL DIMENSIONS UPDATED
D	T.H.	10-10-2023	COORDINATED WITH LATEST MVHR AND SPRINKLER LAYOUTS
C	T.H.	06-08-2023	CLIENT'S COMMENTS INCORPORATED. ISSUED FOR CONSTRUCTION
B	T.H.	17-01-2023	KITCHEN ELECTRICAL SERVICES MOVED TO DRAWING J7919/E33.
A	T.H.	26-04-2022	ISSUED FOR APPROVAL COORDINATED WITH LATEST MVHR AND SPRINKLER LAYOUTS. TV OUTLETS AND COMMS EQUIPMENT DETAIL UPDATED
REV	DRN	DATE	DESCRIPTION
SCHEME			
EASTLEIGH BOROUGH COUNCIL EASTLEIGH POST OFFICE			
TITLE			
FLAT TYPE 4 - BLOCK B PLOTS B1, B5, B9 & B13 ELECTRICAL SERVICES LAYOUT			
1.2 CENTRAL POINT, KIRKPAUL ROAD PORTSMOUTH, PO3 4PH Tel: (023) 9281 9999 Fax: (023) 9281 9998 E-mail: enquiries@mr-electrical.co.uk			
© This design is the property of MR Electrical Services Limited and shall not be reproduced or copied in any way or conveyed to a third party without the owners written permission			
SCALE	1:25 @ A1	DATE	FEBRUARY 2022
DRAWN	TOM HEPELL	CHECKED	GRAHAM WIGGINS
DRG. NO.	J7919/E07	REVISION	F