
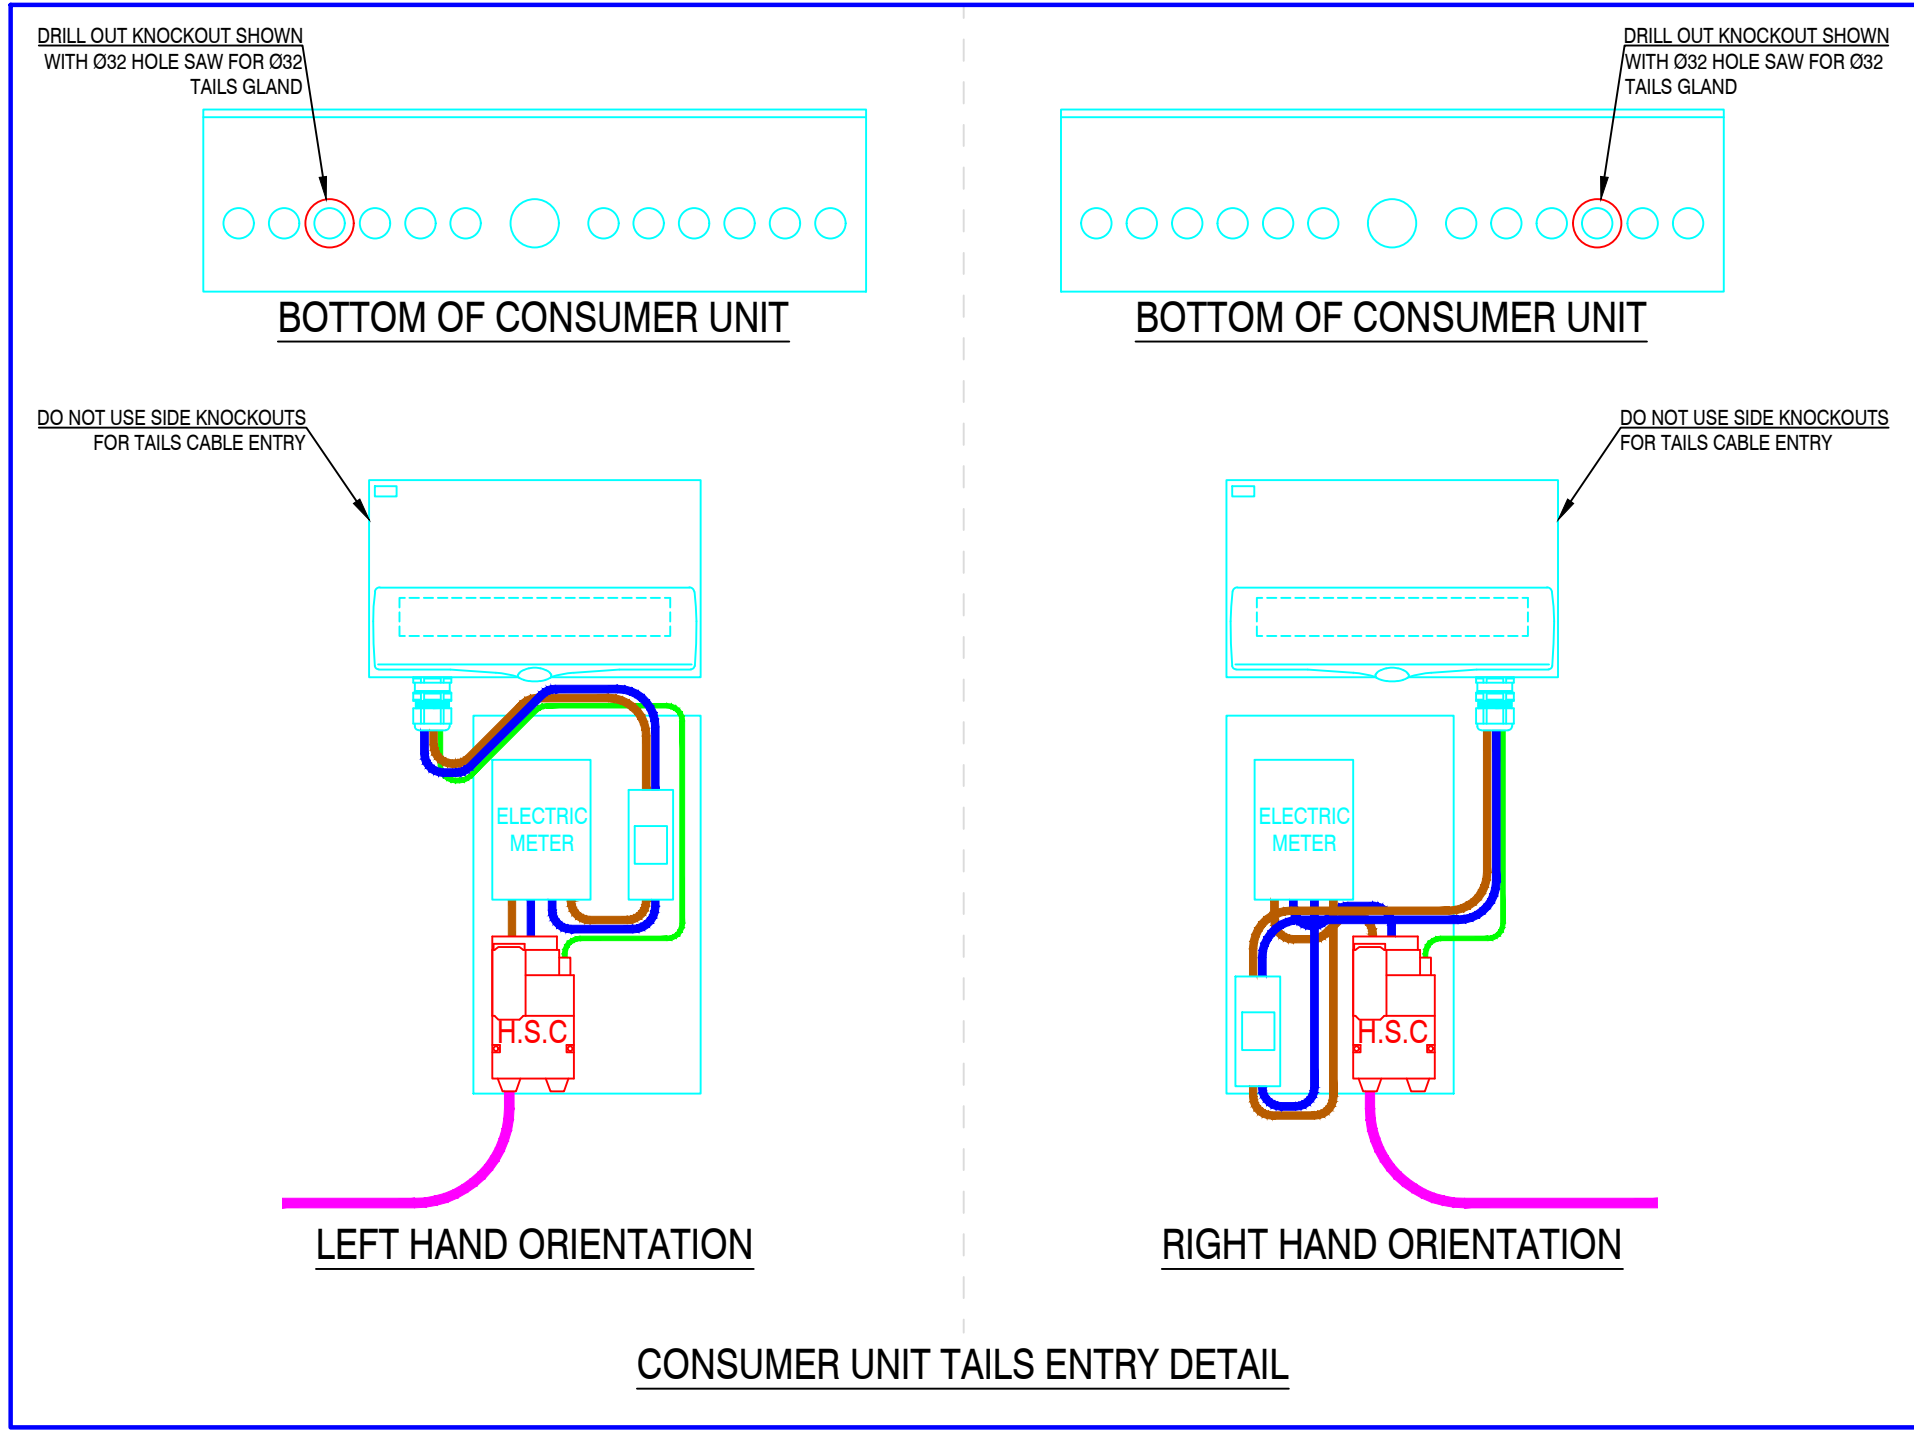
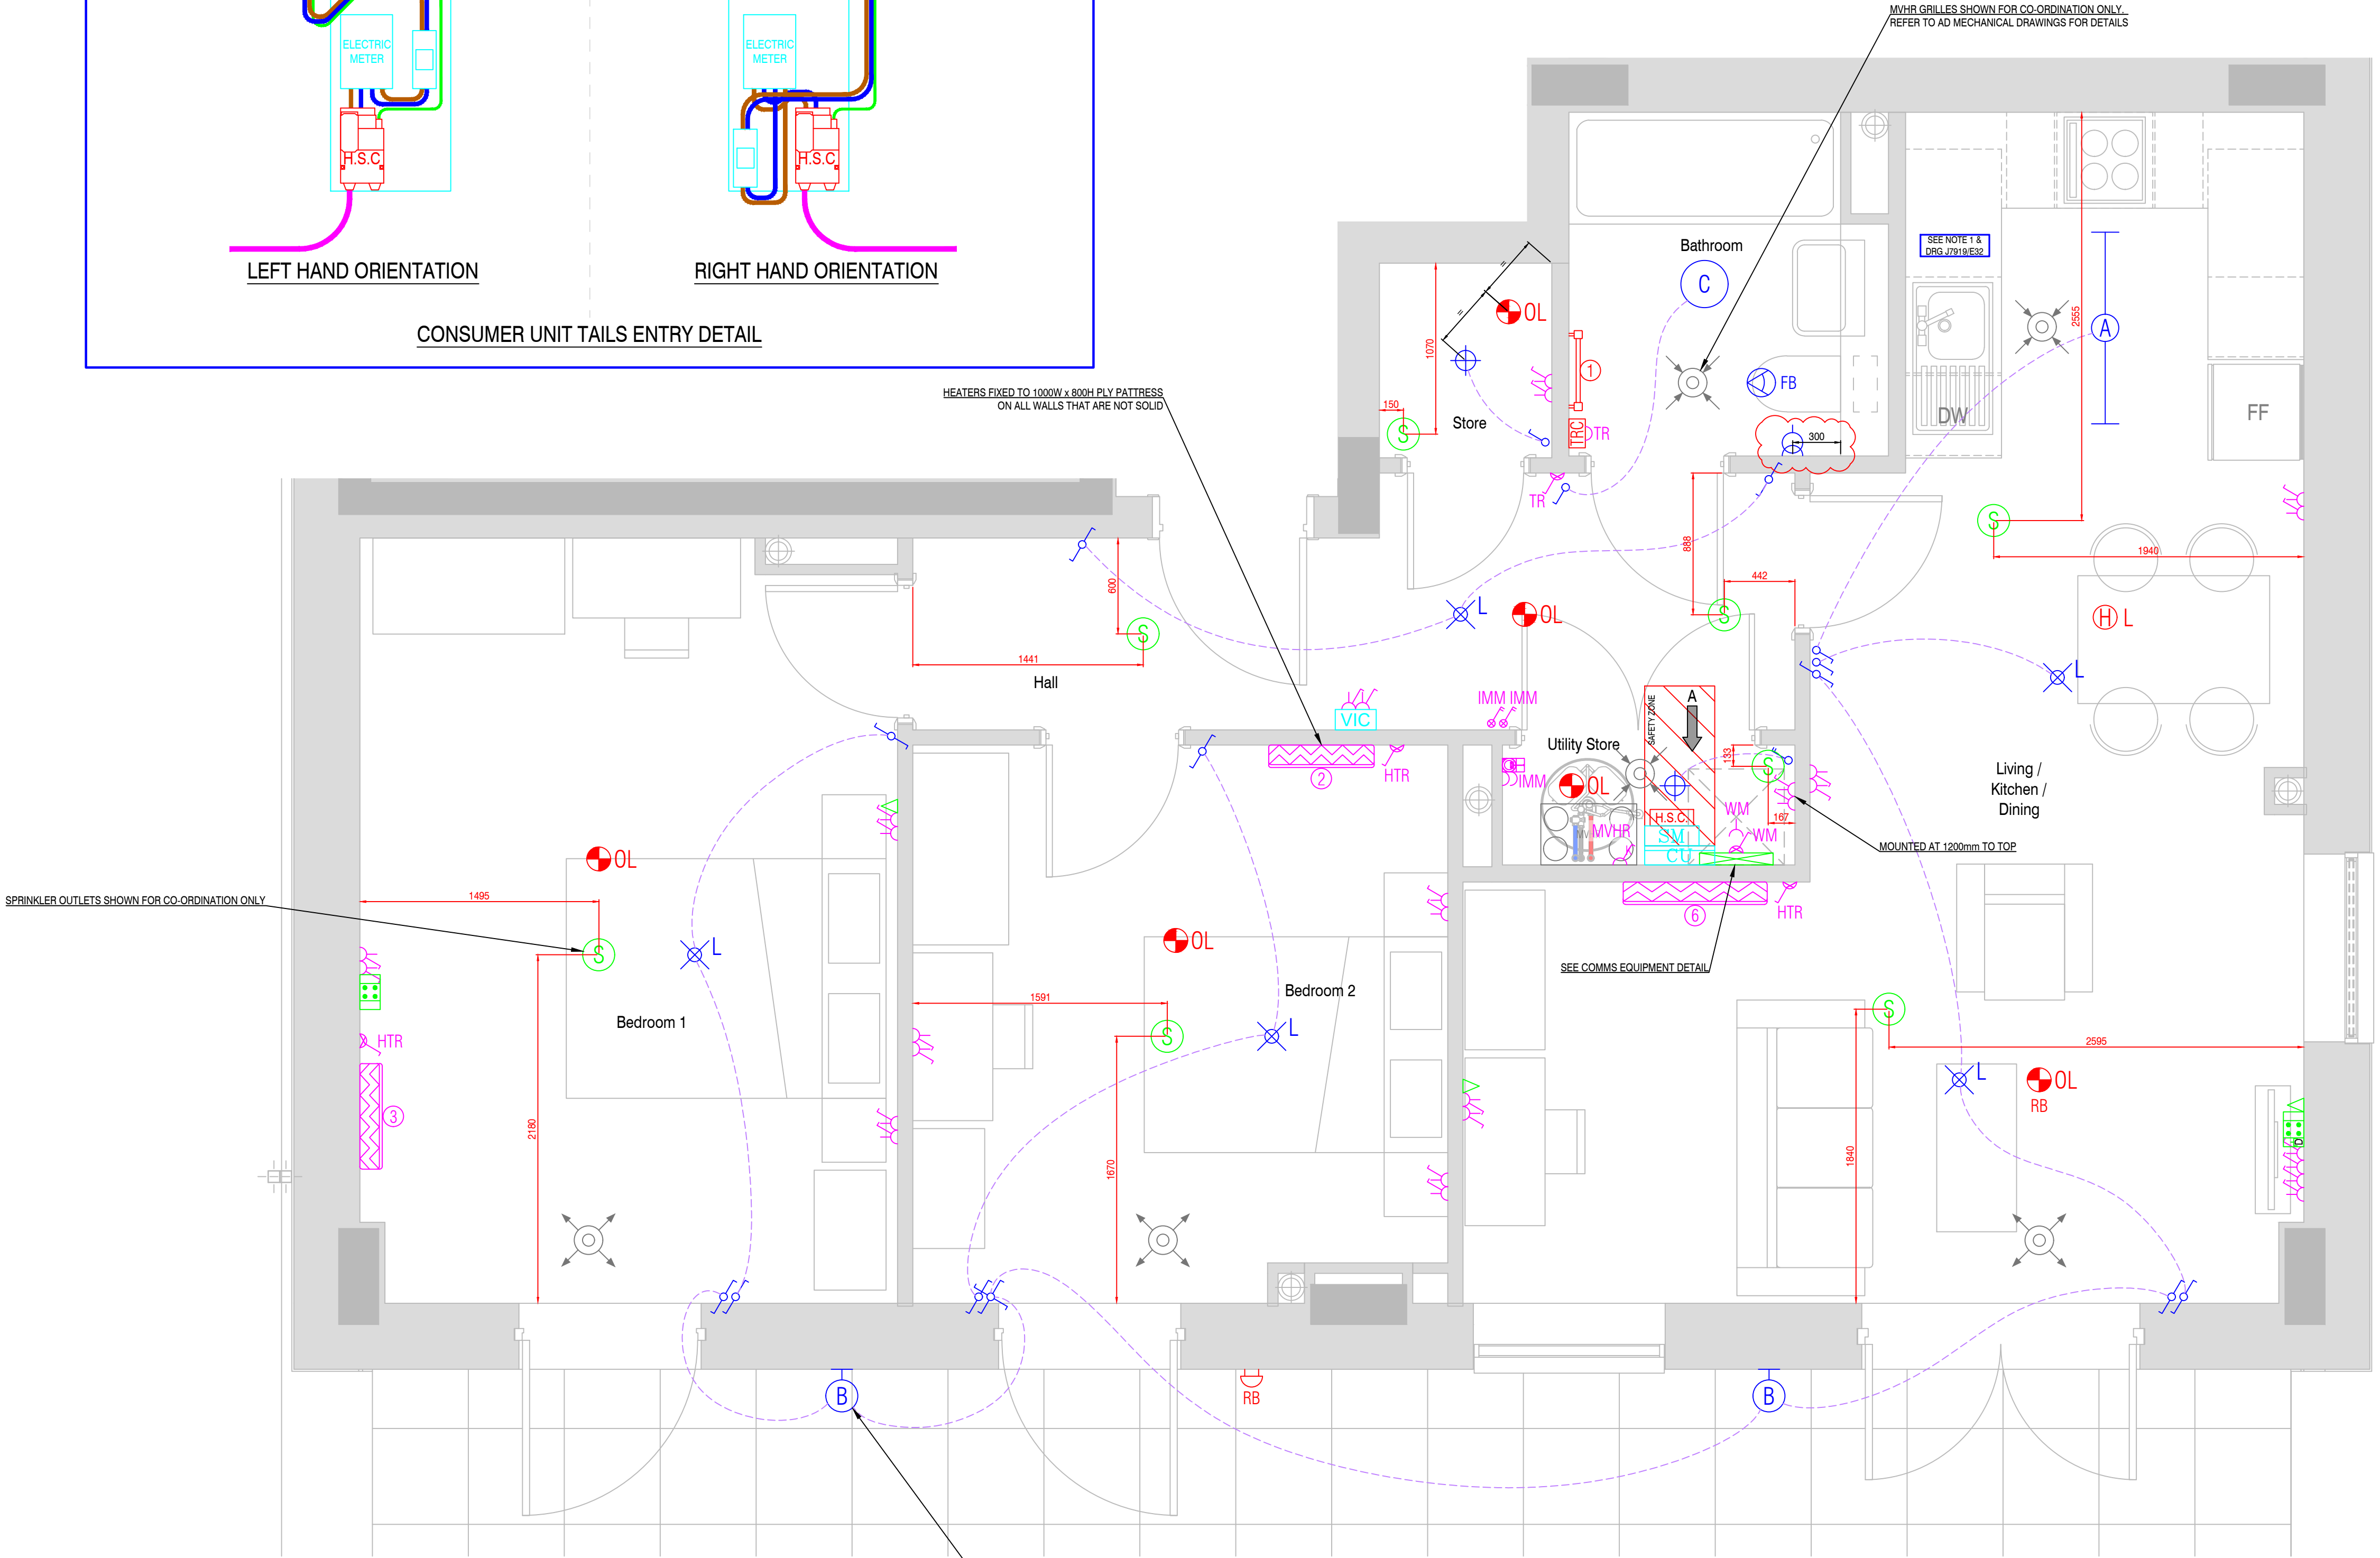
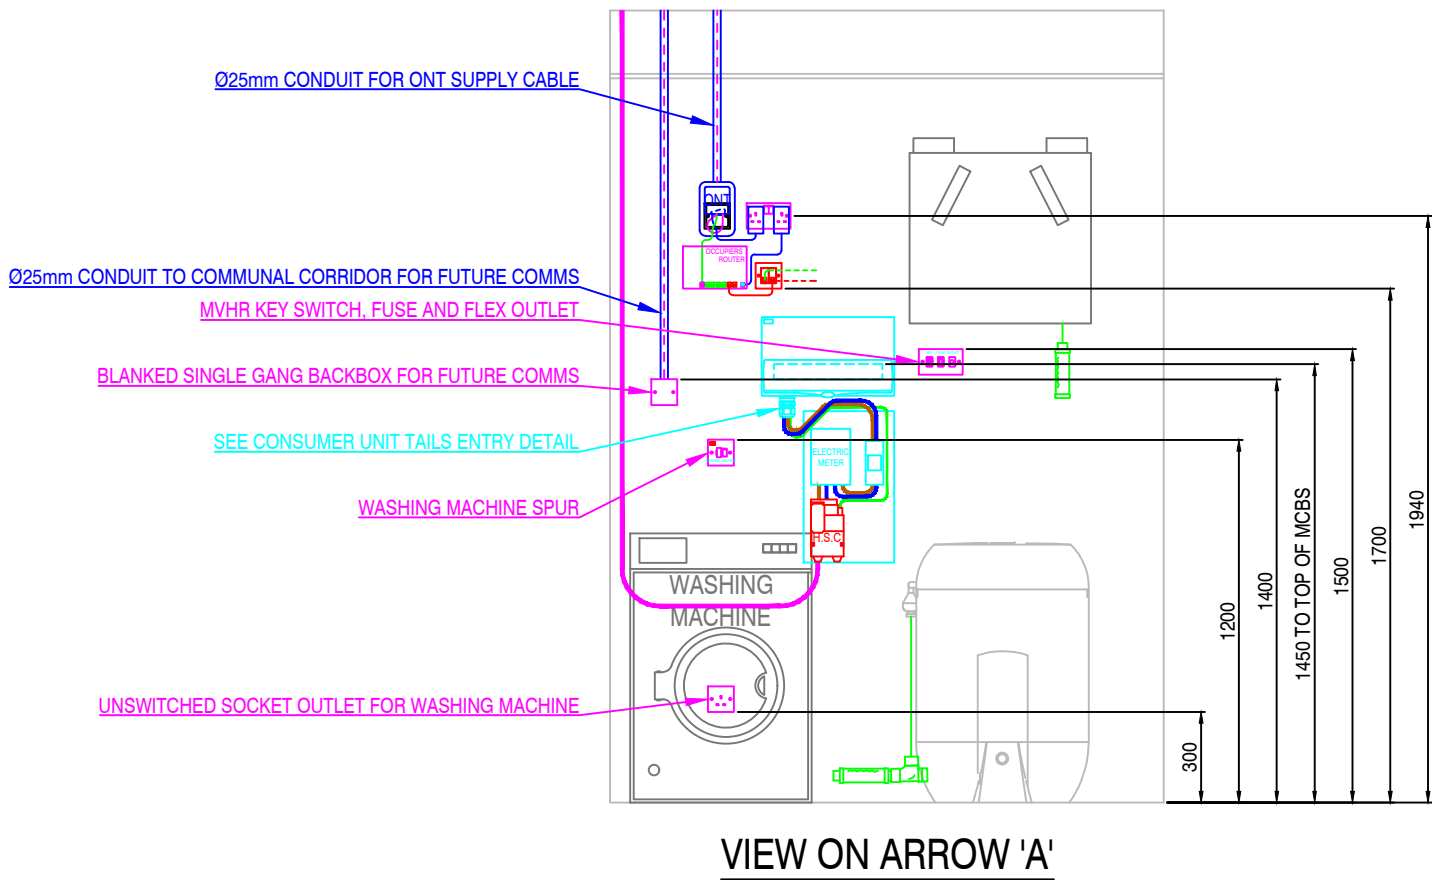


SEE DRAWING No J7919/E401
FOR LEGEND, NOTES AND DETAILS

FOR CONSTRUCTION

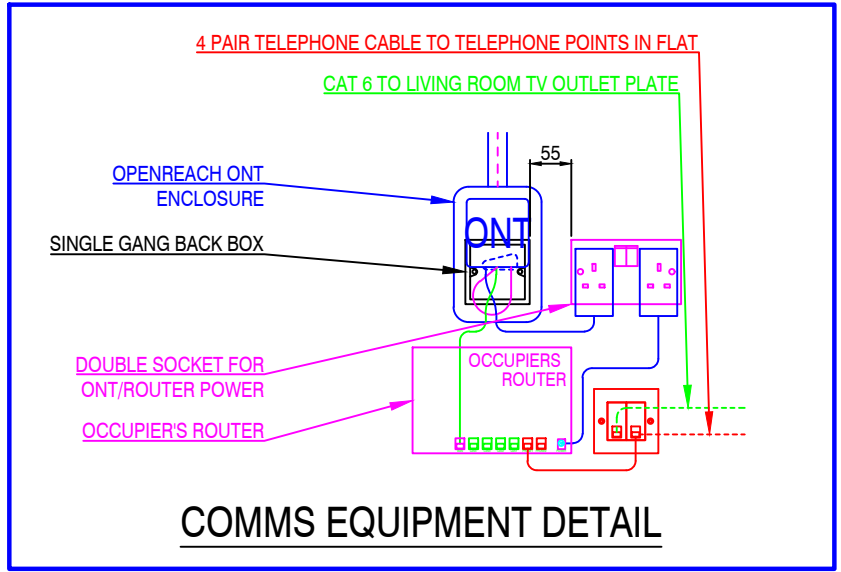

FURNITURE LAYOUTS ARE INDICATIVE ONLY, ALL FURNITURE & OBSTRUCTIONS (e.g. SHELVES) MUST BE KEPT A MINIMUM OF 150mm AWAY FROM ELECTRIC HEATERS. REFER ALSO TO THE HEATER'S INSTRUCTION MANUAL FOR FURTHER GUIDANCE.

DISTANCES FROM EDGE OF SPRINKLERS

DOWN LIGHT - 150mm

DETECTOR - 500mm

PENDANTS - 500mm

G	A.P.	14-12-2023	SHAVER OUTLET POSITION UPDATED
F	T.H.	30-11-2023	HEATER PHYSICAL DIMENSIONS UPDATED
E	T.H.	10-10-2023	COORDINATED WITH LATEST SPRINKLER LAYOUT
D	T.H.	06-08-2023	CLIENT'S COMMENTS INCORPORATED. ISSUED FOR CONSTRUCTION
C	T.H.	17-01-2023	FLAT TYPE CHANGED FROM TYPE 3 (MIRRORED) TO 3. KITCHEN ELECTRICAL SERVICES MOVED TO DRAWING J7919/E32
B	T.H.	26-04-2022	COORDINATED WITH LATEST MVHR AND SPRINKLER LAYOUTS. TV OUTLETS AND COMMS EQUIPMENT DETAIL UPDATED
A	T.H.	24-02-2022	DRAWING CHANGED FROM FLAT TYPE 9 TO 9 (MIRRORED)
REV	DRN	DATE	DESCRIPTION

SCHEME

EASTLEIGH BOROUGH COUNCIL


EASTLEIGH POST OFFICE

TITLE

FLAT TYPE 3 - BLOCK A

PLOT A10

ELECTRICAL SERVICES LAYOUT

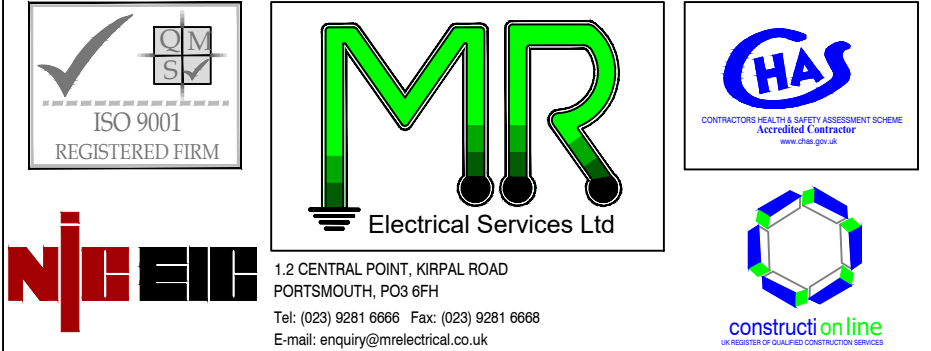

This design is the property of MR Electrical Services Limited and shall not be reproduced or copied in any way or conveyed to a third party without the owners written permission

SCALE	1:25 @ A1	DATE	FEBRUARY 2022
DRAWN	TOM HEPELL	CHECKED	GRAHAM WIGGINS
DRG. NO.	J7919/E06	REVISION	G