


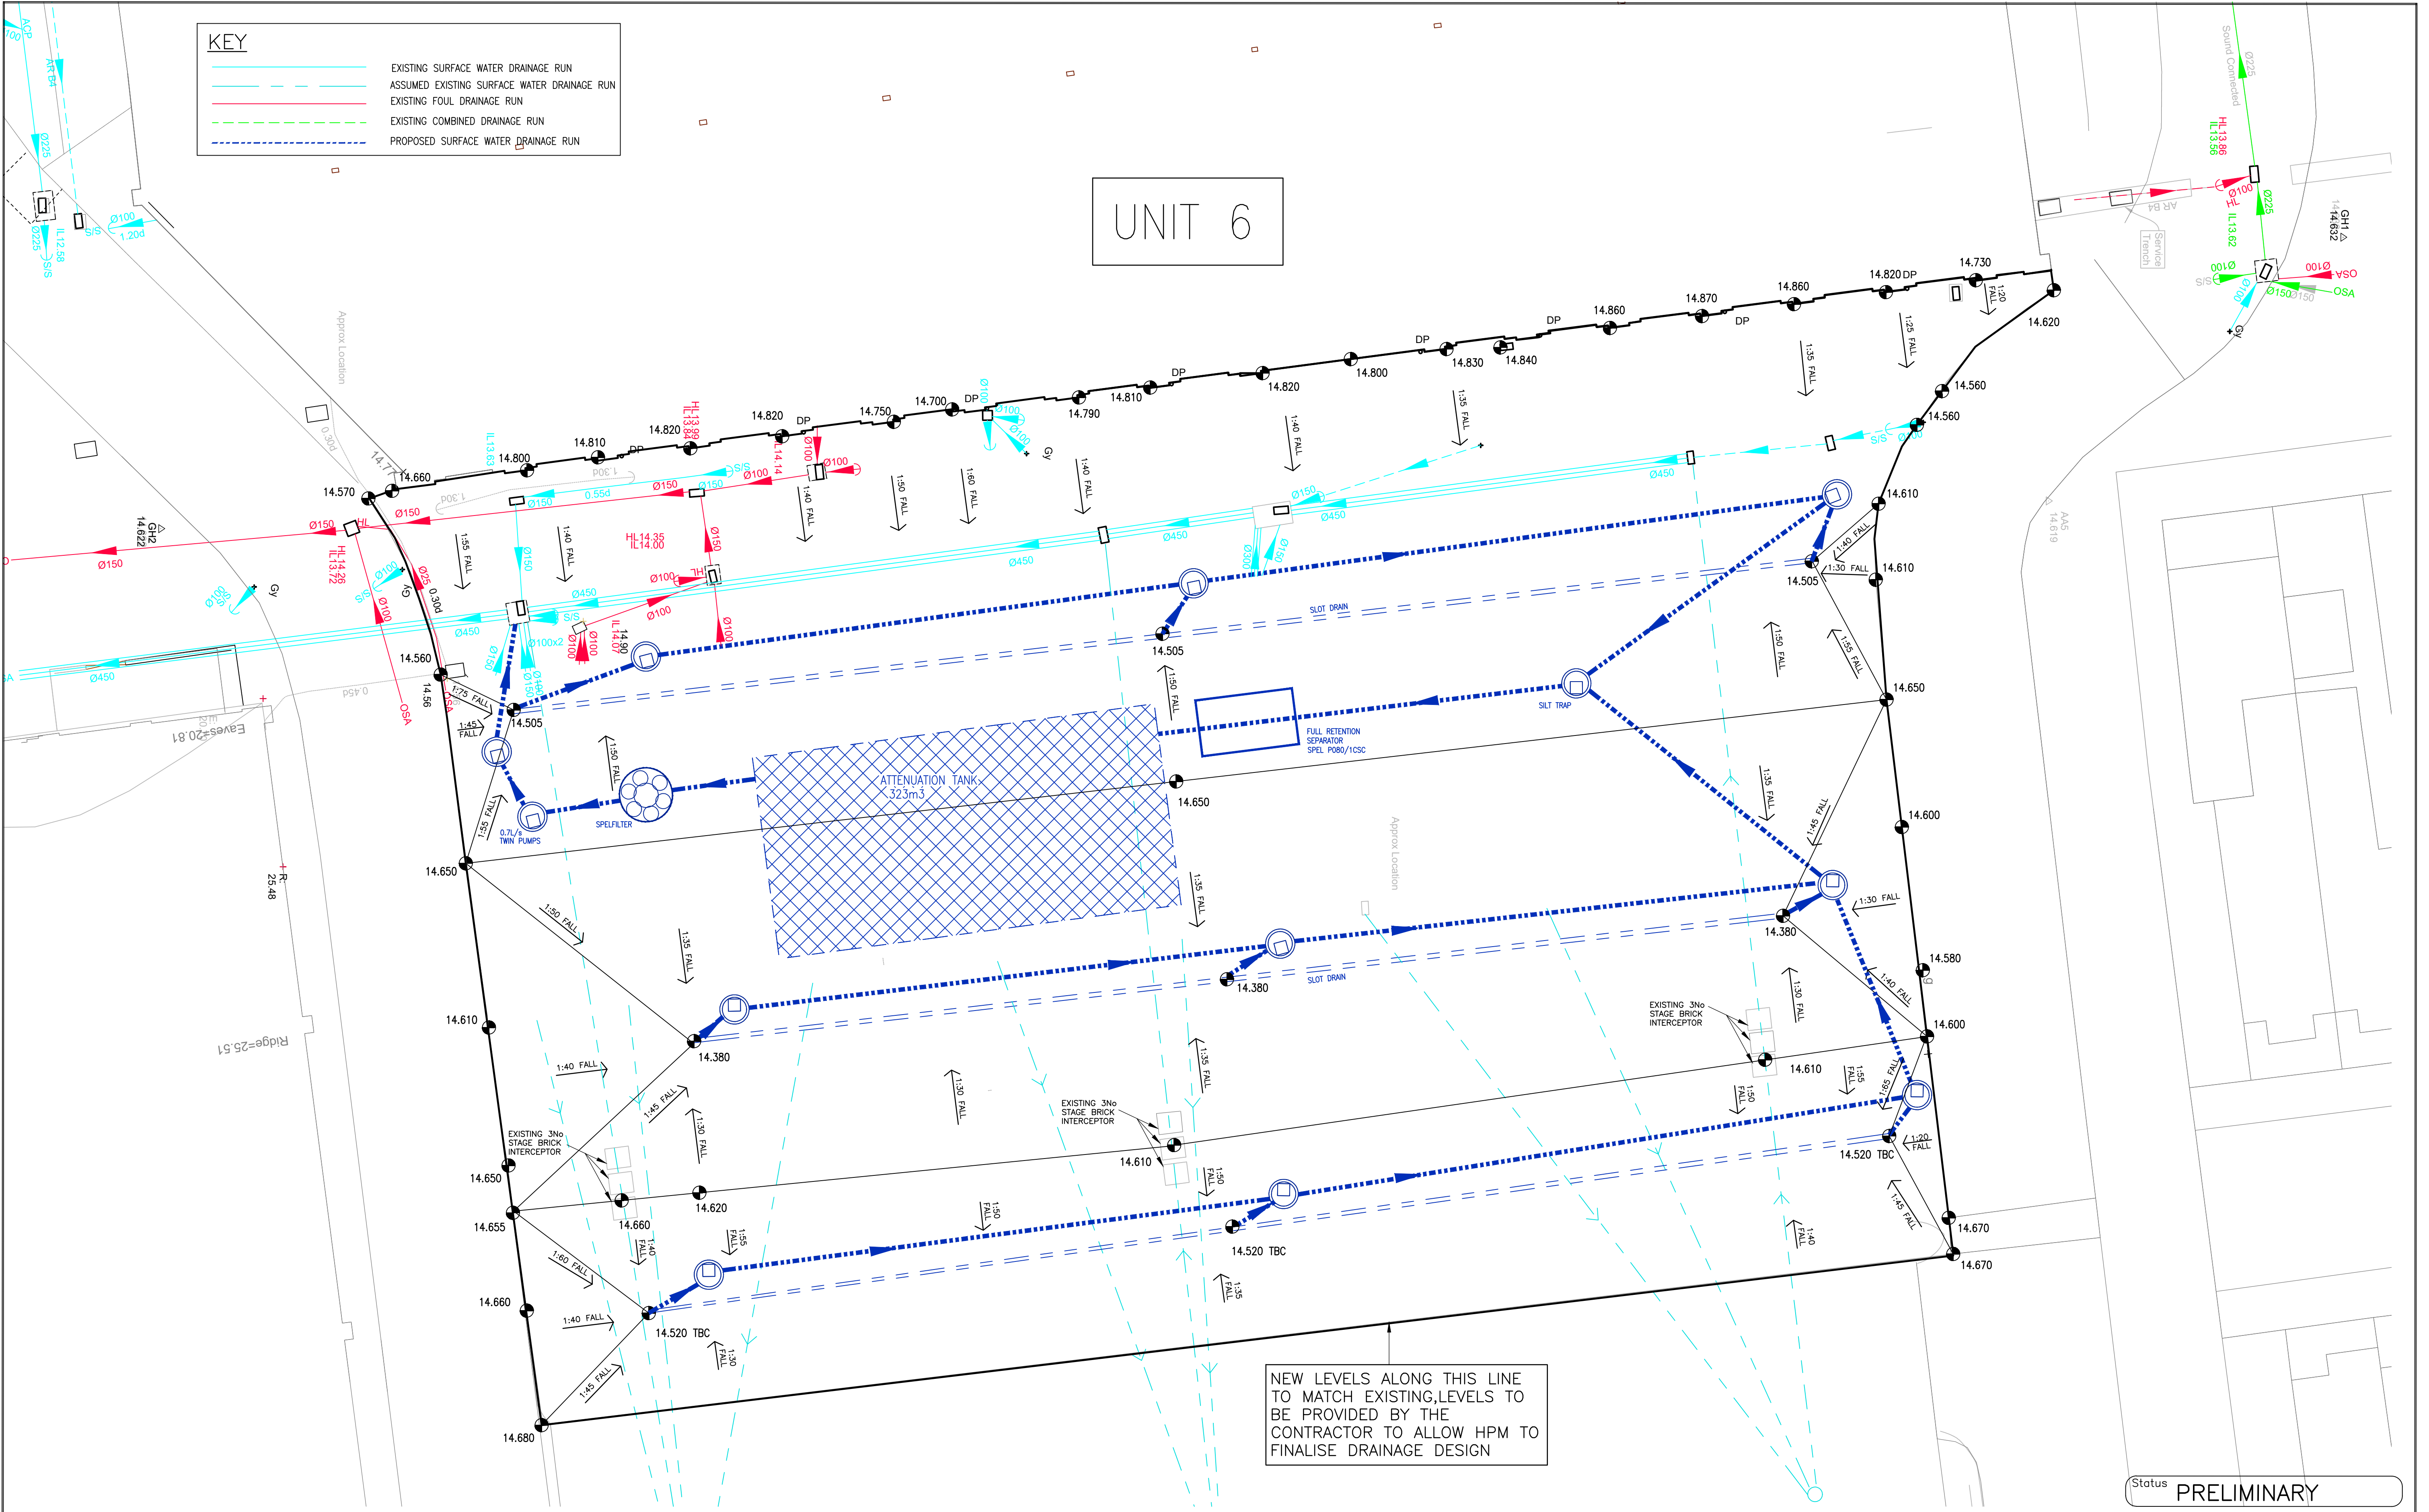

No	Revision	By	Ckd	Psd	Dte
P2	LAYOUT UPDATED TO SUIT REVISED SCHEME	DH	DMC		22 02 24

- NOTES**
- THIS DRAWING IS TO BE READ IN CONJUNCTION WITH ALL RELEVANT ARCHITECTS & ENGINEERS DRAWINGS, DETAILS AND SPECIFICATIONS.
 - CDM DETAILS REFERS TO THE CONSTRUCTION (DESIGN AND MANAGEMENT) REGULATIONS. THE READER MUST REFER TO METHOD STATEMENTS OR RISK ASSESSMENTS AS APPROPRIATE, WHICH IDENTIFY UNUSUAL AND ABNORMAL RISKS THAT A COMPETENT CONTRACTOR COULD NOT BE EXPECTED TO ANTICIPATE.

Hurst Peirce + Malcolm LLP
CONSULTING CIVIL & STRUCTURAL ENGINEERS

CELTIC HOUSE
33 JOHN'S MEWS
HOLBORN
LONDON WC1N 2QL

E-MAIL:
enquiries@hurstpm.co.uk

Web PAGE
www.hurstpm.co.uk

©
TEL: 020 7242 3593
FAX: 020 7405 5274

ARCHITECT			
CDM DETAILS (Refer to Note 2)		ENG	
BURIED SERVICES		DH	
Scale 1:150 AT A1			
Drawn DH	Checked	Passed	Date JAN 2024

Project BARTON PARK, EASTLEIGH UNIT 10	
Title INDICATIVE DRAINAGE LAYOUT	
Drawing No. 27270/DS01 P2	

CAD REF: