




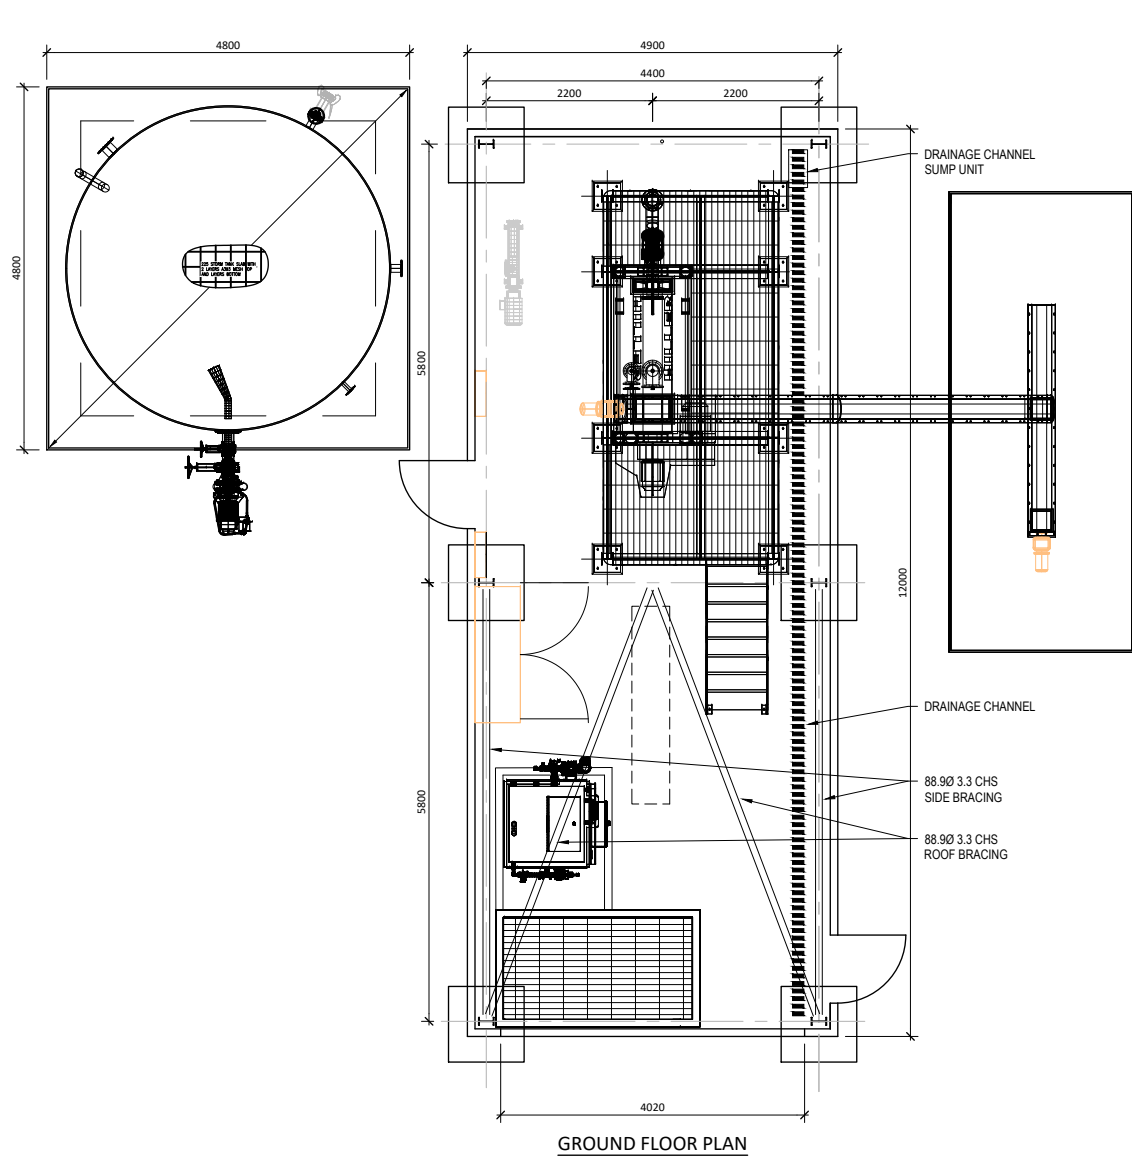

GROUND FLOOR PLAN

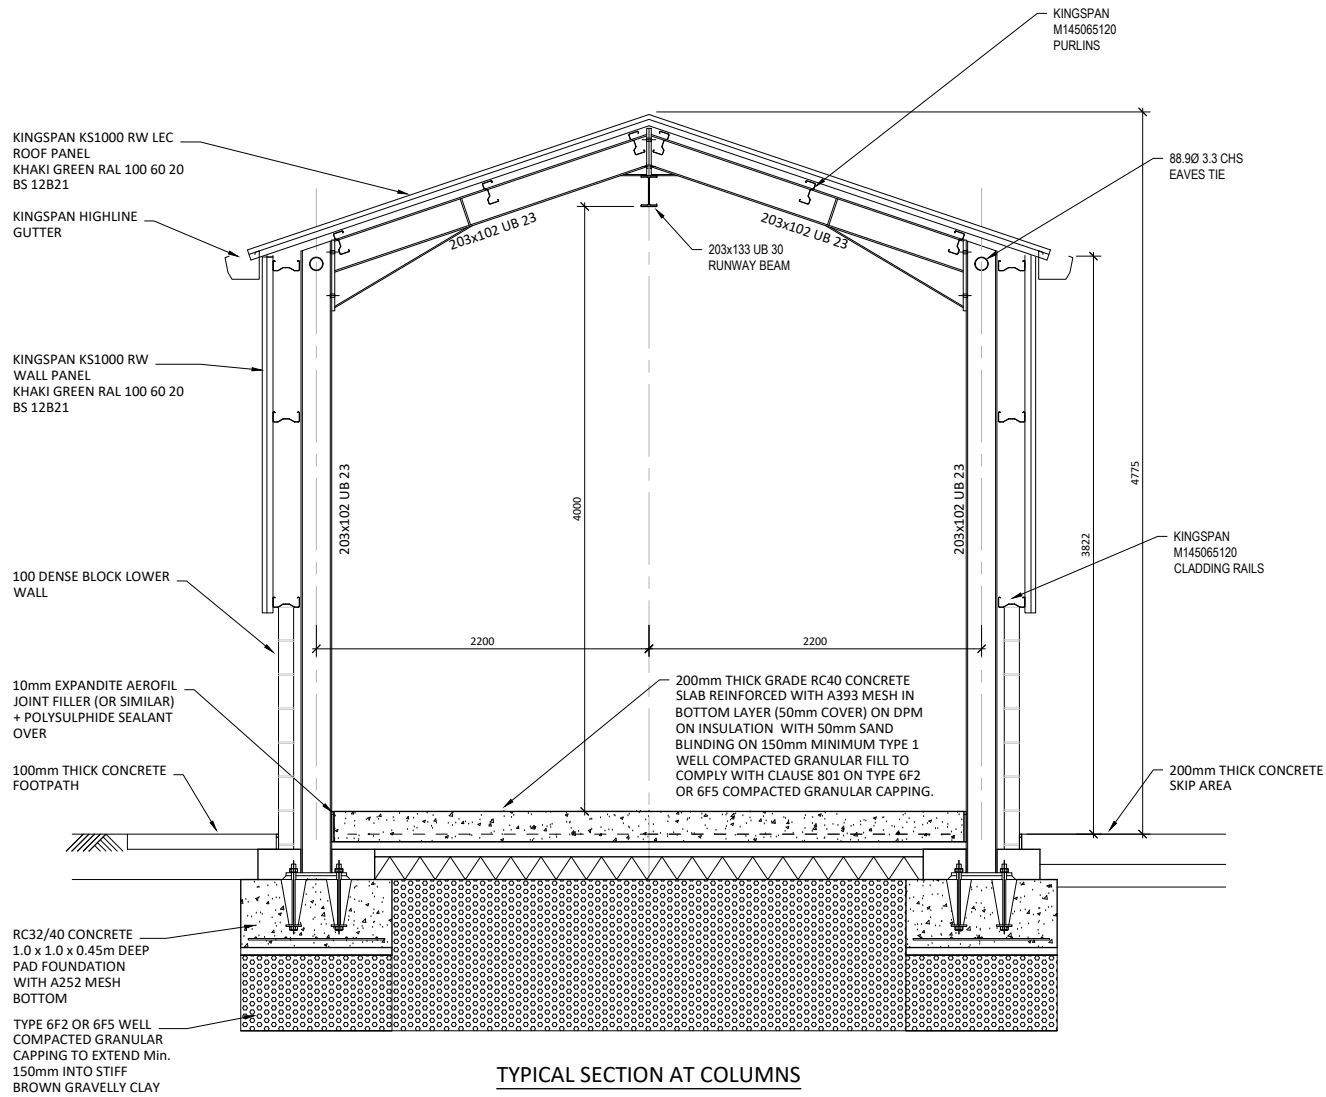

TYPICAL SECTION AT COLUMNS

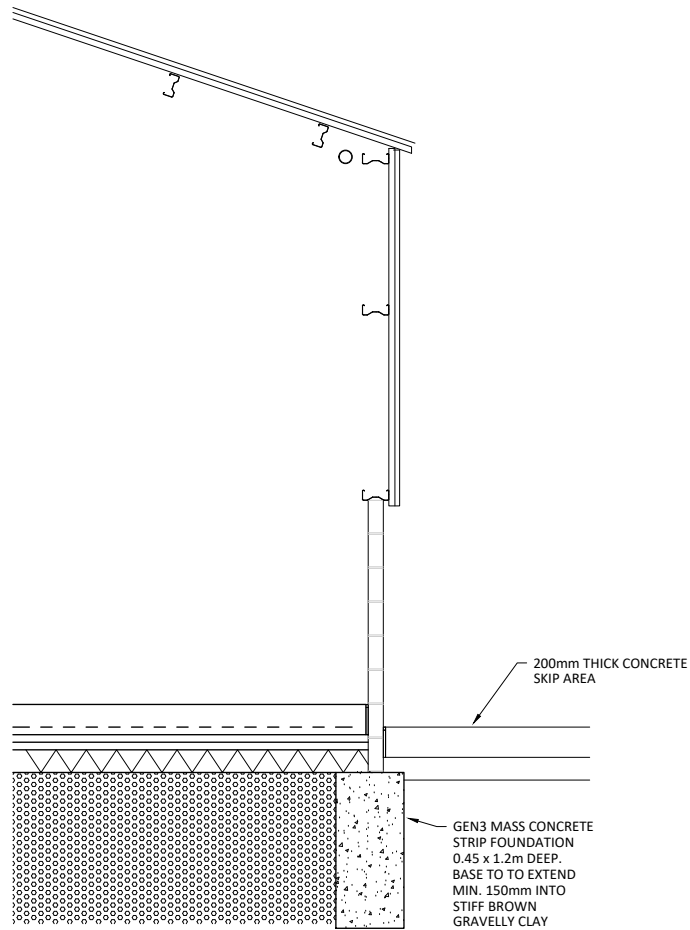

TYPICAL SECTION EDGE STRIP FOUNDATION

General Notes

1. These drawings are to be read in conjunction with all relevant Architect's and Engineer's drawings and specifications, refer to Drg. No.00 for Structural Specification
2. Except where specific dimensions are shown on these drawings, all setting out shall be in accordance with the architects drawings and specifications. Any discrepancy between these drawings and the architects drawings or the actual site dimensions should be referred to the engineer immediately and confirmed in writing. The contractor is responsible for the accuracy of all dimensions and the setting out.
3. Do not scale from these drawings. If in doubt, ask.
4. All dimensions are in millimetres unless noted otherwise.
5. All proprietary materials to be in accordance with manufacturers specifications and to Engineer's approval.
6. All proprietary CDP elements shown on the drawings should be treated as indicative and are subject to detailed design by specialist manufacturer/supplier. The contractor should make suitable allowance for third party design/detailing and potential impact on the permanent work design.

THIS DRAWING IS FOR
PLANNING PURPOSES ONLY

This drawing has been prepared for submission
to fulfil planning permission requirements only.

P03	23.05.24	additional detail / NOTES	IJW
P02	16.04.24	Pad foundation and additional details	IJW
P01	14.03.24	Preliminary Issue	IJW
Rev	Date	Revision Description	Issued by

Drawing Status: S3 - Suitable for Review

GODSELL • ARNOLD
PARTNERSHIP LTD
Consulting Civil and Structural Engineers
7 Arrowsmith Court, Station Approach
Broadstone, Dorset. BH18 8AX
Telephone: 01202 600 900 Website: www.gapltd.net

Client: PORTSMOUTH WATER LTD

Project: RIVER ITCHEN WORKS - CENTRIFUGE

Drawing Title: CENTRIFUGE BUILDING
PLAN & TYPICAL SECTION

Scale: 1 : 50 & 1 : 25 @ A1 Drawn: GAP Checked: IJW

Project-Originator-Zone-Level-Type-Role Drawing No.: Revision:
23708-GAP-XX-XX-DR-C 9202 P03