


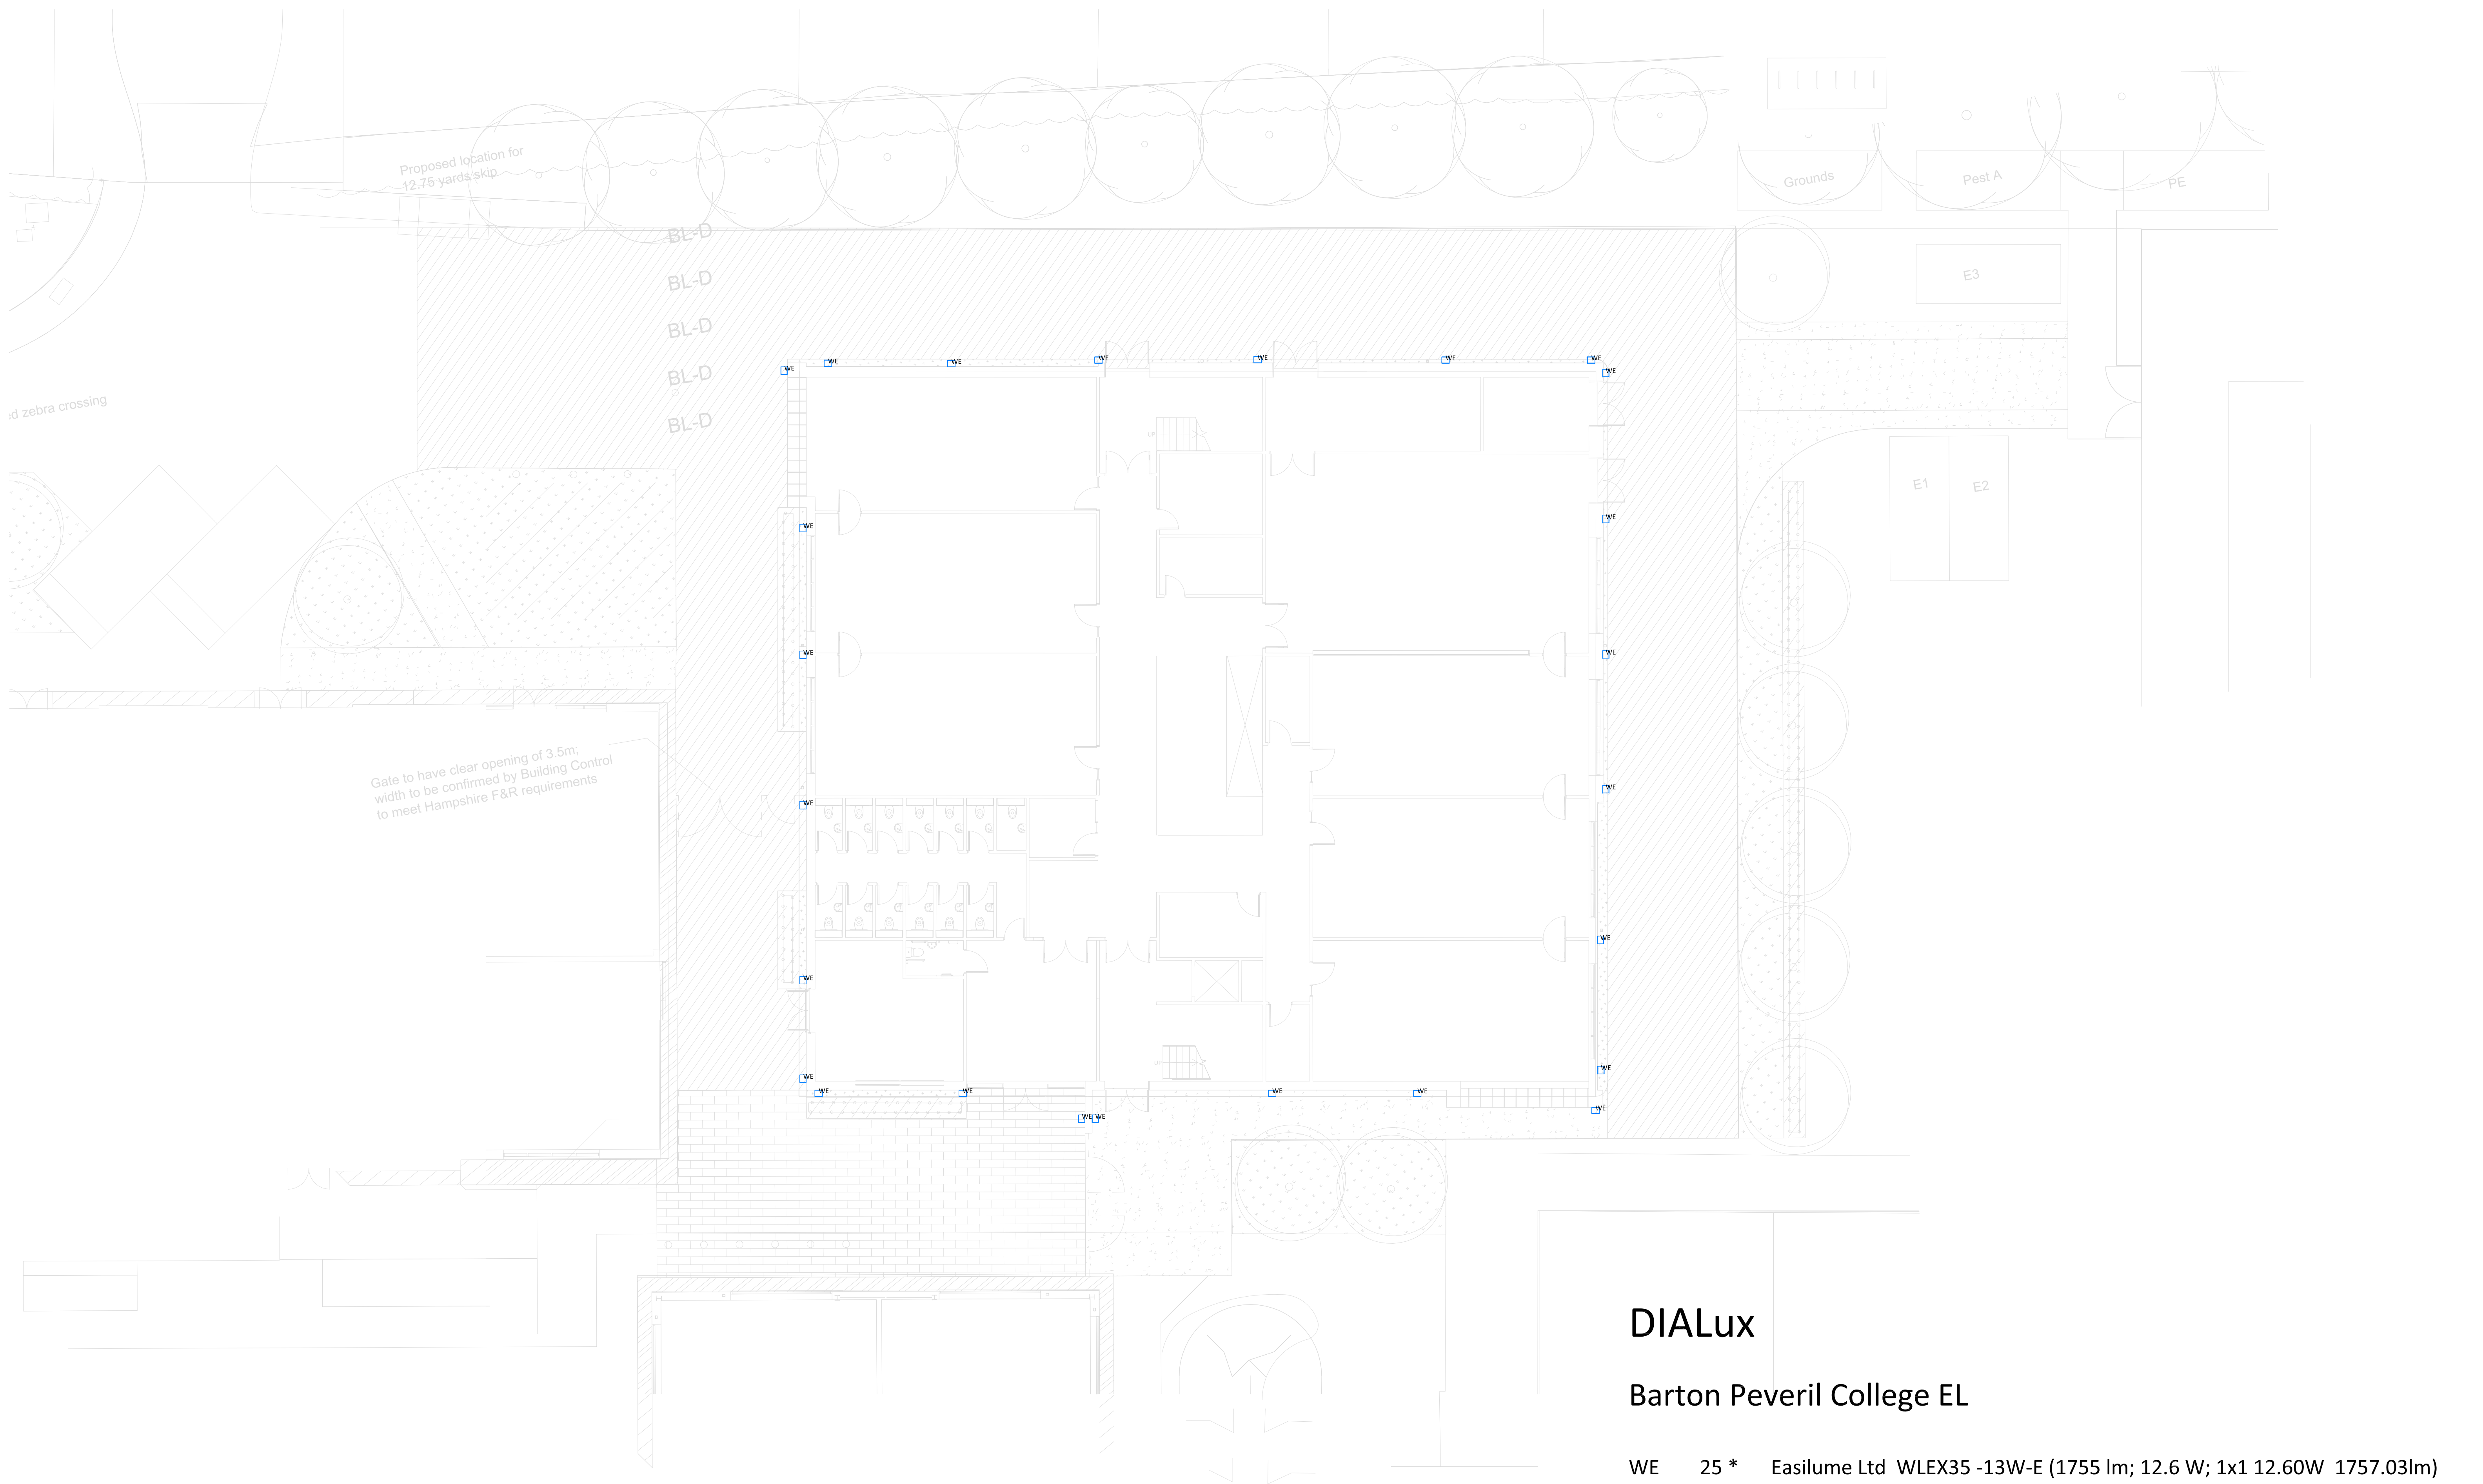

Rev	Date	CHK	Revision Description
R01	240327	JD	Minor adjustments based on comments

0

5

10 m

DO NOT SCALE FROM THIS DRAWING ALL DIMENSIONS TO BE CONFIRMED ON SITE BY THE CONTRACTOR PRIOR TO CONSTRUCTION

EASILUME

EASILUME LTD

Unit 11, Kingsmead, Station Road,

Kings Cliffe, Peterborough, PE6 6YH

email: sales@easilume.co.uk

tel: 0333 800 5555

https://easilume.co.uk/

DRAWING

LIGHTING LAYOUT

CLIENT

JOB

Barton Peveril College

Issued for Information			
JOB	PAPER	A1	SCALE 1:125

Drawing Number

240327 - Barton Peveril College - External - R01