



**In an emergency call 105,
24 hours a day**

Date Requested: 23/10/2023
Job Reference: 31278625
Site Location: 449918 118275
Requested by:
Ms Debbie Wigston

Your Scheme/Reference: 8230679

Scale: 1:500 (When plotted at A3)

IMPORTANT INFO

This plan shows cables owned by Last Mile Electricity Limited in their role as a Licensed Distributor (IDNO). Cables owned by other Distributors or privately owned cables (or, indeed, any other apparatus, equipment or infrastructure may also be present in the area. Information regarding such cables (or any such other apparatus, equipment, or infrastructure) should be obtained from the relevant owners.

The information shown on these plans is provided for general information purposes only and should not be relied on or treated as a substitute for your own enquiries. We make no warranty, representation, or guarantee, whether express or implied, regarding the content of the plans or that the content is accurate, complete, or up to date. No liability of any kind whatsoever is accepted by Last Mile Asset Management Limited, or their agents, servants or contractors for any error, omission, or misstatement.

Safe digging practices, in accordance with HS(G)47, must be used to verify and establish the actual position of all electrical cables and apparatus on site before any mechanical plant is used. It is your responsibility to ensure that this information is provided to all persons on or near electrical cables or apparatus. The information included on this plan should not be referred to beyond a period of 3 month from the date of issue.

ELECTRIC KEY

PROPOSED LV SERVICE	LV STRAIGHT JOINT
PROPOSED LV	LV BREACH JOINT
PROPOSED HV	HV STRAIGHT JOINT
PROPOSED EHV (UG)	HV BREACH JOINT
EXISTING/AS LAID LV SERVICE	STREET LIGHTING C.P
EXISTING/AS LAID LV (UG)	MINI PILLAR
EXISTING/AS LAID HV (UG)	LINK BOX
EXISTING/AS LAID EHV (UG)	EARTH SPIKE
EXISTING LV OVERHEAD	POT END
EXISTING HV OVERHEAD	SERVICE JOINT
EXISTING EHV OVERHEAD	
PROPOSING DISCONNECTED	

Dig Sites


Area:

Line:

Last Mile Asset Management Limited
Fenick House, Lister Way
Hamilton International Technology Park
Glasgow G72 0FT
Telephone 03300 587 443

Crown Copyright © - Reproduced by permission of Ordnance Survey on behalf of HMSO. And database right 2023. All rights reserved. Ordnance Survey Licence number 100061801

(Page 4)

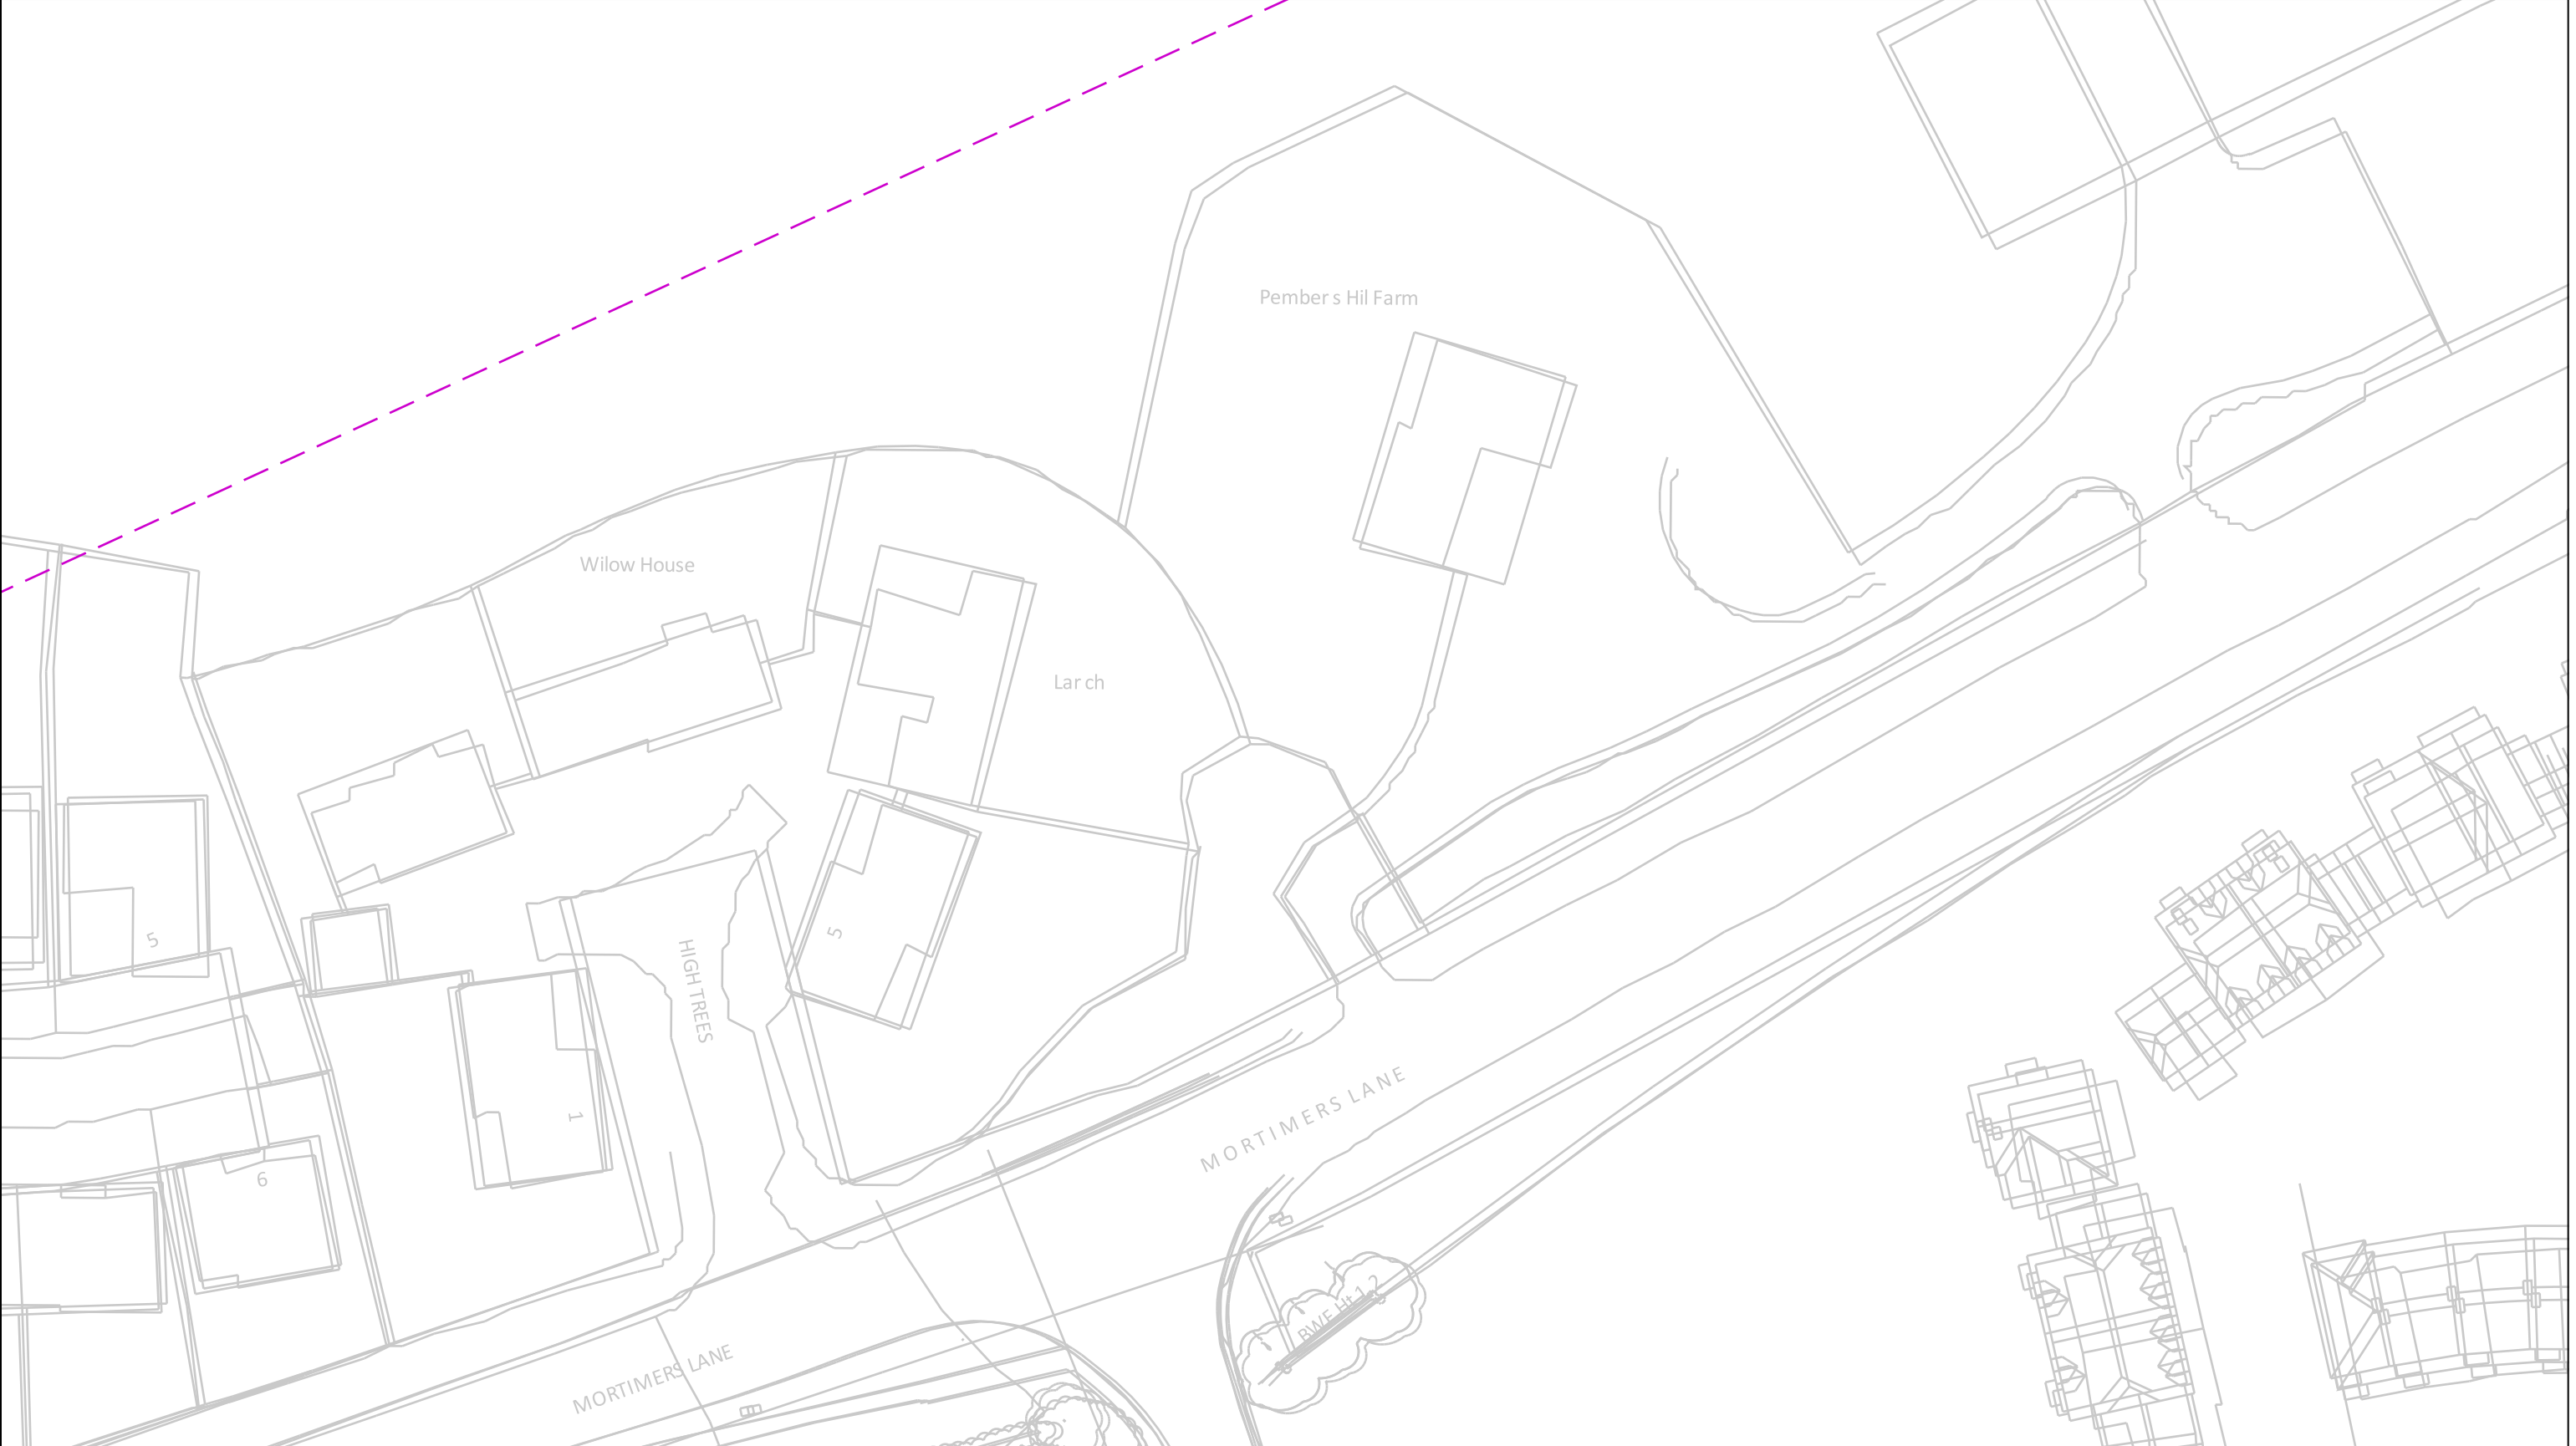

**In an emergency call 105,
24 hours a day**

Date Requested: 23/10/2023
Job Reference: 31278625
Site Location: 449918 118275
Requested by:
Ms Debbie Wigston

Your Scheme/Reference: 8230679

Scale: 1:500 (When plotted at A3)

IMPORTANT INFO

This plan shows cables owned by Last Mile Electricity Limited in their role as a Licensed Distributor (IDNO). Cables owned by other Distributors or privately owned cables (or, indeed, any other apparatus, equipment or infrastructure may also be present in the area. Information regarding such cables (or any such other apparatus, equipment, or infrastructure) should be obtained from the relevant owners.

The information shown on these plans is provided for general information purposes only and should not be relied on or treated as a substitute for your own enquiries. We make no warranty, representation, or guarantee, whether express or implied, regarding the content of the plans or that the content is accurate, complete, or up to date. No liability of any kind whatsoever is accepted by Last Mile Asset Management Limited, or their agents, servants or contractors for any error, omission, or misstatement.

Safe digging practices, in accordance with HS(G)47, must be used to verify and establish the actual position of all electrical cables and apparatus on site before any mechanical plant is used. It is your responsibility to ensure that this information is provided to all persons on or near electrical cables or apparatus. The information included on this plan should not be referred to beyond a period of 3 month from the date of issue.

ELECTRIC KEY


PROPOSED LV SERVICE	LV STRAIGHT JOINT
PROPOSED LV	LV BREACH JOINT
PROPOSED HV	HV STRAIGHT JOINT
PROPOSED EHV (UG)	HV BREACH JOINT
EXISTING/AS LAID LV SERVICE	STREET LIGHTING C.P
EXISTING/AS LAID LV (UG)	MINI PILLAR
EXISTING/AS LAID HV (UG)	LINK BOX
EXISTING/AS LAID EHV (UG)	EARTH SPIKE
EXISTING LV OVERHEAD	POT END
EXISTING HV OVERHEAD	SERVICE JOINT
EXISTING EHV OVERHEAD	
PROPOSING DISCONNECTED	

Dig Sites

Area:

Line:

Last Mile Asset Management Limited
Fenick House, Lister Way
Hamilton International Technology Park
Glasgow G72 0FT
Telephone 03300 587 443

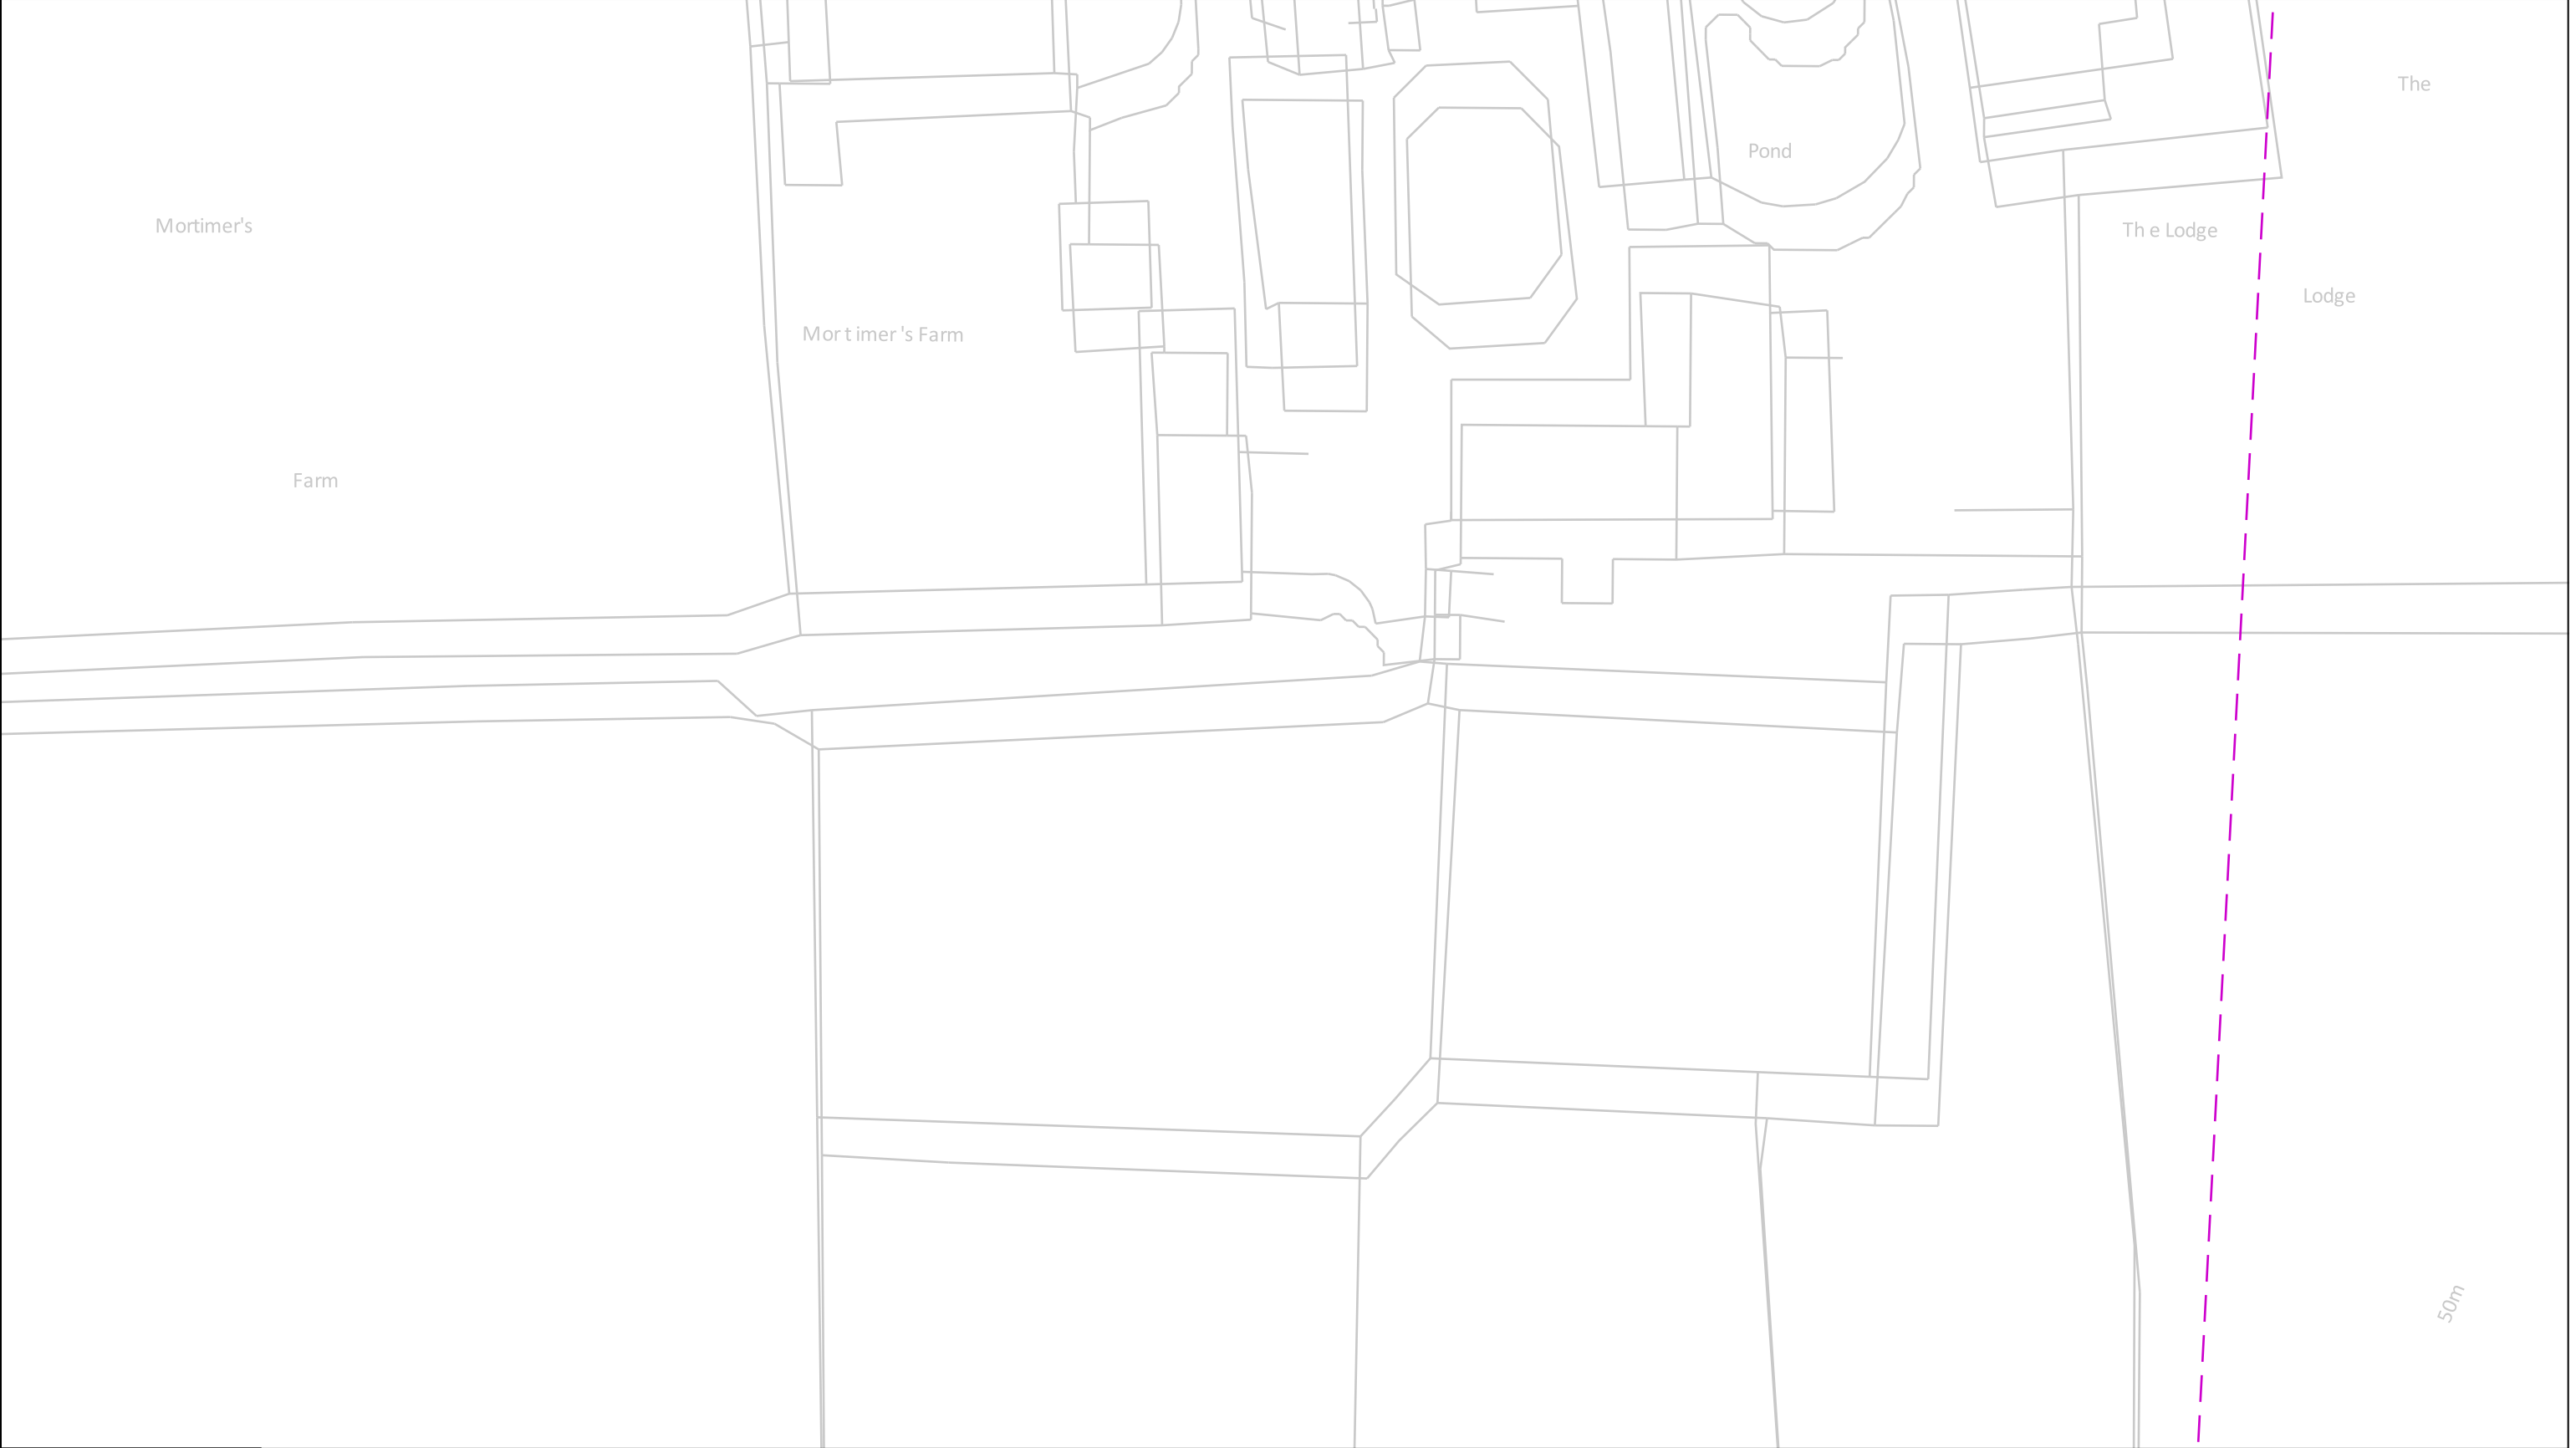

In an emergency call 105, 24 hours a day

Date Requested: 23/10/2023
Job Reference: 31278625
Site Location: 449918 118275
Requested by: Ms Debbie Wigston
Your Scheme/Reference: 8230679

Scale: 1:500 (When plotted at A3)

IMPORTANT INFO

This plan shows cables owned by Last Mile Electricity Limited in their role as a Licensed Distributor (IDNO). Cables owned by other Distributors or privately owned cables (or, indeed, any other apparatus, equipment or infrastructure may also be present in the area. Information regarding such cables (or any such other apparatus, equipment, or infrastructure) should be obtained from the relevant owners.

The information shown on these plans is provided for general information purposes only and should not be relied on or treated as a substitute for your own enquiries. We make no warranty, representation, or guarantee, whether express or implied, regarding the content of the plans or that the content is accurate, complete, or up to date. No liability of any kind whatsoever is accepted by Last Mile Asset Management Limited, or their agents, servants or contractors for any error, omission, or misstatement.

Safe digging practices, in accordance with HS(G)47, must be used to verify and establish the actual position of all electrical cables and apparatus on site before any mechanical plant is used. It is your responsibility to ensure that this information is provided to all persons on or near electrical cables or apparatus. The information included on this plan should not be referred to beyond a period of 3 month from the date of issue.

ELECTRIC KEY

PROPOSED LV SERVICE	LV STRAIGHT JOINT
PROPOSED LV	LV BREACH JOINT
PROPOSED HV	HV STRAIGHT JOINT
PROPOSED EHV (UG)	HV BREACH JOINT
EXISTING/AS LAID LV SERVICE	STREET LIGHTING C.P
EXISTING/AS LAID LV (UG)	MINI PILLAR
EXISTING/AS LAID HV (UG)	LINK BOX
EXISTING/AS LAID EHV (UG)	EARTH SPIKE
EXISTING LV OVERHEAD	POT END
EXISTING HV OVERHEAD	SERVICE JOINT
EXISTING EHV OVERHEAD	
PROPOSING DISCONNECTED	

100m

Dig Sites

Area:

Line:

Last Mile Asset Management Limited
Fenick House, Lister Way
Hamilton International Technology Park
Glasgow G72 0FT
Telephone 03300 587 443



In an emergency call 105, 24 hours a day

Date Requested: 23/10/2023
Job Reference: 31278625
Site Location: 449918 118275
Requested by: Ms Debbie Wigston
Your Scheme/Reference: 8230679

Scale: 1:500 (When plotted at A3)

IMPORTANT INFO

This plan shows cables owned by Last Mile Electricity Limited in their role as a Licensed Distributor (IDNO). Cables owned by other Distributors or privately owned cables (or, indeed, any other apparatus, equipment or infrastructure may also be present in the area. Information regarding such cables (or any such other apparatus, equipment, or infrastructure) should be obtained from the relevant owners.

The information shown on these plans is provided for general information purposes only and should not be relied on or treated as a substitute for your own enquiries. We make no warranty, representation, or guarantee, whether express or implied, regarding the content of the plans or that the content is accurate, complete, or up to date. No liability of any kind whatsoever is accepted by Last Mile Asset Management Limited, or their agents, servants or contractors for any error, omission, or misstatement.

Safe digging practices, in accordance with HS(G)47, must be used to verify and establish the actual position of all electrical cables and apparatus on site before any mechanical plant is used. It is your responsibility to ensure that this information is provided to all persons on or near electrical cables or apparatus. The information included on this plan should not be referred to beyond a period of 3 month from the date of issue.

PROPOSED LV SERVICE

PROPOSED LV

PROPOSED HV

PROPOSED EHV (UG)

EXISTING/AS LAID LV SERVICE

EXISTING/AS LAID LV (UG)

EXISTING/AS LAID HV (UG)

EXISTING/AS LAID EHV (UG)

EXISTING LV OVERHEAD

EXISTING HV OVERHEAD

EXISTING EHV OVERHEAD

PROPOSING DISCONNECTED

ELECTRIC KEY

-----	LV STRAIGHT JOINT
-----	LV BREACH JOINT
-----	HV STRAIGHT JOINT
-----	HV BREACH JOINT
-----	STREET LIGHTING C.P
-----	MINI PILLAR
-----	LINK BOX
-----	EARTH SPIKE
-----	POT END
-----	SERVICE JOINT

Dig Sites

Area: -----

Line: -----

100m

Last Mile Asset Management Limited
Fenick House, Lister Way
Hamilton International Technology Park
Glasgow G72 0FT
Telephone 03300 587 443

Crown Copyright © - Reproduced by permission of Ordnance Survey on behalf of HMSO. And database right 2023. All rights reserved. Ordnance Survey Licence number 100061801

(Page 7)

In an emergency call 105,
24 hours a day

Date Requested: 23/10/2023
Job Reference: 31278625
Site Location: 449918 118275
Requested by:
Ms Debbie Wigston

Your Scheme/Reference: 8230679

Scale: 1:500 (When plotted at A3)

IMPORTANT INFO

This plan shows cables owned by Last Mile Electricity Limited in their role as a Licensed Distributor (IDNO). Cables owned by other Distributors or privately owned cables (or, indeed, any other apparatus, equipment or infrastructure may also be present in the area. Information regarding such cables (or any such other apparatus, equipment, or infrastructure) should be obtained from the relevant owners.

The information shown on these plans is provided for general information purposes only and should not be relied on or treated as a substitute for your own enquiries. We make no warranty, representation, or guarantee, whether express or implied, regarding the content of the plans or that the content is accurate, complete, or up to date. No liability of any kind whatsoever is accepted by Last Mile Asset Management Limited, or their agents, servants or contractors for any error, omission, or misstatement.

Safe digging practices, in accordance with HS(G)47, must be used to verify and establish the actual position of all electrical cables and apparatus on site before any mechanical plant is used. It is your responsibility to ensure that this information is provided to all persons on or near electrical cables or apparatus. The information included on this plan should not be referred to beyond a period of 3 month from the date of issue.

ELECTRIC KEY

PROPOSED LV SERVICE
PROPOSED LV
PROPOSED HV
PROPOSED EHV (UG)
EXISTING/AS LAID LV SERVICE
EXISTING/AS LAID LV (UG)
EXISTING/AS LAID HV (UG)
EXISTING/AS LAID EHV (UG)
EXISTING LV OVERHEAD
EXISTING HV OVERHEAD
EXISTING EHV OVERHEAD
PROPOSING DISCONNECTED

	LV STRAIGHT JOINT
	LV BREACH JOINT
	HV STRAIGHT JOINT
	HV BREACH JOINT
	STREET LIGHTING C.P
	MINI PILLAR
	LINK BOX
	EARTH SPIKE
	POT END
	SERVICE JOINT



Dig Sites

Area:

Line: _ _ _ _



Last Mile Asset Management Limited
Fenick House, Lister Way
Hamilton International Technology Park
Glasgow G72 0FT
Telephone 03300 587 443

Crown Copyright © - Reproduced by permission of Ordnance Survey on behalf of HMSO. And database right 2023. All rights reserved. Ordnance Survey Licence number 100061801

(Page 8)



In an emergency call 105, 24 hours a day

Date Requested: 23/10/2023
Job Reference: 31278625
Site Location: 449918 118275
Requested by: Ms Debbie Wigston
Your Scheme/Reference: 8230679

Scale: 1:500 (When plotted at A3)

IMPORTANT INFO

This plan shows cables owned by Last Mile Electricity Limited in their role as a Licensed Distributor (IDNO). Cables owned by other Distributors or privately owned cables (or, indeed, any other apparatus, equipment or infrastructure may also be present in the area. Information regarding such cables (or any such other apparatus, equipment, or infrastructure) should be obtained from the relevant owners.

The information shown on these plans is provided for general information purposes only and should not be relied on or treated as a substitute for your own enquiries. We make no warranty, representation, or guarantee, whether express or implied, regarding the content of the plans or that the content is accurate, complete, or up to date. No liability of any kind whatsoever is accepted by Last Mile Asset Management Limited, or their agents, servants or contractors for any error, omission, or misstatement.

Safe digging practices, in accordance with HS(G)47, must be used to verify and establish the actual position of all electrical cables and apparatus on site before any mechanical plant is used. It is your responsibility to ensure that this information is provided to all persons on or near electrical cables or apparatus. The information included on this plan should not be referred to beyond a period of 3 month from the date of issue.

ELECTRIC KEY

PROPOSED LV SERVICE	LV STRAIGHT JOINT
PROPOSED LV	LV BREACH JOINT
PROPOSED HV	HV STRAIGHT JOINT
PROPOSED EHV (UG)	HV BREACH JOINT
EXISTING/AS LAID LV SERVICE	STREET LIGHTING C.P
EXISTING/AS LAID LV (UG)	MINI PILLAR
EXISTING/AS LAID HV (UG)	LINK BOX
EXISTING/AS LAID EHV (UG)	EARTH SPIKE
EXISTING LV OVERHEAD	POT END
EXISTING HV OVERHEAD	SERVICE JOINT
EXISTING EHV OVERHEAD	
PROPOSING DISCONNECTED	

Dig Sites
Area:
Line:

100m

lastmile
Asset Management

Last Mile Asset Management Limited
Fenick House, Lister Way
Hamilton International Technology Park
Glasgow G72 0FT
Telephone 03300 587 443



**In an emergency call 105,
24 hours a day**

Date Requested: 23/10/2023
Job Reference: 31278625
Site Location: 449918 118275
Requested by:
Ms Debbie Wigston

Your Scheme/Reference: 8230679

Scale: 1:500 (When plotted at A3)

IMPORTANT INFO

This plan shows cables owned by Last Mile Electricity Limited in their role as a Licensed Distributor (IDNO). Cables owned by other Distributors or privately owned cables (or, indeed, any other apparatus, equipment or infrastructure may also be present in the area. Information regarding such cables (or any such other apparatus, equipment, or infrastructure) should be obtained from the relevant owners.

The information shown on these plans is provided for general information purposes only and should not be relied on or treated as a substitute for your own enquiries. We make no warranty, representation, or guarantee, whether express or implied, regarding the content of the plans or that the content is accurate, complete, or up to date. No liability of any kind whatsoever is accepted by Last Mile Asset Management Limited, or their agents, servants or contractors for any error, omission, or misstatement.

Safe digging practices, in accordance with HS(G)47, must be used to verify and establish the actual position of all electrical cables and apparatus on site before any mechanical plant is used. It is your responsibility to ensure that this information is provided to all persons on or near electrical cables or apparatus. The information included on this plan should not be referred to beyond a period of 3 month from the date of issue.

ELECTRIC KEY

PROPOSED LV SERVICE	-----	LV STRAIGHT JOINT	
PROPOSED LV	- - - - -	LV BREACH JOINT	
PROPOSED HV	- - - - -	HV STRAIGHT JOINT	
PROPOSED EHV (UG)	- - - - -	HV BREACH JOINT	
EXISTING/AS LAID LV SERVICE	-----	STREET LIGHTING C.P	
EXISTING/AS LAID LV (UG)	-----	MINI PILLAR	
EXISTING/AS LAID HV (UG)	-----	LINK BOX	
EXISTING/AS LAID EHV (UG)	-----	EARTH SPIKE	
EXISTING LV OVERHEAD	—x—x—	POT END	
EXISTING HV OVERHEAD	—x—x—	SERVICE JOINT	
EXISTING EHV OVERHEAD	—x—x—		
PROPOSING DISCONNECTED	—x—x—		

100m

Dig Sites

Area:

Line:

Last Mile Asset Management Limited
Fenick House, Lister Way
Hamilton International Technology Park
Glasgow G72 0FT
Telephone 03300 587 443

In an emergency call 105,
24 hours a day

Date Requested: 23/10/2023

Job Reference: 31278625

Site Location: 449918 118275

Requested by:
Ms Debbie Wigston

Your Scheme/Reference: 8230679

IMPORTANT INFO

This plan shows cables owned by Last Mile Electricity Limited in their role as a Licensed Distributor (IDNO). Cables owned by other Distributors or privately owned cables (or, indeed, any other apparatus, equipment or infrastructure may also be present in the area. Information regarding such cables (or any such other apparatus, equipment, or infrastructure) should be obtained from the relevant owners.

The information shown on these plans is provided for general information purposes only and should not be relied on or treated as a substitute for your own enquiries. We make no warranty, representation, or guarantee, whether express or implied, regarding the content of the plans or that the content is accurate, complete, or up to date. No liability of any kind whatsoever is accepted by Last Mile Asset Management Limited, or their agents, servants or contractors for any error, omission, or misstatement.

Safe digging practices, in accordance with HS(G)47, must be used to verify and establish the actual position of all electrical cables and apparatus on site before any mechanical plant is used. It is your responsibility to ensure that this information is provided to all persons on or near electrical cables or apparatus. The information included on this plan should not be referred to beyond a period of 3 month from the date of issue.

ELECTRIC KEY

PROPOSED LV SERVICE

PROPOSED LV

PROPOSED HV

PROPOSED EHV (UG)

EXISTING/AS LAID LV SERVICE

EXISTING/AS LAID LV (UG)

EXISTING/AS LAID HV (UG)

EXISTING/AS LAID EHV (UG)

EXISTING LV OVERHEAD

~~EXISTING HV OVERHEAD~~

EXISTING EHV OVERHEAD

PROPOSING DISCONNECTED

LV STRAIGHT JOINT

LV BREACH JOINT

HV STRAIGHT JOINT

HV BREACH JOINT

STREET LIGHTING C.P

MINI PILLAR

LINK BOX

EARTH SPIKE

POT END

SERVICE JOINT

[illegible]

Dig Sites

Area: 

Line:



Last Mile Asset Management Limited
Fenick House, Lister Way
Hamilton International Technology Park
Glasgow G72 0FT
Telephone 03300 587 443



**In an emergency call 105,
24 hours a day**

Date Requested: 23/10/2023
Job Reference: 31278625
Site Location: 449918 118275
Requested by:
Ms Debbie Wigston

Your Scheme/Reference: 8230679

Scale: 1:500 (When plotted at A3)

IMPORTANT INFO

This plan shows cables owned by Last Mile Electricity Limited in their role as a Licensed Distributor (IDNO). Cables owned by other Distributors or privately owned cables (or, indeed, any other apparatus, equipment or infrastructure may also be present in the area. Information regarding such cables (or any such other apparatus, equipment, or infrastructure) should be obtained from the relevant owners.

The information shown on these plans is provided for general information purposes only and should not be relied on or treated as a substitute for your own enquiries. We make no warranty, representation, or guarantee, whether express or implied, regarding the content of the plans or that the content is accurate, complete, or up to date. No liability of any kind whatsoever is accepted by Last Mile Asset Management Limited, or their agents, servants or contractors for any error, omission, or misstatement.

Safe digging practices, in accordance with HS(G)47, must be used to verify and establish the actual position of all electrical cables and apparatus on site before any mechanical plant is used. It is your responsibility to ensure that this information is provided to all persons on or near electrical cables or apparatus. The information included on this plan should not be referred to beyond a period of 3 month from the date of issue.

ELECTRIC KEY

PROPOSED LV SERVICE	LV STRAIGHT JOINT
PROPOSED LV	LV BREACH JOINT
PROPOSED HV	HV STRAIGHT JOINT
PROPOSED EHV (UG)	HV BREACH JOINT
EXISTING/AS LAID LV SERVICE	STREET LIGHTING C.P
EXISTING/AS LAID LV (UG)	MINI PILLAR
EXISTING/AS LAID HV (UG)	LINK BOX
EXISTING/AS LAID EHV (UG)	EARTH SPIKE
EXISTING LV OVERHEAD	POT END
EXISTING HV OVERHEAD	SERVICE JOINT
EXISTING EHV OVERHEAD	
PROPOSING DISCONNECTED	

Dig Sites


Area:

Line:

100m

lastmile
Asset Management

Last Mile Asset Management Limited
Fenick House, Lister Way
Hamilton International Technology Park
Glasgow G72 0FT
Telephone 03300 587 443

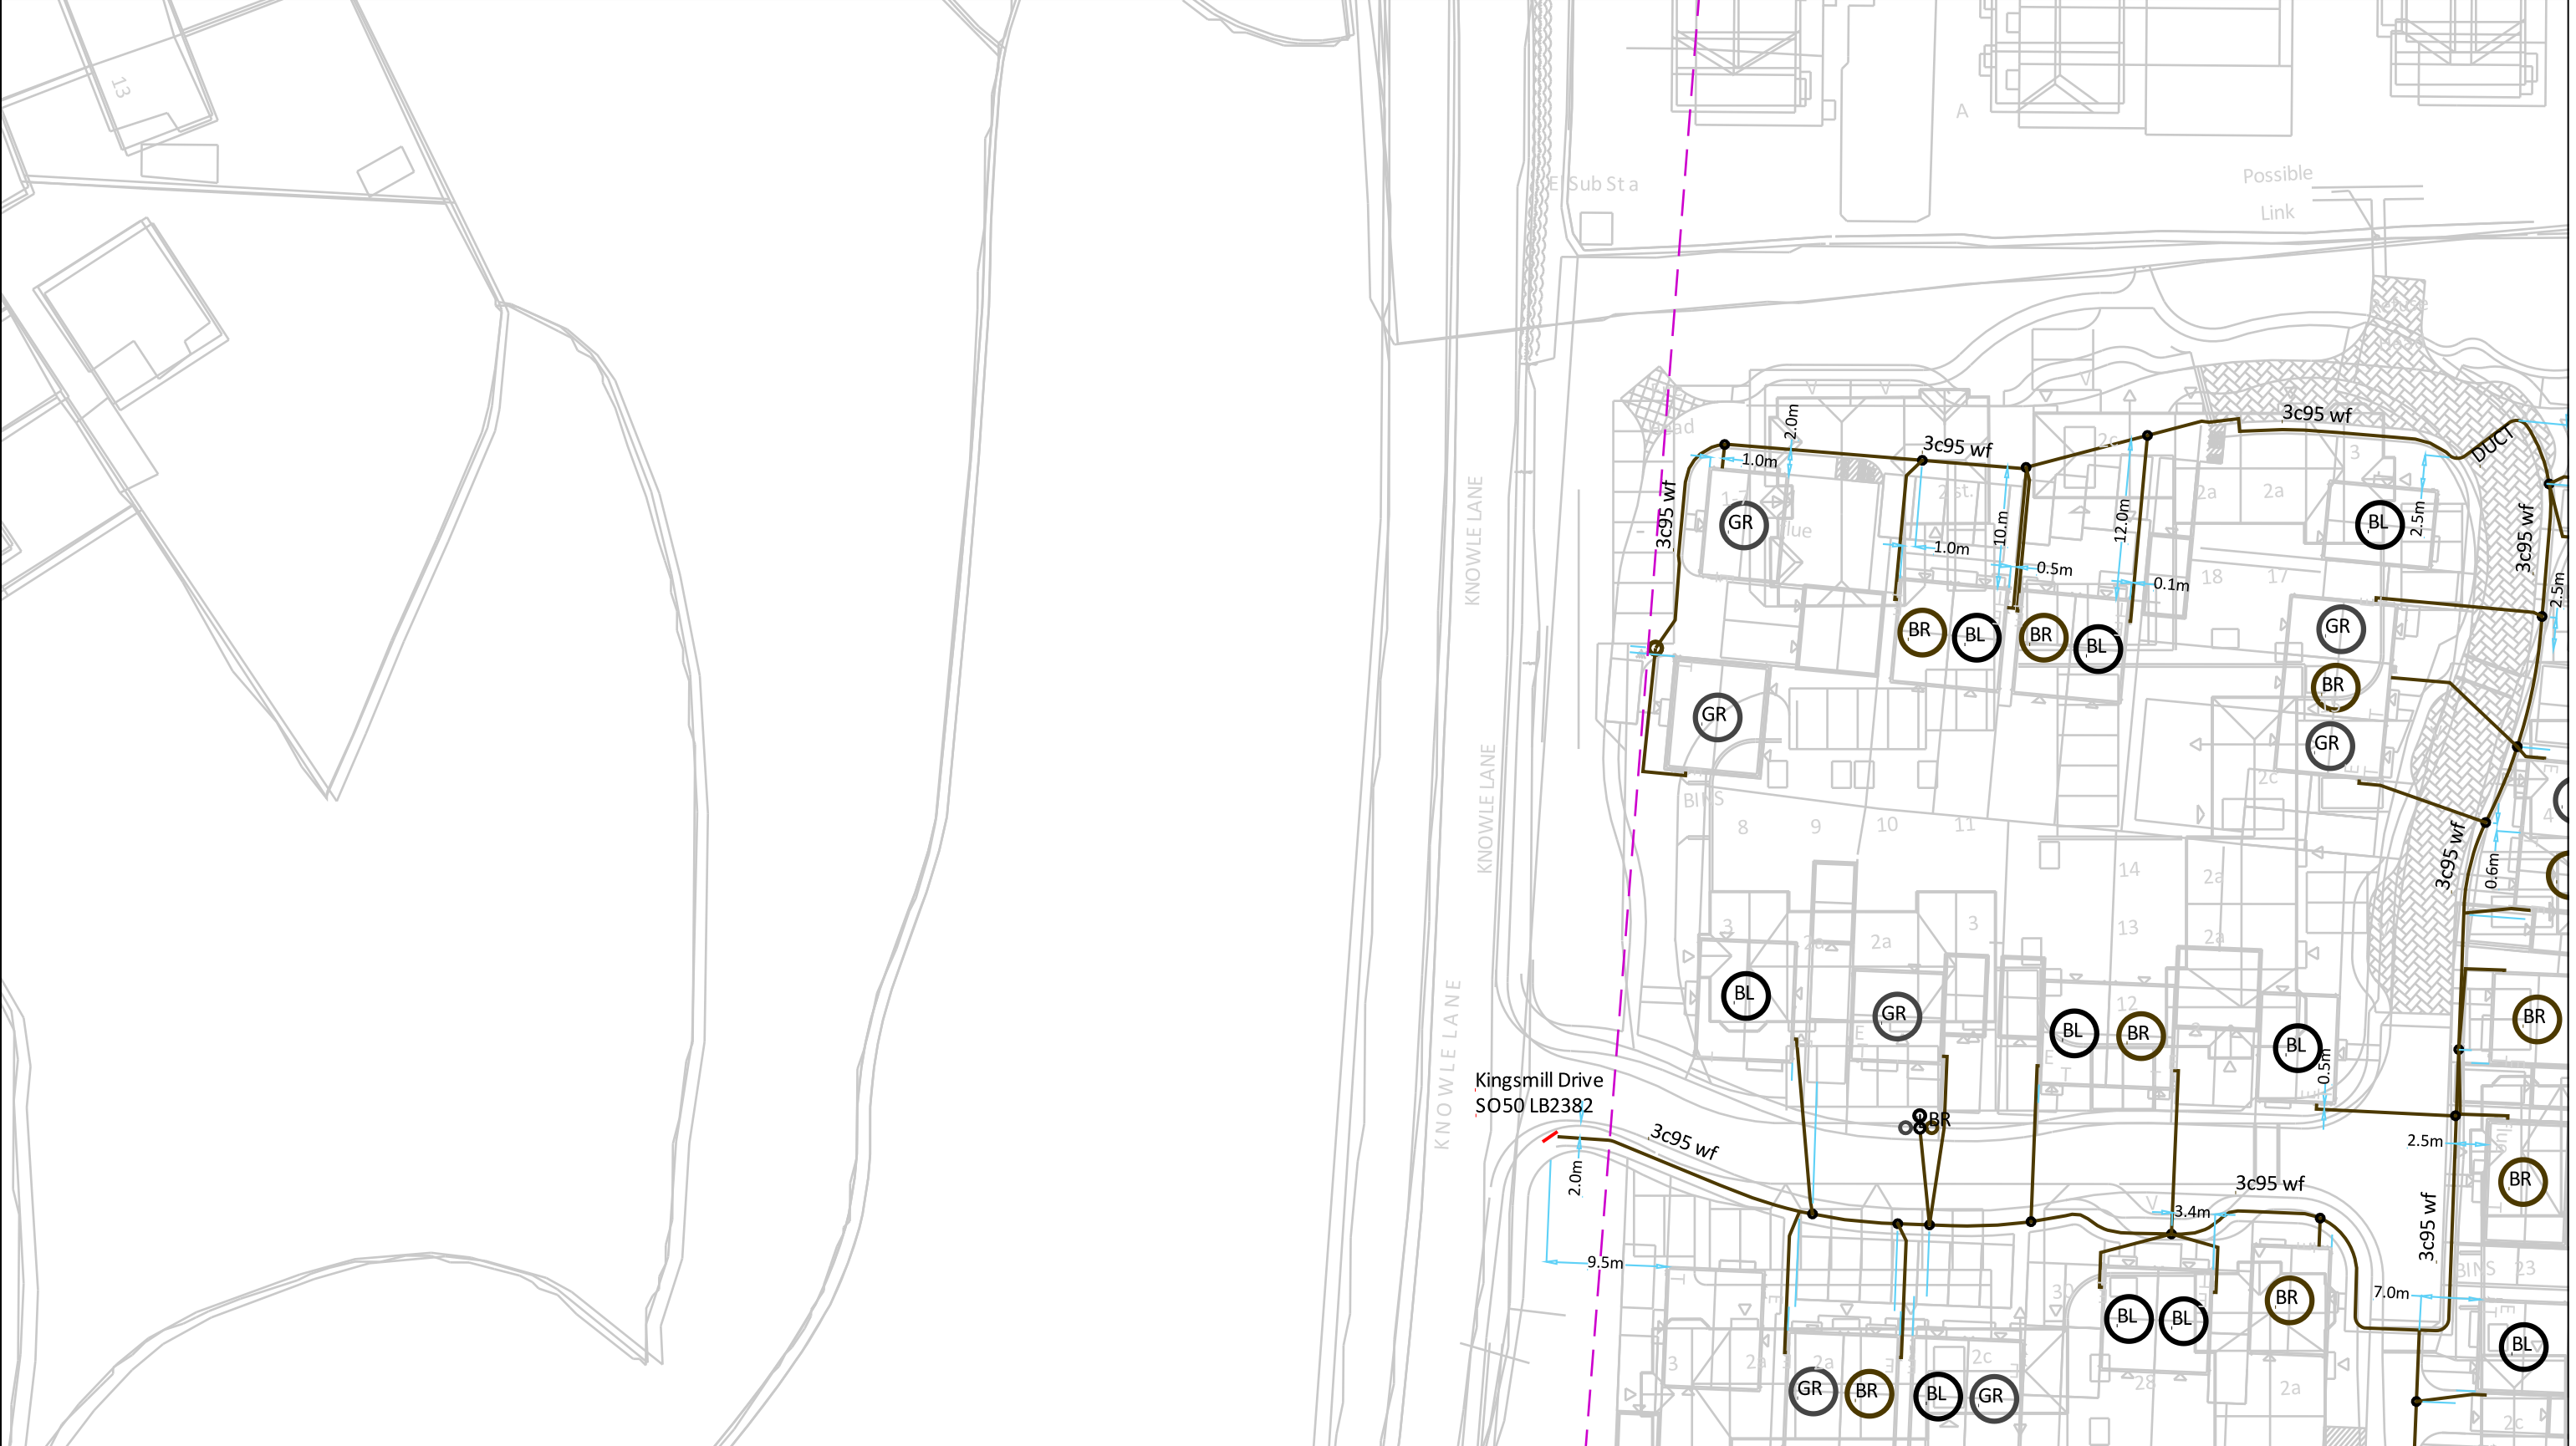

**In an emergency call 105,
24 hours a day**

Date Requested: 23/10/2023
Job Reference: 31278625
Site Location: 449918 118275
Requested by:
Ms Debbie Wigston

Your Scheme/Reference: 8230679

Scale: 1:500 (When plotted at A3)

IMPORTANT INFO

This plan shows cables owned by Last Mile Electricity Limited in their role as a Licensed Distributor (IDNO). Cables owned by other Distributors or privately owned cables (or, indeed, any other apparatus, equipment or infrastructure may also be present in the area. Information regarding such cables (or any such other apparatus, equipment, or infrastructure) should be obtained from the relevant owners.

The information shown on these plans is provided for general information purposes only and should not be relied on or treated as a substitute for your own enquiries. We make no warranty, representation, or guarantee, whether express or implied, regarding the content of the plans or that the content is accurate, complete, or up to date. No liability of any kind whatsoever is accepted by Last Mile Asset Management Limited, or their agents, servants or contractors for any error, omission, or misstatement.

Safe digging practices, in accordance with HS(G)47, must be used to verify and establish the actual position of all electrical cables and apparatus on site before any mechanical plant is used. It is your responsibility to ensure that this information is provided to all persons on or near electrical cables or apparatus. The information included on this plan should not be referred to beyond a period of 3 month from the date of issue.

ELECTRIC KEY

PROPOSED LV SERVICE	LV STRAIGHT JOINT
PROPOSED LV	LV BREACH JOINT
PROPOSED HV	HV STRAIGHT JOINT
PROPOSED EHV (UG)	HV BREACH JOINT
EXISTING/AS LAID LV SERVICE	STREET LIGHTING C.P
EXISTING/AS LAID LV (UG)	MINI PILLAR
EXISTING/AS LAID HV (UG)	LINK BOX
EXISTING/AS LAID EHV (UG)	EARTH SPIKE
EXISTING LV OVERHEAD	POT END
EXISTING HV OVERHEAD	SERVICE JOINT
EXISTING EHV OVERHEAD	
PROPOSING DISCONNECTED	

Dig Sites

Area:

Line:

Last Mile Asset Management Limited
Fenick House, Lister Way
Hamilton International Technology Park
Glasgow G72 0FT
Telephone 03300 587 443



**In an emergency call 105,
24 hours a day**

Date Requested: 23/10/2023
Job Reference: 31278625
Site Location: 449918 118275
Requested by:
Ms Debbie Wigston

Your Scheme/Reference: 8230679

Scale: 1:500 (When plotted at A3)

IMPORTANT INFO

This plan shows cables owned by Last Mile Electricity Limited in their role as a Licensed Distributor (IDNO). Cables owned by other Distributors or privately owned cables (or, indeed, any other apparatus, equipment or infrastructure may also be present in the area. Information regarding such cables (or any such other apparatus, equipment, or infrastructure) should be obtained from the relevant owners.

The information shown on these plans is provided for general information purposes only and should not be relied on or treated as a substitute for your own enquiries. We make no warranty, representation, or guarantee, whether express or implied, regarding the content of the plans or that the content is accurate, complete, or up to date. No liability of any kind whatsoever is accepted by Last Mile Asset Management Limited, or their agents, servants or contractors for any error, omission, or misstatement.

Safe digging practices, in accordance with HS(G)47, must be used to verify and establish the actual position of all electrical cables and apparatus on site before any mechanical plant is used. It is your responsibility to ensure that this information is provided to all persons on or near electrical cables or apparatus. The information included on this plan should not be referred to beyond a period of 3 month from the date of issue.

ELECTRIC KEY


PROPOSED LV SERVICE	-----	LV STRAIGHT JOINT	
PROPOSED LV	- - - - -	LV BREACH JOINT	
PROPOSED HV	- - - - -	HV STRAIGHT JOINT	
PROPOSED EHV (UG)	- - - - -	HV BREACH JOINT	
EXISTING/AS LAID LV SERVICE	-----	STREET LIGHTING C.P	
EXISTING/AS LAID LV (UG)	-----	MINI PILLAR	
EXISTING/AS LAID HV (UG)	-----	LINK BOX	
EXISTING/AS LAID EHV (UG)	-----	EARTH SPIKE	
EXISTING LV OVERHEAD	—x—x—	POT END	
EXISTING HV OVERHEAD	—x—x—	SERVICE JOINT	
EXISTING EHV OVERHEAD	—x—x—		
PROPOSING DISCONNECTED	—x—x—		


Dig Sites

Area:

Line:

Last Mile Asset Management Limited
Fenick House, Lister Way
Hamilton International Technology Park
Glasgow G72 0FT
Telephone 03300 587 443

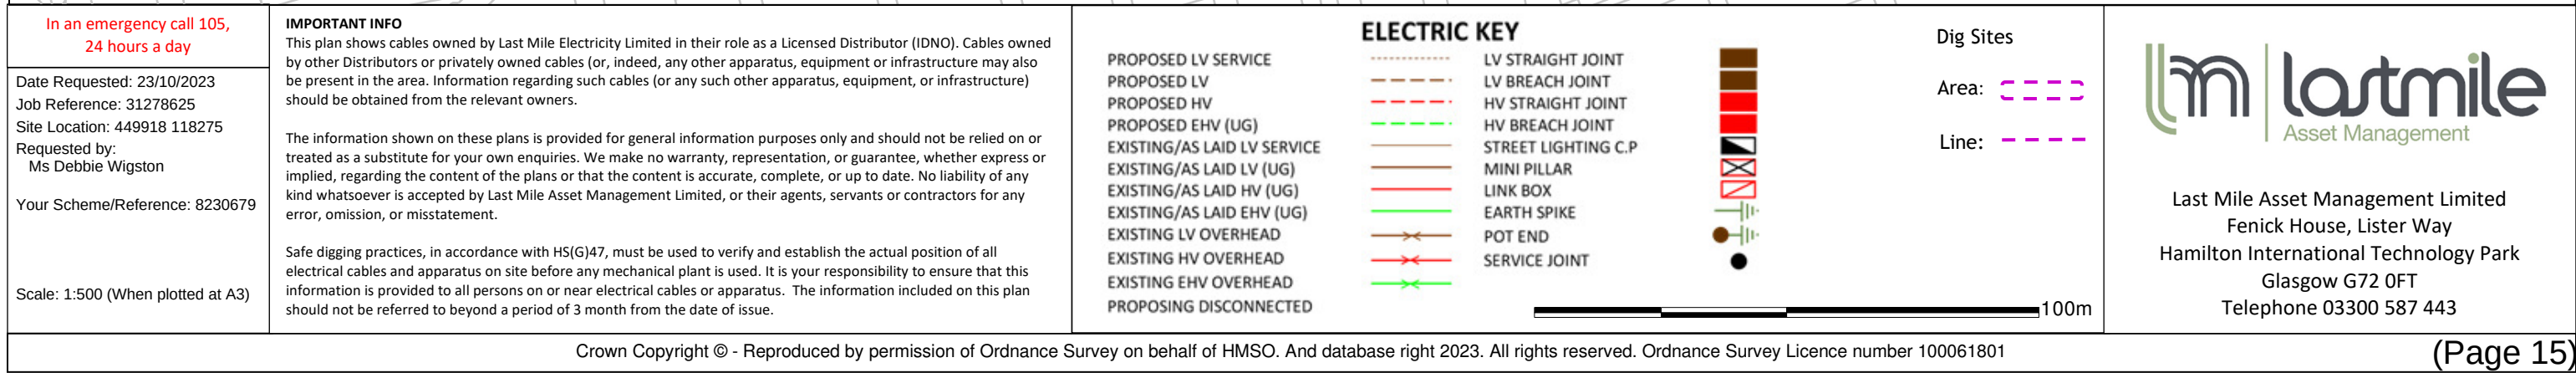

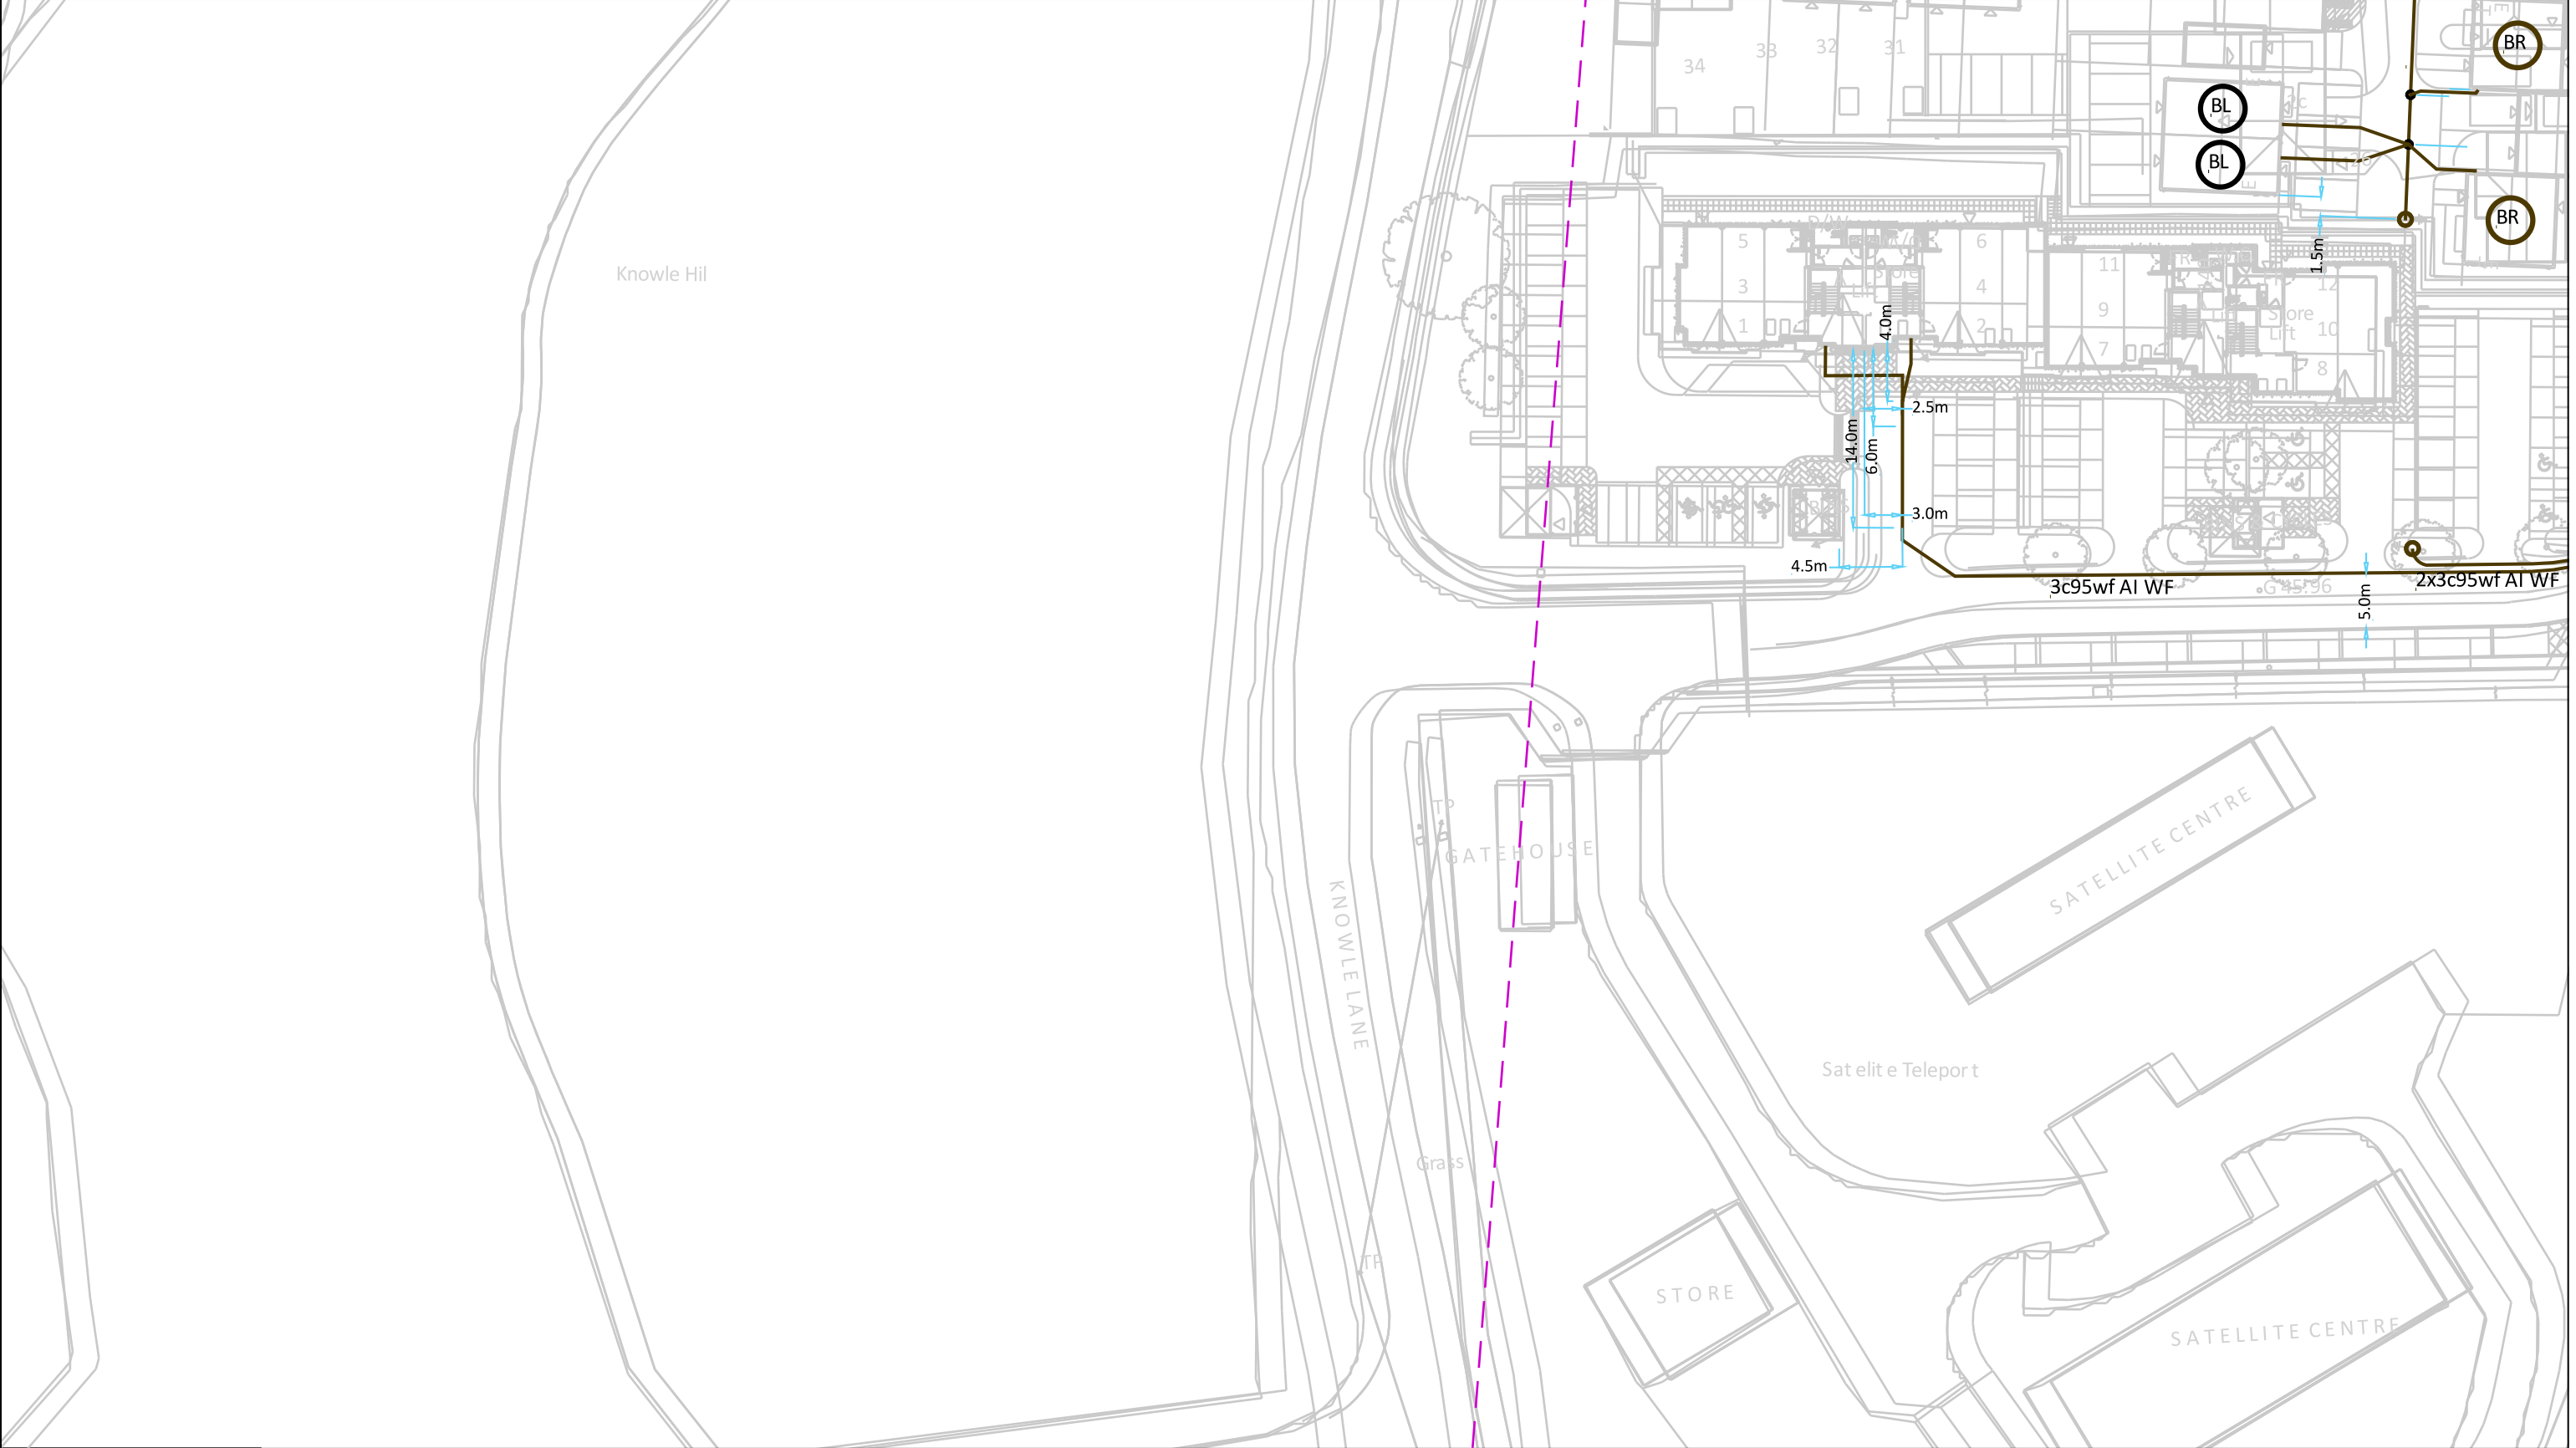

In an emergency call 105, 24 hours a day

Date Requested: 23/10/2023
Job Reference: 31278625
Site Location: 449918 118275
Requested by: Ms Debbie Wigston
Your Scheme/Reference: 8230679

Scale: 1:500 (When plotted at A3)

IMPORTANT INFO

This plan shows cables owned by Last Mile Electricity Limited in their role as a Licensed Distributor (IDNO). Cables owned by other Distributors or privately owned cables (or, indeed, any other apparatus, equipment or infrastructure may also be present in the area. Information regarding such cables (or any such other apparatus, equipment, or infrastructure) should be obtained from the relevant owners.

The information shown on these plans is provided for general information purposes only and should not be relied on or treated as a substitute for your own enquiries. We make no warranty, representation, or guarantee, whether express or implied, regarding the content of the plans or that the content is accurate, complete, or up to date. No liability of any kind whatsoever is accepted by Last Mile Asset Management Limited, or their agents, servants or contractors for any error, omission, or misstatement.

Safe digging practices, in accordance with HS(G)47, must be used to verify and establish the actual position of all electrical cables and apparatus on site before any mechanical plant is used. It is your responsibility to ensure that this information is provided to all persons on or near electrical cables or apparatus. The information included on this plan should not be referred to beyond a period of 3 month from the date of issue.

ELECTRIC KEY


PROPOSED LV SERVICE	LV STRAIGHT JOINT
PROPOSED LV	LV BREACH JOINT
PROPOSED HV	HV STRAIGHT JOINT
PROPOSED EHV (UG)	HV BREACH JOINT
EXISTING/AS LAID LV SERVICE	STREET LIGHTING C.P
EXISTING/AS LAID LV (UG)	MINI PILLAR
EXISTING/AS LAID HV (UG)	LINK BOX
EXISTING/AS LAID EHV (UG)	EARTH SPIKE
EXISTING LV OVERHEAD	POT END
EXISTING HV OVERHEAD	SERVICE JOINT
EXISTING EHV OVERHEAD	
PROPOSING DISCONNECTED	

Dig Sites

Area:

Line:

Last Mile Asset Management Limited
Fenick House, Lister Way
Hamilton International Technology Park
Glasgow G72 0FT
Telephone 03300 587 443

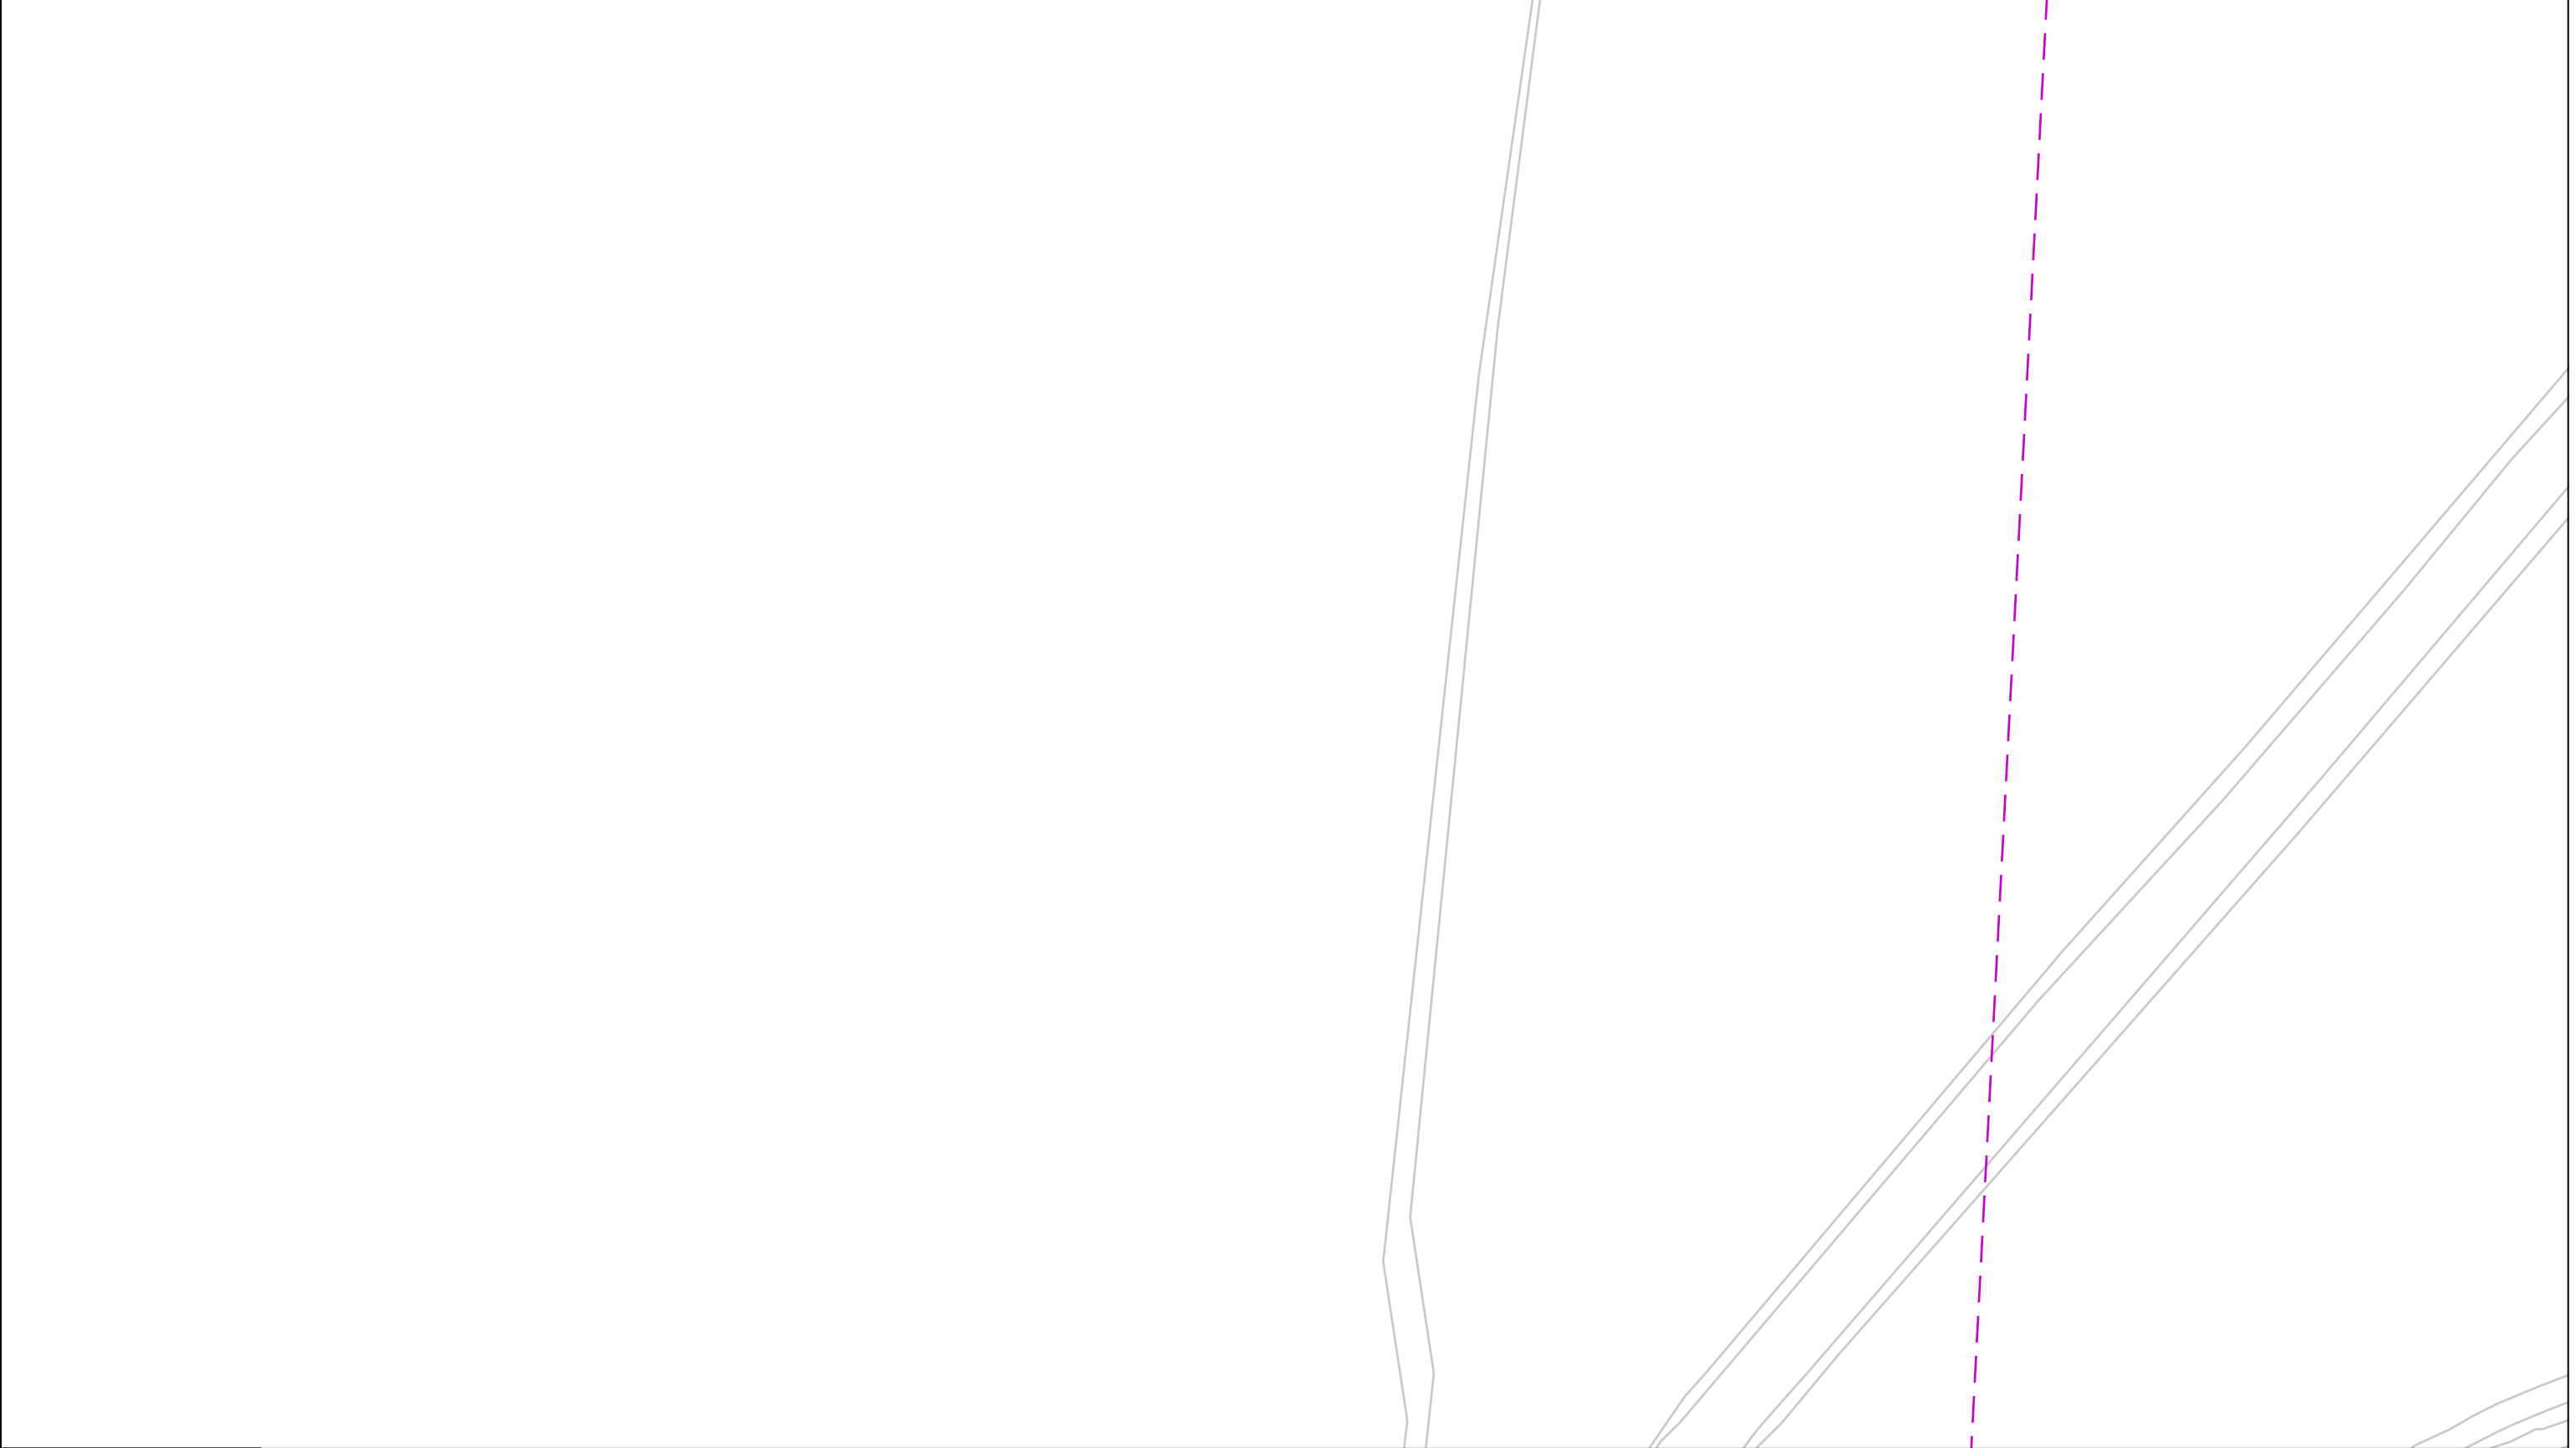

**In an emergency call 105,
24 hours a day**

Date Requested: 23/10/2023
Job Reference: 31278625
Site Location: 449918 118275
Requested by:
Ms Debbie Wigston

Your Scheme/Reference: 8230679

Scale: 1:500 (When plotted at A3)

IMPORTANT INFO

This plan shows cables owned by Last Mile Electricity Limited in their role as a Licensed Distributor (IDNO). Cables owned by other Distributors or privately owned cables (or, indeed, any other apparatus, equipment or infrastructure may also be present in the area. Information regarding such cables (or any such other apparatus, equipment, or infrastructure) should be obtained from the relevant owners.

The information shown on these plans is provided for general information purposes only and should not be relied on or treated as a substitute for your own enquiries. We make no warranty, representation, or guarantee, whether express or implied, regarding the content of the plans or that the content is accurate, complete, or up to date. No liability of any kind whatsoever is accepted by Last Mile Asset Management Limited, or their agents, servants or contractors for any error, omission, or misstatement.

Safe digging practices, in accordance with HS(G)47, must be used to verify and establish the actual position of all electrical cables and apparatus on site before any mechanical plant is used. It is your responsibility to ensure that this information is provided to all persons on or near electrical cables or apparatus. The information included on this plan should not be referred to beyond a period of 3 month from the date of issue.

ELECTRIC KEY

PROPOSED LV SERVICE	LV STRAIGHT JOINT	
PROPOSED LV	LV BREACH JOINT	
PROPOSED HV	HV STRAIGHT JOINT	
PROPOSED EHV (UG)	HV BREACH JOINT	
EXISTING/AS LAID LV SERVICE	STREET LIGHTING C.P	
EXISTING/AS LAID LV (UG)	MINI PILLAR	
EXISTING/AS LAID HV (UG)	LINK BOX	
EXISTING/AS LAID EHV (UG)	EARTH SPIKE	
EXISTING LV OVERHEAD	POT END	
EXISTING HV OVERHEAD	SERVICE JOINT	
EXISTING EHV OVERHEAD		
PROPOSING DISCONNECTED		

100m

Dig Sites

Area:

Line:

Last Mile Asset Management Limited
Fenick House, Lister Way
Hamilton International Technology Park
Glasgow G72 0FT
Telephone 03300 587 443



**In an emergency call 105,
24 hours a day**

Date Requested: 23/10/2023
Job Reference: 31278625
Site Location: 449918 118275
Requested by:
Ms Debbie Wigston

Your Scheme/Reference: 8230679

Scale: 1:500 (When plotted at A3)

IMPORTANT INFO
This plan shows cables owned by Last Mile Electricity Limited in their role as a Licensed Distributor (IDNO). Cables owned by other Distributors or privately owned cables (or, indeed, any other apparatus, equipment or infrastructure may also be present in the area. Information regarding such cables (or any such other apparatus, equipment, or infrastructure) should be obtained from the relevant owners.

The information shown on these plans is provided for general information purposes only and should not be relied on or treated as a substitute for your own enquiries. We make no warranty, representation, or guarantee, whether express or implied, regarding the content of the plans or that the content is accurate, complete, or up to date. No liability of any kind whatsoever is accepted by Last Mile Asset Management Limited, or their agents, servants or contractors for any error, omission, or misstatement.

Safe digging practices, in accordance with HS(G)47, must be used to verify and establish the actual position of all electrical cables and apparatus on site before any mechanical plant is used. It is your responsibility to ensure that this information is provided to all persons on or near electrical cables or apparatus. The information included on this plan should not be referred to beyond a period of 3 month from the date of issue.

ELECTRIC KEY


PROPOSED LV SERVICE	LV STRAIGHT JOINT
PROPOSED LV	LV BREACH JOINT
PROPOSED HV	HV STRAIGHT JOINT
PROPOSED EHV (UG)	HV BREACH JOINT
EXISTING/AS LAID LV SERVICE	STREET LIGHTING C.P
EXISTING/AS LAID LV (UG)	MINI PILLAR
EXISTING/AS LAID HV (UG)	LINK BOX
EXISTING/AS LAID EHV (UG)	EARTH SPIKE
EXISTING LV OVERHEAD	POT END
EXISTING HV OVERHEAD	SERVICE JOINT
EXISTING EHV OVERHEAD	
PROPOSING DISCONNECTED	

Dig Sites

Area:

Line:

Last Mile Asset Management Limited
Fenick House, Lister Way
Hamilton International Technology Park
Glasgow G72 0FT
Telephone 03300 587 443

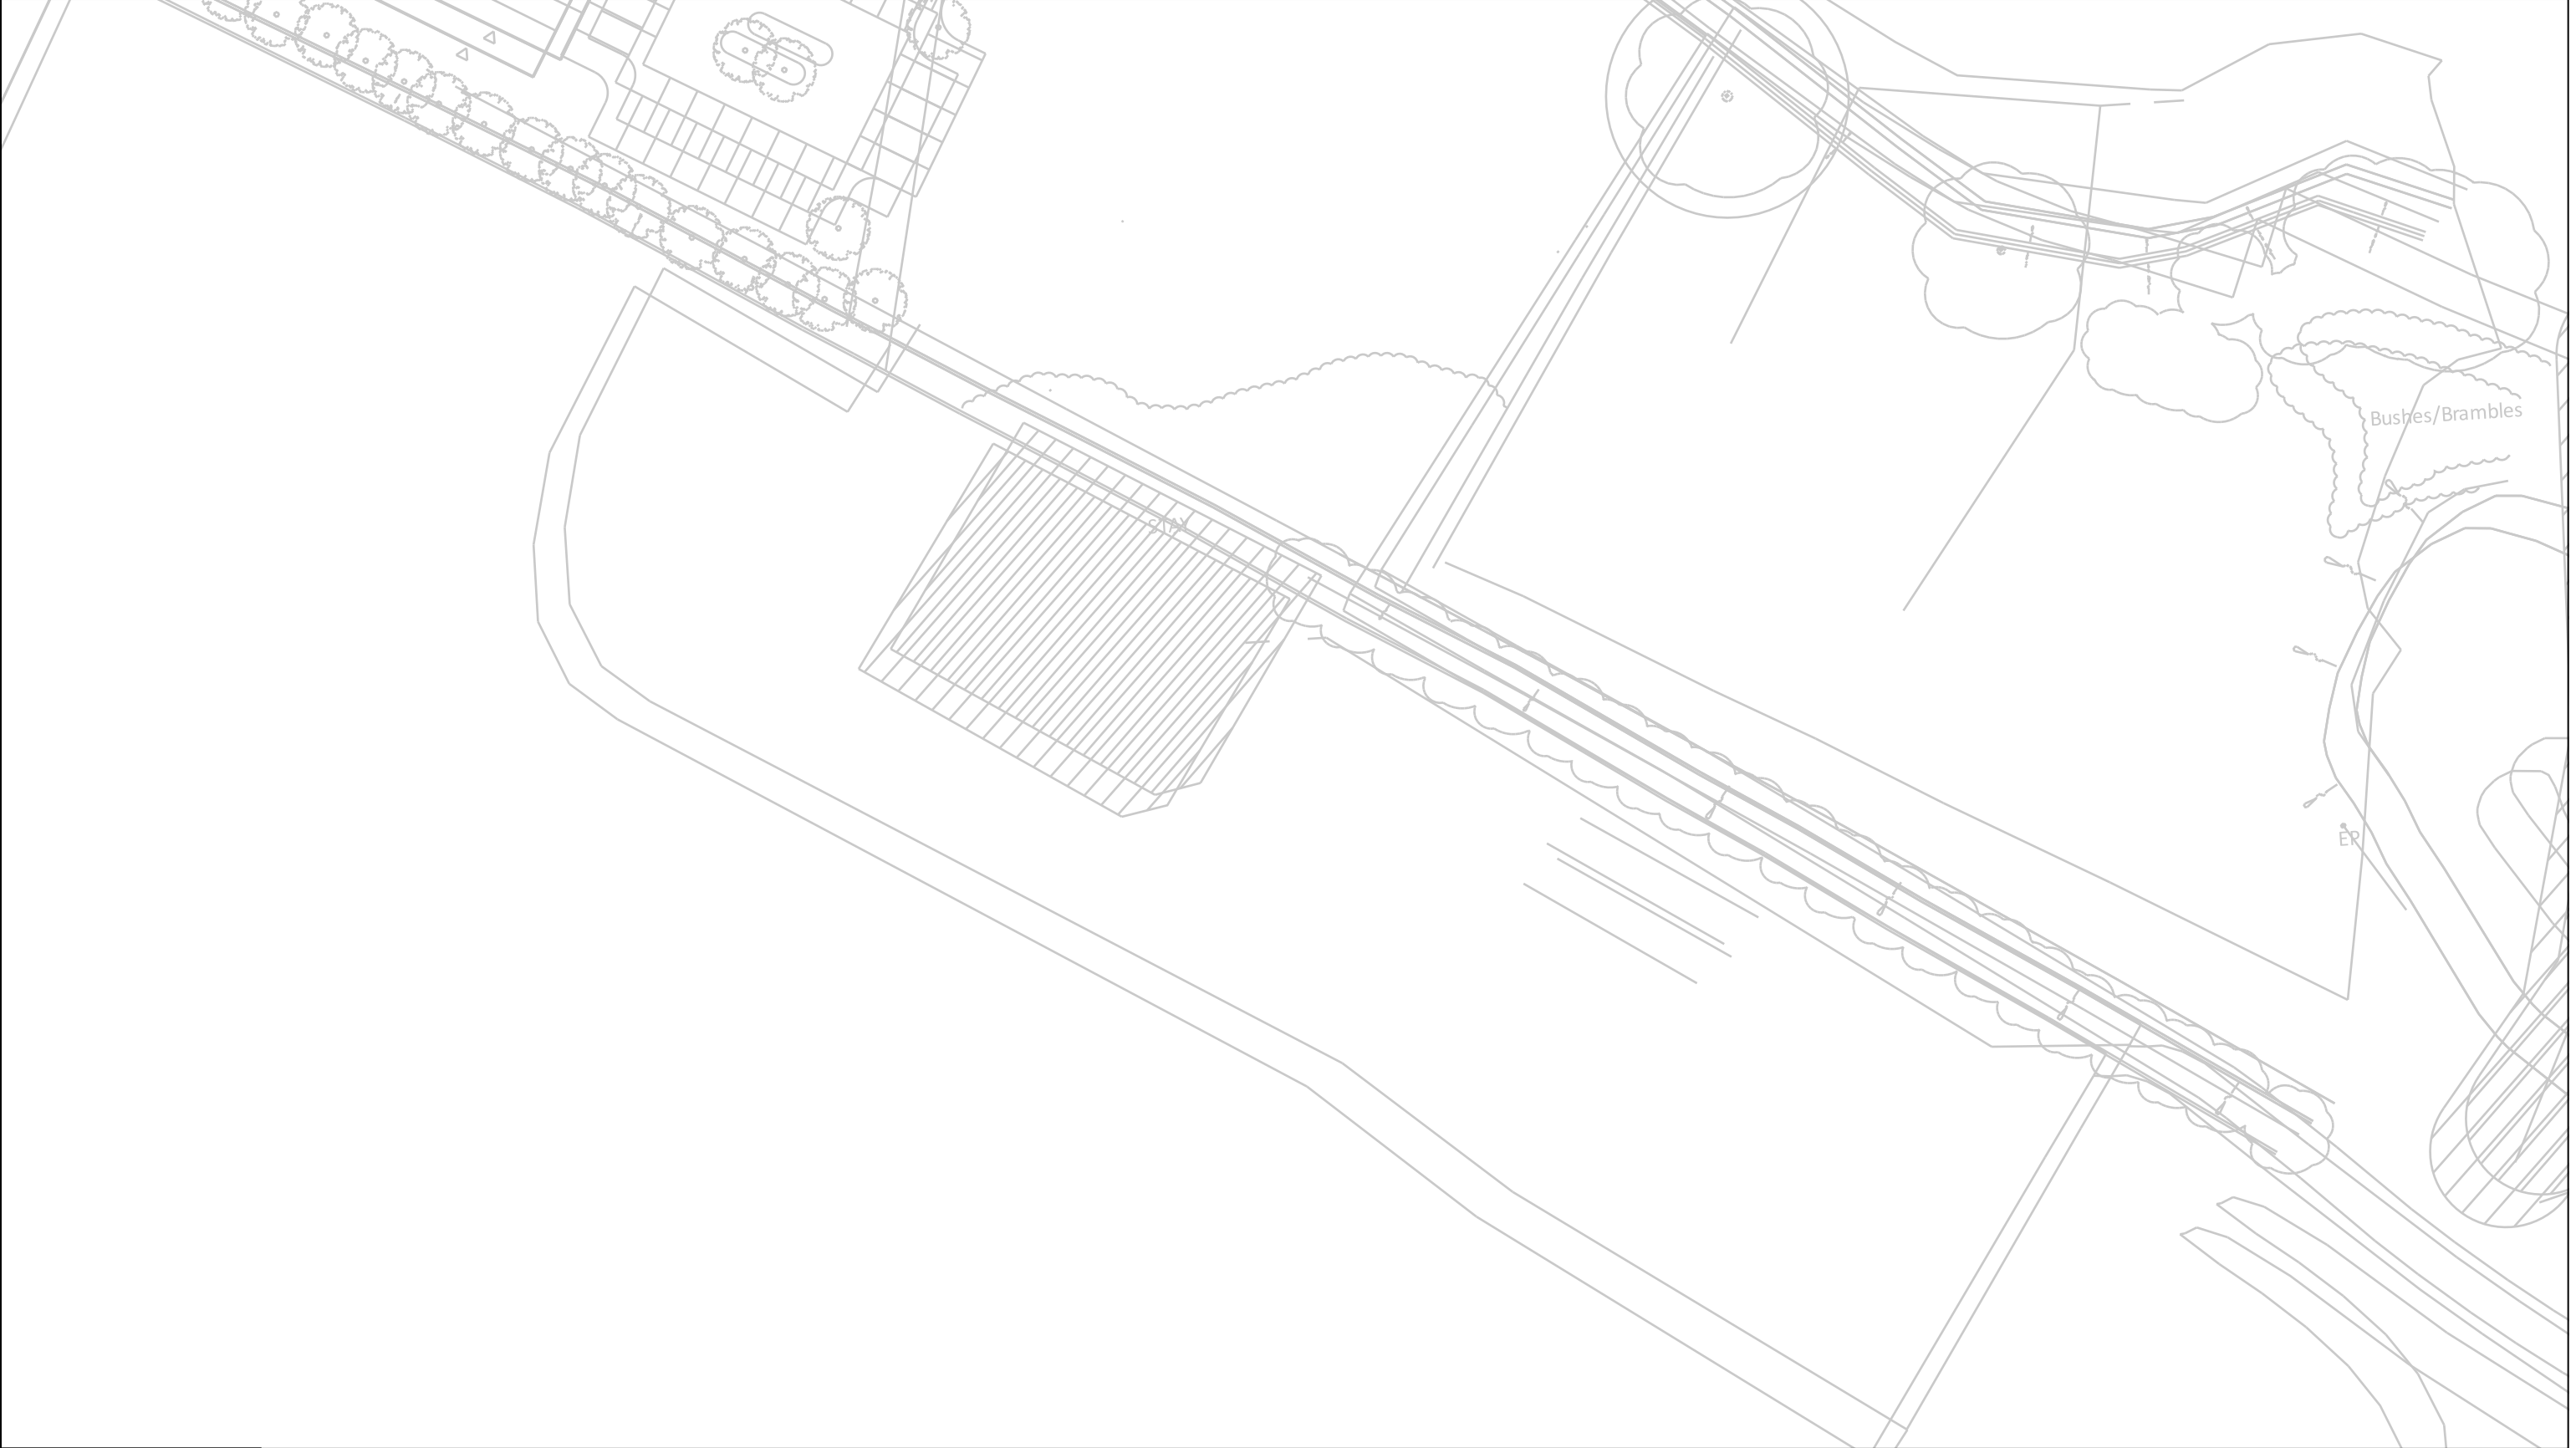

In an emergency call 105, 24 hours a day

Date Requested: 23/10/2023
Job Reference: 31278625
Site Location: 449918 118275
Requested by: Ms Debbie Wigston
Your Scheme/Reference: 8230679

Scale: 1:500 (When plotted at A3)

IMPORTANT INFO

This plan shows cables owned by Last Mile Electricity Limited in their role as a Licensed Distributor (IDNO). Cables owned by other Distributors or privately owned cables (or, indeed, any other apparatus, equipment or infrastructure may also be present in the area. Information regarding such cables (or any such other apparatus, equipment, or infrastructure) should be obtained from the relevant owners.

The information shown on these plans is provided for general information purposes only and should not be relied on or treated as a substitute for your own enquiries. We make no warranty, representation, or guarantee, whether express or implied, regarding the content of the plans or that the content is accurate, complete, or up to date. No liability of any kind whatsoever is accepted by Last Mile Asset Management Limited, or their agents, servants or contractors for any error, omission, or misstatement.

Safe digging practices, in accordance with HS(G)47, must be used to verify and establish the actual position of all electrical cables and apparatus on site before any mechanical plant is used. It is your responsibility to ensure that this information is provided to all persons on or near electrical cables or apparatus. The information included on this plan should not be referred to beyond a period of 3 month from the date of issue.

ELECTRIC KEY

PROPOSED LV SERVICE	LV STRAIGHT JOINT
PROPOSED LV	LV BREACH JOINT
PROPOSED HV	HV STRAIGHT JOINT
PROPOSED EHV (UG)	HV BREACH JOINT
EXISTING/AS LAID LV SERVICE	STREET LIGHTING C.P
EXISTING/AS LAID LV (UG)	MINI PILLAR
EXISTING/AS LAID HV (UG)	LINK BOX
EXISTING/AS LAID EHV (UG)	EARTH SPIKE
EXISTING LV OVERHEAD	POT END
EXISTING HV OVERHEAD	SERVICE JOINT
EXISTING EHV OVERHEAD	
PROPOSING DISCONNECTED	

100m

Dig Sites

Area:

Line:

Last Mile Asset Management Limited
Fenick House, Lister Way
Hamilton International Technology Park
Glasgow G72 0FT
Telephone 03300 587 443

Crown Copyright © - Reproduced by permission of Ordnance Survey on behalf of HMSO. And database right 2023. All rights reserved. Ordnance Survey Licence number 100061801

(Page 19)



**In an emergency call 105,
24 hours a day**

Date Requested: 23/10/2023
Job Reference: 31278625
Site Location: 449918 118275
Requested by:
Ms Debbie Wigston

Your Scheme/Reference: 8230679

Scale: 1:500 (When plotted at A3)

IMPORTANT INFO
This plan shows cables owned by Last Mile Electricity Limited in their role as a Licensed Distributor (IDNO). Cables owned by other Distributors or privately owned cables (or, indeed, any other apparatus, equipment or infrastructure may also be present in the area. Information regarding such cables (or any such other apparatus, equipment, or infrastructure) should be obtained from the relevant owners.

The information shown on these plans is provided for general information purposes only and should not be relied on or treated as a substitute for your own enquiries. We make no warranty, representation, or guarantee, whether express or implied, regarding the content of the plans or that the content is accurate, complete, or up to date. No liability of any kind whatsoever is accepted by Last Mile Asset Management Limited, or their agents, servants or contractors for any error, omission, or misstatement.

Safe digging practices, in accordance with HS(G)47, must be used to verify and establish the actual position of all electrical cables and apparatus on site before any mechanical plant is used. It is your responsibility to ensure that this information is provided to all persons on or near electrical cables or apparatus. The information included on this plan should not be referred to beyond a period of 3 month from the date of issue.

ELECTRIC KEY

PROPOSED LV SERVICE	-----	LV STRAIGHT JOINT
PROPOSED LV	- - - - -	LV BREACH JOINT
PROPOSED HV	- . - . -	HV STRAIGHT JOINT
PROPOSED EHV (UG)	- . - . -	HV BREACH JOINT
EXISTING/AS LAID LV SERVICE	-----	STREET LIGHTING C.P
EXISTING/AS LAID LV (UG)	- - - - -	MINI PILLAR
EXISTING/AS LAID HV (UG)	- . - . -	LINK BOX
EXISTING/AS LAID EHV (UG)	- . - . -	EARTH SPIKE
EXISTING LV OVERHEAD	—x—x—	POT END
EXISTING HV OVERHEAD	—x—x—	SERVICE JOINT
EXISTING EHV OVERHEAD	—x—x—	
PROPOSING DISCONNECTED	—x—x—	

Dig Sites

Area:

Line:

Last Mile Asset Management Limited
Fenick House, Lister Way
Hamilton International Technology Park
Glasgow G72 0FT
Telephone 03300 587 443



**In an emergency call 105,
24 hours a day**

Date Requested: 23/10/2023
Job Reference: 31278625
Site Location: 449918 118275
Requested by:
Ms Debbie Wigston

Your Scheme/Reference: 8230679

Scale: 1:500 (When plotted at A3)

IMPORTANT INFO
This plan shows cables owned by Last Mile Electricity Limited in their role as a Licensed Distributor (IDNO). Cables owned by other Distributors or privately owned cables (or, indeed, any other apparatus, equipment or infrastructure may also be present in the area. Information regarding such cables (or any such other apparatus, equipment, or infrastructure) should be obtained from the relevant owners.

The information shown on these plans is provided for general information purposes only and should not be relied on or treated as a substitute for your own enquiries. We make no warranty, representation, or guarantee, whether express or implied, regarding the content of the plans or that the content is accurate, complete, or up to date. No liability of any kind whatsoever is accepted by Last Mile Asset Management Limited, or their agents, servants or contractors for any error, omission, or misstatement.

Safe digging practices, in accordance with HS(G)47, must be used to verify and establish the actual position of all electrical cables and apparatus on site before any mechanical plant is used. It is your responsibility to ensure that this information is provided to all persons on or near electrical cables or apparatus. The information included on this plan should not be referred to beyond a period of 3 month from the date of issue.

ELECTRIC KEY


PROPOSED LV SERVICE	-----	LV STRAIGHT JOINT
PROPOSED LV	-----	LV BREACH JOINT
PROPOSED HV	-----	HV STRAIGHT JOINT
PROPOSED EHV (UG)	-----	HV BREACH JOINT
EXISTING/AS LAID LV SERVICE	-----	STREET LIGHTING C.P
EXISTING/AS LAID LV (UG)	-----	MINI PILLAR
EXISTING/AS LAID HV (UG)	-----	LINK BOX
EXISTING/AS LAID EHV (UG)	-----	EARTH SPIKE
EXISTING LV OVERHEAD	-----	POT END
EXISTING HV OVERHEAD	-----	SERVICE JOINT
EXISTING EHV OVERHEAD	-----	
PROPOSING DISCONNECTED	-----	

Dig Sites

Area:

Line:

Last Mile Asset Management Limited
Fenick House, Lister Way
Hamilton International Technology Park
Glasgow G72 0FT
Telephone 03300 587 443

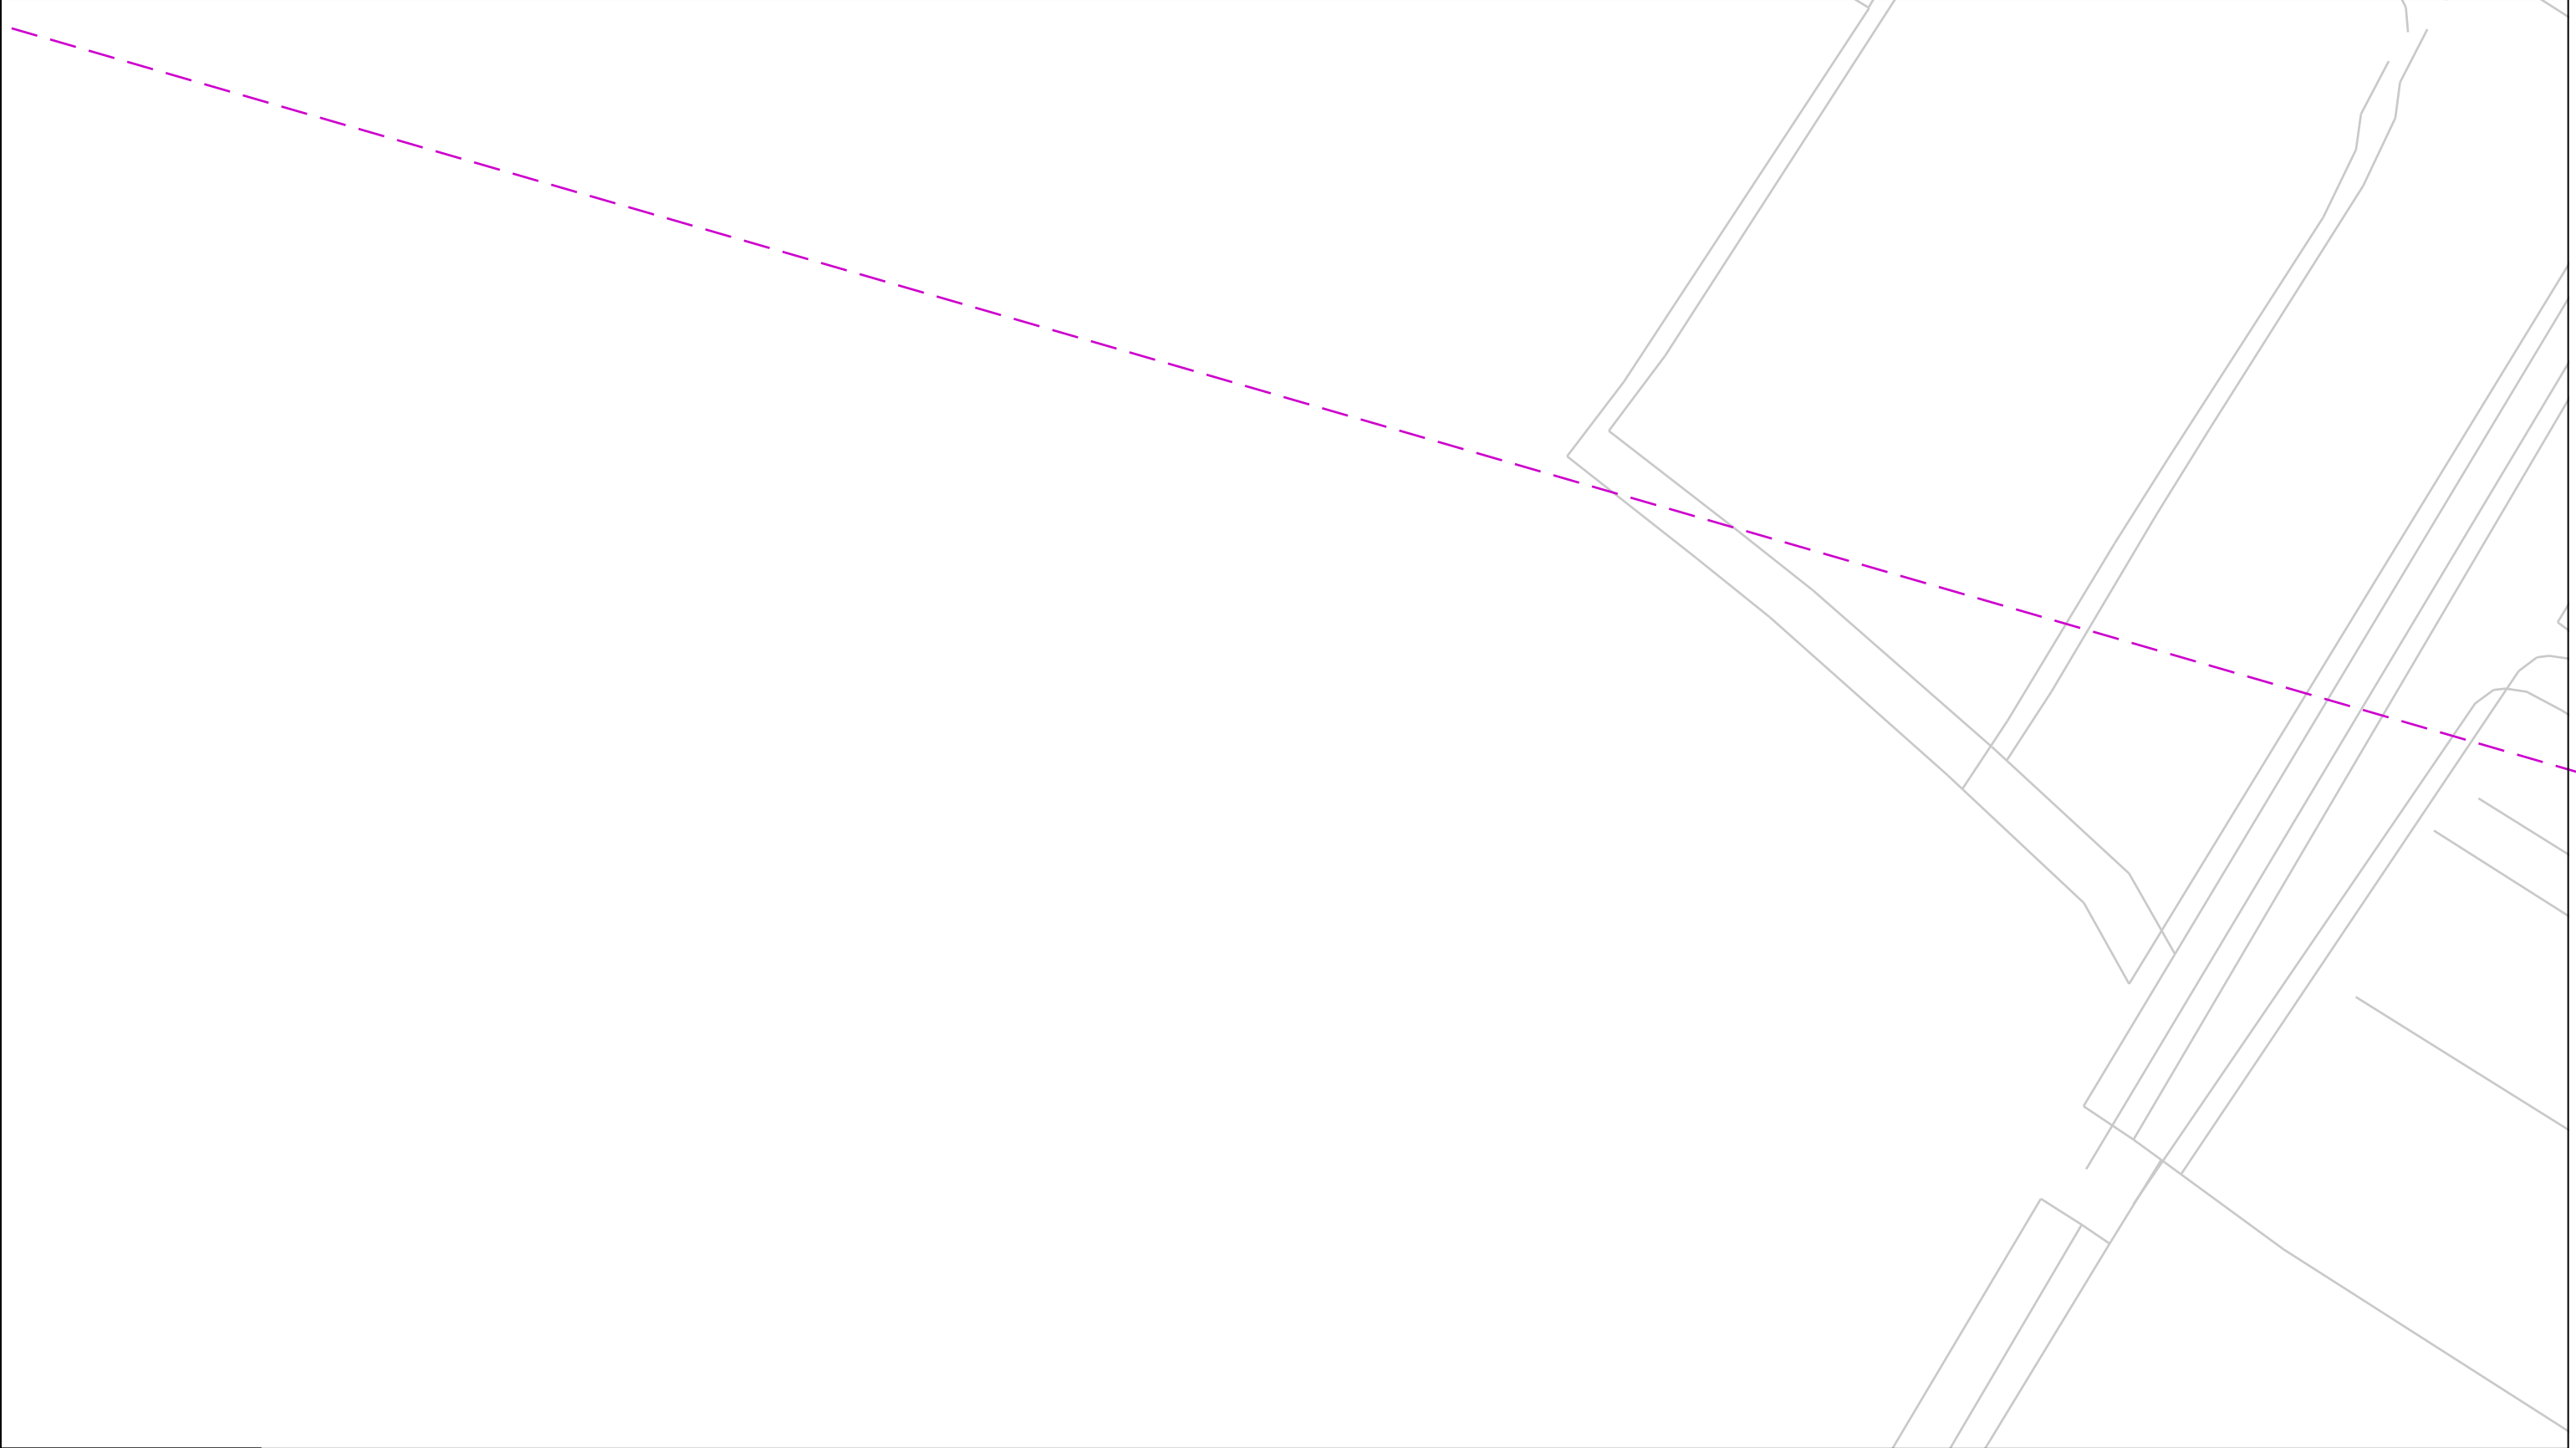

**In an emergency call 105,
24 hours a day**

Date Requested: 23/10/2023
Job Reference: 31278625
Site Location: 449918 118275
Requested by:
Ms Debbie Wigston

Your Scheme/Reference: 8230679

Scale: 1:500 (When plotted at A3)

IMPORTANT INFO

This plan shows cables owned by Last Mile Electricity Limited in their role as a Licensed Distributor (IDNO). Cables owned by other Distributors or privately owned cables (or, indeed, any other apparatus, equipment or infrastructure may also be present in the area. Information regarding such cables (or any such other apparatus, equipment, or infrastructure) should be obtained from the relevant owners.

The information shown on these plans is provided for general information purposes only and should not be relied on or treated as a substitute for your own enquiries. We make no warranty, representation, or guarantee, whether express or implied, regarding the content of the plans or that the content is accurate, complete, or up to date. No liability of any kind whatsoever is accepted by Last Mile Asset Management Limited, or their agents, servants or contractors for any error, omission, or misstatement.

Safe digging practices, in accordance with HS(G)47, must be used to verify and establish the actual position of all electrical cables and apparatus on site before any mechanical plant is used. It is your responsibility to ensure that this information is provided to all persons on or near electrical cables or apparatus. The information included on this plan should not be referred to beyond a period of 3 month from the date of issue.

ELECTRIC KEY


PROPOSED LV SERVICE	-----	LV STRAIGHT JOINT	
PROPOSED LV	- - - - -	LV BREACH JOINT	
PROPOSED HV	- - - - -	HV STRAIGHT JOINT	
PROPOSED EHV (UG)	- - - - -	HV BREACH JOINT	
EXISTING/AS LAID LV SERVICE	-----	STREET LIGHTING C.P	
EXISTING/AS LAID LV (UG)	-----	MINI PILLAR	
EXISTING/AS LAID HV (UG)	-----	LINK BOX	
EXISTING/AS LAID EHV (UG)	-----	EARTH SPIKE	
EXISTING LV OVERHEAD	-----	POT END	
EXISTING HV OVERHEAD	-----	SERVICE JOINT	
EXISTING EHV OVERHEAD	-----		
PROPOSING DISCONNECTED	-----		


Dig Sites

Area:

Line:

Last Mile Asset Management Limited
Fenick House, Lister Way
Hamilton International Technology Park
Glasgow G72 0FT
Telephone 03300 587 443

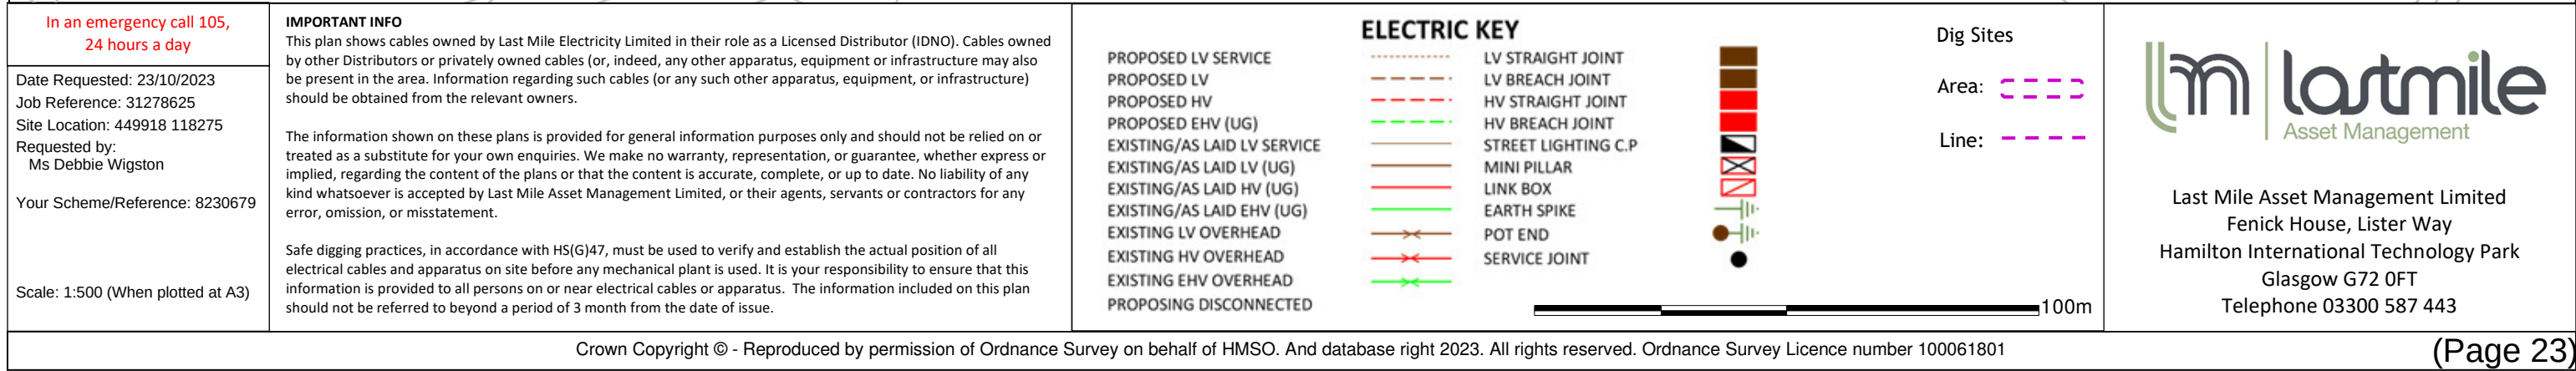

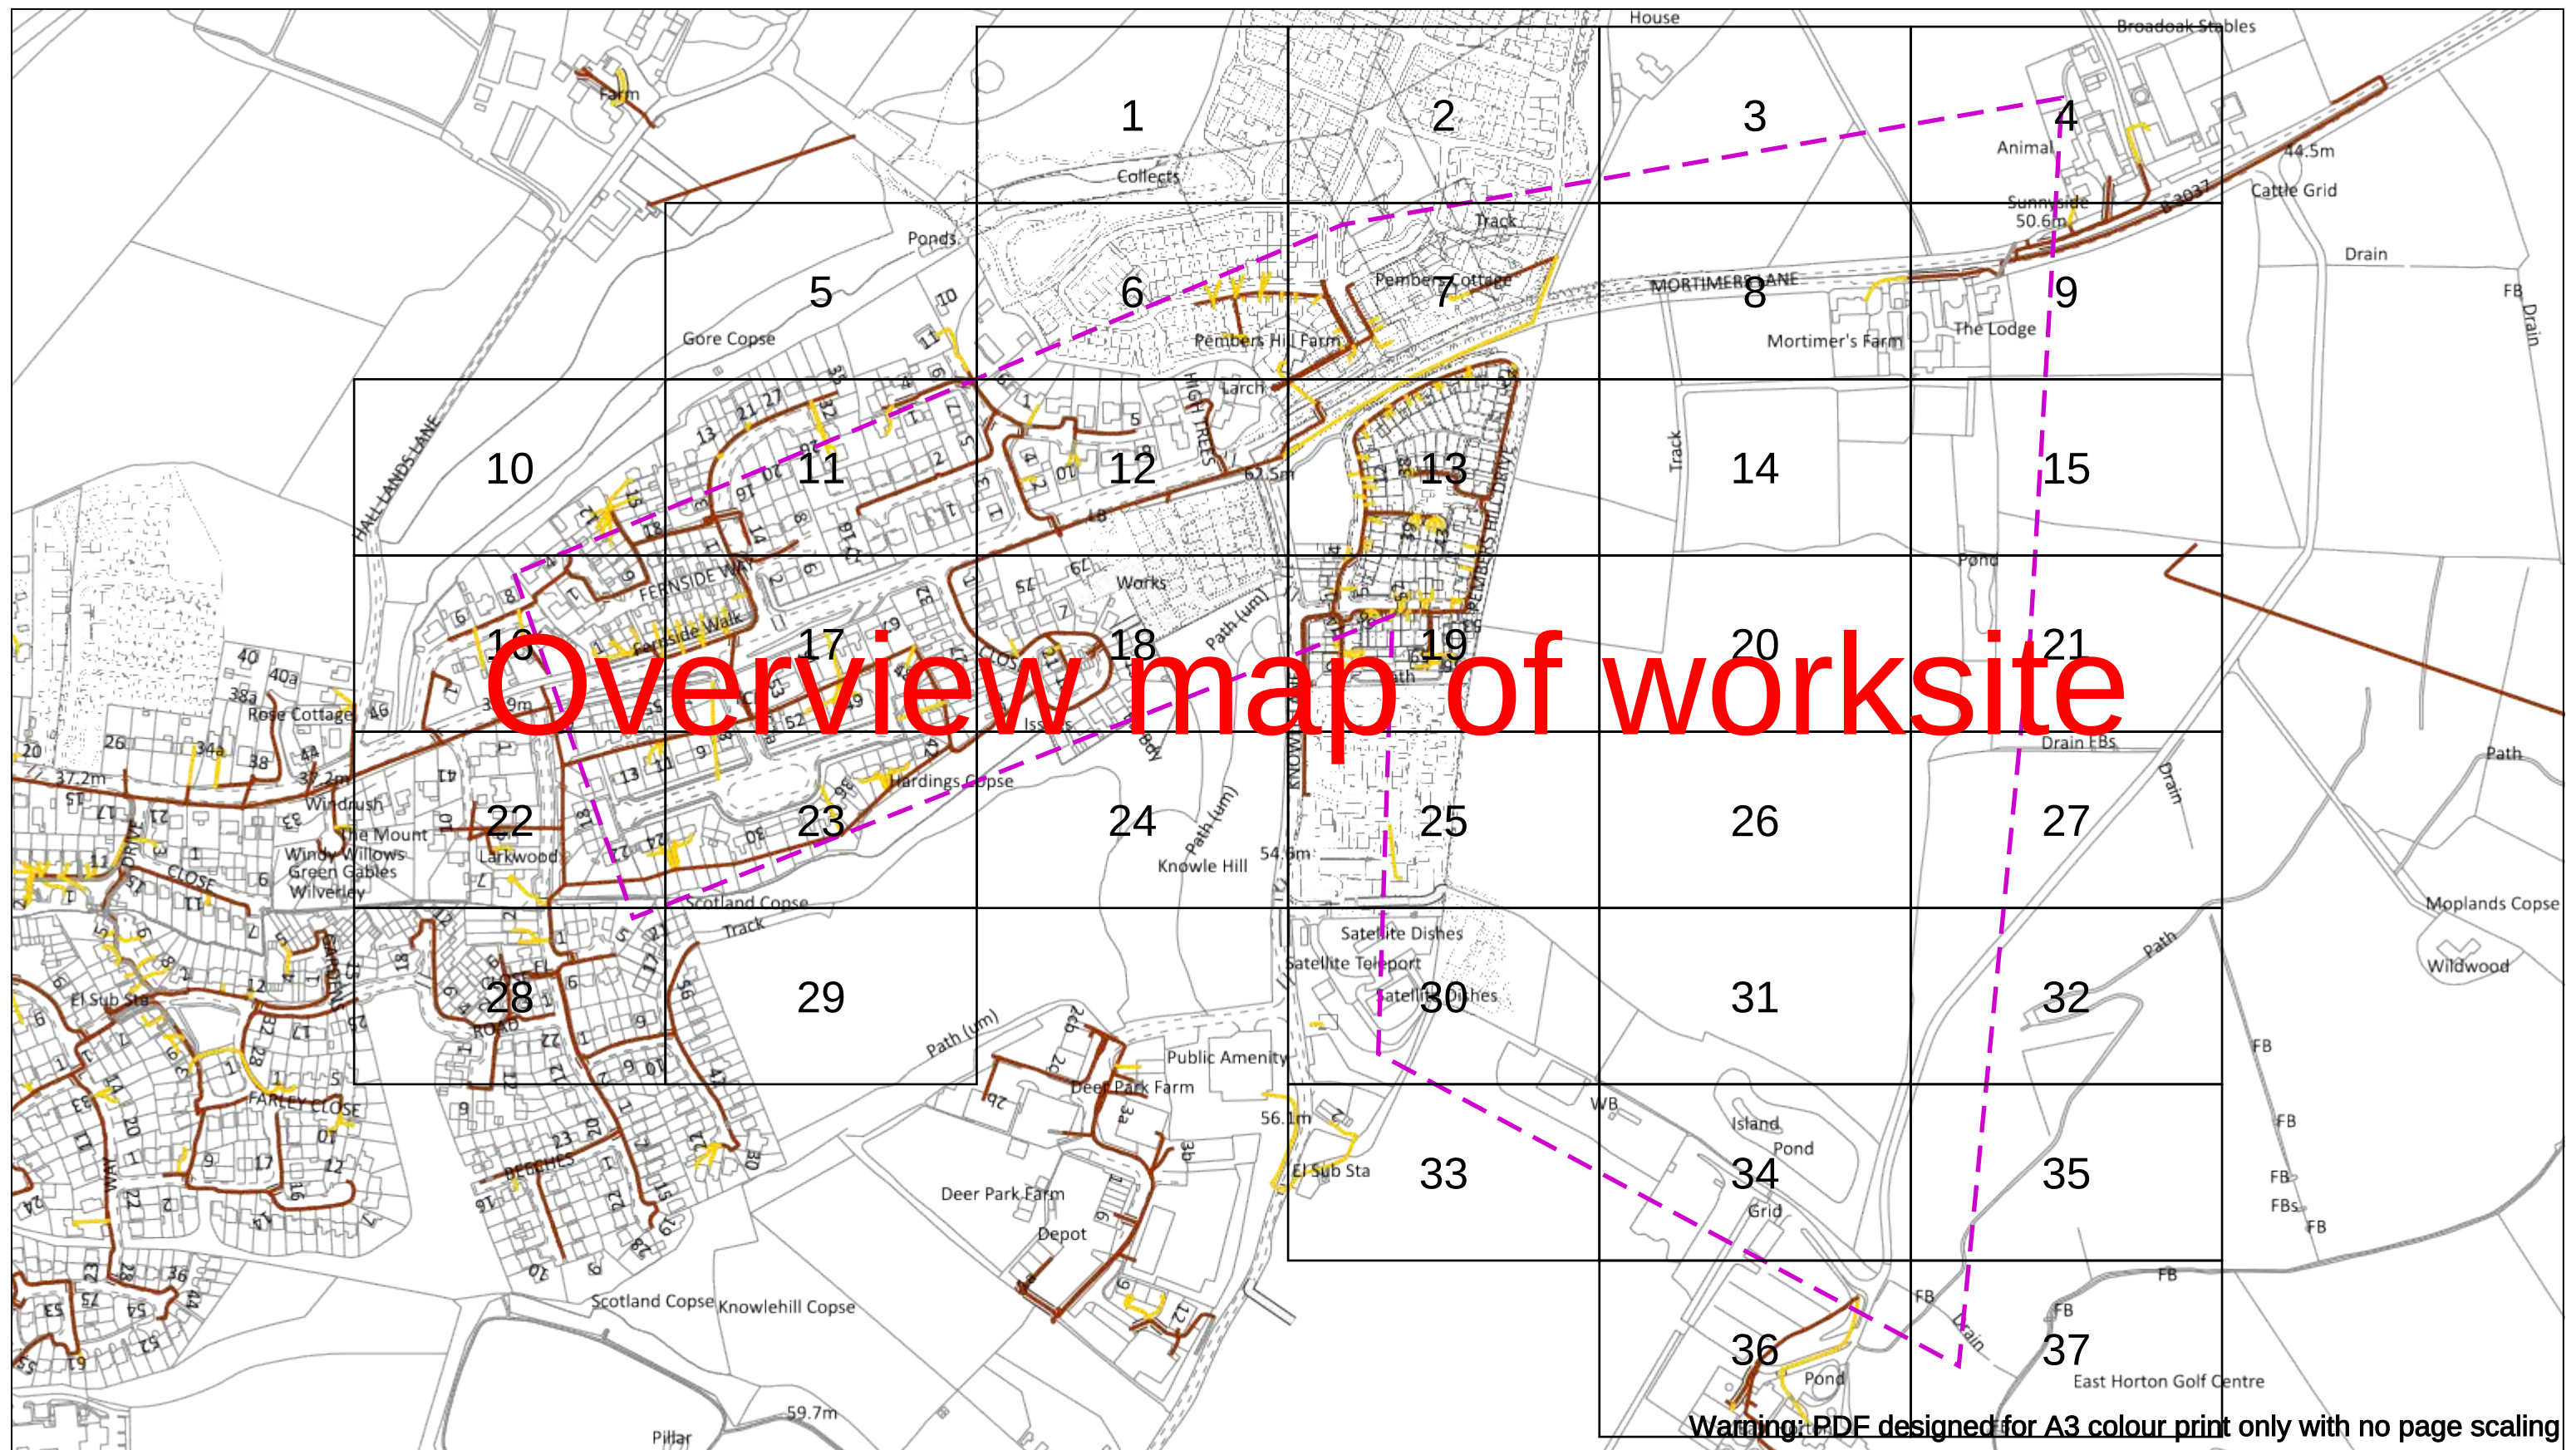

Dig Sites Area: Line:



Date Requested: 23/11/2023
Job Reference: 31641913
Site Location: 450687 118647
Requested by:
Ms Debbie Wigston
Your Scheme/Reference:
8230679

WARNING

There may have been subsequent alteration to the surface levels. Trial holes must be undertaken to determine position and depths of cables. HS (G) 47 Booklet from the Health and Safety Executive – Avoiding Danger from Buried Cables – should be consulted before commencing excavation work.

WHEN WORKING IN THE VICINITY OF OVERHEAD LINES THE HEALTH AND SAFETY GUIDANCE NOTES GS6 SHOULD BE CONSULTED (AVAILABLE FROM THE HSE WEBSITE)

Voltages (V)				
LV (Low Voltage) and Services		Up to 1,000V		
HV (High Voltage)		Over 1,000V to 11,000V		
EHV (Extra High Voltage)		22,000V to 132,000V		
Transmission		275,000V and 400,000V		
NORMAL DEPTH TO THE TOP OF THE CABLE WHEN LAID				
	Services	LV	HV	EHV
Footpath/Unmade	0.45m	0.45m	0.6m	0.9m
Road Crossing	0.6m	0.6m	0.75m	0.9m
Agricultural	1m	1m	1m	1.2m

Legend

- Service Cable
- LV Mains
- 2 – 3.3kV
- 6.6kV
- 11kV
- 22kV
- 33kV
- 66kV
- 132kV
- 275kV
- 400kV
- Fibre Optic
- Pilot Cable

Distribution Structures (Electric)

- Pole, Existing Location
- Pole Structure, Existing Location - Single
- Pole Structure, Existing Location - H
- Duct Route
- Cross Section Route

Southern Electric Power Distribution plc
Registered Office: No.1 Forbury Place
43 Forbury Road Reading RG1 3JH
Registered In England & Wales No.04094290



If you're unsure & need to seek advice before commencing excavations please contact:
General Enquiries: 0800 048 3516


Subject to revision – Master held by SSEN Asset Data Team:
Asset.Data@sse.com
 01256 337 294

Scale: 1:4100 (When plotted at A3)

BASED UPON THE ORDNANCE SURVEY MAP WITH THE SANCTION OF THE CONTROLLER OF H.M STATIONERY OFFICE CROWN COPYRIGHT RESERVED.

This copy has been made by or with the authority of Scottish and Southern Energy Power Distribution Ltd. Pursuant to section 47 of the Copyright, Designs and Patents Act 1988 ('The Act'). Unless the Act provides a relevant exception to copyright the copy must not be copied without prior permission of the copyright owner. Plans generated by DigSAFE Pro™ software provided by LinesearchbeforeUdig.

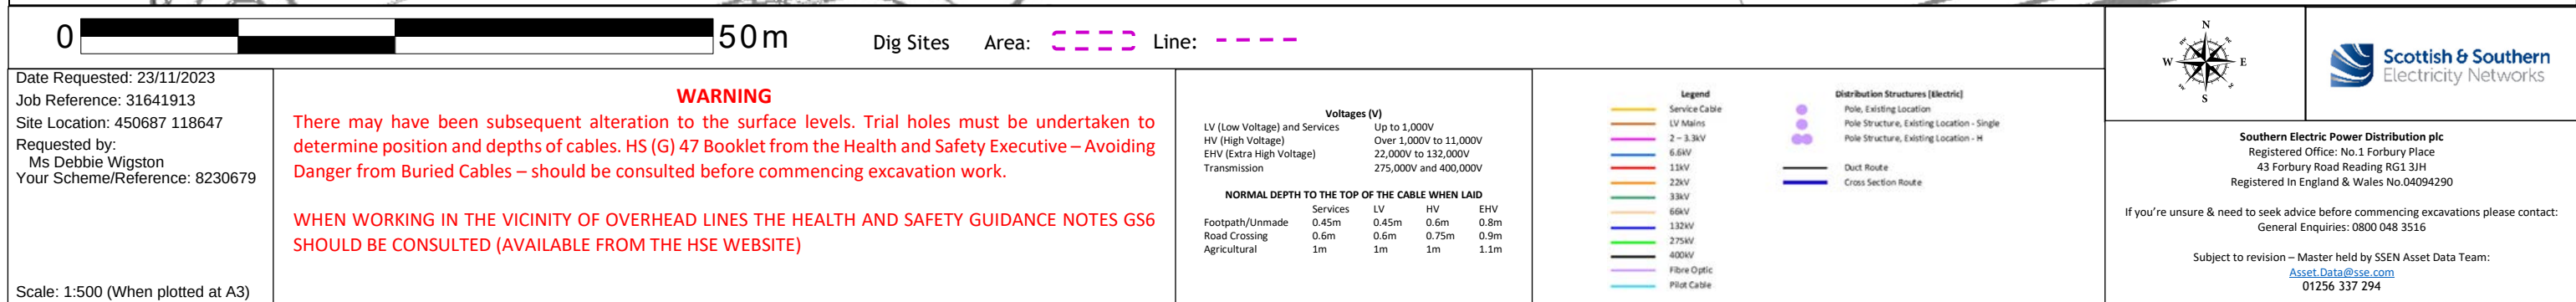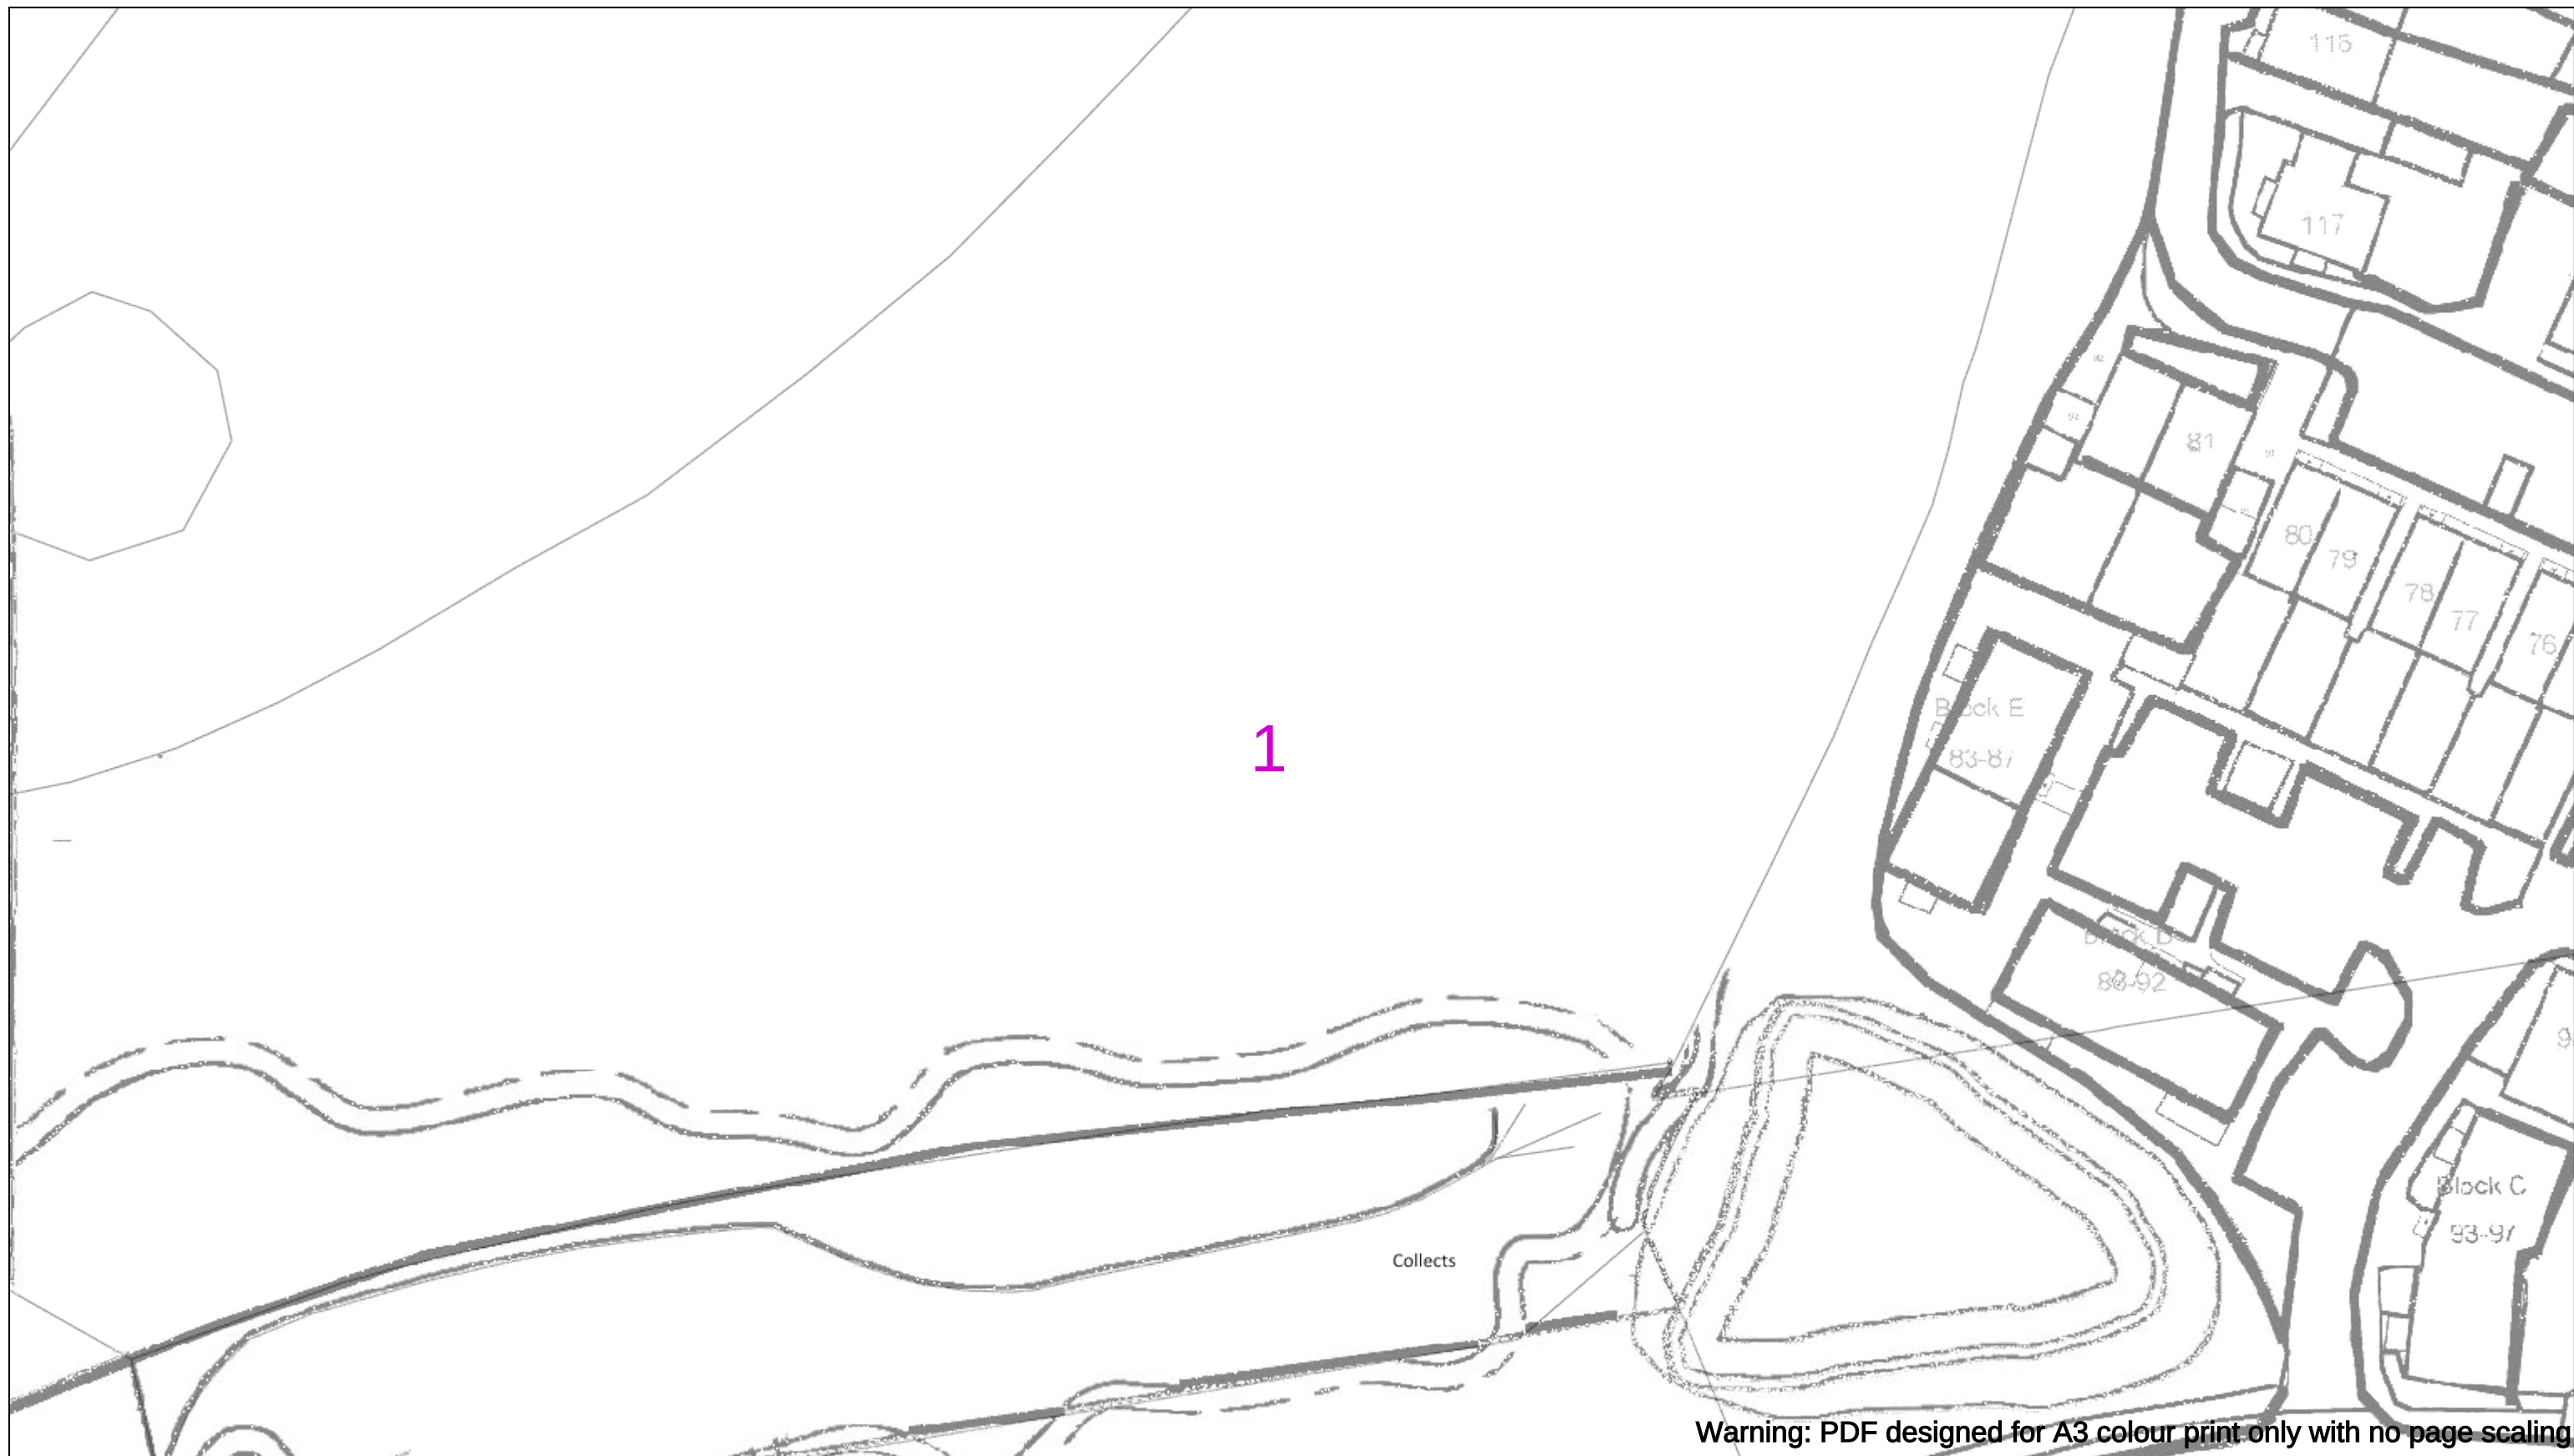

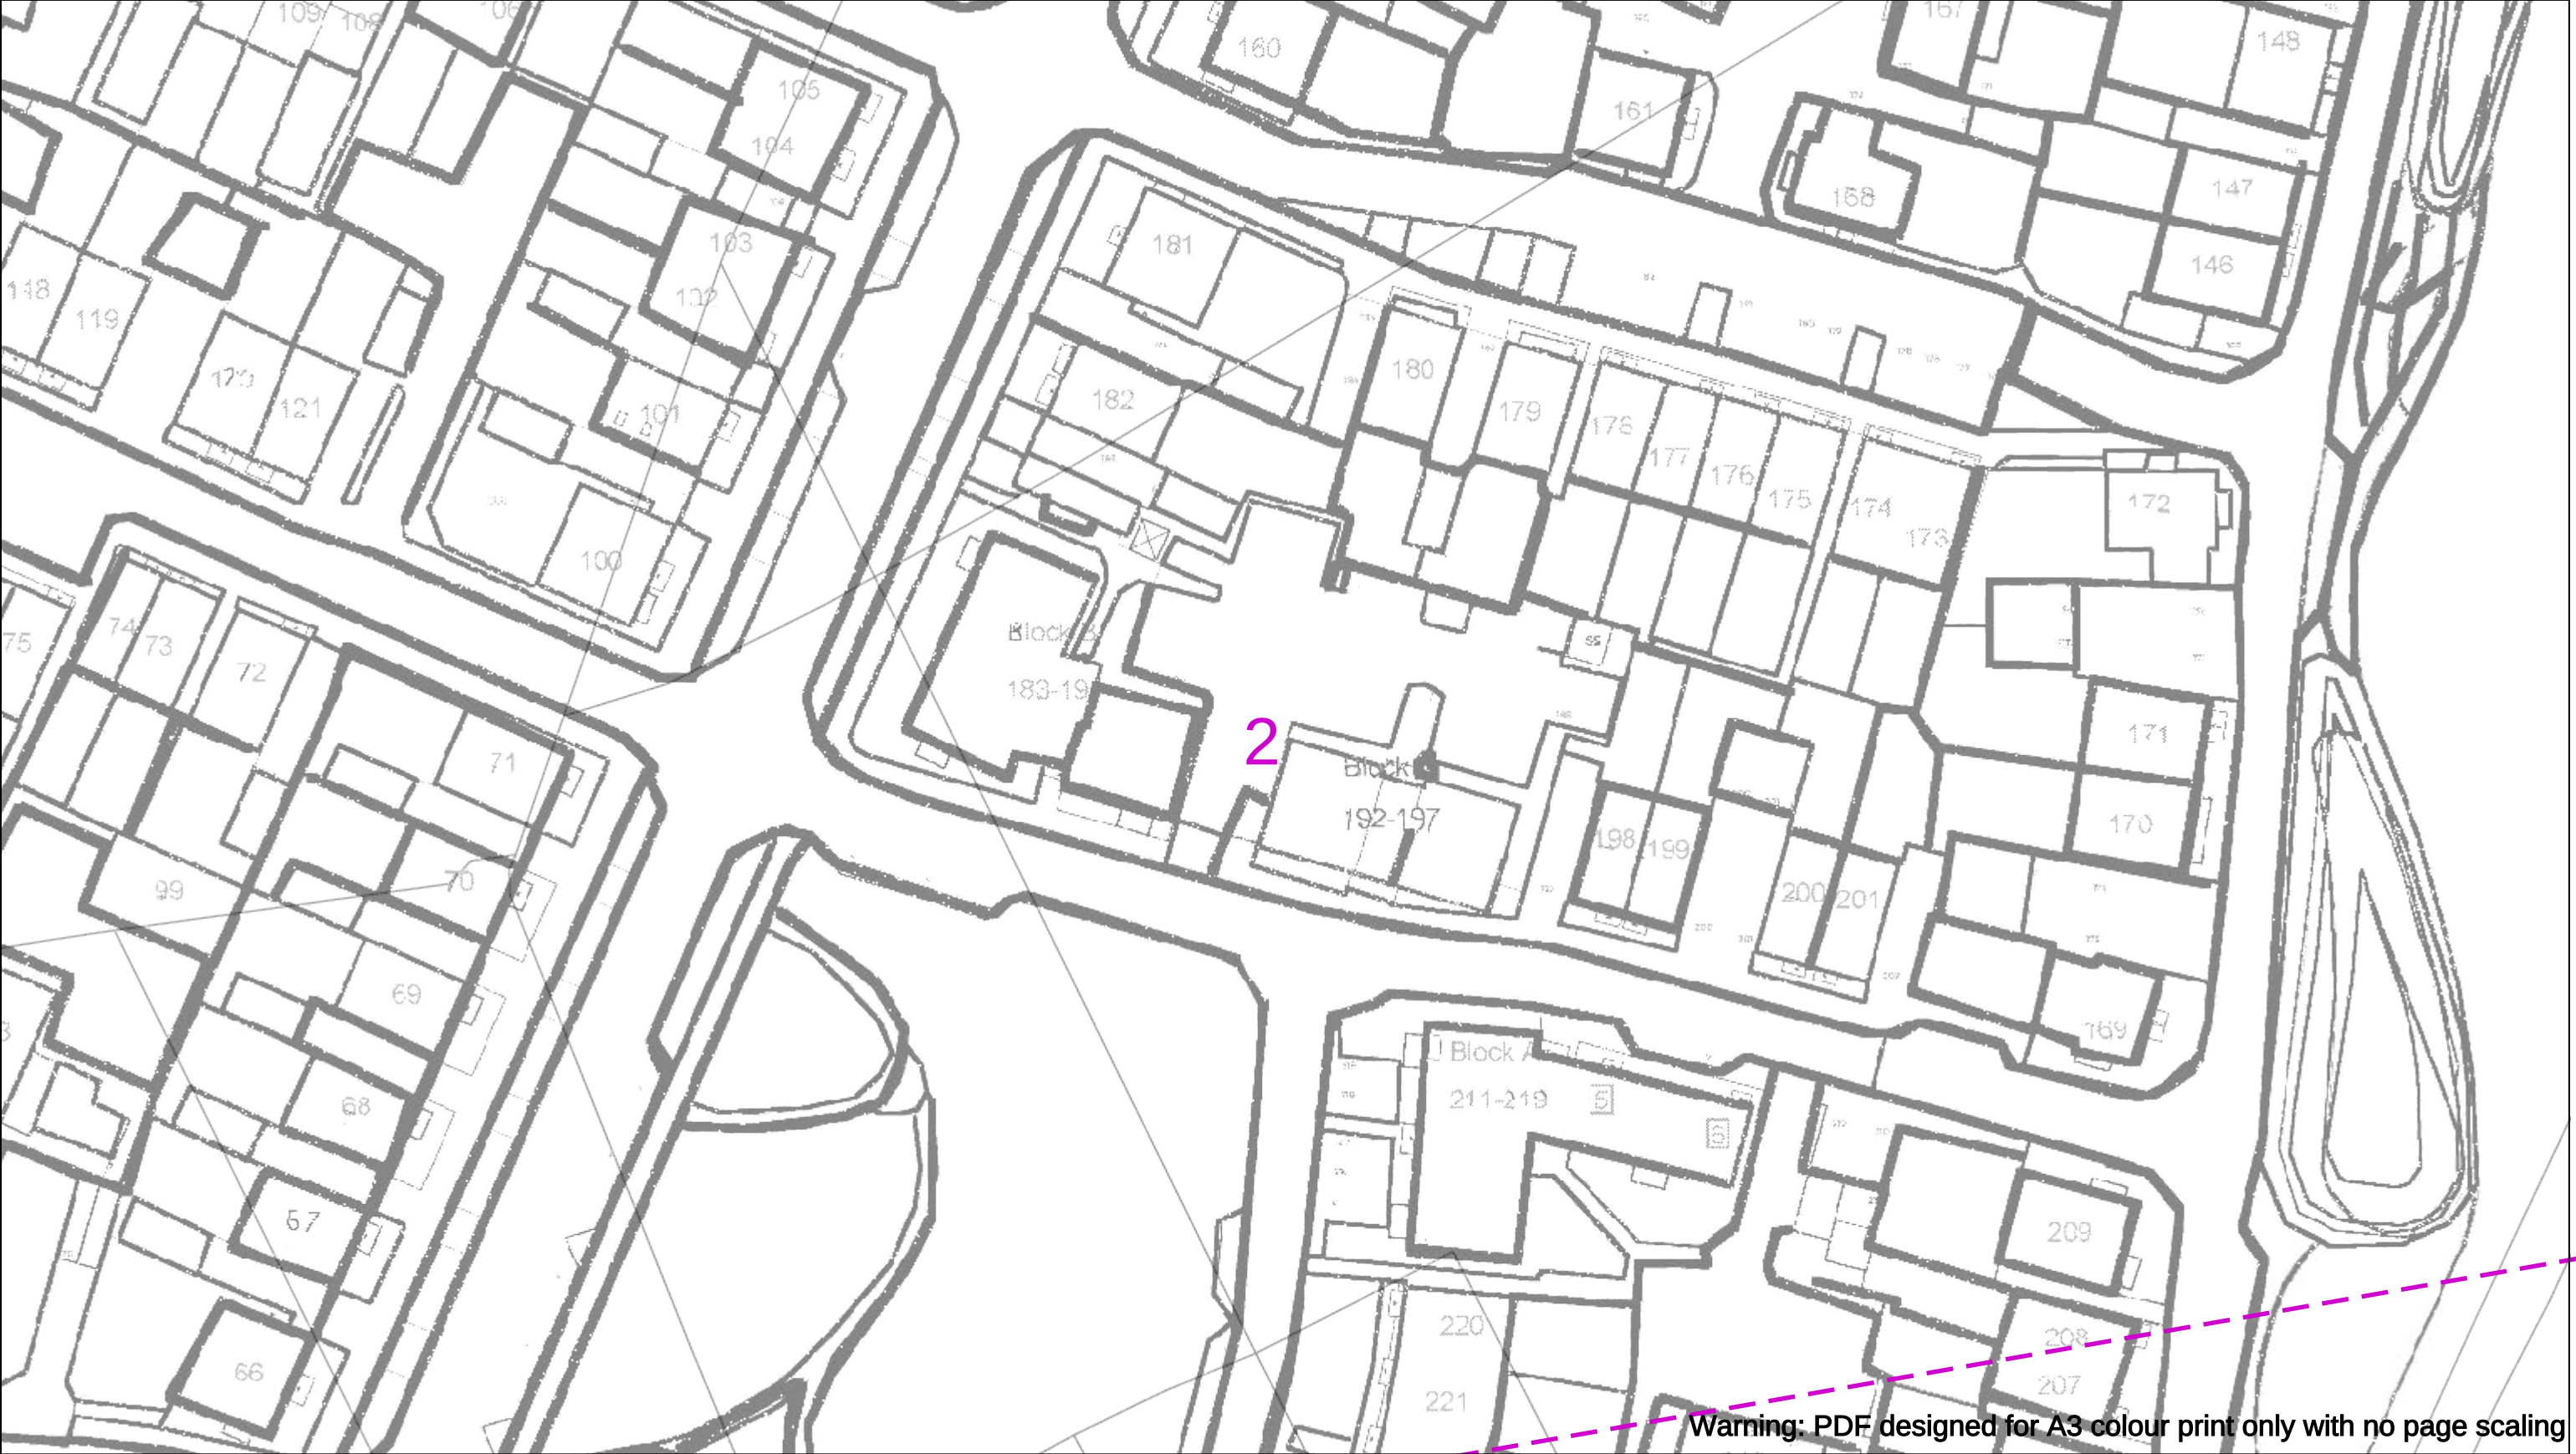

Warning: PDF designed for A3 colour print only with no page scaling

050m

Dig Sites

Area: 

Line: 

Date Requested: 23/11/2023

Job Reference: 31641913

Site Location: 450687 118647

Requested by: Ms Debbie Wigston

Your Scheme/Reference: 8230679

WARNING

There may have been subsequent alteration to the surface levels. Trial holes must be undertaken to determine position and depths of cables. HS (G) 47 Booklet from the Health and Safety Executive – Avoiding Danger from Buried Cables – should be consulted before commencing excavation work.

WHEN WORKING IN THE VICINITY OF OVERHEAD LINES THE HEALTH AND SAFETY GUIDANCE NOTES GS6 SHOULD BE CONSULTED (AVAILABLE FROM THE HSE WEBSITE)

Voltages (V)				
LV (Low Voltage) and Services	Up to 1,000V			
HV (High Voltage)	Over 1,000V to 11,000V			
EHV (Extra High Voltage)	22,000V to 132,000V			
Transmission	275,000V and 400,000V			

NORMAL DEPTH TO THE TOP OF THE CABLE WHEN LAID				
	Services	LV	HV	EHV
Footpath/Unmade	0.45m	0.45m	0.6m	0.8m
Road Crossing	0.6m	0.6m	0.75m	0.9m
Agricultural	1m	1m	1m	1.1m

Legend

 Service Cable

 LV Mains

 2 – 3.3kV

 6.6kV

 11kV

 22kV

 33kV

 66kV

 132kV

 275kV

 400kV

 Fibre Optic

 Pilot Cable

Distribution Structures (Electric)

 Pole, Existing Location

 Pole Structure, Existing Location - Single

 Pole Structure, Existing Location - H

 Duct Route

 Cross Section Route



Scottish & Southern

Electricity Networks

Southern Electric Power Distribution plc

Registered Office: No.1 Forbury Place

43 Forbury Road Reading RG1 3JH

Registered In England & Wales No.04094290

If you're unsure & need to seek advice before commencing excavations please contact:

General Enquiries: 0800 048 3516

Subject to revision – Master held by SSEN Asset Data Team:


Asset.Data@sse.com

01256 337 294

Scale: 1:500 (When plotted at A3)

BASED UPON THE ORDNANCE SURVEY MAP WITH THE SANCTION OF THE CONTROLLER OF H.M STATIONERY OFFICE CROWN COPYRIGHT RESERVED.

This copy has been made by or with the authority of Scottish and Southern Energy Power Distribution Ltd. Pursuant to section 47 of the Copyright, Designs and Patents Act 1988 ('The Act'). Unless the Act provides a relevant exception to copyright the copy must not be copied without prior permission of the copyright owner. Plans generated by DigSAFE Pro™ software provided by LinesearchbeforeUdig.

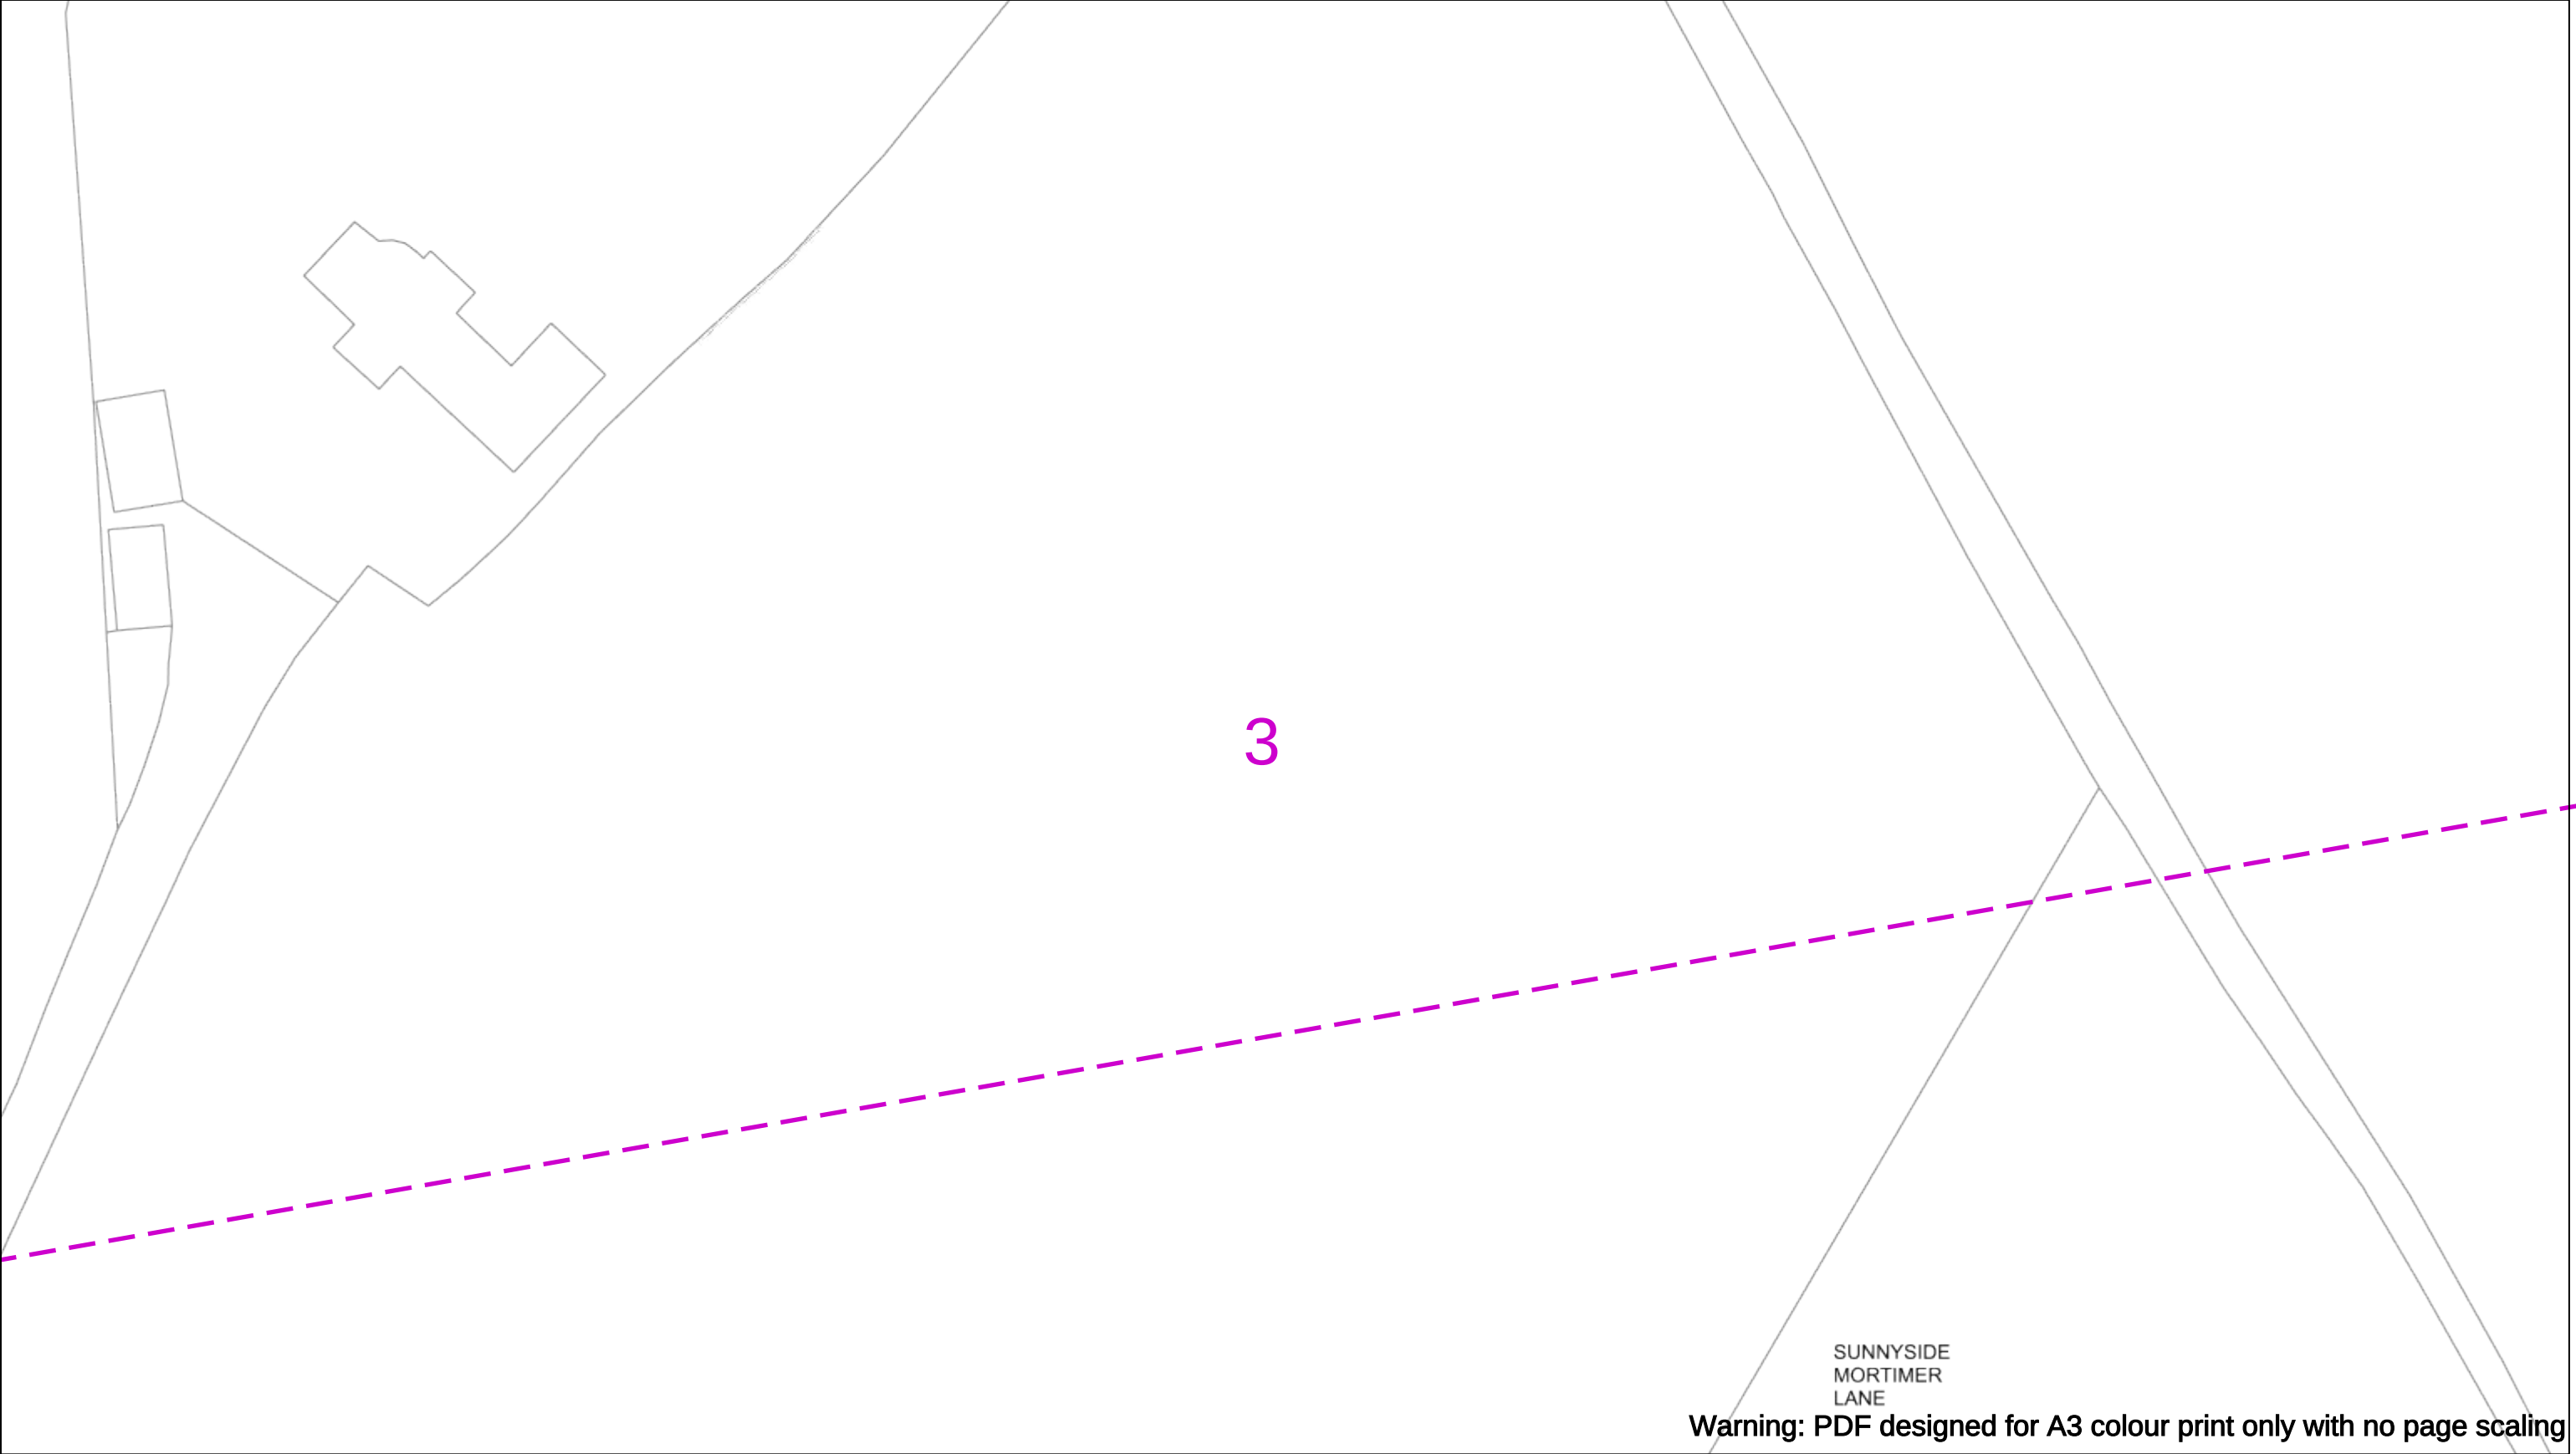

Warning: PDF designed for A3 colour print only with no page scaling

050m

Dig Sites

Area:

Line:

Date Requested: 23/11/2023

Job Reference: 31641913

Site Location: 450687 118647

Requested by:
Ms Debbie Wigston

Your Scheme/Reference: 8230679

WARNING

There may have been subsequent alteration to the surface levels. Trial holes must be undertaken to determine position and depths of cables. HS (G) 47 Booklet from the Health and Safety Executive – Avoiding Danger from Buried Cables – should be consulted before commencing excavation work.

WHEN WORKING IN THE VICINITY OF OVERHEAD LINES THE HEALTH AND SAFETY GUIDANCE NOTES GS6 SHOULD BE CONSULTED (AVAILABLE FROM THE HSE WEBSITE)

Voltages (V)				
LV (Low Voltage) and Services	Up to 1,000V			
HV (High Voltage)	Over 1,000V to 11,000V			
EHV (Extra High Voltage)	22,000V to 132,000V			
Transmission	275,000V and 400,000V			

NORMAL DEPTH TO THE TOP OF THE CABLE WHEN LAID				
	Services	LV	HV	EHV
Footpath/Unmade	0.45m	0.45m	0.6m	0.8m
Road Crossing	0.6m	0.6m	0.75m	0.9m
Agricultural	1m	1m	1m	1.1m

Legend

Service Cable

LV Mains

2 – 3.3kV

6.6kV

11kV

22kV

33kV

66kV

132kV

275kV

400kV

Fibre Optic

Pilot Cable

Distribution Structures (Electric)

Pole, Existing Location

Pole Structure, Existing Location - Single

Pole Structure, Existing Location - H

Duct Route

Cross Section Route

N

E

S

W

Scottish & Southern
Electricity Networks

Southern Electric Power Distribution plc


Registered Office: No.1 Forbury Place
43 Forbury Road Reading RG1 3JH
Registered In England & Wales No.04094290

If you're unsure & need to seek advice before commencing excavations please contact:
General Enquiries: 0800 048 3516

Subject to revision – Master held by SSEN Asset Data Team:
Asset.Data@sse.com
01256 337 294

BASED UPON THE ORDNANCE SURVEY MAP WITH THE SANCTION OF THE CONTROLLER OF H.M STATIONERY OFFICE CROWN COPYRIGHT RESERVED.

This copy has been made by or with the authority of Scottish and Southern Energy Power Distribution Ltd. Pursuant to section 47 of the Copyright, Designs and Patents Act 1988 ('The Act'). Unless the Act provides a relevant exception to copyright the copy must not be copied without prior permission of the copyright owner. Plans generated by DigSAFE Pro™ software provided by LinesearchbeforeUdig.

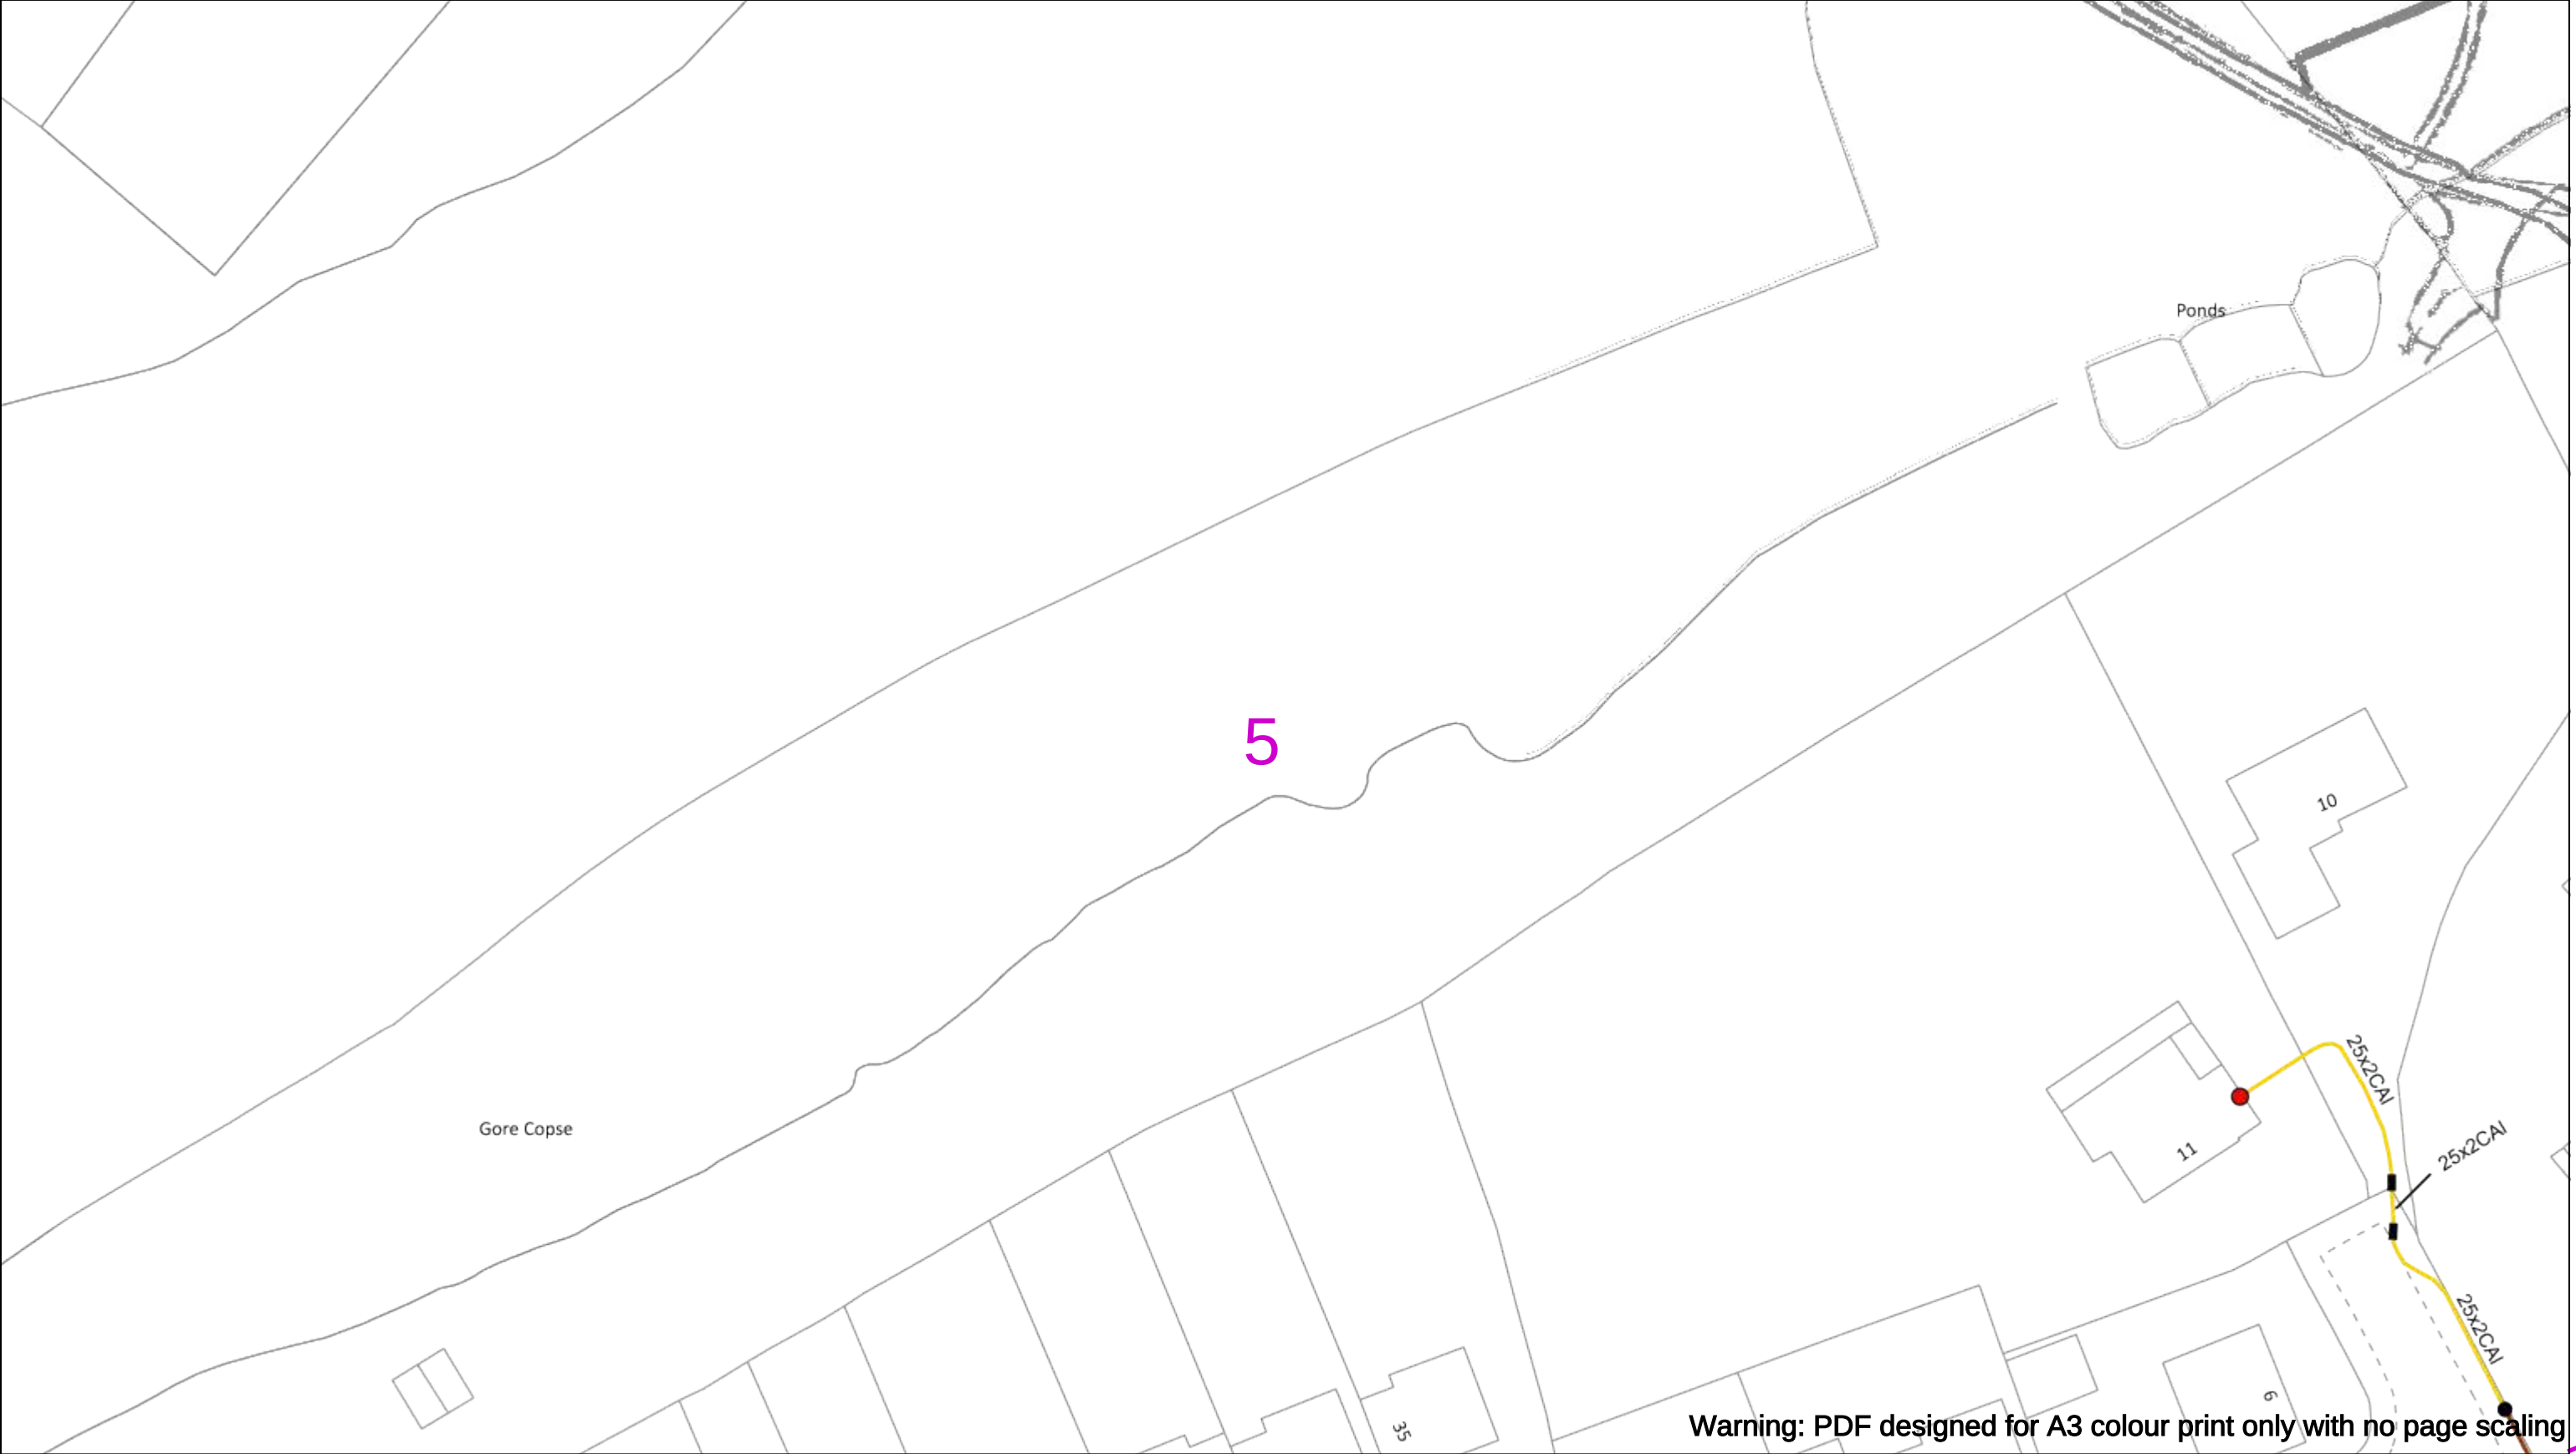

Warning: PDF designed for A3 colour print only with no page scaling

050m

Dig Sites

Area:

Line:

Date Requested: 23/11/2023

Job Reference: 31641913

Site Location: 450687 118647

Requested by:
Ms Debbie Wigston

Your Scheme/Reference: 8230679

WARNING

There may have been subsequent alteration to the surface levels. Trial holes must be undertaken to determine position and depths of cables. HS (G) 47 Booklet from the Health and Safety Executive – Avoiding Danger from Buried Cables – should be consulted before commencing excavation work.

WHEN WORKING IN THE VICINITY OF OVERHEAD LINES THE HEALTH AND SAFETY GUIDANCE NOTES GS6 SHOULD BE CONSULTED (AVAILABLE FROM THE HSE WEBSITE)

Voltages (V)

LV (Low Voltage) and ServicesUp to 1,000V

HV (High Voltage)Over 1,000V to 11,000V

EHV (Extra High Voltage)22,000V to 132,000V

Transmission275,000V and 400,000V

NORMAL DEPTH TO THE TOP OF THE CABLE WHEN LAID

	Services	LV	HV	EHV
Footpath/Unmade	0.45m	0.45m	0.6m	0.8m
Road Crossing	0.6m	0.6m	0.75m	0.9m
Agricultural	1m	1m	1m	1.1m

Legend

Service Cable

LV Mains

2 – 3.3kV

6.6kV

11kV

22kV

33kV

66kV

132kV

275kV

400kV

Fibre Optic

Pilot Cable

Distribution Structures (Electric)

Pole, Existing Location

Pole Structure, Existing Location - Single

Pole Structure, Existing Location - H

Duct Route

Cross Section Route

Southern Electric Power Distribution plc

Registered Office: No.1 Forbury Place

43 Forbury Road Reading RG1 3JH

Registered In England & Wales No.04094290

If you're unsure & need to seek advice before commencing excavations please contact:

General Enquiries: 0800 048 3516

Subject to revision – Master held by SSEN Asset Data Team:


Asset.Data@sse.com

01256 337 294

Scale: 1:500 (When plotted at A3)

BASED UPON THE ORDNANCE SURVEY MAP WITH THE SANCTION OF THE CONTROLLER OF THE STATIONERY OFFICE CROWN COPYRIGHT RESERVED.

This copy has been made by or with the authority of Scottish and Southern Energy Power Distribution Ltd. Pursuant to section 47 of the Copyright, Designs and Patents Act 1988 ('The Act'). Unless the Act provides a relevant exception to copyright the copy must not be copied without prior permission of the copyright owner. Plans generated by DigSAFE Pro™ software provided by LinesearchbeforeUdig.

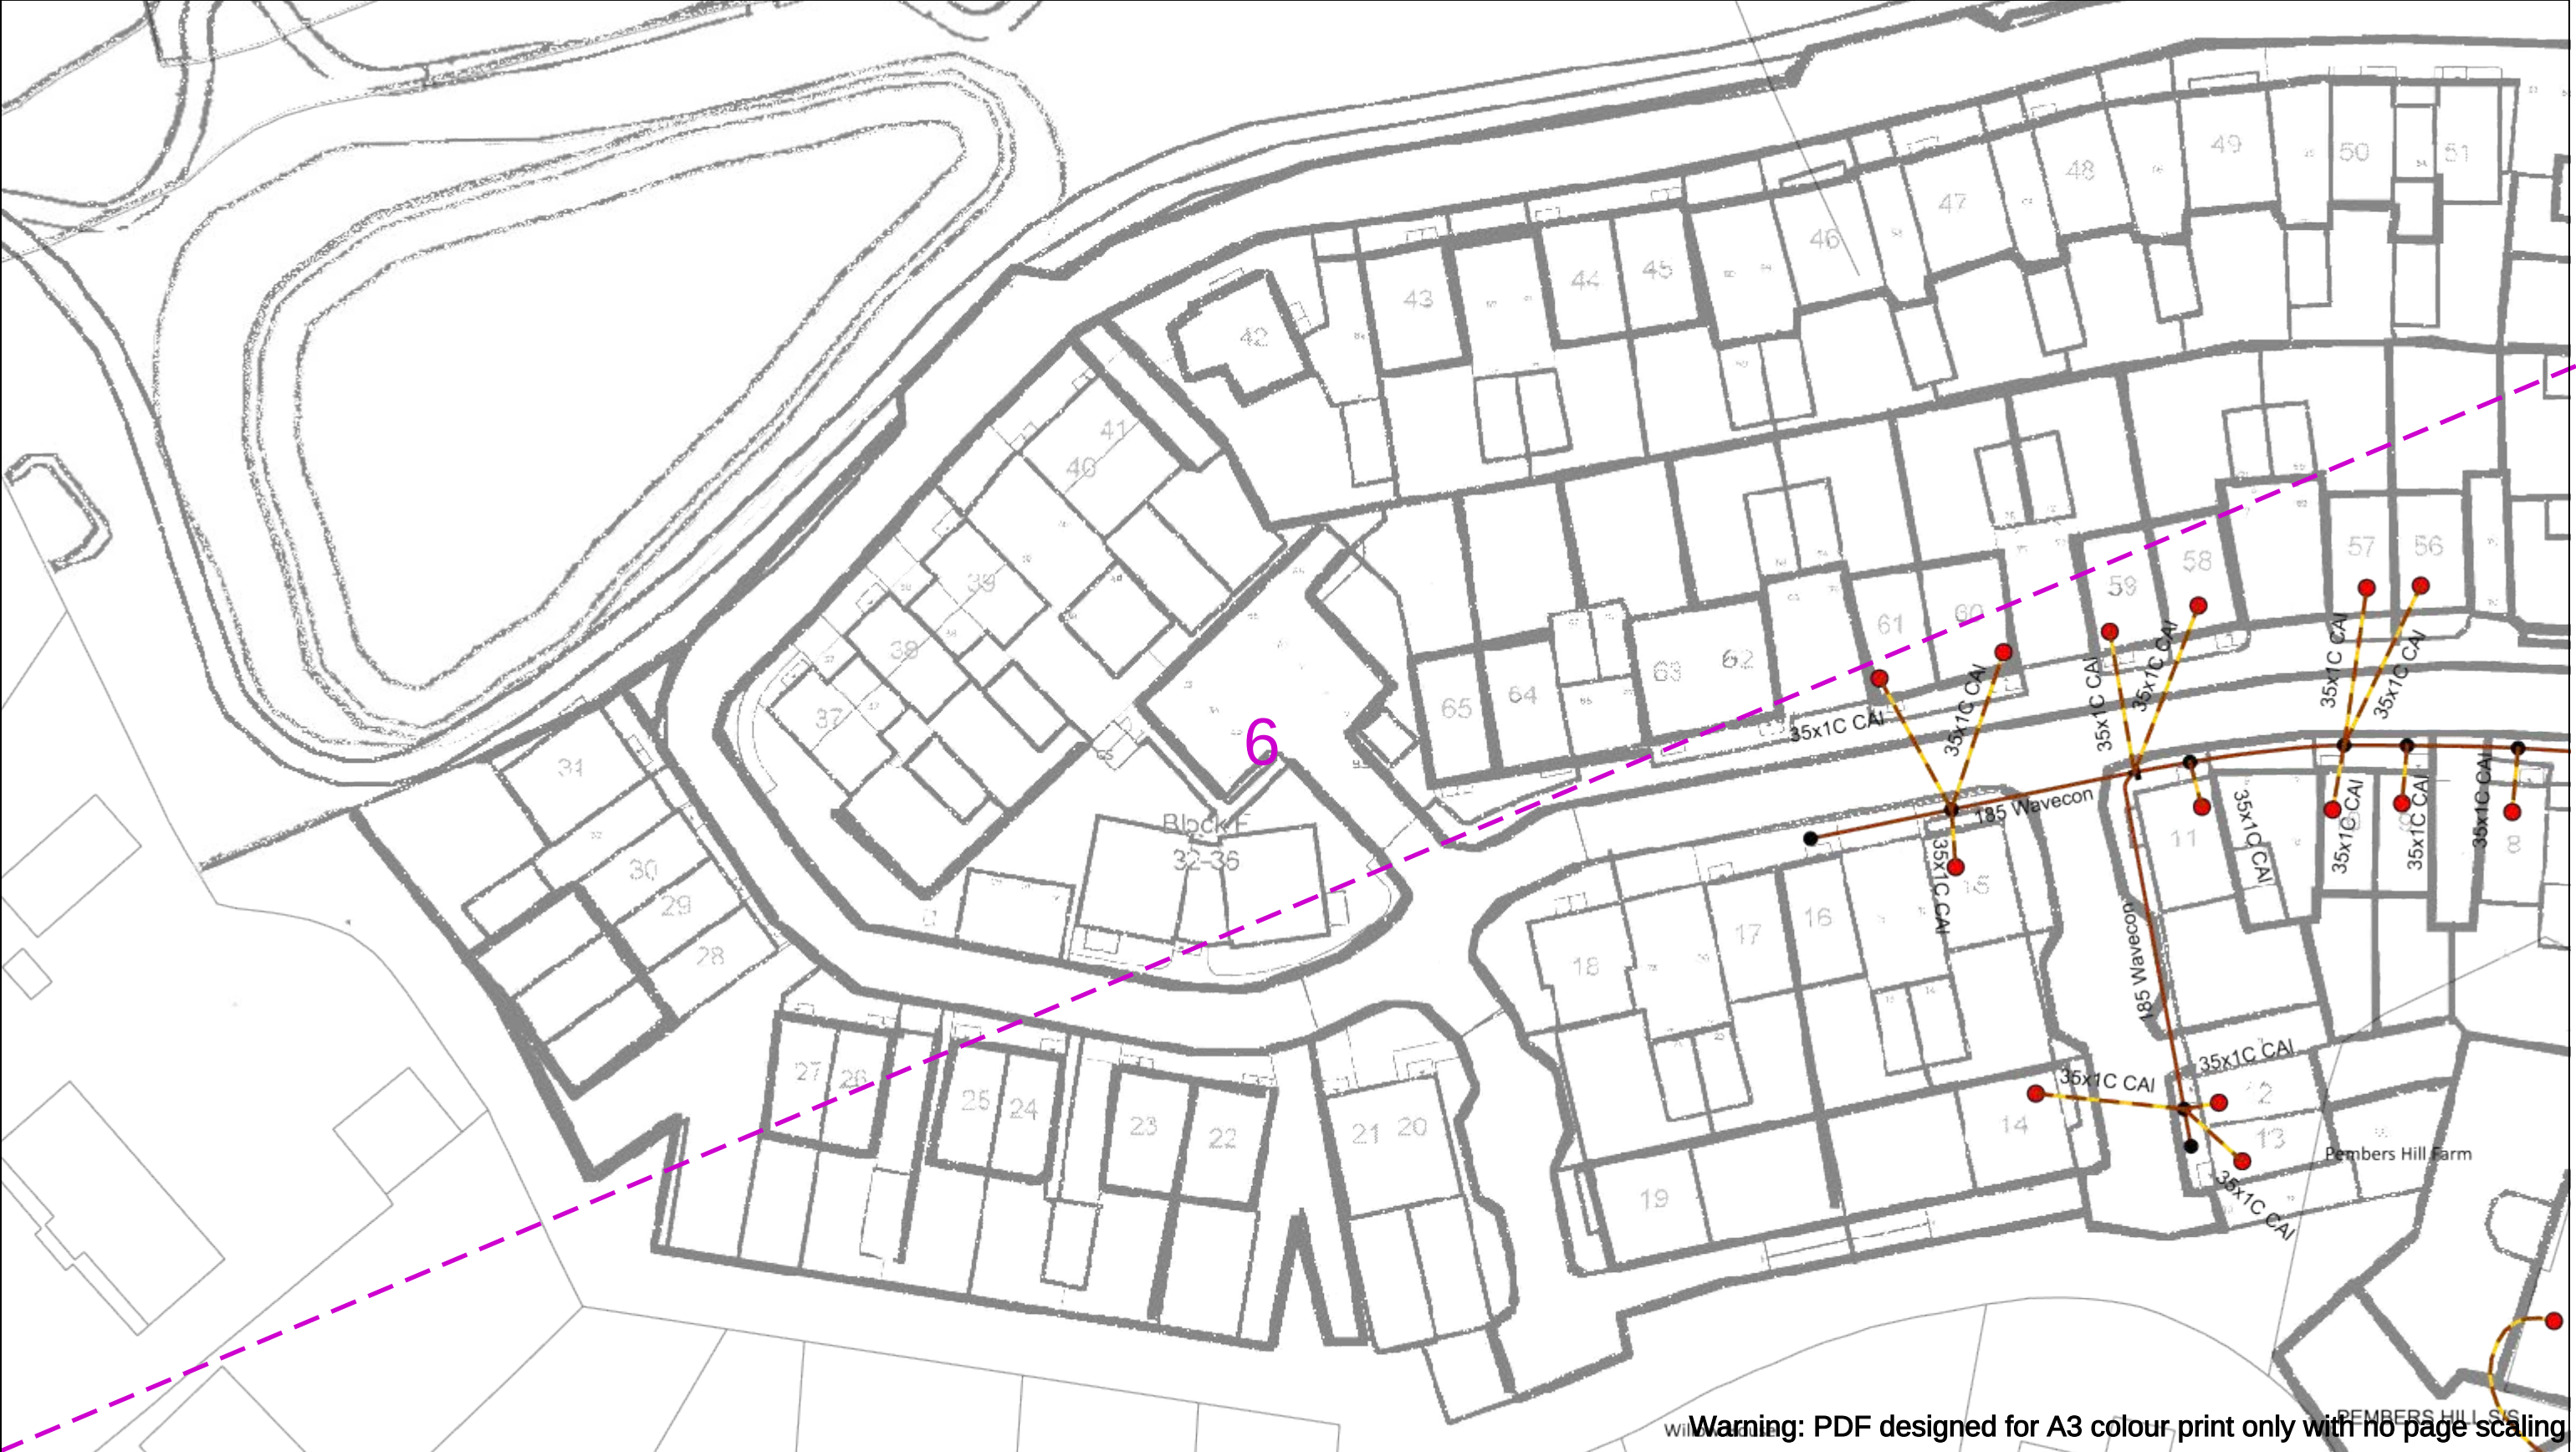

050m

Dig Sites

Area:

Line:

Date Requested: 23/11/2023

Job Reference: 31641913

Site Location: 450687 118647

Requested by:
Ms Debbie Wigston

Your Scheme/Reference: 8230679

WARNING

There may have been subsequent alteration to the surface levels. Trial holes must be undertaken to determine position and depths of cables. HS (G) 47 Booklet from the Health and Safety Executive – Avoiding Danger from Buried Cables – should be consulted before commencing excavation work.

WHEN WORKING IN THE VICINITY OF OVERHEAD LINES THE HEALTH AND SAFETY GUIDANCE NOTES GS6 SHOULD BE CONSULTED (AVAILABLE FROM THE HSE WEBSITE)

Scale: 1:500 (When plotted at A3)

Volts (V)

LV (Low Voltage) and Services Up to 1,000V

HV (High Voltage) Over 1,000V to 11,000V

EHV (Extra High Voltage) 22,000V to 132,000V

Transmission 275,000V and 400,000V

NORMAL DEPTH TO THE TOP OF THE CABLE WHEN LAID

	Services	LV	HV	EHV
Footpath/Unmade	0.45m	0.45m	0.6m	0.8m
Road Crossing	0.6m	0.6m	0.75m	0.9m
Agricultural	1m	1m	1m	1.1m

Legend

Service Cable

LV Mains

2 – 3.3kV

6.6kV

11kV

22kV

33kV

66kV

132kV

275kV

400kV

Fibre Optic

Pilot Cable

Distribution Structures (Electric)

Pole, Existing Location

Pole Structure, Existing Location - Single

Pole Structure, Existing Location - H

Duct Route

Cross Section Route

Scottish & Southern
Electricity Networks

Southern Electric Power Distribution plc
Registered Office: No.1 Forbury Place
43 Forbury Road Reading RG1 3JH
Registered in England & Wales No.04094290

If you're unsure & need to seek advice before commencing excavations please contact:
General Enquiries: 0800 048 3516


Subject to revision – Master held by SSEN Asset Data Team:
Asset.Data@sse.com
01256 337 294

Warning: PDF designed for A3 colour print only with no page scaling

PEMBERS HILL

BASED UPON THE ORDNANCE SURVEY MAP WITH THE SANCTION OF H.M STATIONERY OFFICE CROWN COPYRIGHT RESERVED.

This copy has been made by or with the authority of Scottish and Southern Energy Power Distribution Ltd. Pursuant to section 47 of the Copyright, Designs and Patents Act 1988 ('The Act'). Unless the Act provides a relevant exception to copyright the copy must not be copied without prior permission of the copyright owner. Plans generated by DigSAFE Pro™ software provided by LinesearchbeforeUdig.

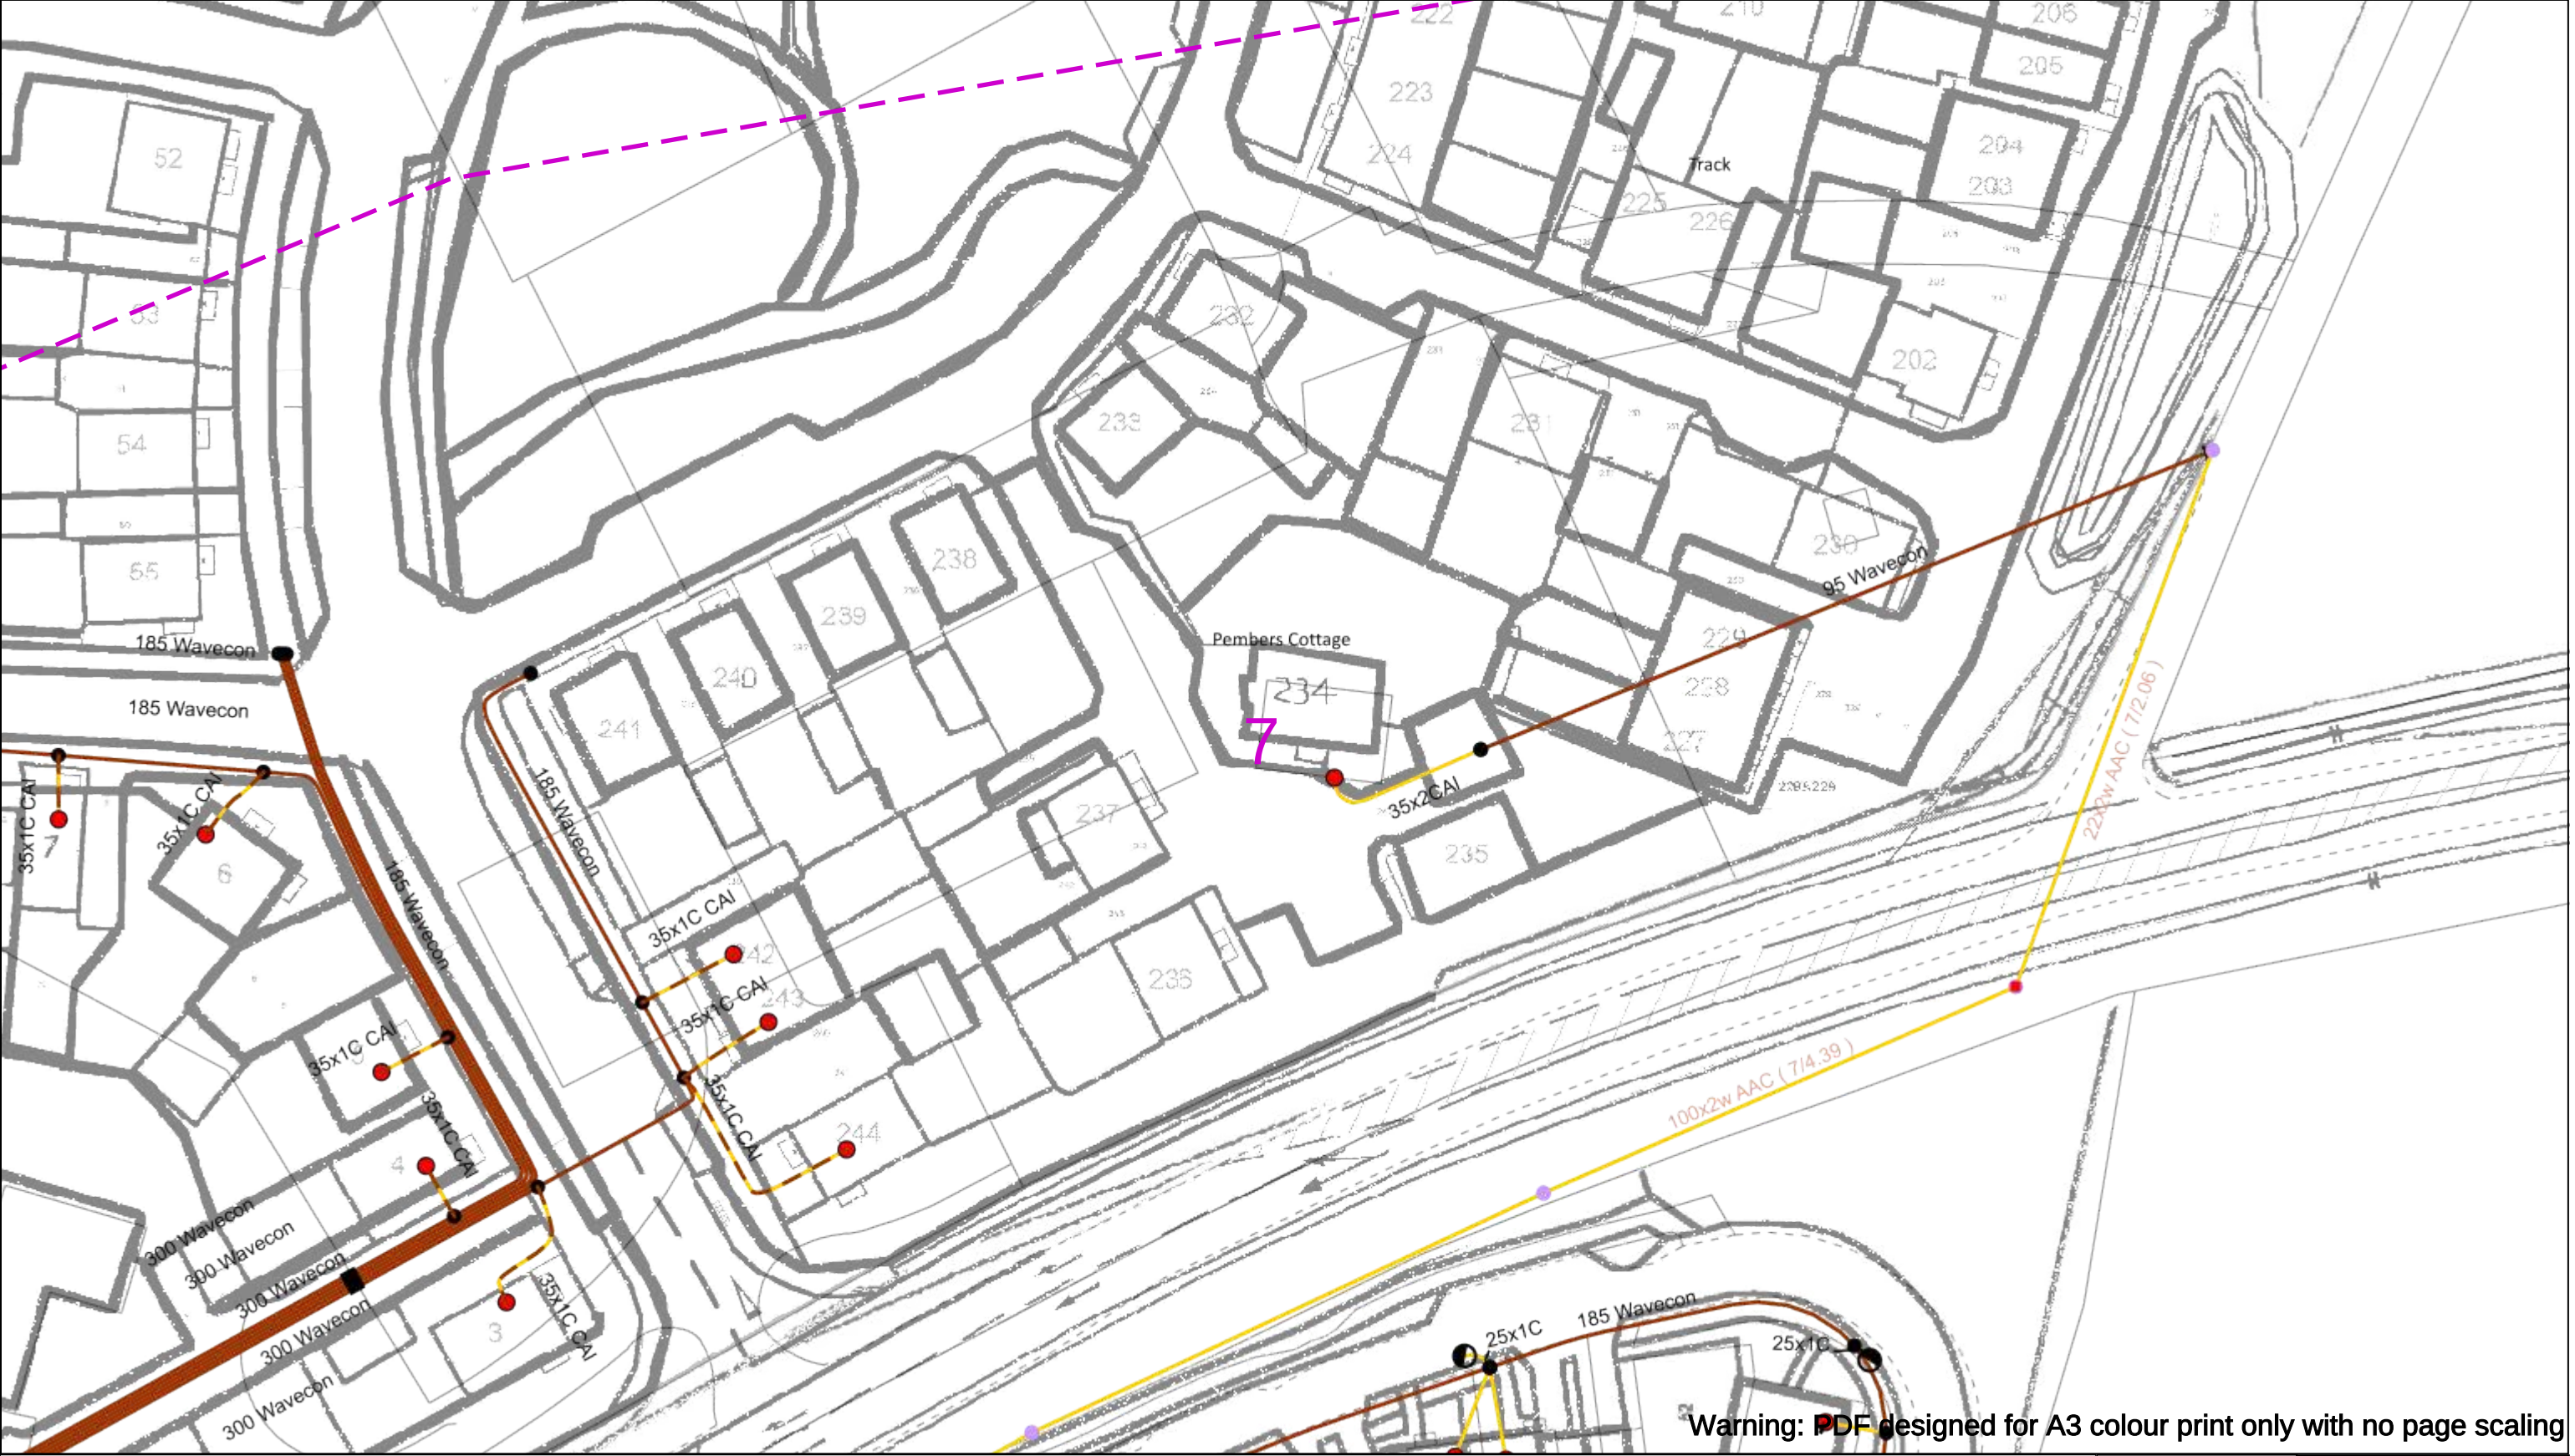

Warning: PDF designed for A3 colour print only with no page scaling

050m

Dig Sites

Area:

Line:

Date Requested: 23/11/2023

Job Reference: 31641913

Site Location: 450687 118647

Requested by: Ms Debbie Wigston

Your Scheme/Reference: 8230679

WARNING

There may have been subsequent alteration to the surface levels. Trial holes must be undertaken to determine position and depths of cables. HS (G) 47 Booklet from the Health and Safety Executive – Avoiding Danger from Buried Cables – should be consulted before commencing excavation work.

WHEN WORKING IN THE VICINITY OF OVERHEAD LINES THE HEALTH AND SAFETY GUIDANCE NOTES GS6 SHOULD BE CONSULTED (AVAILABLE FROM THE HSE WEBSITE)

	Voltages (V)			
LV (Low Voltage) and Services	Up to 1,000V			
HV (High Voltage)	Over 1,000V to 11,000V			
EHV (Extra High Voltage)	22,000V to 132,000V			
Transmission	275,000V and 400,000V			

	NORMAL DEPTH TO THE TOP OF THE CABLE WHEN LAID			
	Services	LV	HV	EHV
Footpath/Unmade	0.45m	0.45m	0.6m	0.8m
Road Crossing	0.6m	0.6m	0.75m	0.9m
Agricultural	1m	1m	1m	1.1m

Legend

Service Cable

LV Mains

2 – 3.3kV

6.6kV

11kV

22kV

33kV

Distribution Structures (Electric)

Pole, Existing Location

Pole Structure, Existing Location - Single

Southern Electric Power Distribution plc

Registered Office: No.1 Forbury Place

43 Forbury Road Reading RG1 3JH

Registered In England & Wales No.04094290


If you're unsure & need to seek advice before commencing excavations please contact:

General Enquiries: 0800 048 3516

Subject to revision – Master held by SSEN Asset Data Team:

Asset.Data@sse.com

01256 337 294

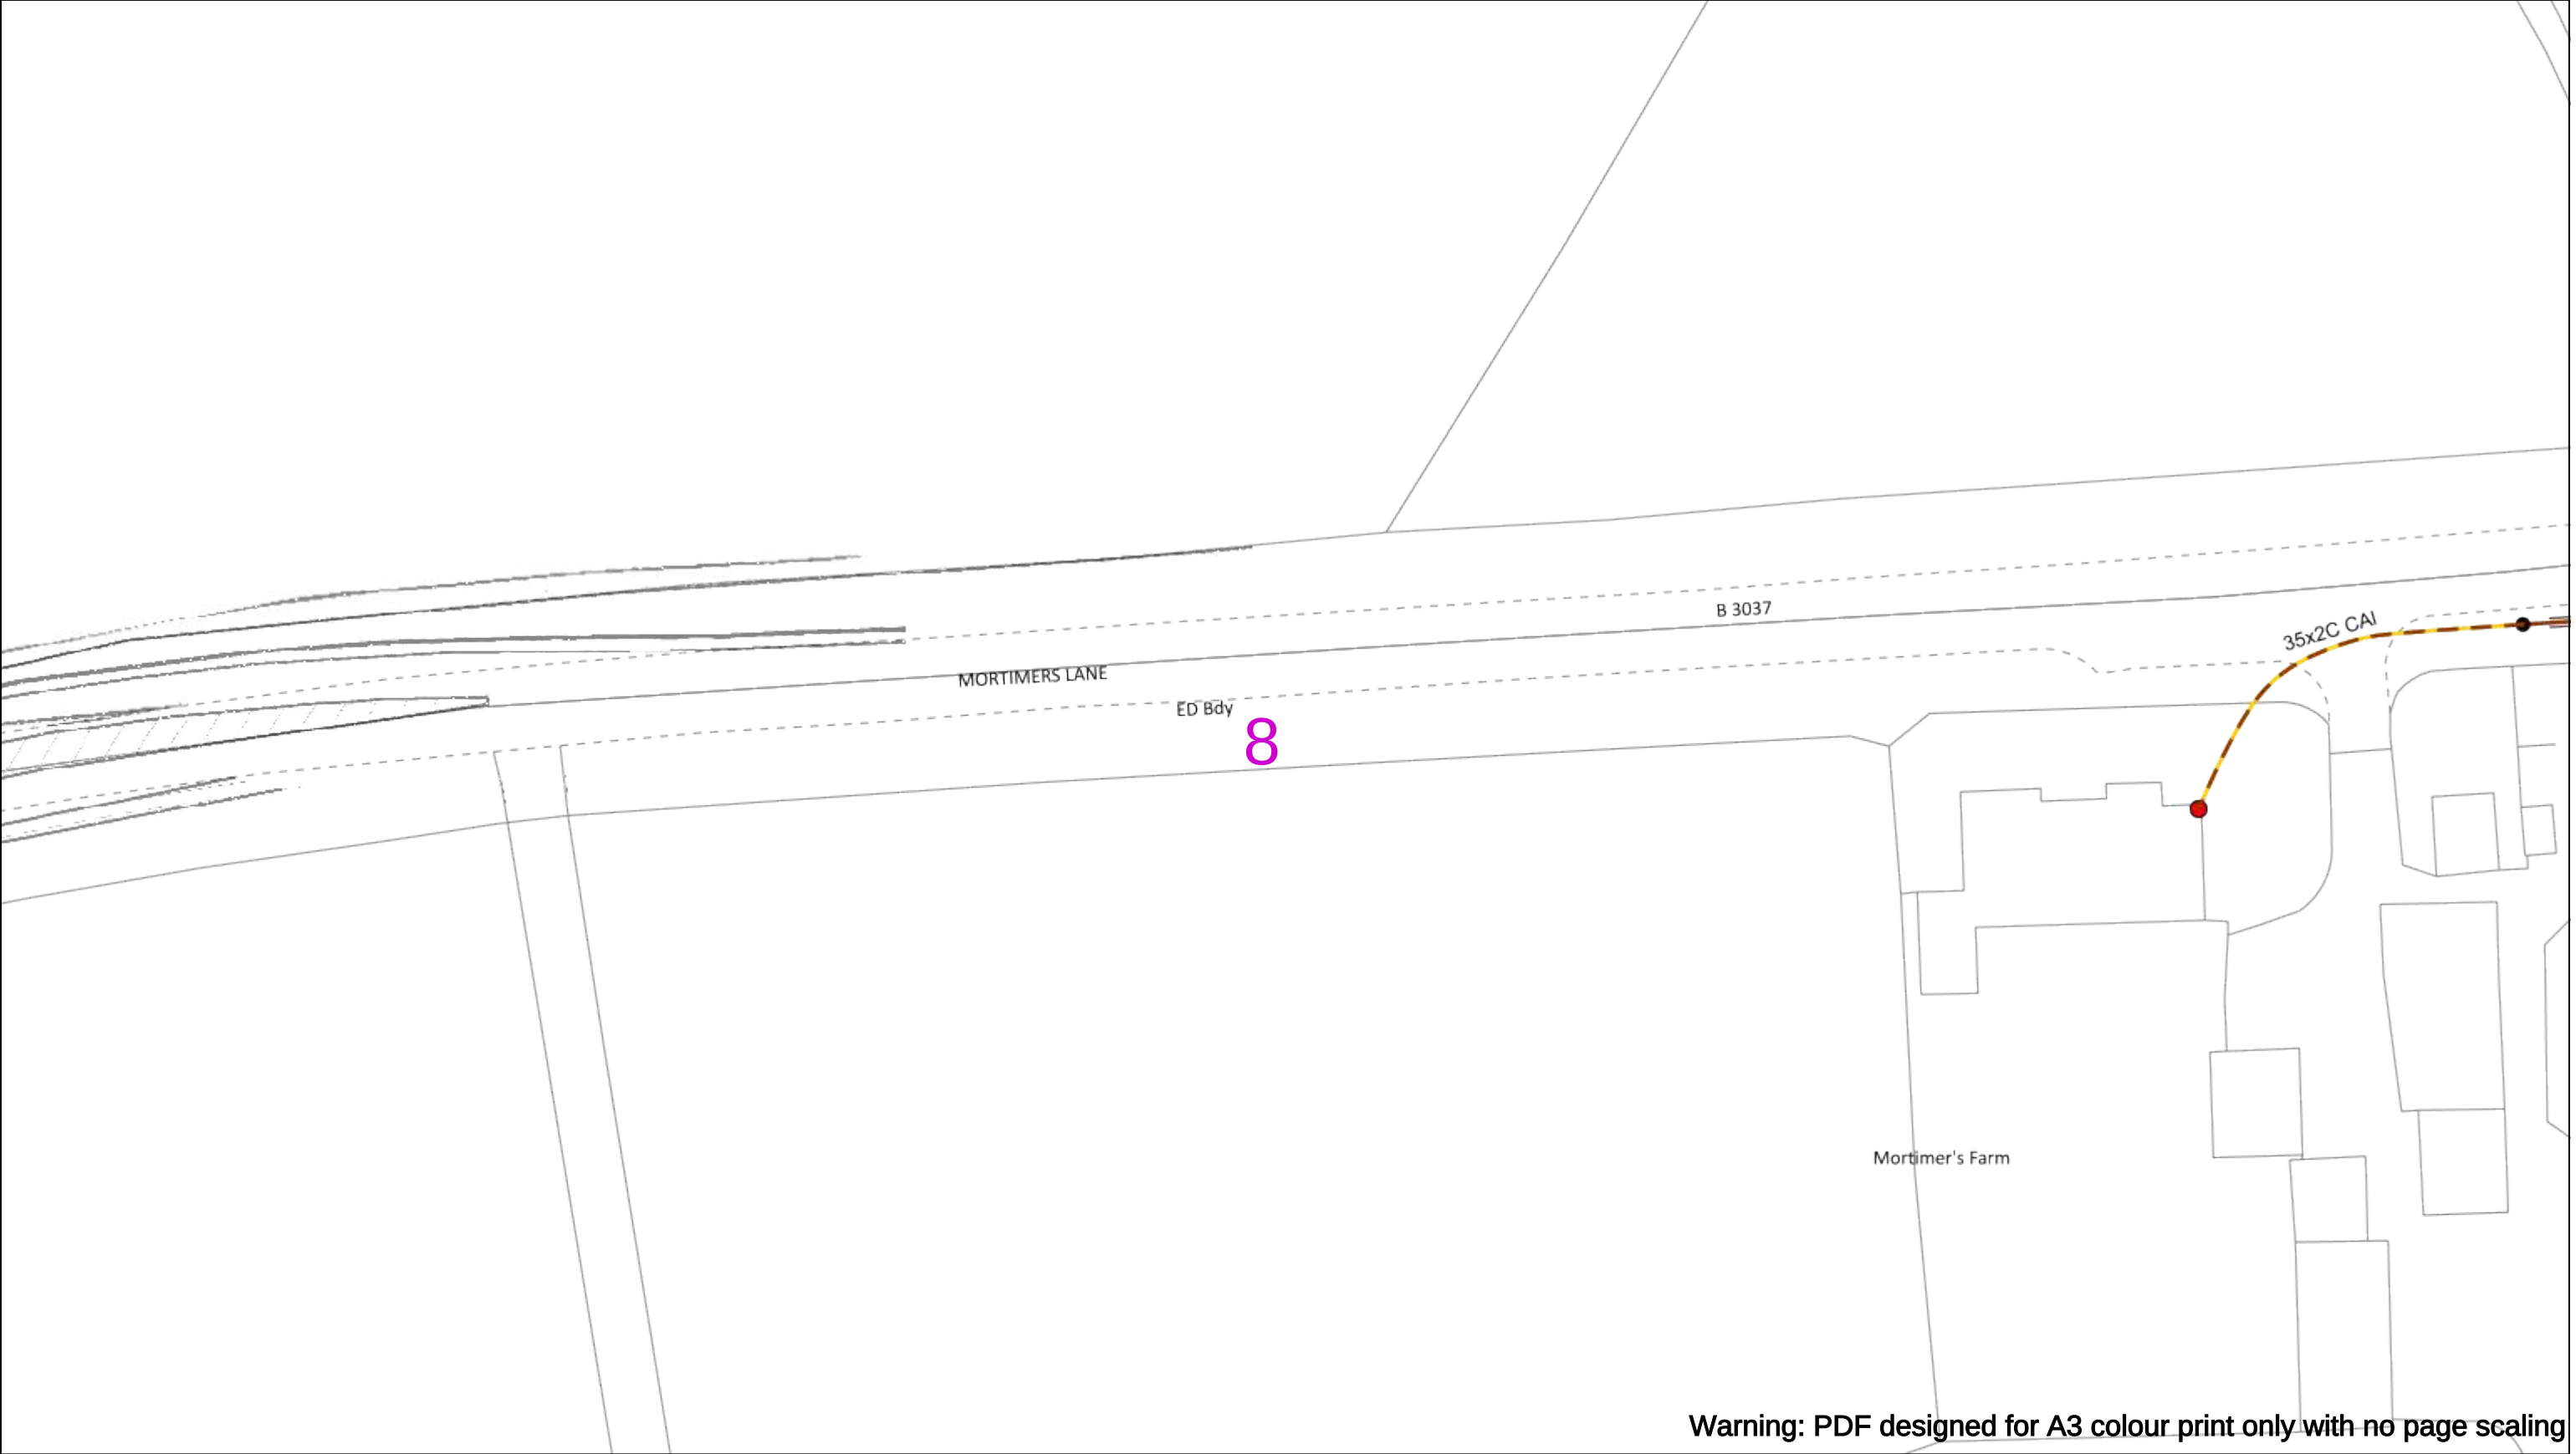

Warning: PDF designed for A3 colour print only with no page scaling

050m

Dig Sites

Area:

Line:

Date Requested: 23/11/2023

Job Reference: 31641913

Site Location: 450687 118647

Requested by:
Ms Debbie Wigston

Your Scheme/Reference: 8230679

WARNING

There may have been subsequent alteration to the surface levels. Trial holes must be undertaken to determine position and depths of cables. HS (G) 47 Booklet from the Health and Safety Executive – Avoiding Danger from Buried Cables – should be consulted before commencing excavation work.

WHEN WORKING IN THE VICINITY OF OVERHEAD LINES THE HEALTH AND SAFETY GUIDANCE NOTES GS6 SHOULD BE CONSULTED (AVAILABLE FROM THE HSE WEBSITE)

Voltages (V)				
LV (Low Voltage) and Services	Up to 1,000V			
HV (High Voltage)	Over 1,000V to 11,000V			
EHV (Extra High Voltage)	22,000V to 132,000V			
Transmission	275,000V and 400,000V			

NORMAL DEPTH TO THE TOP OF THE CABLE WHEN LAID				
	Services	LV	HV	EHV
Footpath/Unmade	0.45m	0.45m	0.6m	0.8m
Road Crossing	0.6m	0.6m	0.75m	0.9m
Agricultural	1m	1m	1m	1.1m

Legend

Service Cable

LV Mains

2 – 3.3kV

6.6kV

11kV

22kV

33kV

66kV

132kV

275kV

400kV

Fibre Optic

Pilot Cable

Distribution Structures (Electric)

Pole, Existing Location

Pole Structure, Existing Location - Single

Pole Structure, Existing Location - H

Duct Route

Cross Section Route

N

E

S

W

Scottish & Southern
Electricity Networks

Southern Electric Power Distribution plc

Registered Office: No.1 Forbury Place

43 Forbury Road Reading RG1 3JH

Registered In England & Wales No.04094290

If you're unsure & need to seek advice before commencing excavations please contact:

General Enquiries: 0800 048 3516

Subject to revision – Master held by SSEN Asset Data Team:


Asset.Data@sse.com

01256 337 294

Scale: 1:500 (When plotted at A3)

BASED UPON THE ORDNANCE SURVEY MAP WITH THE SANCTION OF THE CONTROLLER OF THE STATIONERY OFFICE CROWN COPYRIGHT RESERVED.

This copy has been made by or with the authority of Scottish and Southern Energy Power Distribution Ltd. Pursuant to section 47 of the Copyright, Designs and Patents Act 1988 ('The Act'). Unless the Act provides a relevant exception to copyright the copy must not be copied without prior permission of the copyright owner. Plans generated by DigSAFE Pro™ software provided by LinesearchbeforeUdig.

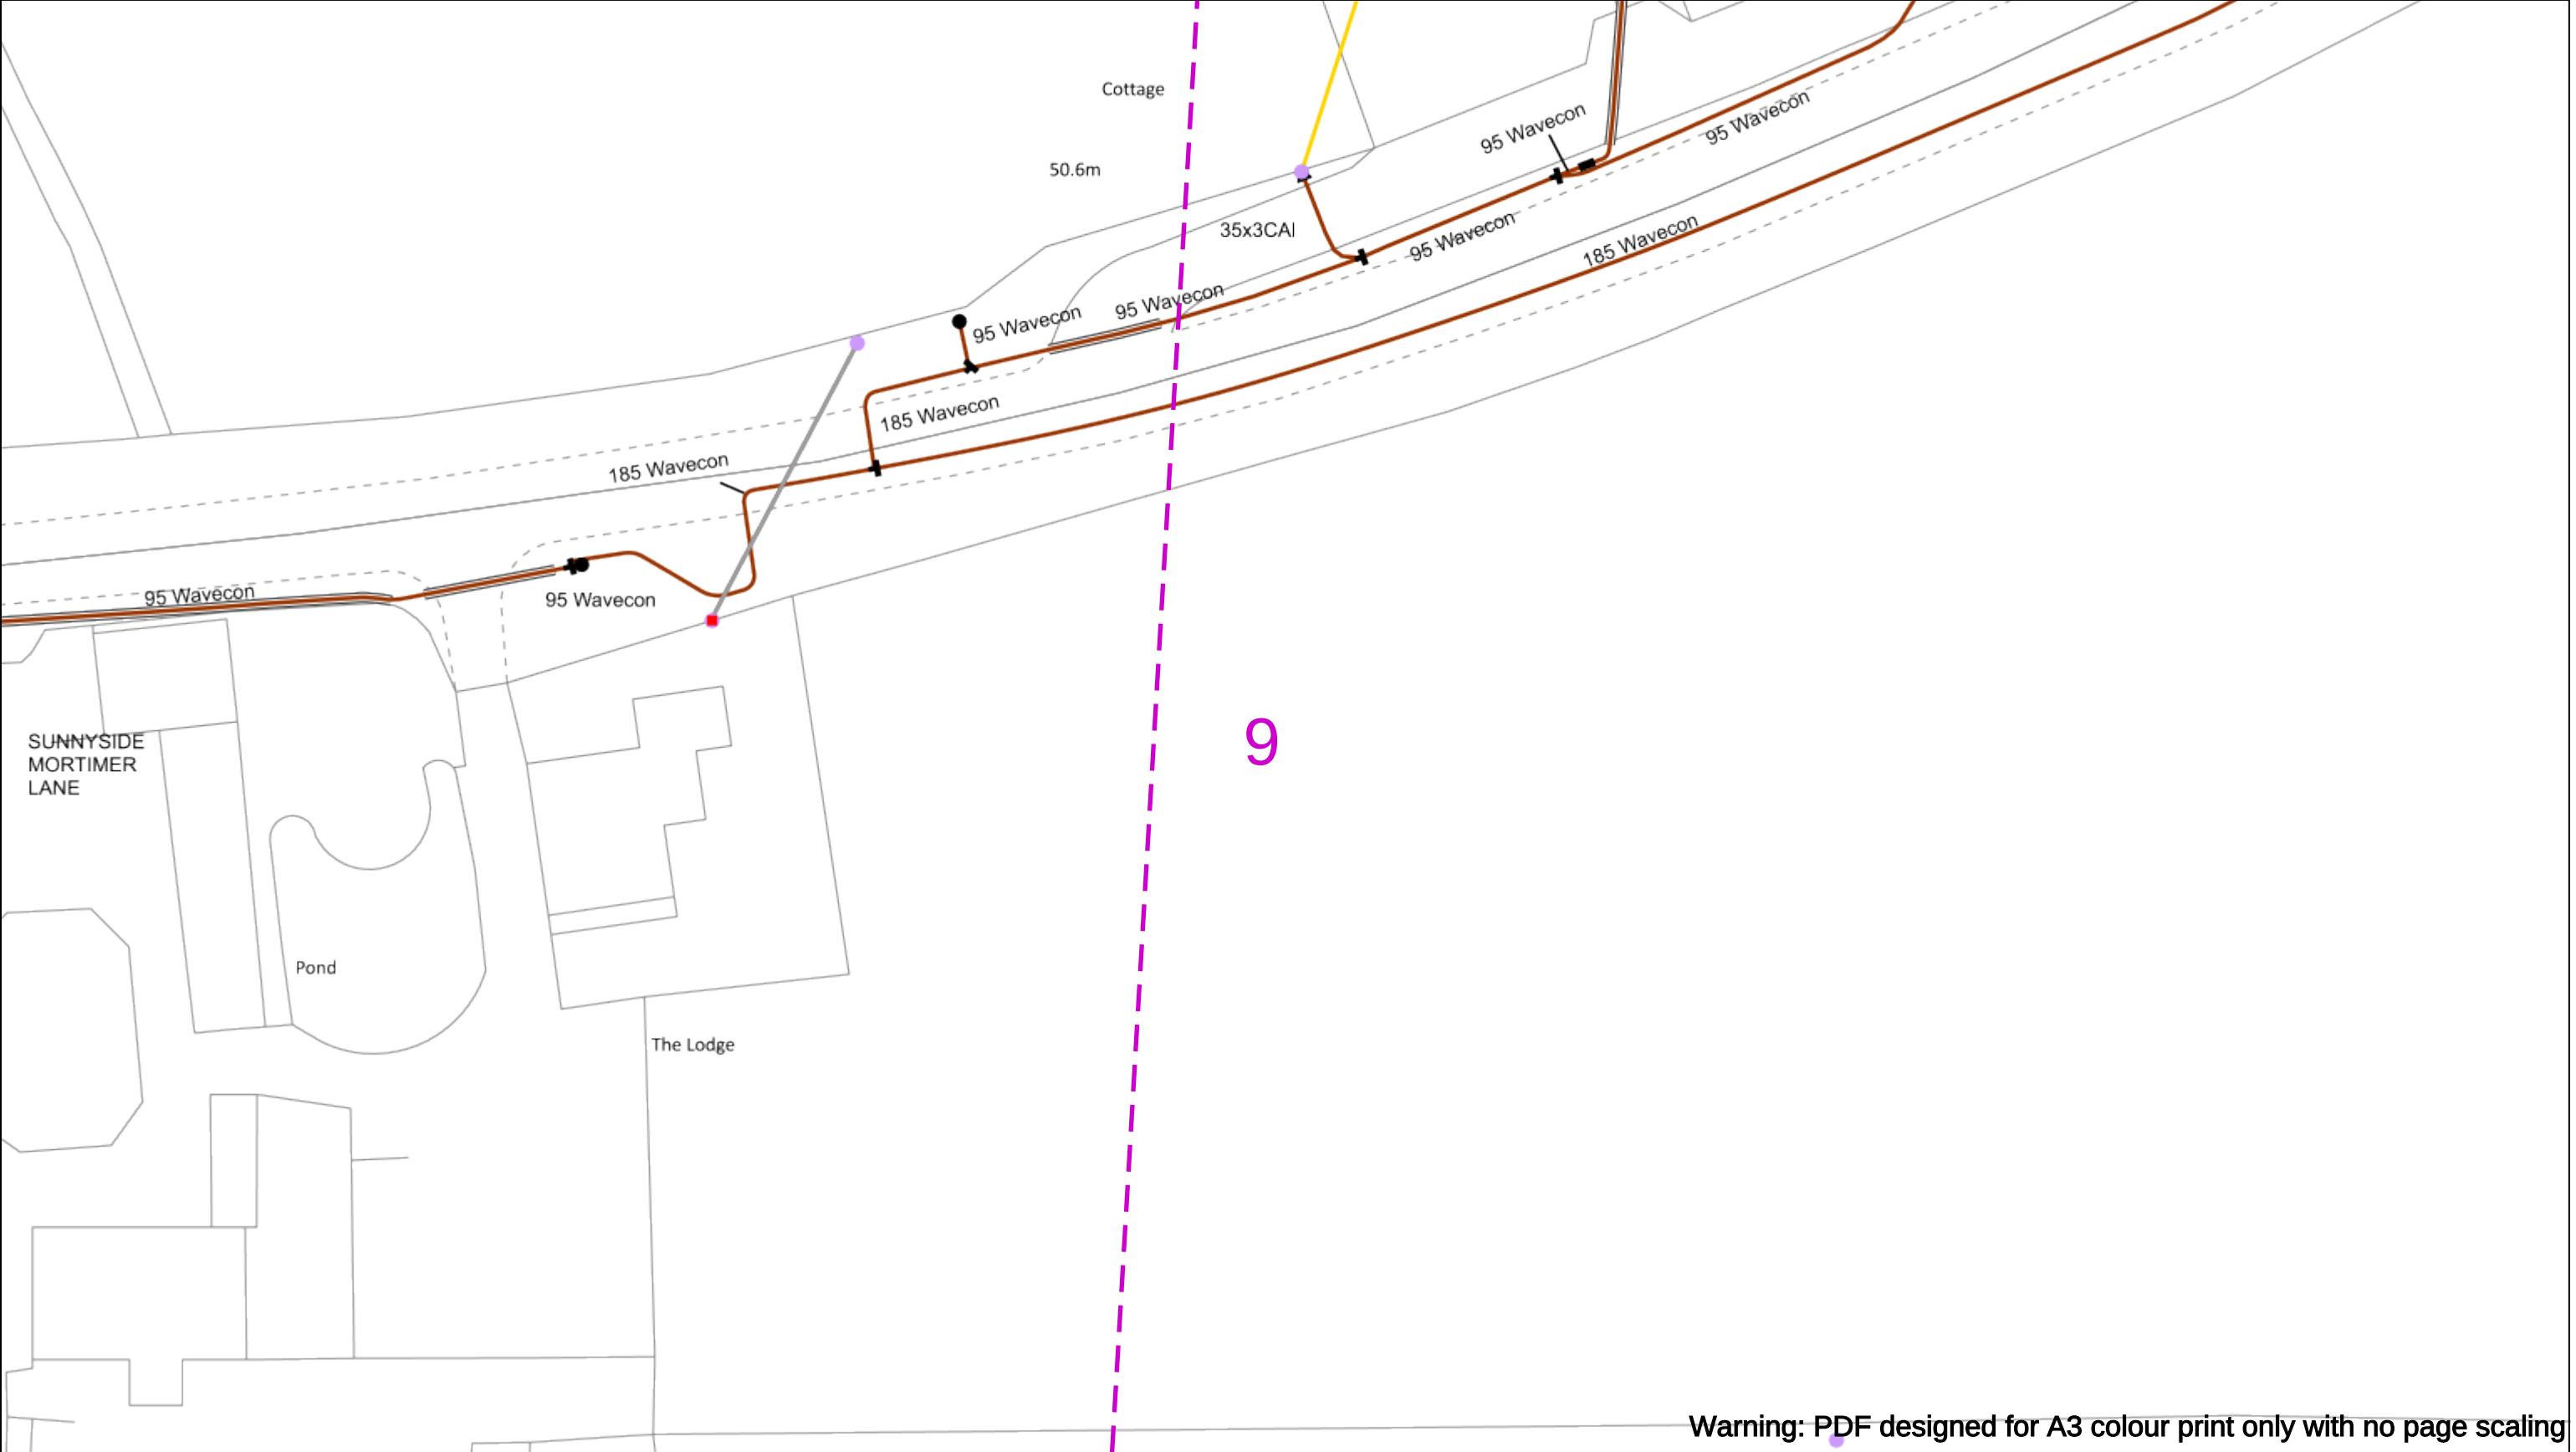

Warning: PDF designed for A3 colour print only with no page scaling

050m

Dig Sites

Area:

Line:

Date Requested: 23/11/2023

Job Reference: 31641913

Site Location: 450687 118647

Requested by:
Ms Debbie Wigston

Your Scheme/Reference: 8230679

WARNING

There may have been subsequent alteration to the surface levels. Trial holes must be undertaken to determine position and depths of cables. HS (G) 47 Booklet from the Health and Safety Executive – Avoiding Danger from Buried Cables – should be consulted before commencing excavation work.

WHEN WORKING IN THE VICINITY OF OVERHEAD LINES THE HEALTH AND SAFETY GUIDANCE NOTES GS6 SHOULD BE CONSULTED (AVAILABLE FROM THE HSE WEBSITE)

Scale: 1:500 (When plotted at A3)

Voltages (V)				
LV (Low Voltage) and Services	Up to 1,000V			
HV (High Voltage)	Over 1,000V to 11,000V			
EHV (Extra High Voltage)	22,000V to 132,000V			
Transmission	275,000V and 400,000V			

NORMAL DEPTH TO THE TOP OF THE CABLE WHEN LAID				
	Services	LV	HV	EHV
Footpath/Unmade	0.45m	0.45m	0.6m	0.8m
Road Crossing	0.6m	0.6m	0.75m	0.9m
Agricultural	1m	1m	1m	1.1m

Legend

Service Cable

LV Mains

2 – 3.3kV

6.6kV

11kV

22kV

33kV

66kV

Distribution Structures (Electric)

Pole, Existing Location

Pole Structure, Existing Location - Single

Pole Structure, Existing Location - H

Scottish & Southern

Electricity Networks

Southern Electric Power Distribution plc

Registered Office: No.1 Forbury Place

43 Forbury Road Reading RG1 3JH

Registered In England & Wales No.04094290

If you're unsure & need to seek advice before commencing excavations please contact:

General Enquiries: 0800 048 3516


Subject to revision – Master held by SSEN Asset Data Team:

Asset.Data@sse.com

01256 337 294

BASED UPON THE ORDNANCE SURVEY MAP WITH THE SANCTION OF THE CONTROLLER OF THE STATIONERY OFFICE CROWN COPYRIGHT RESERVED.

This copy has been made by or with the authority of Scottish and Southern Energy Power Distribution Ltd. Pursuant to section 47 of the Copyright, Designs and Patents Act 1988 ('The Act'). Unless the Act provides a relevant exception to copyright the copy must not be copied without prior permission of the copyright owner. Plans generated by DigSAFE Pro™ software provided by LinesearchbeforeUdig.

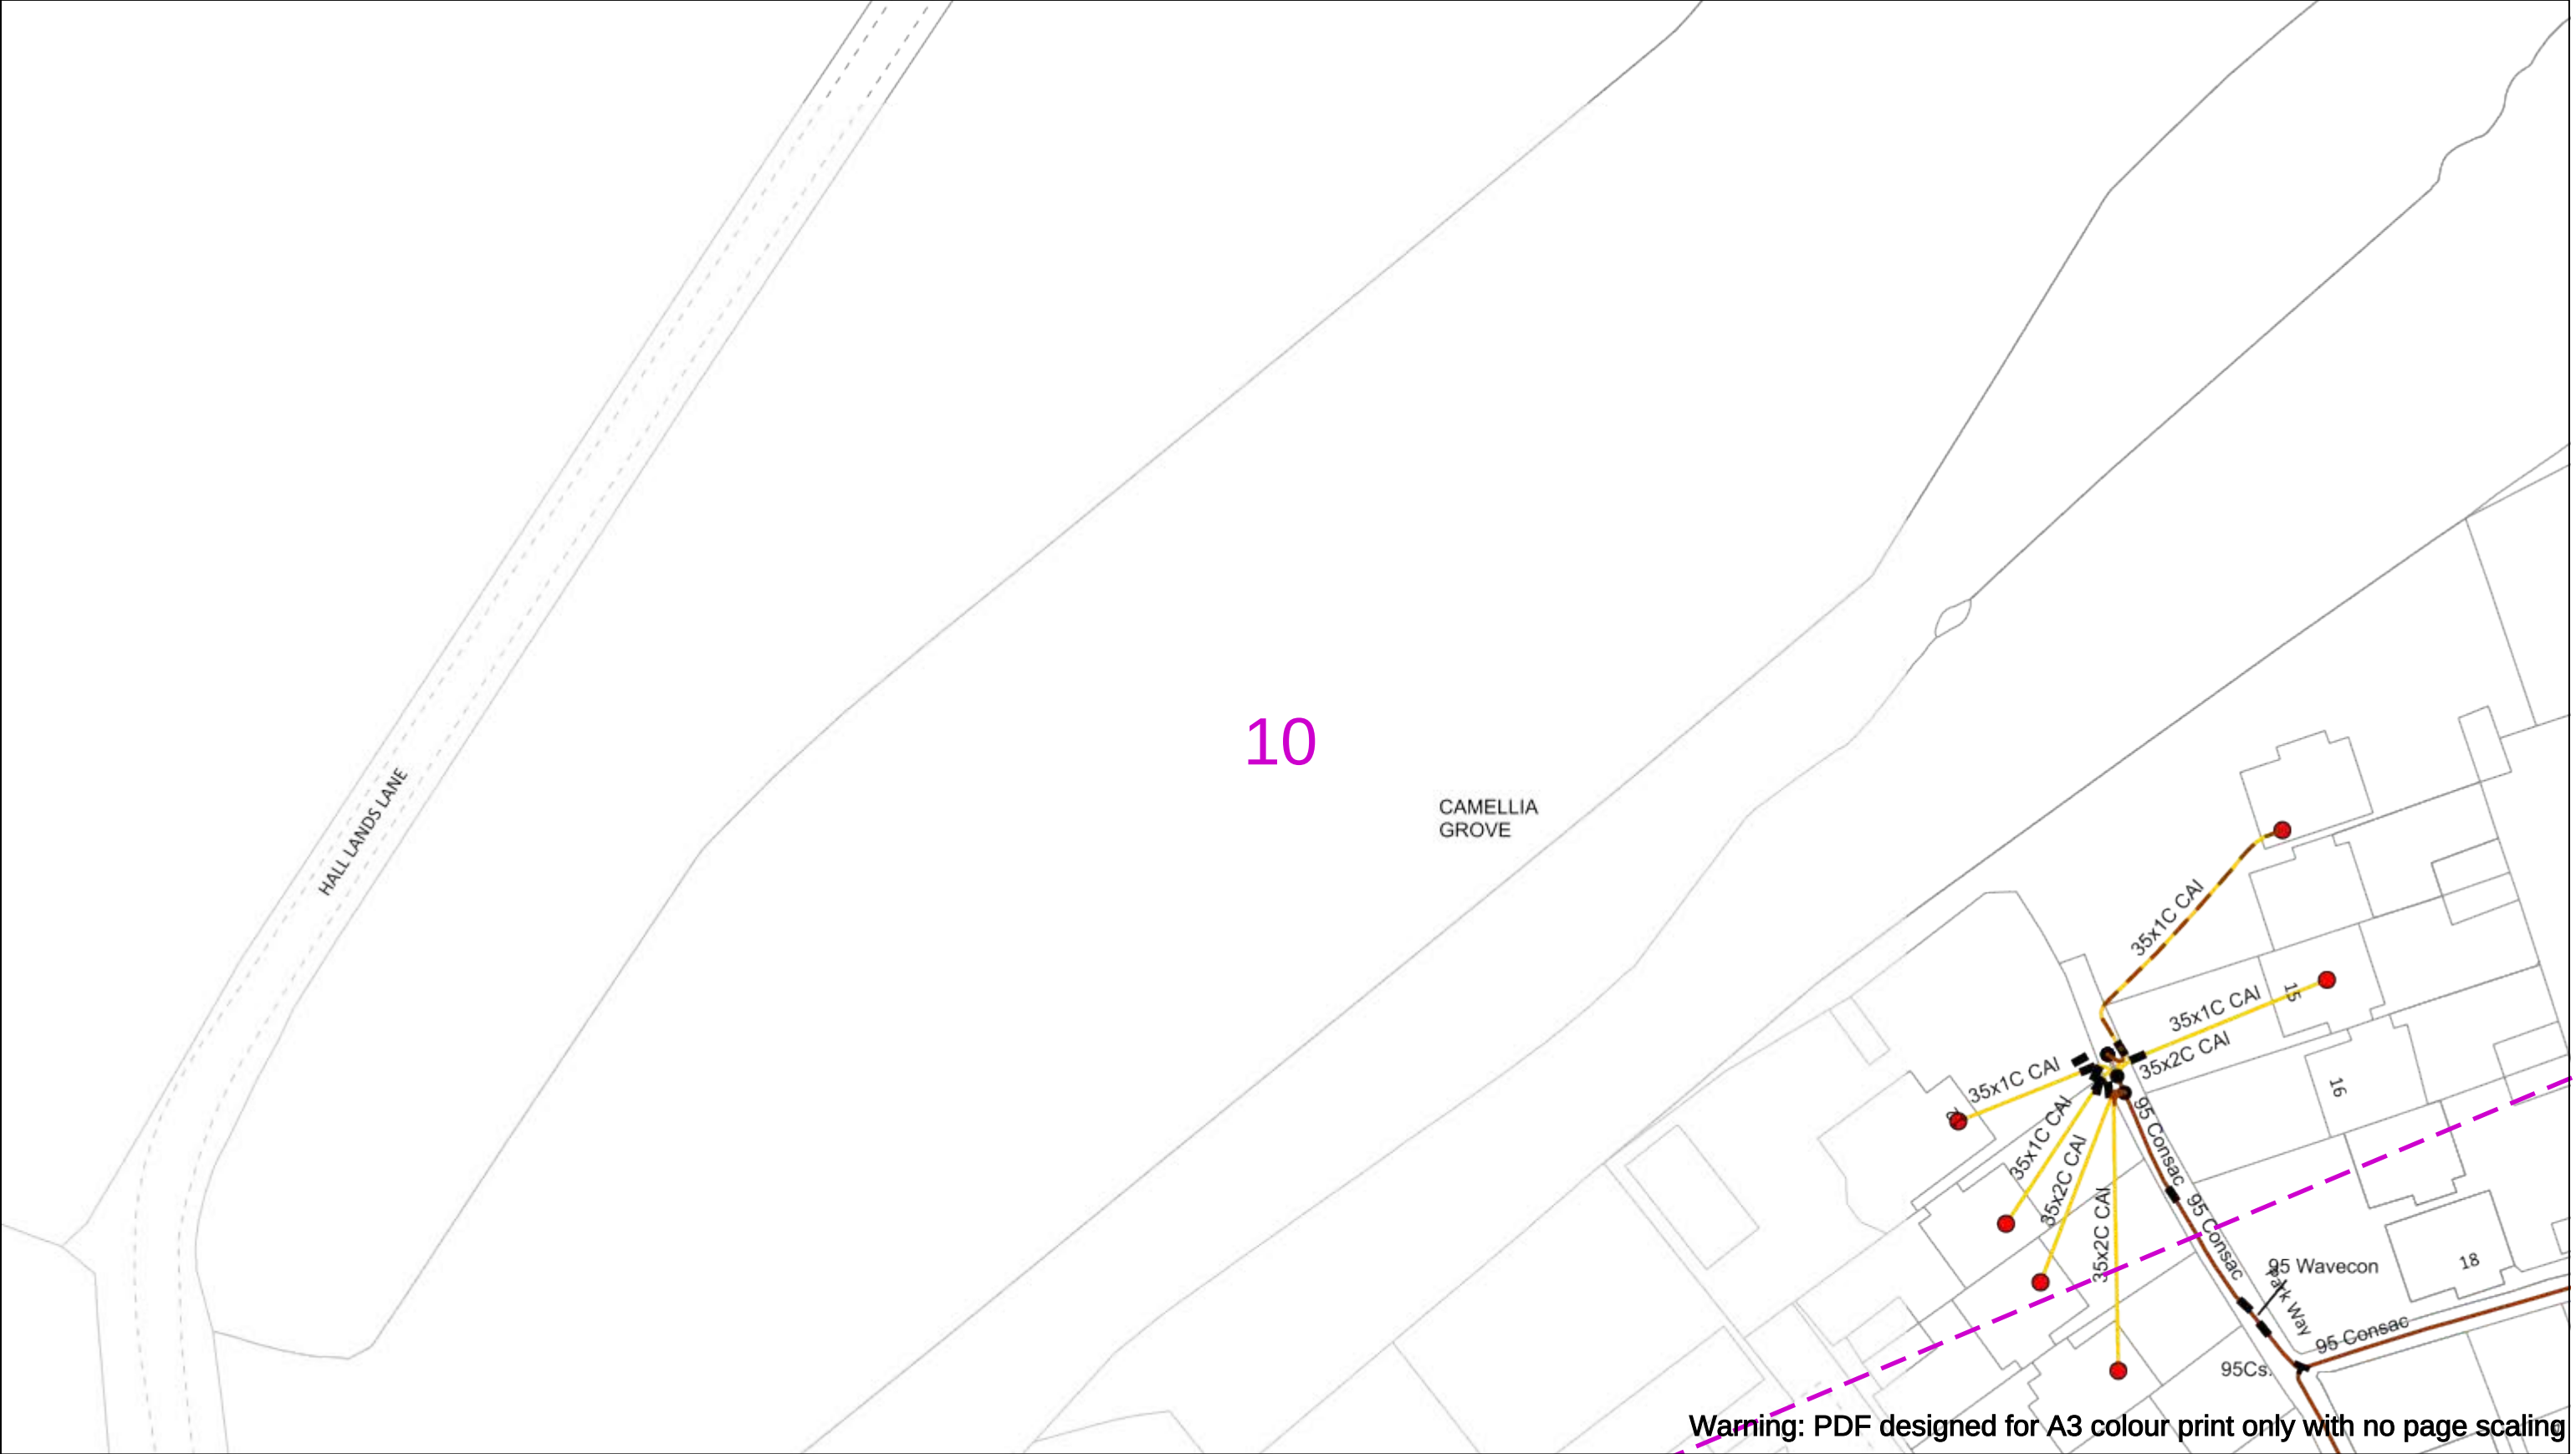

Warning: PDF designed for A3 colour print only with no page scaling

050m

Dig Sites

Area:

Line:

Date Requested: 23/11/2023

Job Reference: 31641913

Site Location: 450687 118647

Requested by: Ms Debbie Wigston

Your Scheme/Reference: 8230679

WARNING

There may have been subsequent alteration to the surface levels. Trial holes must be undertaken to determine position and depths of cables. HS (G) 47 Booklet from the Health and Safety Executive – Avoiding Danger from Buried Cables – should be consulted before commencing excavation work.

WHEN WORKING IN THE VICINITY OF OVERHEAD LINES THE HEALTH AND SAFETY GUIDANCE NOTES GS6 SHOULD BE CONSULTED (AVAILABLE FROM THE HSE WEBSITE)

	Voltages (V)			
LV (Low Voltage) and Services	Up to 1,000V			
HV (High Voltage)	Over 1,000V to 11,000V			
EHV (Extra High Voltage)	22,000V to 132,000V			
Transmission	275,000V and 400,000V			

	NORMAL DEPTH TO THE TOP OF THE CABLE WHEN LAID			
	Services	LV	HV	EHV
Footpath/Unmade	0.45m	0.45m	0.6m	0.8m
Road Crossing	0.6m	0.6m	0.75m	0.9m
Agricultural	1m	1m	1m	1.1m

Legend

Service Cable

LV Mains

2 – 3.3kV

6.6kV

11kV

22kV

33kV

66kV

132kV

275kV

400kV

Fibre Optic

Pilot Cable

Distribution Structures (Electric)

Pole, Existing Location

Pole Structure, Existing Location - Single

Pole Structure, Existing Location - H

Duct Route

Cross Section Route

Scottish & Southern

Electricity Networks

Southern Electric Power Distribution plc

Registered Office: No.1 Forbury Place

43 Forbury Road Reading RG1 3JH

Registered In England & Wales No.04094290

If you're unsure & need to seek advice before commencing excavations please contact:

General Enquiries: 0800 048 3516

Subject to revision – Master held by SSEN Asset Data Team:


Asset.Data@sse.com

01256 337 294

Scale: 1:500 (When plotted at A3)

BASED UPON THE ORDNANCE SURVEY MAP WITH THE SANCTION OF THE CONTROLLER OF H.M STATIONERY OFFICE CROWN COPYRIGHT RESERVED.

This copy has been made by or with the authority of Scottish and Southern Energy Power Distribution Ltd. Pursuant to section 47 of the Copyright, Designs and Patents Act 1988 ('The Act'). Unless the Act provides a relevant exception to copyright the copy must not be copied without prior permission of the copyright owner. Plans generated by DigSAFE Pro™ software provided by LinesearchbeforeUdig.

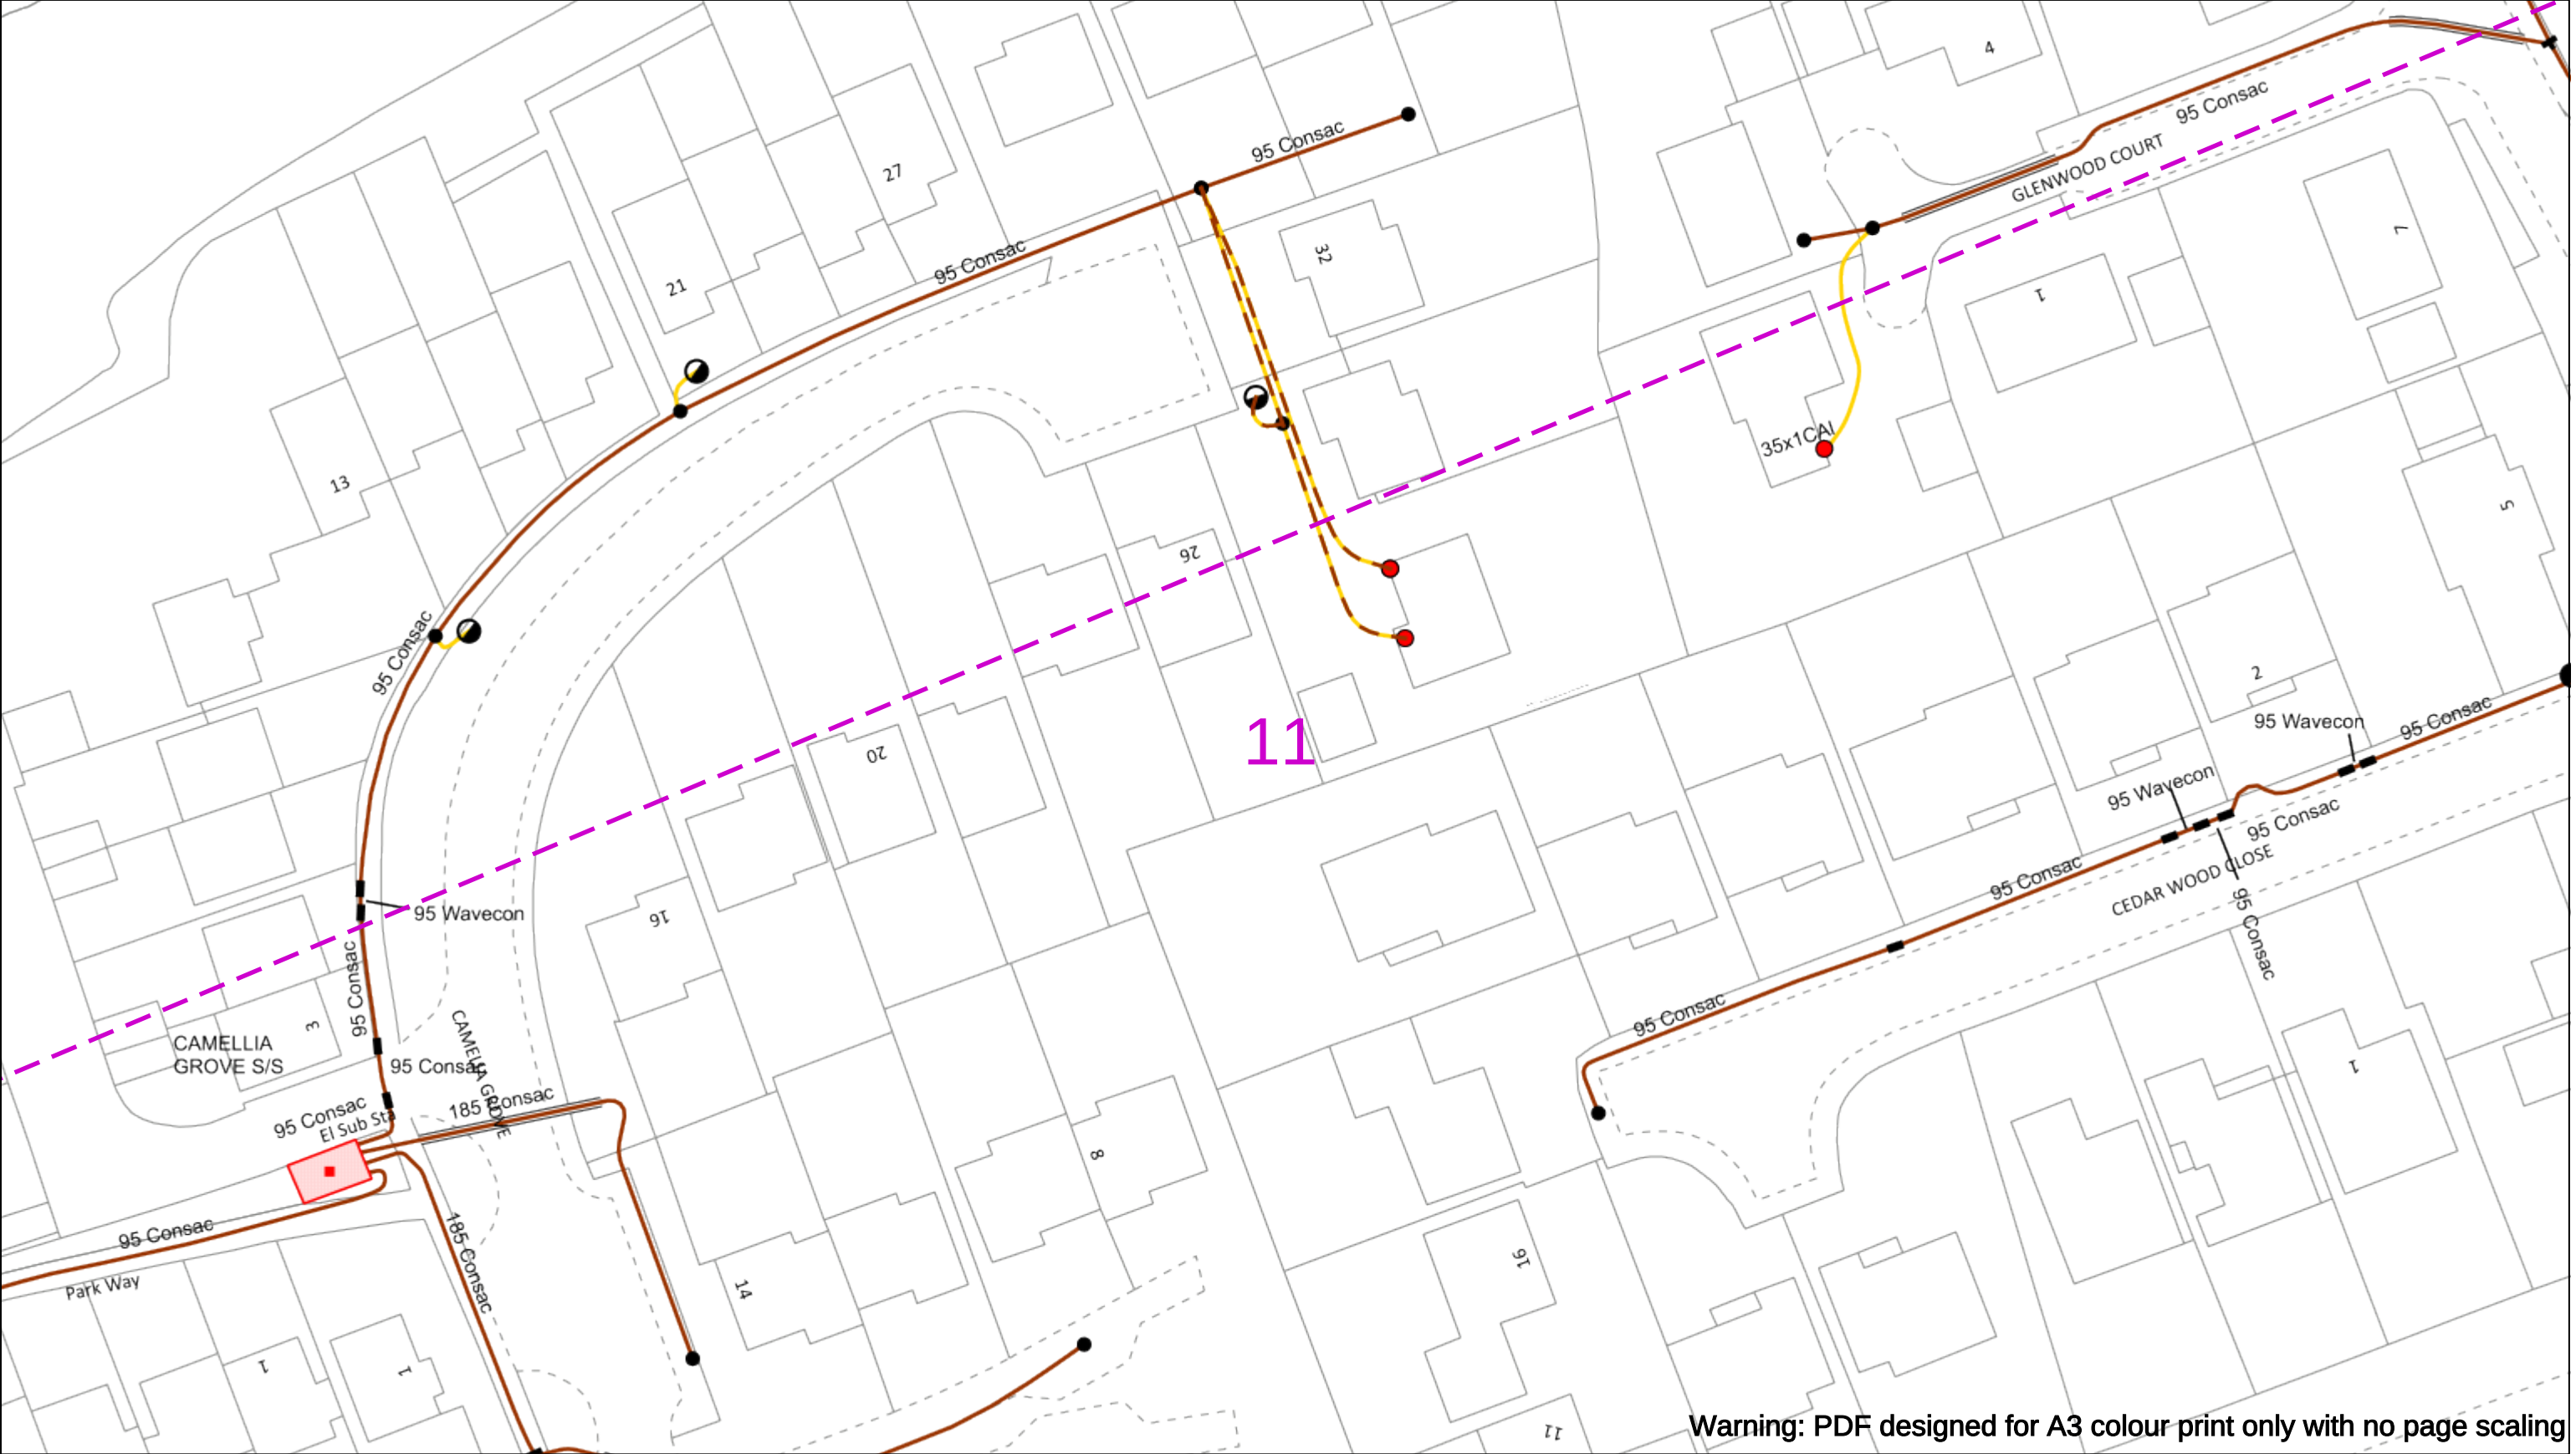

050m

Dig Sites

Area:

Line:

Date Requested: 23/11/2023

Job Reference: 31641913

Site Location: 450687 118647

Requested by:
Ms Debbie Wigston

Your Scheme/Reference: 8230679

WARNING

There may have been subsequent alteration to the surface levels. Trial holes must be undertaken to determine position and depths of cables. HS (G) 47 Booklet from the Health and Safety Executive – Avoiding Danger from Buried Cables – should be consulted before commencing excavation work.

WHEN WORKING IN THE VICINITY OF OVERHEAD LINES THE HEALTH AND SAFETY GUIDANCE NOTES GS6 SHOULD BE CONSULTED (AVAILABLE FROM THE HSE WEBSITE)

	Voltages (V)			
LV (Low Voltage) and Services	Up to 1,000V			
HV (High Voltage)	Over 1,000V to 11,000V			
EHV (Extra High Voltage)	22,000V to 132,000V			
Transmission	275,000V and 400,000V			

	NORMAL DEPTH TO THE TOP OF THE CABLE WHEN LAID			
	Services	LV	HV	EHV
Footpath/Unmade	0.45m	0.45m	0.6m	0.8m
Road Crossing	0.6m	0.6m	0.75m	0.9m
Agricultural	1m	1m	1m	1.1m

Legend

Service Cable

LV Mains

2 – 3.3kV

6.6kV

11kV

22kV

33kV

66kV

132kV

275kV

400kV

Fibre Optic

Pilot Cable

Distribution Structures (Electric)

Pole, Existing Location

Pole Structure, Existing Location - Single

Pole Structure, Existing Location - H

Duct Route

Cross Section Route

Scottish & Southern

Electricity Networks

Southern Electric Power Distribution plc

Registered Office: No.1 Forbury Place

43 Forbury Road Reading RG1 3JH

Registered In England & Wales No.04094290

If you're unsure & need to seek advice before commencing excavations please contact:

General Enquiries: 0800 048 3516

Subject to revision – Master held by SSEN Asset Data Team:


Asset.Data@sse.com

01256 337 294

Scale: 1:500 (When plotted at A3)

BASED UPON THE ORDNANCE SURVEY MAP WITH THE SANCTION OF THE CONTROLLER OF H.M STATIONERY OFFICE CROWN COPYRIGHT RESERVED.

This copy has been made by or with the authority of Scottish and Southern Energy Power Distribution Ltd. Pursuant to section 47 of the Copyright, Designs and Patents Act 1988 ('The Act'). Unless the Act provides a relevant exception to copyright the copy must not be copied without prior permission of the copyright owner. Plans generated by DigSAFE Pro™ software provided by LinesearchbeforeUdig.

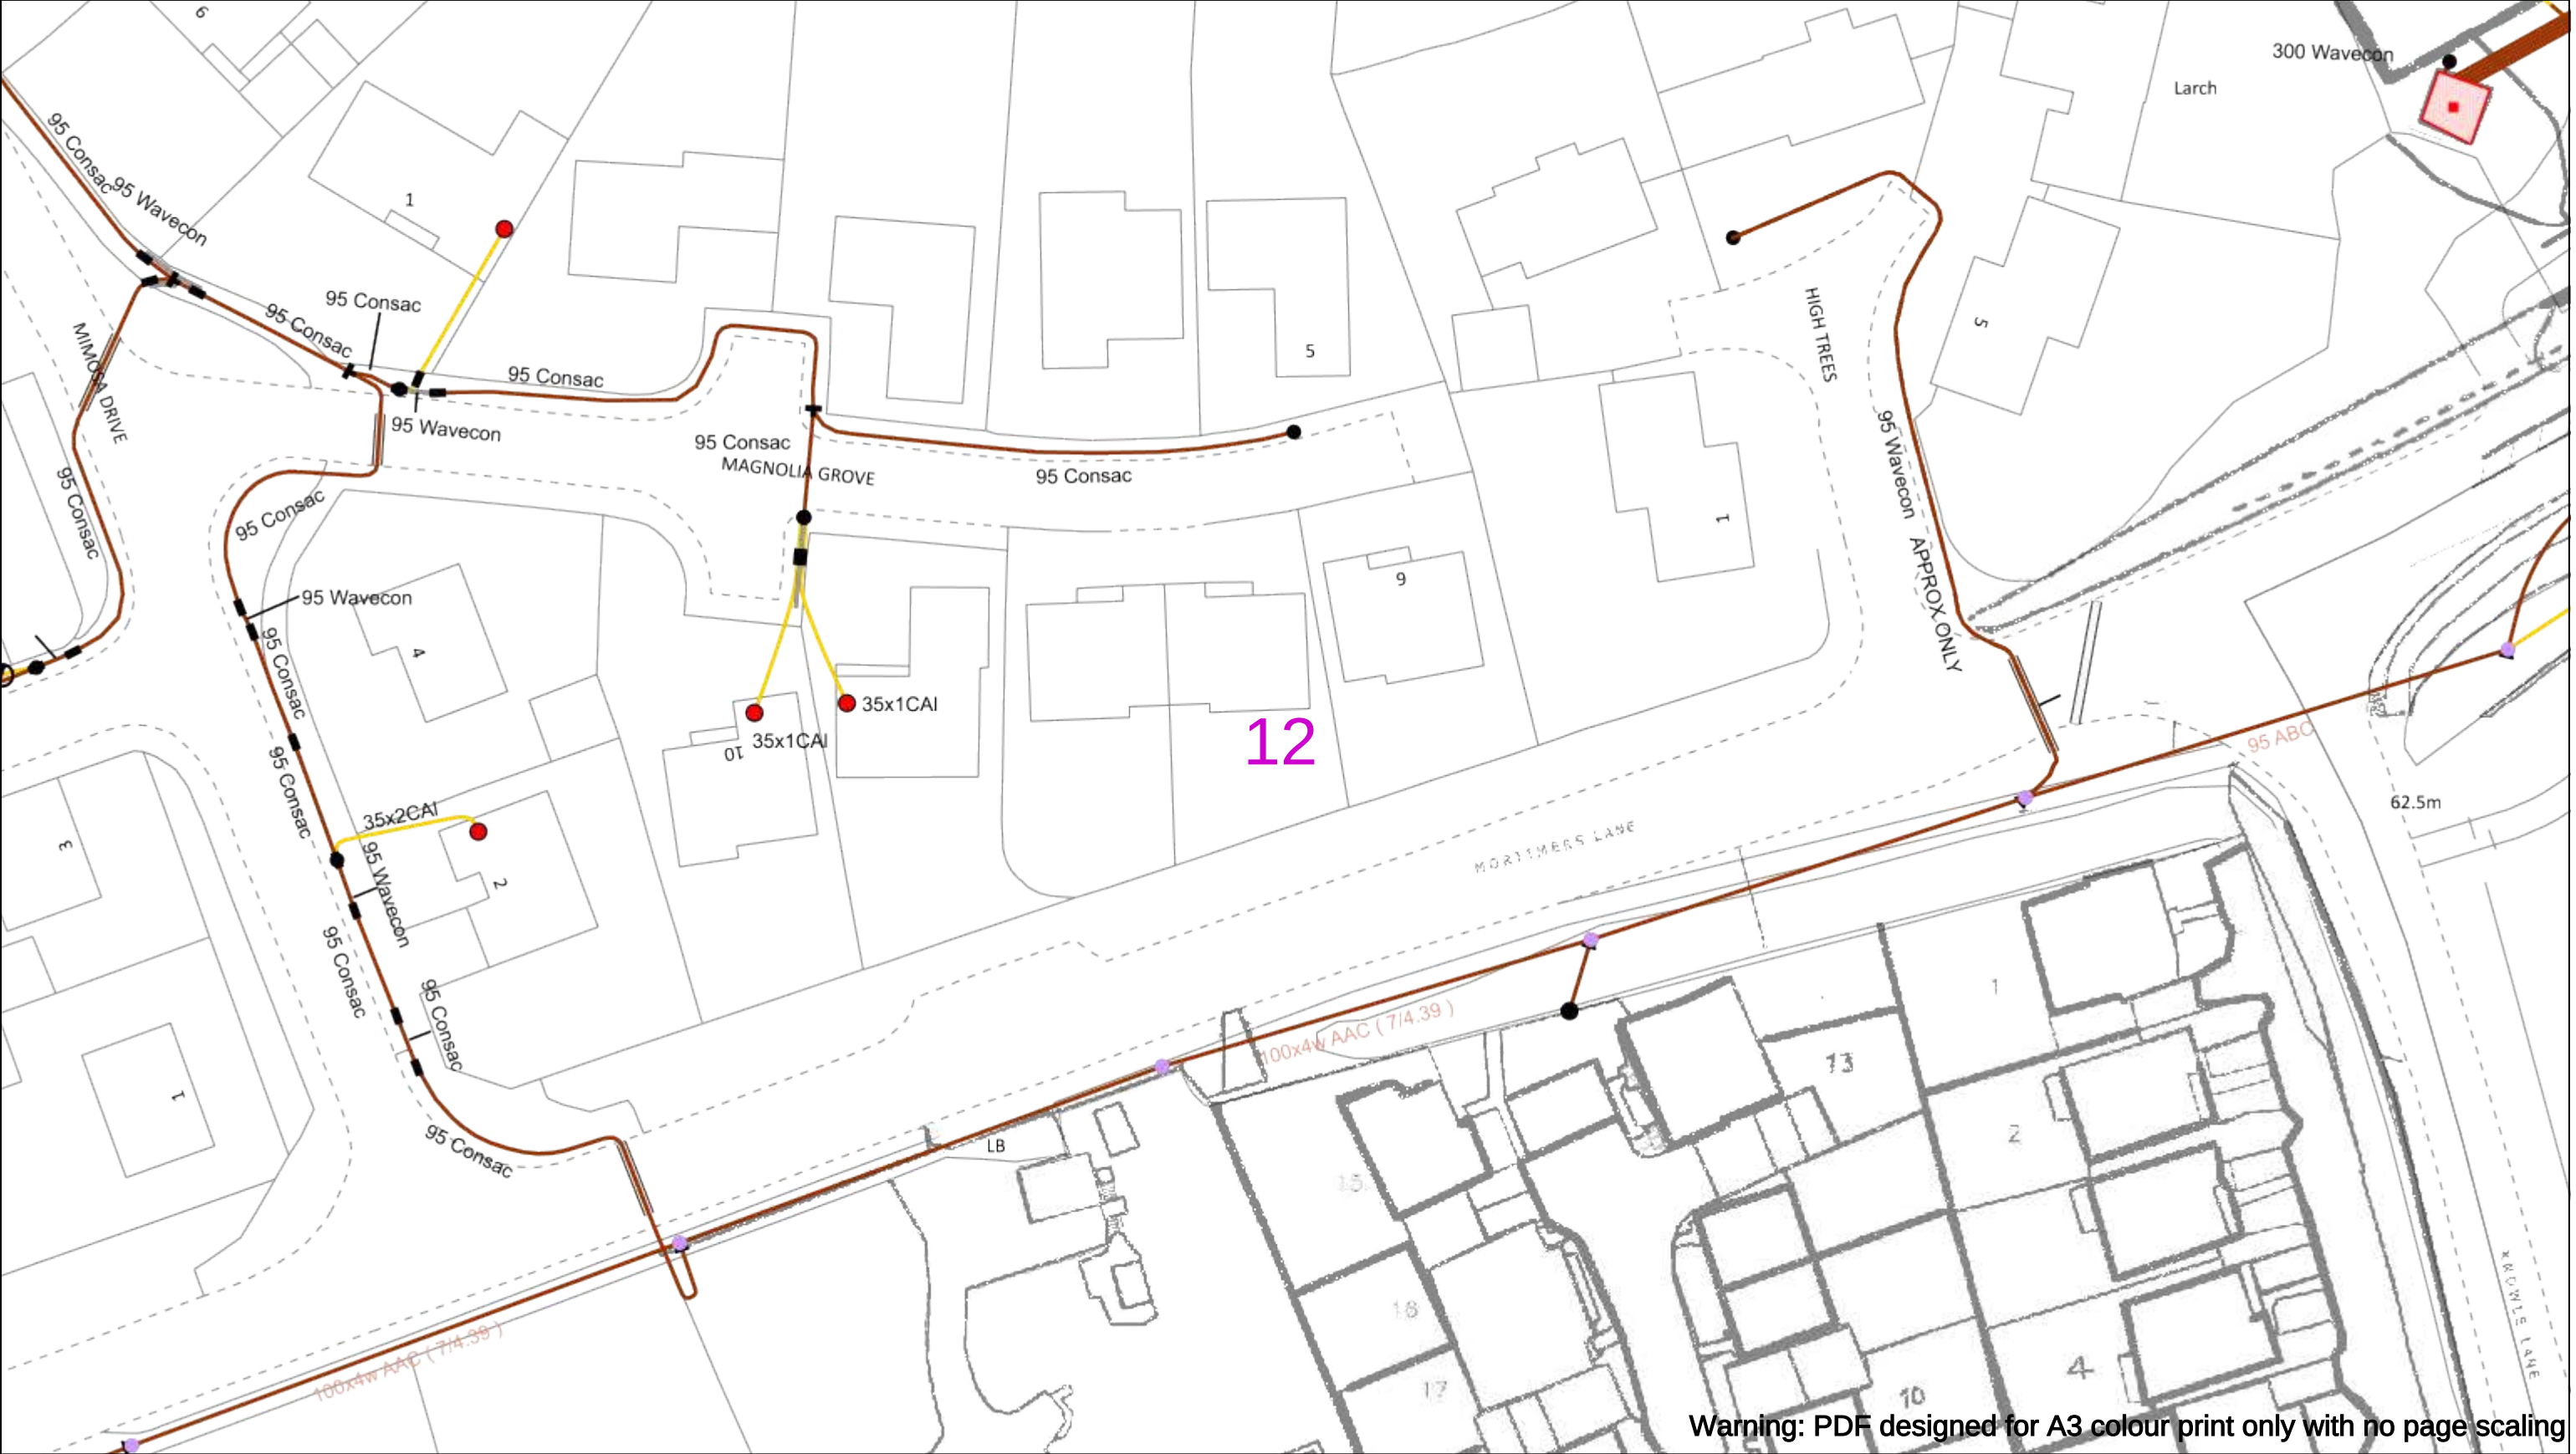

Warning: PDF designed for A3 colour print only with no page scaling

050m

Dig Sites

Area:

Line:

Date Requested: 23/11/2023

Job Reference: 31641913

Site Location: 450687 118647

Requested by:
Ms Debbie Wigston

Your Scheme/Reference: 8230679

WARNING

There may have been subsequent alteration to the surface levels. Trial holes must be undertaken to determine position and depths of cables. HS (G) 47 Booklet from the Health and Safety Executive – Avoiding Danger from Buried Cables – should be consulted before commencing excavation work.

WHEN WORKING IN THE VICINITY OF OVERHEAD LINES THE HEALTH AND SAFETY GUIDANCE NOTES GS6 SHOULD BE CONSULTED (AVAILABLE FROM THE HSE WEBSITE)

	Voltages (V)			
LV (Low Voltage) and Services	Up to 1,000V			
HV (High Voltage)	Over 1,000V to 11,000V			
EHV (Extra High Voltage)	22,000V to 132,000V			
Transmission	275,000V and 400,000V			

	NORMAL DEPTH TO THE TOP OF THE CABLE WHEN LAID			
	Services	LV	HV	EHV
Footpath/Unmade	0.45m	0.45m	0.6m	0.8m
Road Crossing	0.6m	0.6m	0.75m	0.9m
Agricultural	1m	1m	1m	1.1m

Legend

Service Cable

LV Mains

2 – 3.3kV

6.6kV

11kV

22kV

33kV

Distribution Structures (Electric)

Pole, Existing Location

Southern Electric Power Distribution plc

Registered Office: No.1 Forbury Place

43 Forbury Road Reading RG1 3JH

Registered In England & Wales No.04094290

If you're unsure & need to seek advice before commencing excavations please contact:

General Enquiries: 0800 048 3516

Subject to revision – Master held by SSEN Asset Data Team:

Asset.Data@sse.com

01256 337 294

Scale: 1:500 (When plotted at A3)

BASED UPON THE ORDNANCE SURVEY MAP WITH THE SANCTION OF THE CONTROLLER OF THE STATIONERY OFFICE CROWN COPYRIGHT RESERVED.

This copy has been made by or with the authority of Scottish and Southern Energy Power Distribution Ltd. Pursuant to section 47 of the Copyright, Designs and Patents Act 1988 ('The Act'). Unless the Act provides a relevant exception to copyright the copy must not be copied without prior permission of the copyright owner. Plans generated by DigSAFE Pro™ software provided by LinesearchbeforeUdig.



Warning: PDF designed for A3 colour print only with no page scaling

050m

Dig Sites

Area: ----

Line: ----

Date Requested: 23/11/2023

Job Reference: 31641913

Site Location: 450687 118647

Requested by: Ms Debbie Wigston

Your Scheme/Reference: 8230679

WARNING

There may have been subsequent alteration to the surface levels. Trial holes must be undertaken to determine position and depths of cables. HS (G) 47 Booklet from the Health and Safety Executive – Avoiding Danger from Buried Cables – should be consulted before commencing excavation work.

WHEN WORKING IN THE VICINITY OF OVERHEAD LINES THE HEALTH AND SAFETY GUIDANCE NOTES GS6 SHOULD BE CONSULTED (AVAILABLE FROM THE HSE WEBSITE)

	Voltages (V)			
LV (Low Voltage) and Services	Up to 1,000V			
HV (High Voltage)	Over 1,000V to 11,000V			
EHV (Extra High Voltage)	22,000V to 132,000V			
Transmission	275,000V and 400,000V			

	NORMAL DEPTH TO THE TOP OF THE CABLE WHEN LAID			
	Services	LV	HV	EHV
Footpath/Unmade	0.45m	0.45m	0.6m	0.8m
Road Crossing	0.6m	0.6m	0.75m	0.9m
Agricultural	1m	1m	1m	1.1m

Legend

Service Cable

LV Mains

2 – 3.3kV

6.6kV

11kV

22kV

33kV

66kV

132kV

275kV

400kV

Fibre Optic

Pilot Cable

Distribution Structures (Electric)

Pole, Existing Location

Pole Structure, Existing Location - Single

Pole Structure, Existing Location - H

Duct Route

Cross Section Route

Southern Electric Power Distribution plc

Registered Office: No.1 Forbury Place

43 Forbury Road Reading RG1 3JH

Registered In England & Wales No.04094290

If you're unsure & need to seek advice before commencing excavations please contact:


General Enquiries: 0800 048 3516

Subject to revision – Master held by SSEN Asset Data Team:

Asset.Data@sse.com

01256 337 294

THIS COPY HAS BEEN MADE BY OR WITH THE AUTHORITY OF SCOTTISH AND SOUTHERN ENERGY POWER DISTRIBUTION LTD. PURSUANT TO SECTION 47 OF THE COPYRIGHT, DESIGNS AND PATENTS ACT 1988 ('THE ACT'). UNLESS THE ACT PROVIDES A RELEVANT EXCEPTION TO COPYRIGHT THE COPY MUST NOT BE COPIED WITHOUT PRIOR PERMISSION OF THE COPYRIGHT OWNER. PLANS GENERATED BY DIGSAFE PRO™ SOFTWARE PROVIDED BY LINESearchBeforeUdig.

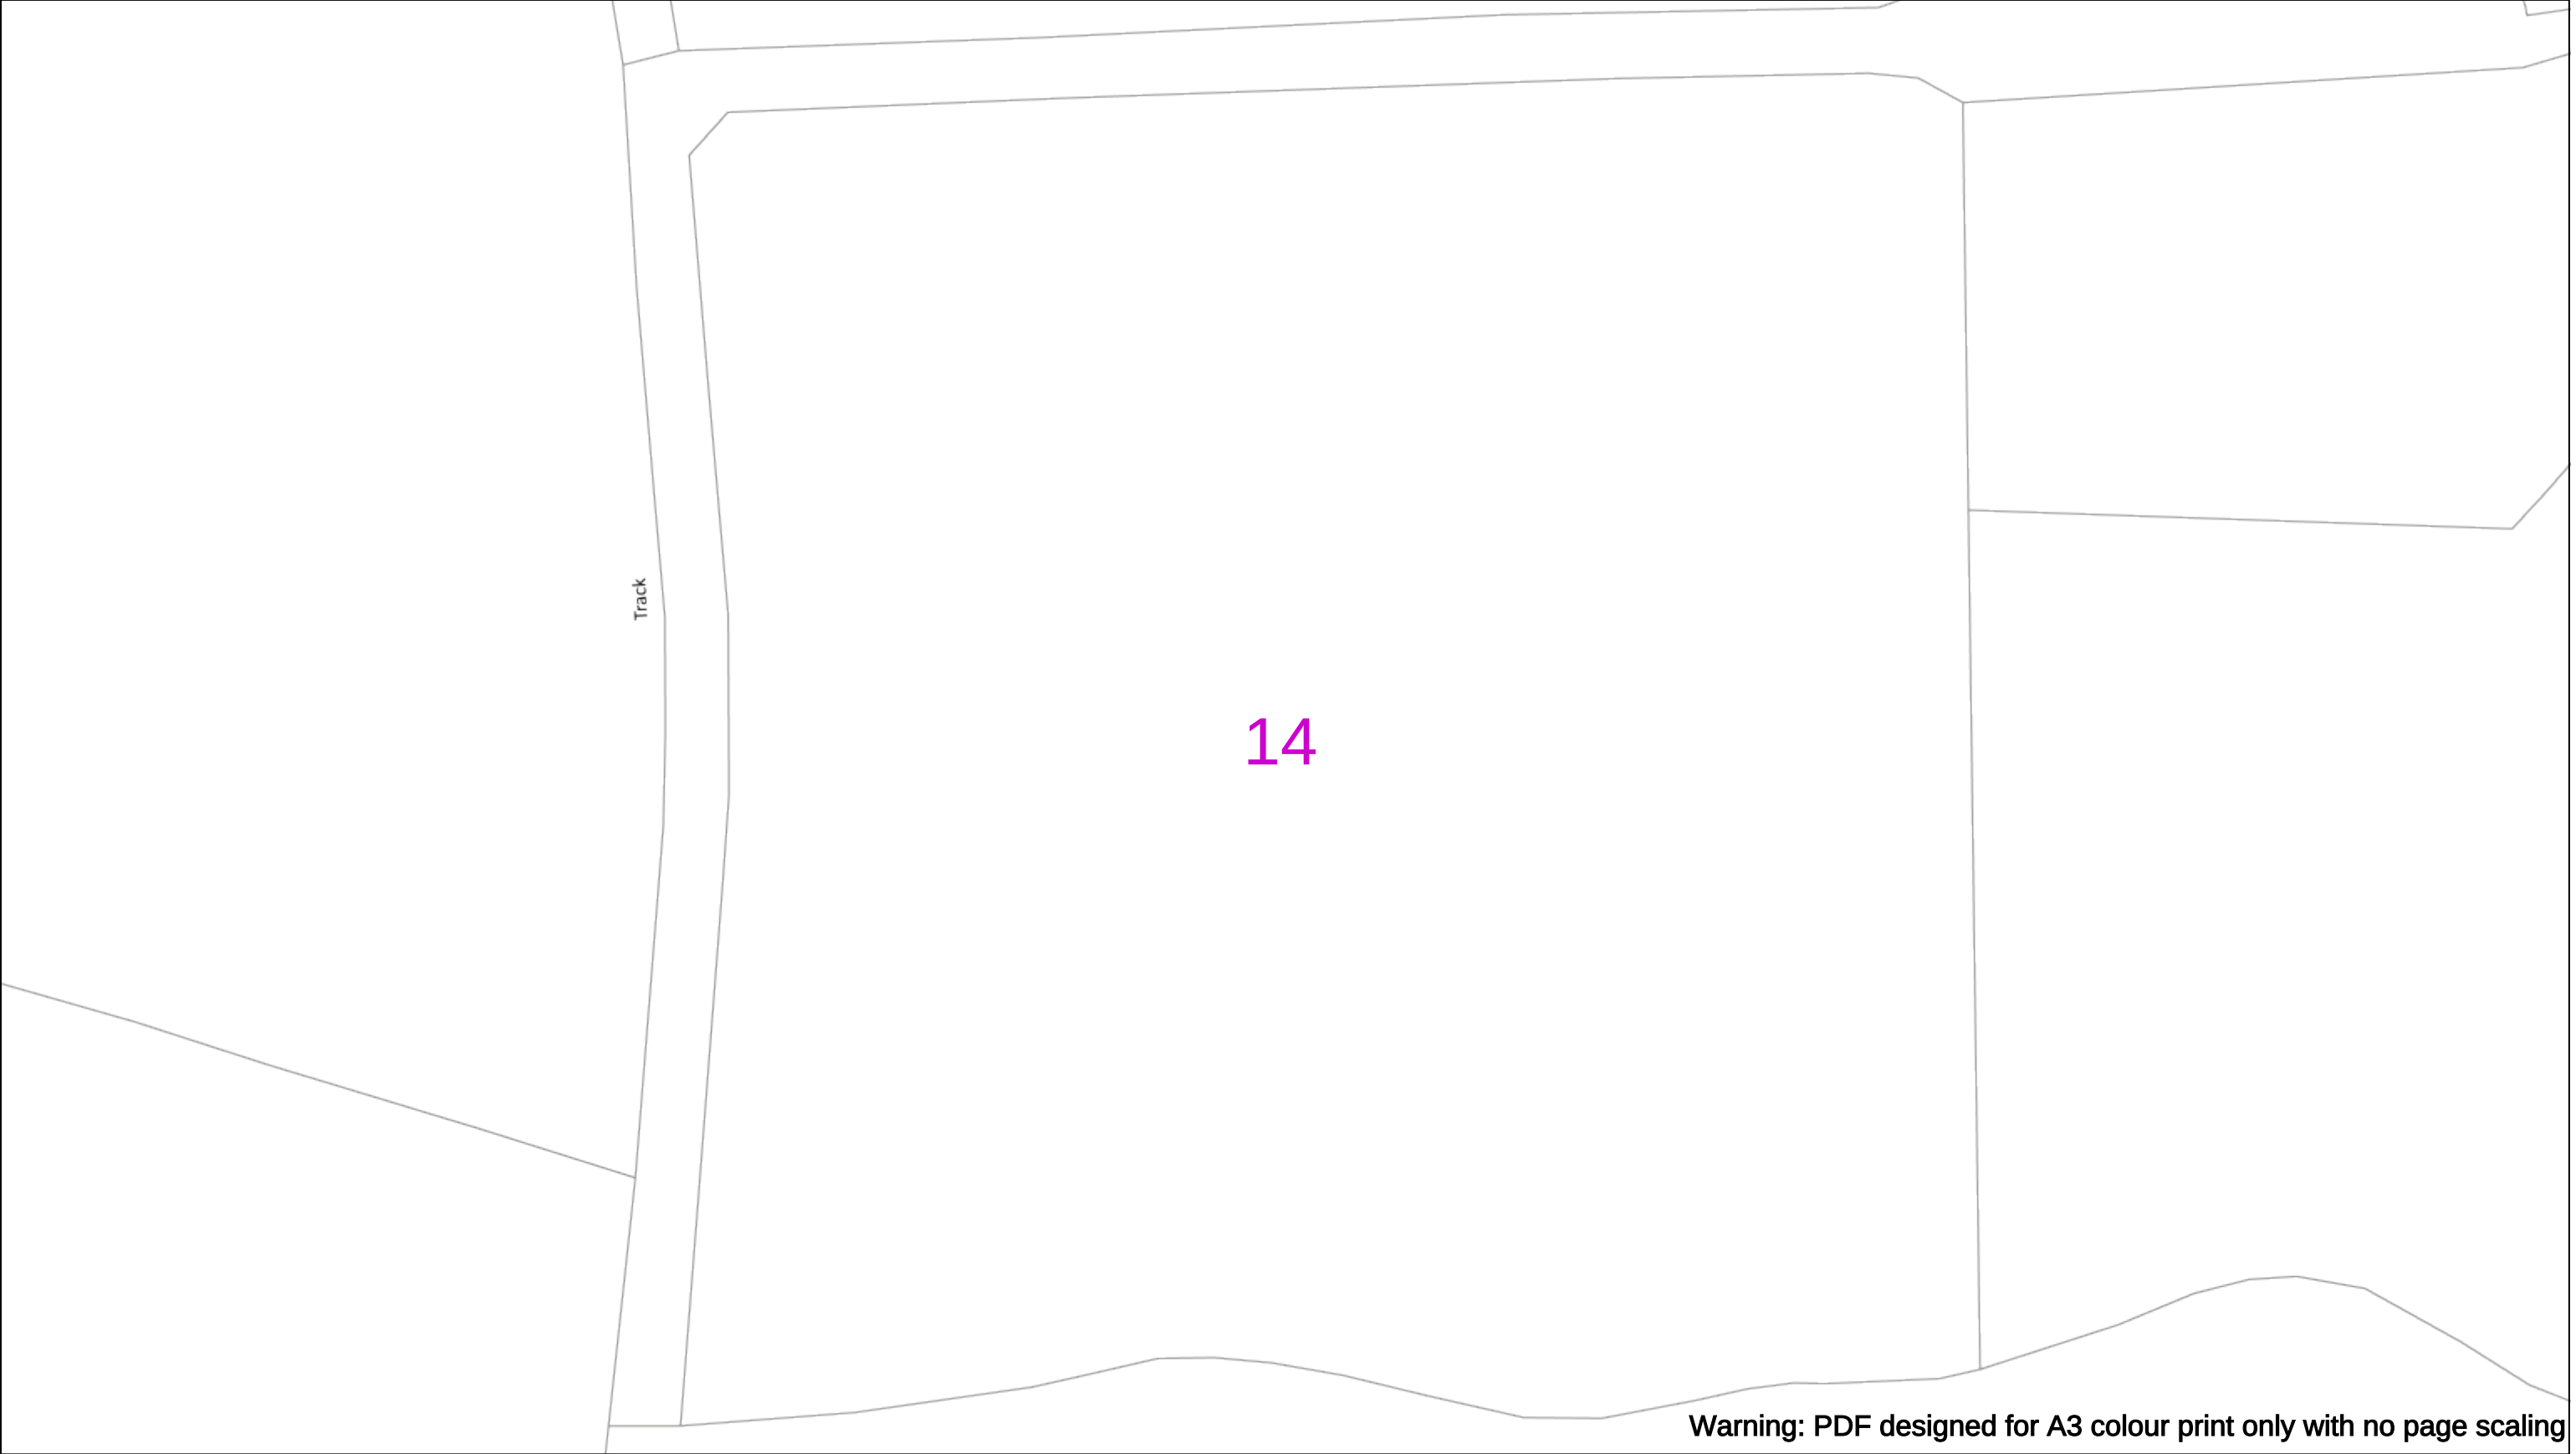

Warning: PDF designed for A3 colour print only with no page scaling

050m

Dig Sites

Area:

Line:

Date Requested: 23/11/2023

Job Reference: 31641913

Site Location: 450687 118647

Requested by:
Ms Debbie Wigston

Your Scheme/Reference: 8230679

WARNING

There may have been subsequent alteration to the surface levels. Trial holes must be undertaken to determine position and depths of cables. HS (G) 47 Booklet from the Health and Safety Executive – Avoiding Danger from Buried Cables – should be consulted before commencing excavation work.

WHEN WORKING IN THE VICINITY OF OVERHEAD LINES THE HEALTH AND SAFETY GUIDANCE NOTES GS6 SHOULD BE CONSULTED (AVAILABLE FROM THE HSE WEBSITE)

Voltages (V)				
LV (Low Voltage) and Services	Up to 1,000V			
HV (High Voltage)	Over 1,000V to 11,000V			
EHV (Extra High Voltage)	22,000V to 132,000V			
Transmission	275,000V and 400,000V			

NORMAL DEPTH TO THE TOP OF THE CABLE WHEN LAID				
	Services	LV	HV	EHV
Footpath/Unmade	0.45m	0.45m	0.6m	0.8m
Road Crossing	0.6m	0.6m	0.75m	0.9m
Agricultural	1m	1m	1m	1.1m

Legend

Service Cable

LV Mains

2 – 3.3kV

6.6kV

11kV

22kV

33kV

66kV

132kV

275kV

400kV

Fibre Optic

Pilot Cable

Distribution Structures (Electric)

Pole, Existing Location

Pole Structure, Existing Location - Single

Pole Structure, Existing Location - H

Duct Route

Cross Section Route

N

E

S

W

Scottish & Southern
Electricity Networks

Southern Electric Power Distribution plc


Registered Office: No.1 Forbury Place
43 Forbury Road Reading RG1 3JH
Registered In England & Wales No.04094290

If you're unsure & need to seek advice before commencing excavations please contact:
General Enquiries: 0800 048 3516

Subject to revision – Master held by SSEN Asset Data Team:
Asset.Data@sse.com
01256 337 294

BASED UPON THE ORDNANCE SURVEY MAP WITH THE SANCTION OF THE CONTROLLER OF THE STATIONERY OFFICE CROWN COPYRIGHT RESERVED.

This copy has been made by or with the authority of Scottish and Southern Energy Power Distribution Ltd. Pursuant to section 47 of the Copyright, Designs and Patents Act 1988 ('The Act'). Unless the Act provides a relevant exception to copyright the copy must not be copied without prior permission of the copyright owner. Plans generated by DigSAFE Pro™ software provided by LinesearchbeforeUdig.

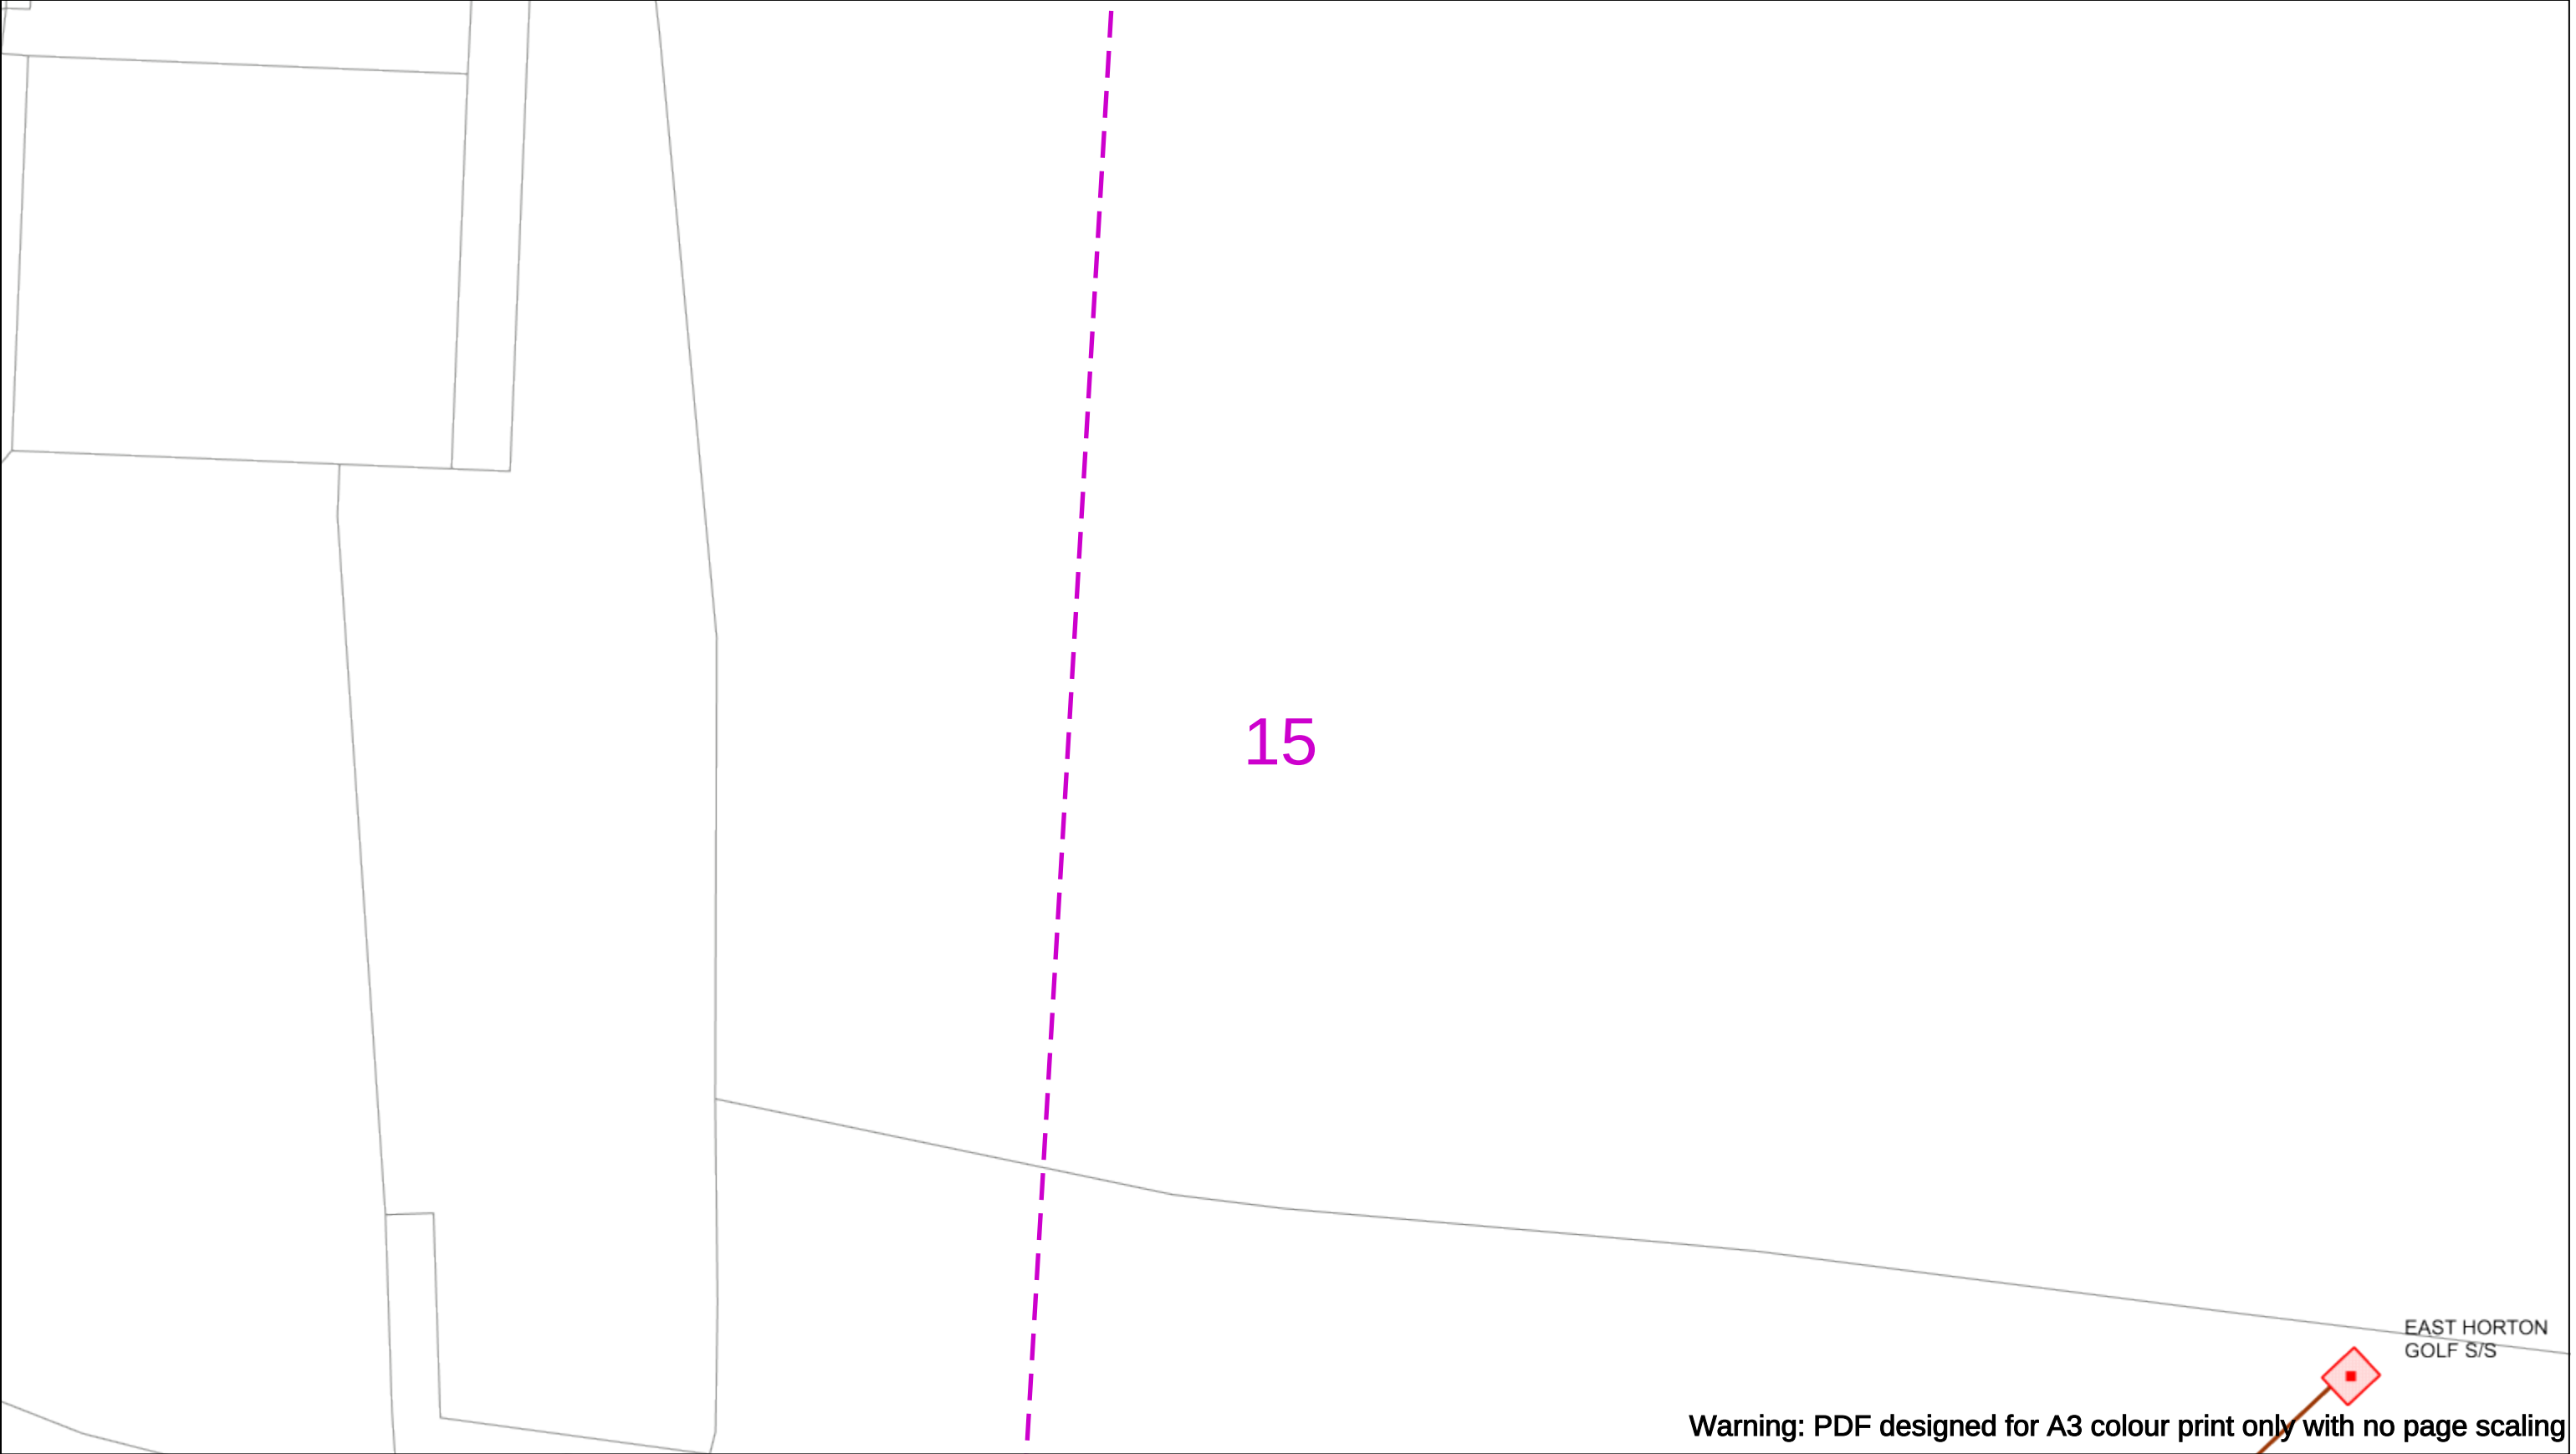

Warning: PDF designed for A3 colour print only with no page scaling

0

50m

Dig Sites

Area:

Line:

Date Requested: 23/11/2023

Job Reference: 31641913

Site Location: 450687 118647

Requested by:
Ms Debbie Wigston

Your Scheme/Reference: 8230679

WARNING

There may have been subsequent alteration to the surface levels. Trial holes must be undertaken to determine position and depths of cables. HS (G) 47 Booklet from the Health and Safety Executive – Avoiding Danger from Buried Cables – should be consulted before commencing excavation work.

WHEN WORKING IN THE VICINITY OF OVERHEAD LINES THE HEALTH AND SAFETY GUIDANCE NOTES GS6 SHOULD BE CONSULTED (AVAILABLE FROM THE HSE WEBSITE)

Voltages (V)				
LV (Low Voltage) and Services	Up to 1,000V			
HV (High Voltage)	Over 1,000V to 11,000V			
EHV (Extra High Voltage)	22,000V to 132,000V			
Transmission	275,000V and 400,000V			

NORMAL DEPTH TO THE TOP OF THE CABLE WHEN LAID				
	Services	LV	HV	EHV
Footpath/Unmade	0.45m	0.45m	0.6m	0.8m
Road Crossing	0.6m	0.6m	0.75m	0.9m
Agricultural	1m	1m	1m	1.1m

Legend

Service Cable

LV Mains

2 – 3.3kV

6.6kV

11kV

22kV

33kV

66kV

132kV

275kV

400kV

Fibre Optic

Pilot Cable

Distribution Structures (Electric)

Pole, Existing Location

Pole Structure, Existing Location - Single

Pole Structure, Existing Location - H

Duct Route

Cross Section Route

N

E

S

W

Scottish & Southern

Electricity Networks

Southern Electric Power Distribution plc

Registered Office: No.1 Forbury Place

43 Forbury Road Reading RG1 3JH

Registered In England & Wales No.04094290

If you're unsure & need to seek advice before commencing excavations please contact:

General Enquiries: 0800 048 3516


Subject to revision – Master held by SSEN Asset Data Team:

Asset.Data@sse.com

01256 337 294

BASED UPON THE ORDNANCE SURVEY MAP WITH THE SANCTION OF THE CONTROLLER OF H.M STATIONERY OFFICE CROWN COPYRIGHT RESERVED.

This copy has been made by or with the authority of Scottish and Southern Energy Power Distribution Ltd. Pursuant to section 47 of the Copyright, Designs and Patents Act 1988 ('The Act'). Unless the Act provides a relevant exception to copyright the copy must not be copied without prior permission of the copyright owner. Plans generated by DigSAFE Pro™ software provided by LinesearchbeforeUdig.

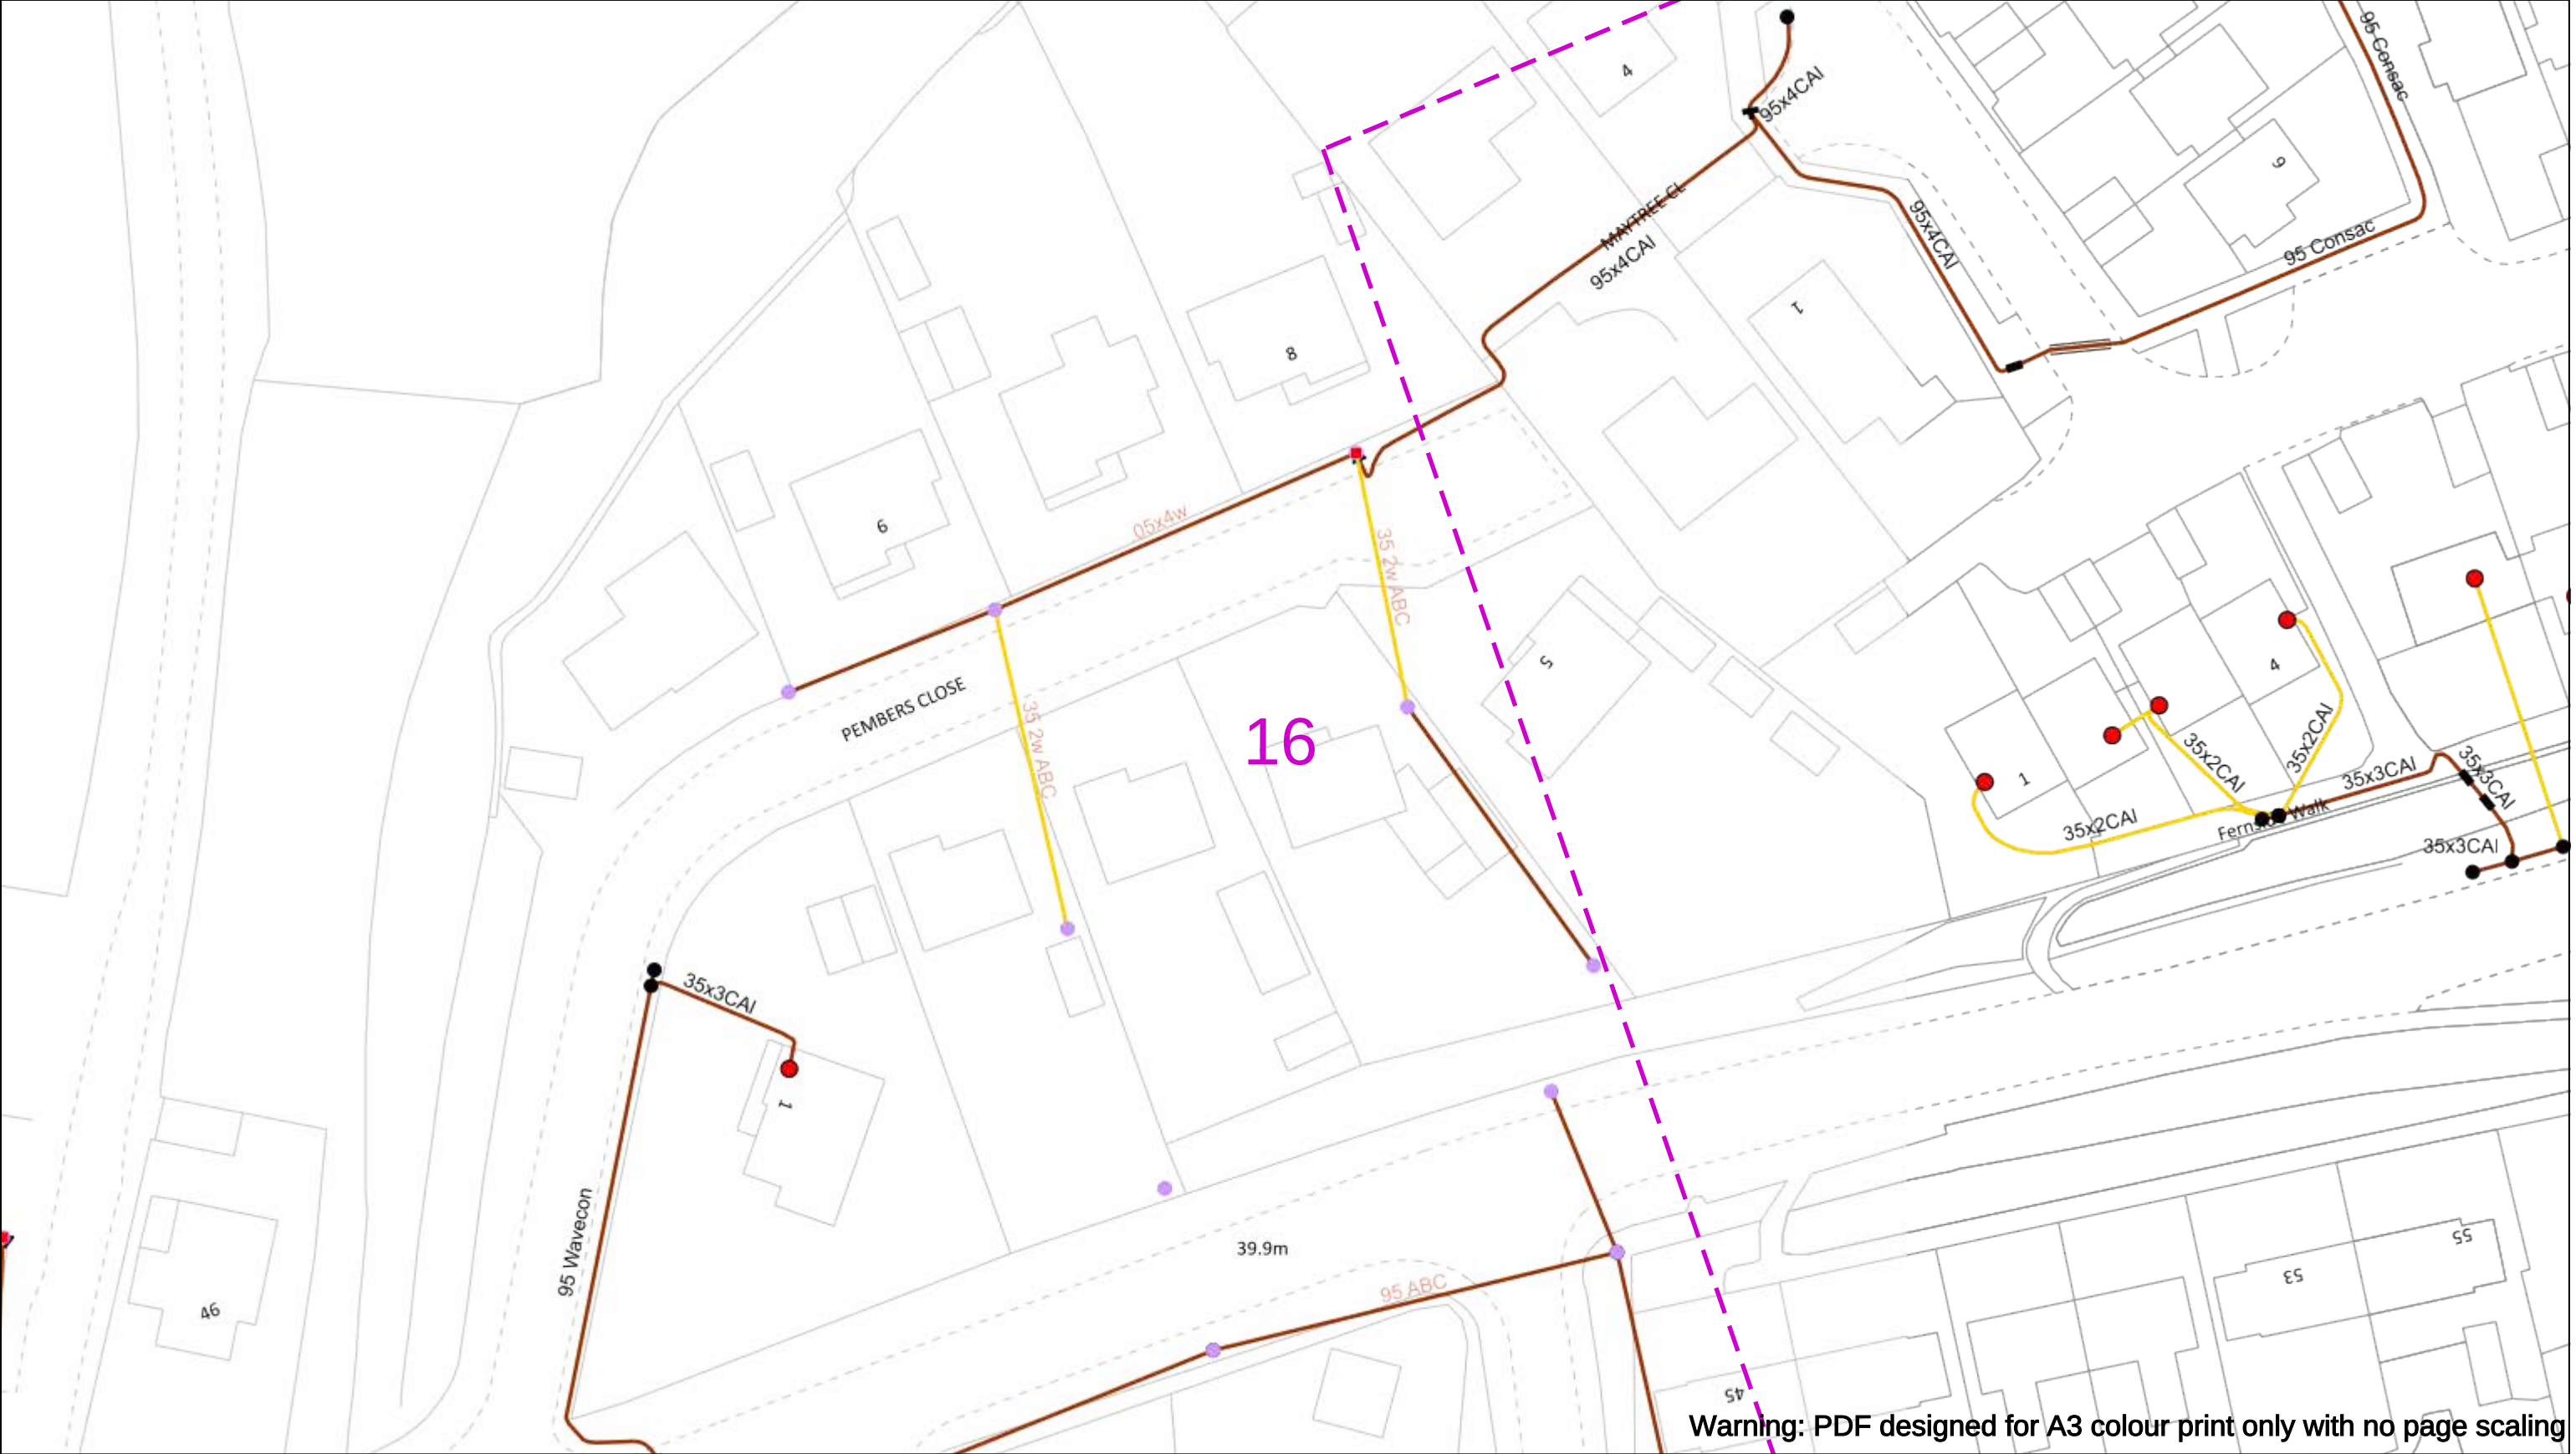

050m

Dig Sites

Area: ----

Line: ----

Date Requested: 23/11/2023

Job Reference: 31641913

Site Location: 450687 118647

Requested by: Ms Debbie Wigston

Your Scheme/Reference: 8230679

WARNING

There may have been subsequent alteration to the surface levels. Trial holes must be undertaken to determine position and depths of cables. HS (G) 47 Booklet from the Health and Safety Executive – Avoiding Danger from Buried Cables – should be consulted before commencing excavation work.

WHEN WORKING IN THE VICINITY OF OVERHEAD LINES THE HEALTH AND SAFETY GUIDANCE NOTES GS6 SHOULD BE CONSULTED (AVAILABLE FROM THE HSE WEBSITE)

	Voltages (V)			
LV (Low Voltage) and Services	Up to 1,000V			
HV (High Voltage)	Over 1,000V to 11,000V			
EHV (Extra High Voltage)	22,000V to 132,000V			
Transmission	275,000V and 400,000V			

	NORMAL DEPTH TO THE TOP OF THE CABLE WHEN LAID			
	Services	LV	HV	EHV
Footpath/Unmade	0.45m	0.45m	0.6m	0.8m
Road Crossing	0.6m	0.6m	0.75m	0.9m
Agricultural	1m	1m	1m	1.1m

Legend

Service Cable

LV Mains

2 – 33kV

66kV

11kV

22kV

33kV

66kV

132kV

275kV

400kV

Fibre Optic

Pilot Cable

Distribution Structures (Electric)

Pole, Existing Location

Pole Structure, Existing Location - Single

Pole Structure, Existing Location - H

Duct Route

Cross Section Route

N

E

S

W

Scottish & Southern Electricity Networks

Southern Electric Power Distribution plc

Registered Office: No.1 Forbury Place

43 Forbury Road Reading RG1 3JH

Registered In England & Wales No.04094290

If you're unsure & need to seek advice before commencing excavations please contact:

General Enquiries: 0800 048 3516

Subject to revision – Master held by SSEN Asset Data Team:


Asset.Data@sse.com

01256 337 294

Scale: 1:500 (When plotted at A3)

BASED UPON THE ORDNANCE SURVEY MAP WITH THE SANCTION OF THE CONTROLLER OF THE STATIONERY OFFICE CROWN COPYRIGHT RESERVED.

This copy has been made by or with the authority of Scottish and Southern Energy Power Distribution Ltd. Pursuant to section 47 of the Copyright, Designs and Patents Act 1988 ('The Act'). Unless the Act provides a relevant exception to copyright the copy must not be copied without prior permission of the copyright owner. Plans generated by DigSAFE Pro™ software provided by LinesearchbeforeUdig.

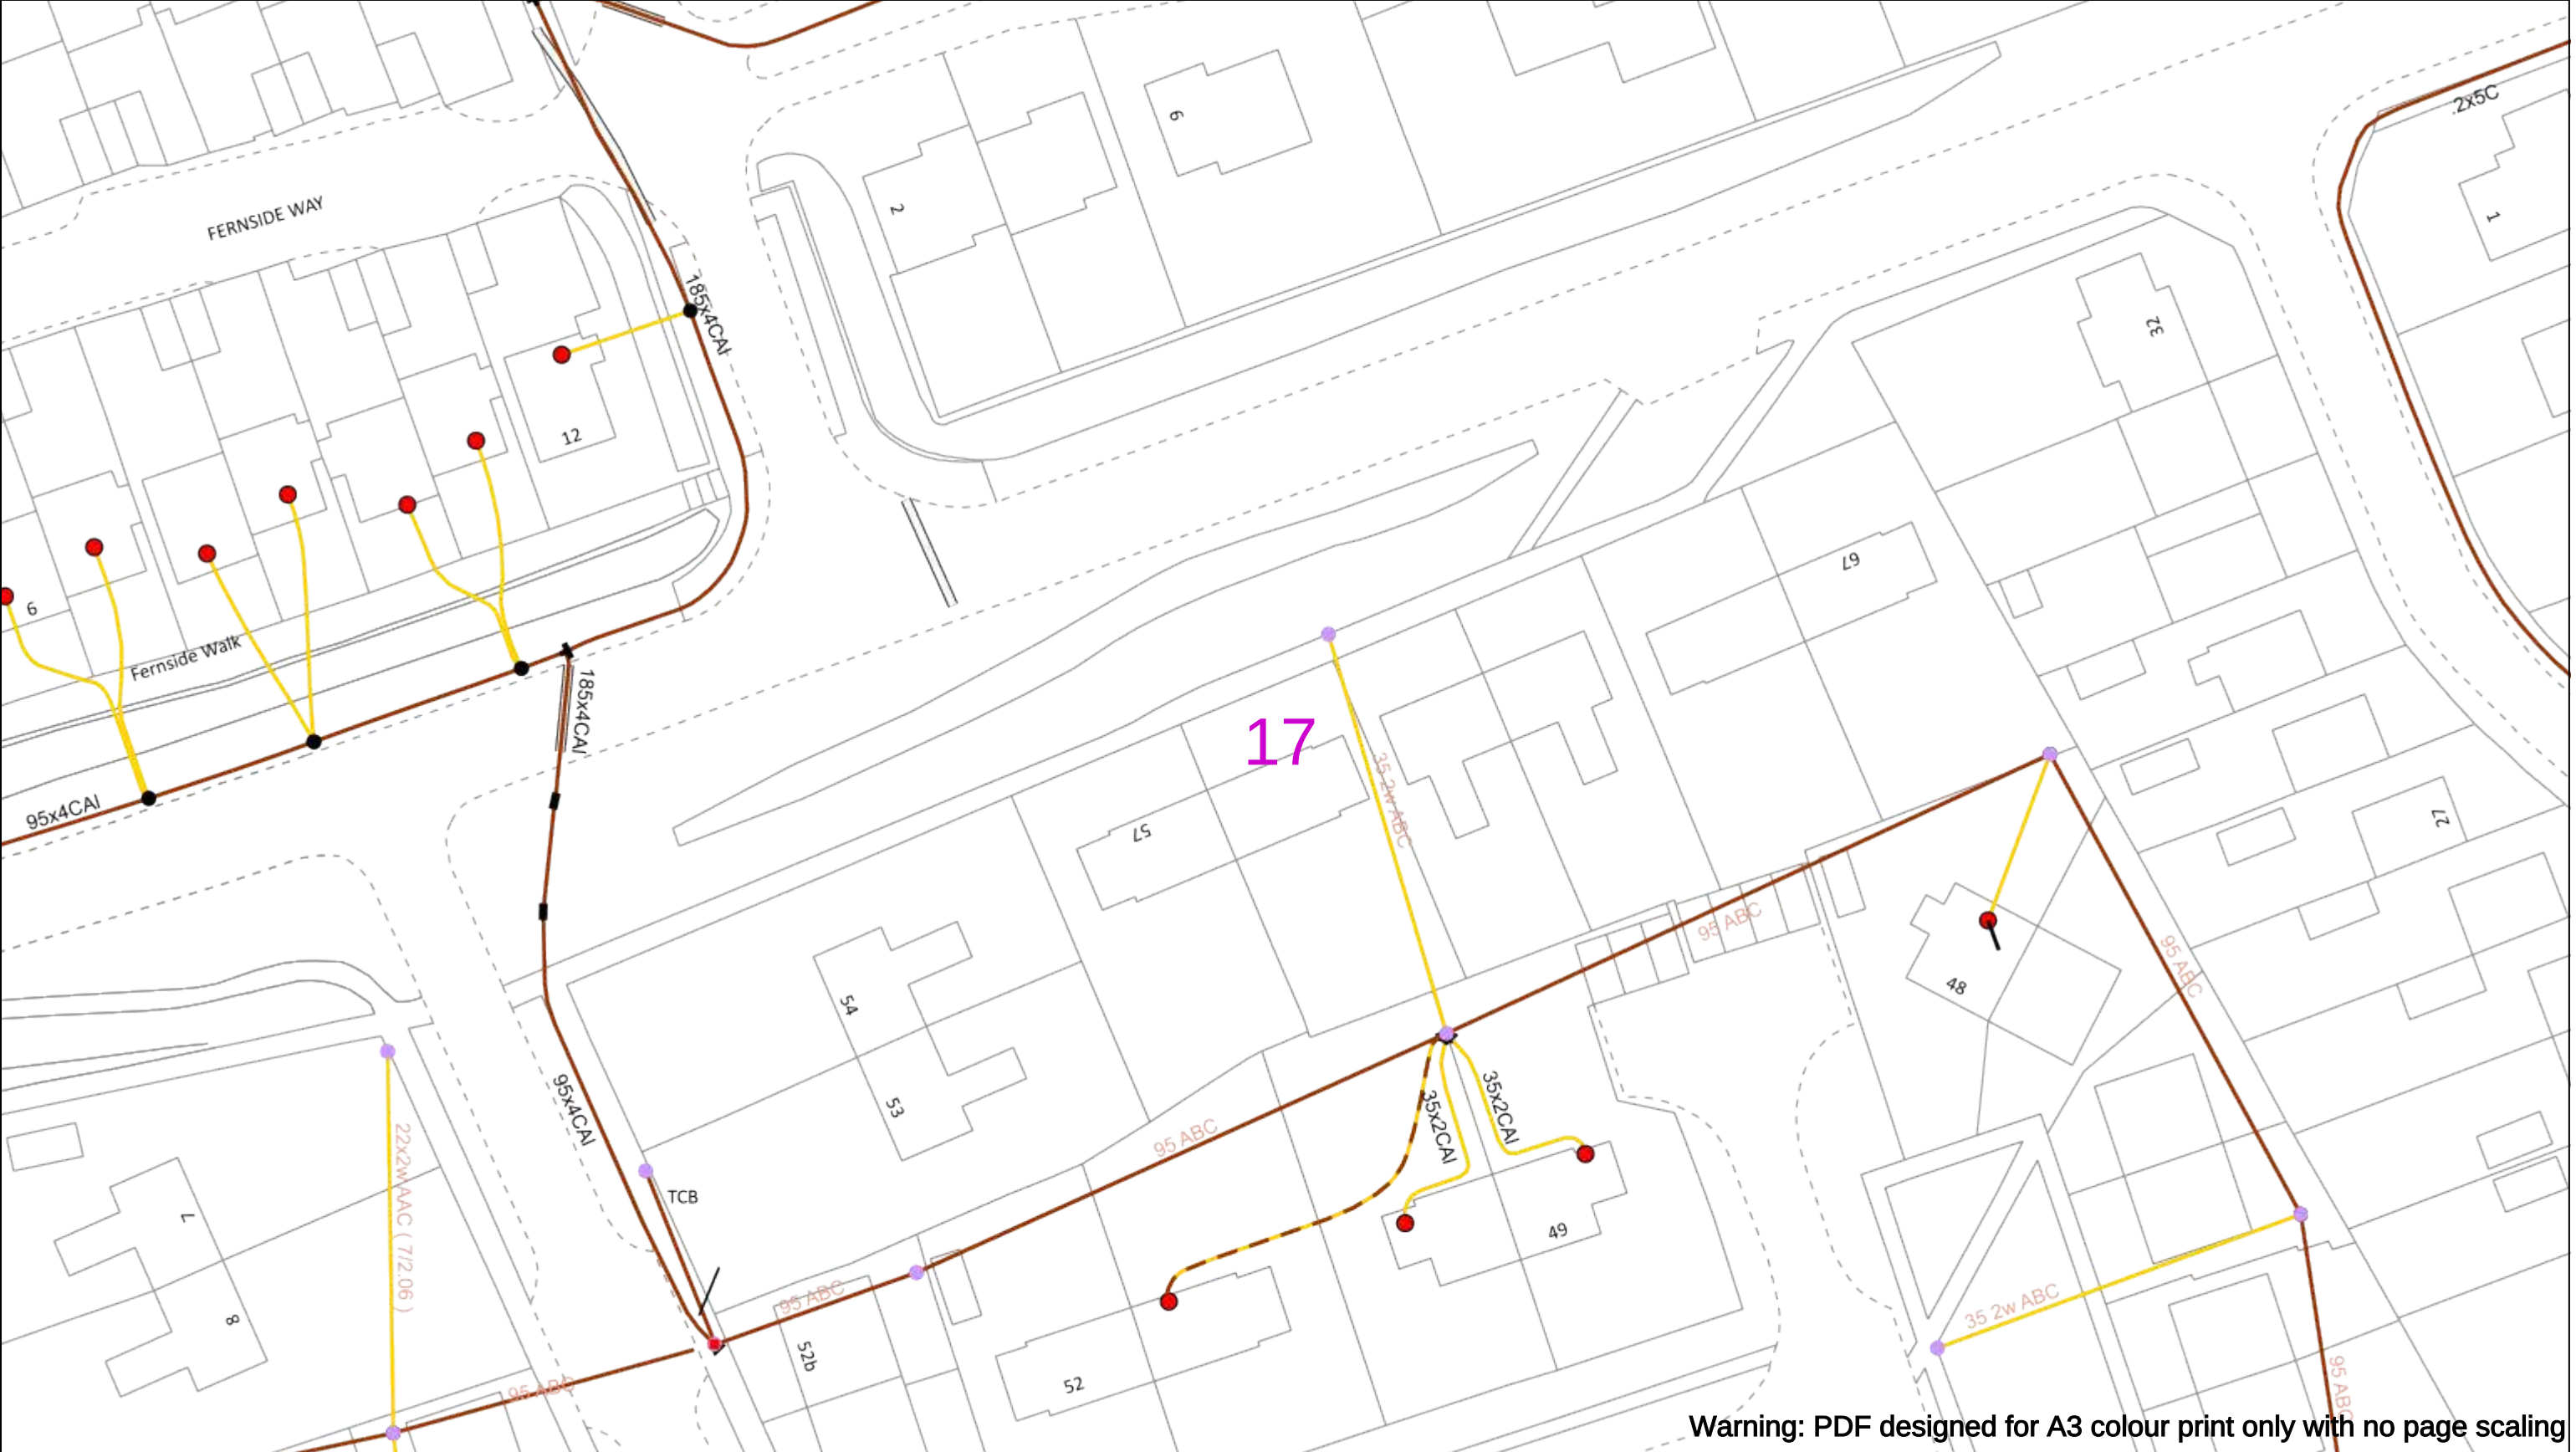

Warning: PDF designed for A3 colour print only with no page scaling

050m

Dig Sites

Area: ----

Line: ----

Date Requested: 23/11/2023

Job Reference: 31641913

Site Location: 450687 118647

Requested by:
Ms Debbie Wigston

Your Scheme/Reference: 8230679

WARNING

There may have been subsequent alteration to the surface levels. Trial holes must be undertaken to determine position and depths of cables. HS (G) 47 Booklet from the Health and Safety Executive – Avoiding Danger from Buried Cables – should be consulted before commencing excavation work.

WHEN WORKING IN THE VICINITY OF OVERHEAD LINES THE HEALTH AND SAFETY GUIDANCE NOTES GS6 SHOULD BE CONSULTED (AVAILABLE FROM THE HSE WEBSITE)

	Voltages (V)			
LV (Low Voltage) and Services	Up to 1,000V			
HV (High Voltage)	Over 1,000V to 11,000V			
EHV (Extra High Voltage)	22,000V to 132,000V			
Transmission	275,000V and 400,000V			

	NORMAL DEPTH TO THE TOP OF THE CABLE WHEN LAID			
	Services	LV	HV	EHV
Footpath/Unmade	0.45m	0.45m	0.6m	0.8m
Road Crossing	0.6m	0.6m	0.75m	0.9m
Agricultural	1m	1m	1m	1.1m

Legend

Service Cable

LV Mains

2 – 3.3kV

6.6kV

11kV

22kV

33kV

66kV

132kV

275kV

400kV

Fibre Optic

Pilot Cable

Distribution Structures (Electric)

Pole, Existing Location

Pole Structure, Existing Location - Single

Pole Structure, Existing Location - H

Duct Route

Cross Section Route

N

E

S

W

Scottish & Southern
Electricity Networks

Southern Electric Power Distribution plc

Registered Office: No.1 Forbury Place

43 Forbury Road Reading RG1 3JH

Registered In England & Wales No.04094290

If you're unsure & need to seek advice before commencing excavations please contact:

General Enquiries: 0800 048 3516


Subject to revision – Master held by SSEN Asset Data Team:

Asset.Data@sse.com

01256 337 294

BASED UPON THE ORDNANCE SURVEY MAP WITH THE SANCTION OF THE CONTROLLER OF H.M STATIONERY OFFICE CROWN COPYRIGHT RESERVED.

This copy has been made by or with the authority of Scottish and Southern Energy Power Distribution Ltd. Pursuant to section 47 of the Copyright, Designs and Patents Act 1988 ('The Act'). Unless the Act provides a relevant exception to copyright the copy must not be copied without prior permission of the copyright owner. Plans generated by DigSAFE Pro™ software provided by LinesearchbeforeUdig.

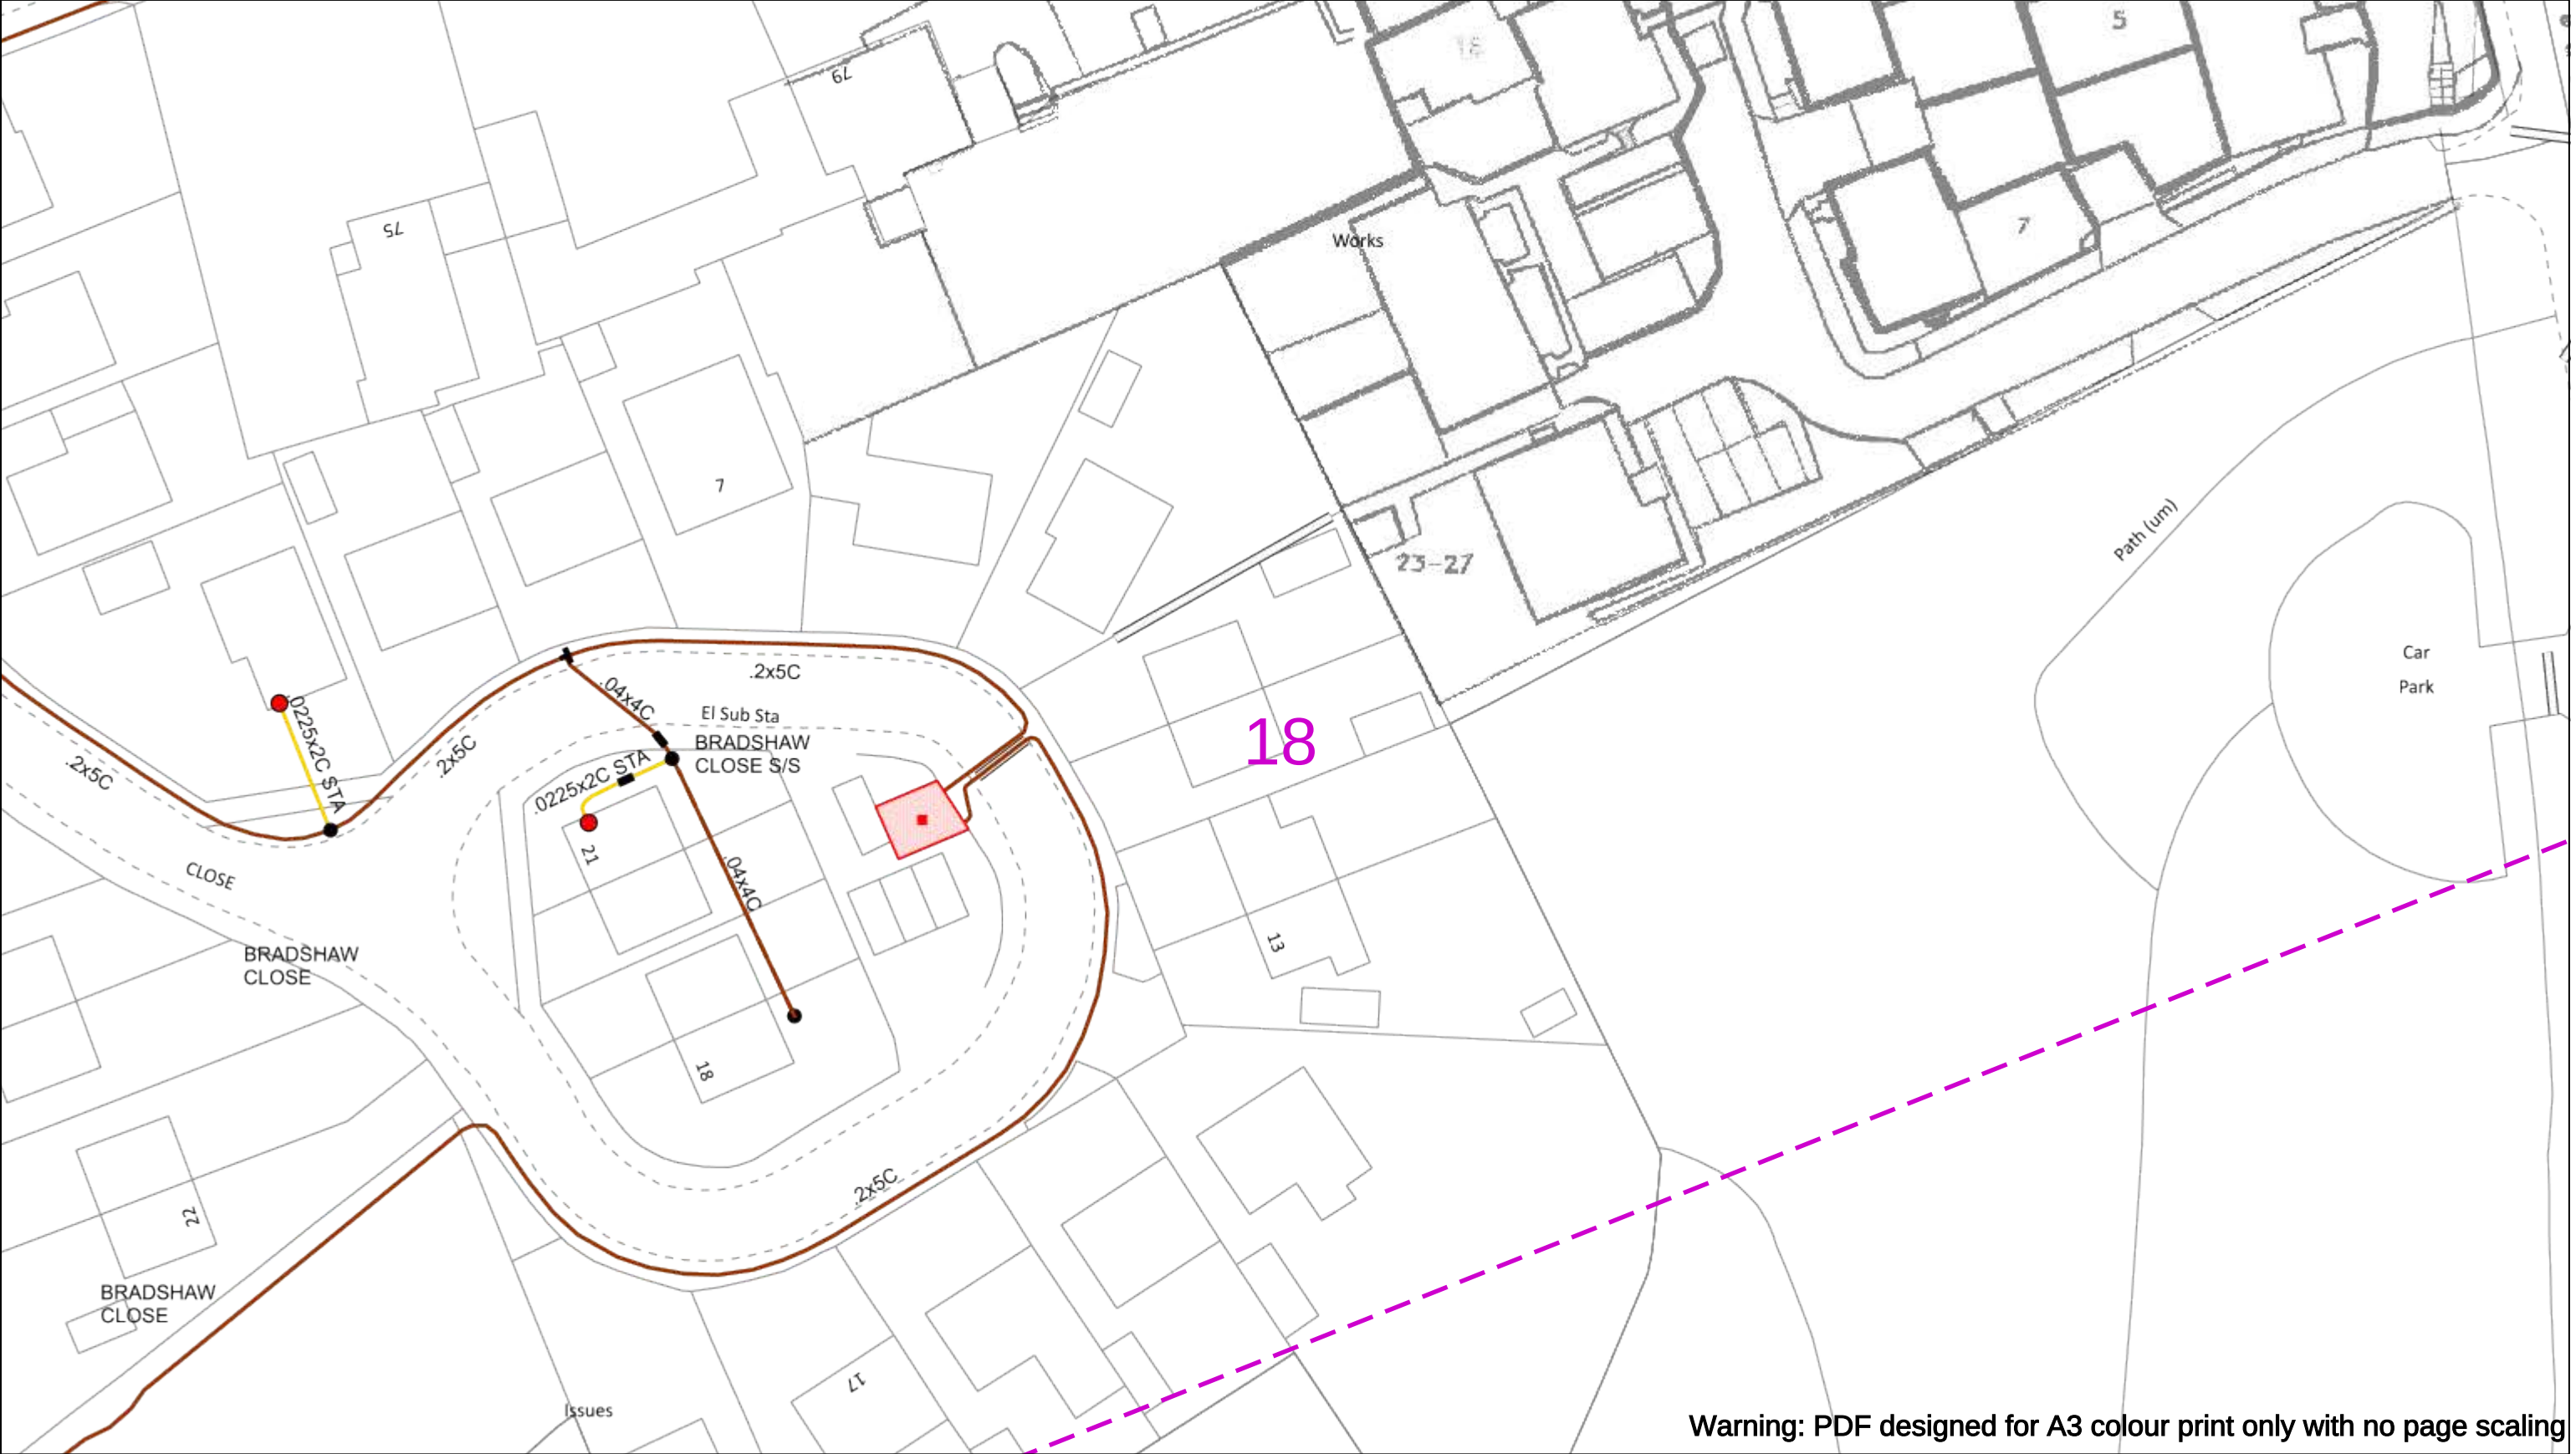

Warning: PDF designed for A3 colour print only with no page scaling

050m

Dig Sites

Area:

Line:

Date Requested: 23/11/2023
Job Reference: 31641913
Site Location: 450687 118647
Requested by:
Ms Debbie Wigston
Your Scheme/Reference: 8230679

WARNING

There may have been subsequent alteration to the surface levels. Trial holes must be undertaken to determine position and depths of cables. HS (G) 47 Booklet from the Health and Safety Executive – Avoiding Danger from Buried Cables – should be consulted before commencing excavation work.

WHEN WORKING IN THE VICINITY OF OVERHEAD LINES THE HEALTH AND SAFETY GUIDANCE NOTES GS6 SHOULD BE CONSULTED (AVAILABLE FROM THE HSE WEBSITE)

Scale: 1:500 (When plotted at A3)

Voltages (V)				
LV (Low Voltage) and Services	Up to 1,000V			
HV (High Voltage)	Over 1,000V to 11,000V			
EHV (Extra High Voltage)	22,000V to 132,000V			
Transmission	275,000V and 400,000V			

NORMAL DEPTH TO THE TOP OF THE CABLE WHEN LAID				
	Services	LV	HV	EHV
Footpath/Unmade	0.45m	0.45m	0.6m	0.8m
Road Crossing	0.6m	0.6m	0.75m	0.9m
Agricultural	1m	1m	1m	1.1m

Legend

Service Cable

LV Mains

2 – 3.3kV

6.6kV

11kV

22kV

33kV

66kV

132kV

275kV

400kV

Fibre Optic

Pilot Cable

Distribution Structures (Electric)

Pole, Existing Location

Pole Structure, Existing Location - Single

Pole Structure, Existing Location - H

Duct Route

Cross Section Route

N

E

S

W

Scottish & Southern

Electricity Networks

Southern Electric Power Distribution plc

Registered Office: No.1 Forbury Place

43 Forbury Road Reading RG1 3JH

Registered In England & Wales No.04094290

If you're unsure & need to seek advice before commencing excavations please contact:

General Enquiries: 0800 048 3516


Subject to revision – Master held by SSEN Asset Data Team:

Asset.Data@sse.com

01256 337 294

BASED UPON THE ORDNANCE SURVEY MAP WITH THE SANCTION OF THE CONTROLLER OF H.M STATIONERY OFFICE CROWN COPYRIGHT RESERVED.

This copy has been made by or with the authority of Scottish and Southern Energy Power Distribution Ltd. Pursuant to section 47 of the Copyright, Designs and Patents Act 1988 ('The Act'). Unless the Act provides a relevant exception to copyright the copy must not be copied without prior permission of the copyright owner. Plans generated by DigSAFE Pro™ software provided by LinesearchbeforeUdig.

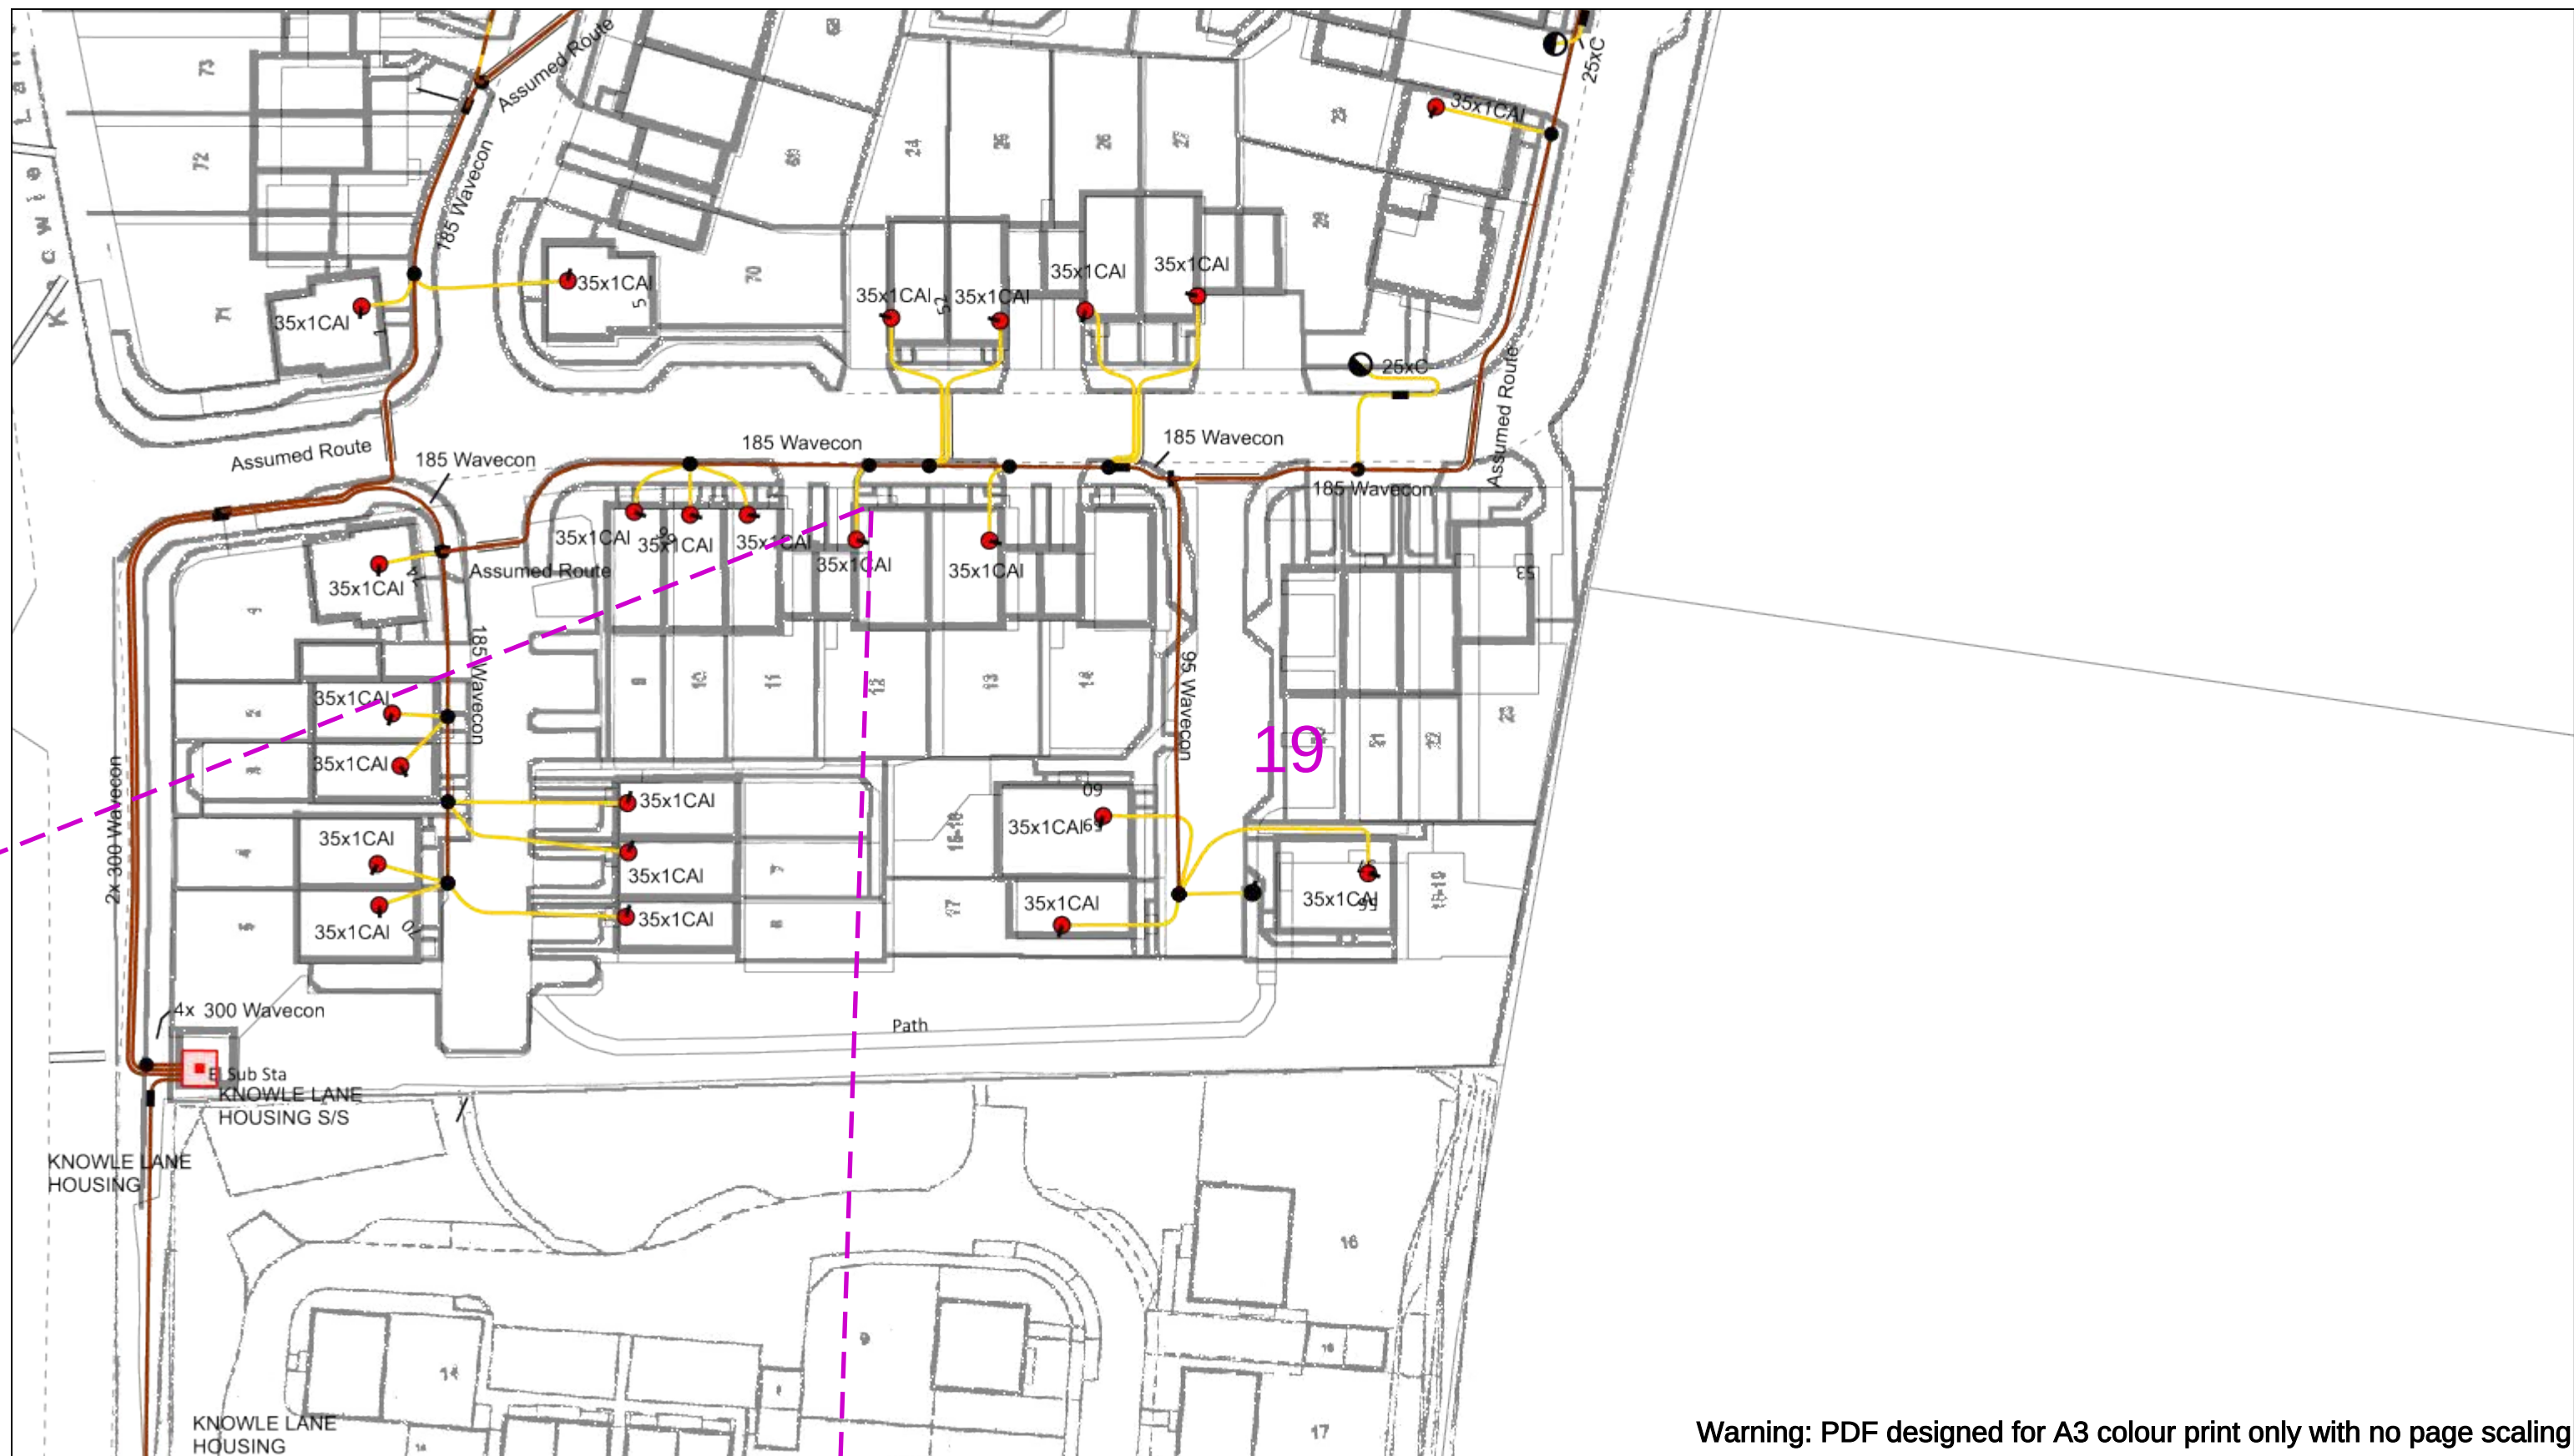

Warning: PDF designed for A3 colour print only with no page scaling



Dig Sites Area:  Line: 

Date Requested: 23/11/2023
Job Reference: 31641913
Site Location: 450687 118647
Requested by: Ms Debbie Wigston
Your Scheme/Reference: 8230679

WARNING

There may have been subsequent alteration to the surface levels. Trial holes must be undertaken to determine position and depths of cables. HS (G) 47 Booklet from the Health and Safety Executive – Avoiding Danger from Buried Cables – should be consulted before commencing excavation work.

WHEN WORKING IN THE VICINITY OF OVERHEAD LINES THE HEALTH AND SAFETY GUIDANCE NOTES GS6 SHOULD BE CONSULTED (AVAILABLE FROM THE HSE WEBSITE)

Scale: 1:500 (When plotted at A3)

Voltages (V)				
LV (Low Voltage) and Services		Up to 1,000V		
HV (High Voltage)		Over 1,000V to 11,000V		
EHV (Extra High Voltage)		22,000V to 132,000V		
Transmission		275,000V and 400,000V		
NORMAL DEPTH TO THE TOP OF THE CABLE WHEN LAID				
	Services	LV	HV	EHV
Footpath/Unmade	0.45m	0.45m	0.6m	0.9m
Road Crossing	0.6m	0.6m	0.75m	0.9m
Agricultural	1m	1m	1m	1.2m

Legend

- Service Cable
- LV Mains
- 2 – 3.3kV
- 6.6kV
- 11kV
- 22kV
- 33kV
- 66kV
- 132kV
- 275kV
- 400kV
- Fibre Optic
- Pilot Cable

Distribution Structures (Electric)

-  Pole, Existing Location
-  Pole Structure, Existing Location - Single
-  Pole Structure, Existing Location - H
- Duct Route
- Cross Section Route



Southern Electric Power Distribution plc
Registered Office: No.1 Forbury Place
43 Forbury Road Reading RG1 3JH
Registered In England & Wales No.04094290

If you're unsure & need to seek advice before commencing excavations please contact:
General Enquiries: 0800 048 3516

Subject to revision – Master held by SSEN Asset Data Team:
Asset.Data@sse.com
 01256 337 294

This copy has been made by or with the authority of Scottish and Southern Energy Power Distribution Ltd. Pursuant to section 47 of the Copyright, Designs and Patents Act 1988 ('The Act'). Unless the Act provides a relevant exception to copyright the copy must not be copied without prior permission of the copyright owner. Plans generated by DigSAFE Pro™ software provided by LinesearchbeforeUdig.

Warning: PDF designed for A3 colour print only with no page scaling

050m

Dig Sites

Area:

Line:

Date Requested: 23/11/2023

Job Reference: 31641913

Site Location: 450687 118647

Requested by:
Ms Debbie Wigston

Your Scheme/Reference: 8230679

WARNING

There may have been subsequent alteration to the surface levels. Trial holes must be undertaken to determine position and depths of cables. HS (G) 47 Booklet from the Health and Safety Executive – Avoiding Danger from Buried Cables – should be consulted before commencing excavation work.

WHEN WORKING IN THE VICINITY OF OVERHEAD LINES THE HEALTH AND SAFETY GUIDANCE NOTES GS6 SHOULD BE CONSULTED (AVAILABLE FROM THE HSE WEBSITE)

Voltages (V)				
LV (Low Voltage) and Services	Up to 1,000V			
HV (High Voltage)	Over 1,000V to 11,000V			
EHV (Extra High Voltage)	22,000V to 132,000V			
Transmission	275,000V and 400,000V			

NORMAL DEPTH TO THE TOP OF THE CABLE WHEN LAID				
	Services	LV	HV	EHV
Footpath/Unmade	0.45m	0.45m	0.6m	0.8m
Road Crossing	0.6m	0.6m	0.75m	0.9m
Agricultural	1m	1m	1m	1.1m

Legend

Service Cable

LV Mains

2 – 3.3kV

6.6kV

11kV

22kV

33kV

66kV

132kV

275kV

400kV

Fibre Optic

Pilot Cable

Distribution Structures (Electric)

Pole, Existing Location

Pole Structure, Existing Location - Single

Pole Structure, Existing Location - H

Duct Route

Cross Section Route

N

E

S

W

Scottish & Southern

Electricity Networks

Southern Electric Power Distribution plc

Registered Office: No.1 Forbury Place

43 Forbury Road Reading RG1 3JH

Registered In England & Wales No.04094290

If you're unsure & need to seek advice before commencing excavations please contact:

General Enquiries: 0800 048 3516


Subject to revision – Master held by SSEN Asset Data Team:

Asset.Data@sse.com

01256 337 294

BASED UPON THE ORDNANCE SURVEY MAP WITH THE SANCTION OF THE CONTROLLER OF H.M STATIONERY OFFICE CROWN COPYRIGHT RESERVED.

This copy has been made by or with the authority of Scottish and Southern Energy Power Distribution Ltd. Pursuant to section 47 of the Copyright, Designs and Patents Act 1988 ('The Act'). Unless the Act provides a relevant exception to copyright the copy must not be copied without prior permission of the copyright owner. Plans generated by DigSAFE Pro™ software provided by LinesearchbeforeUdig.

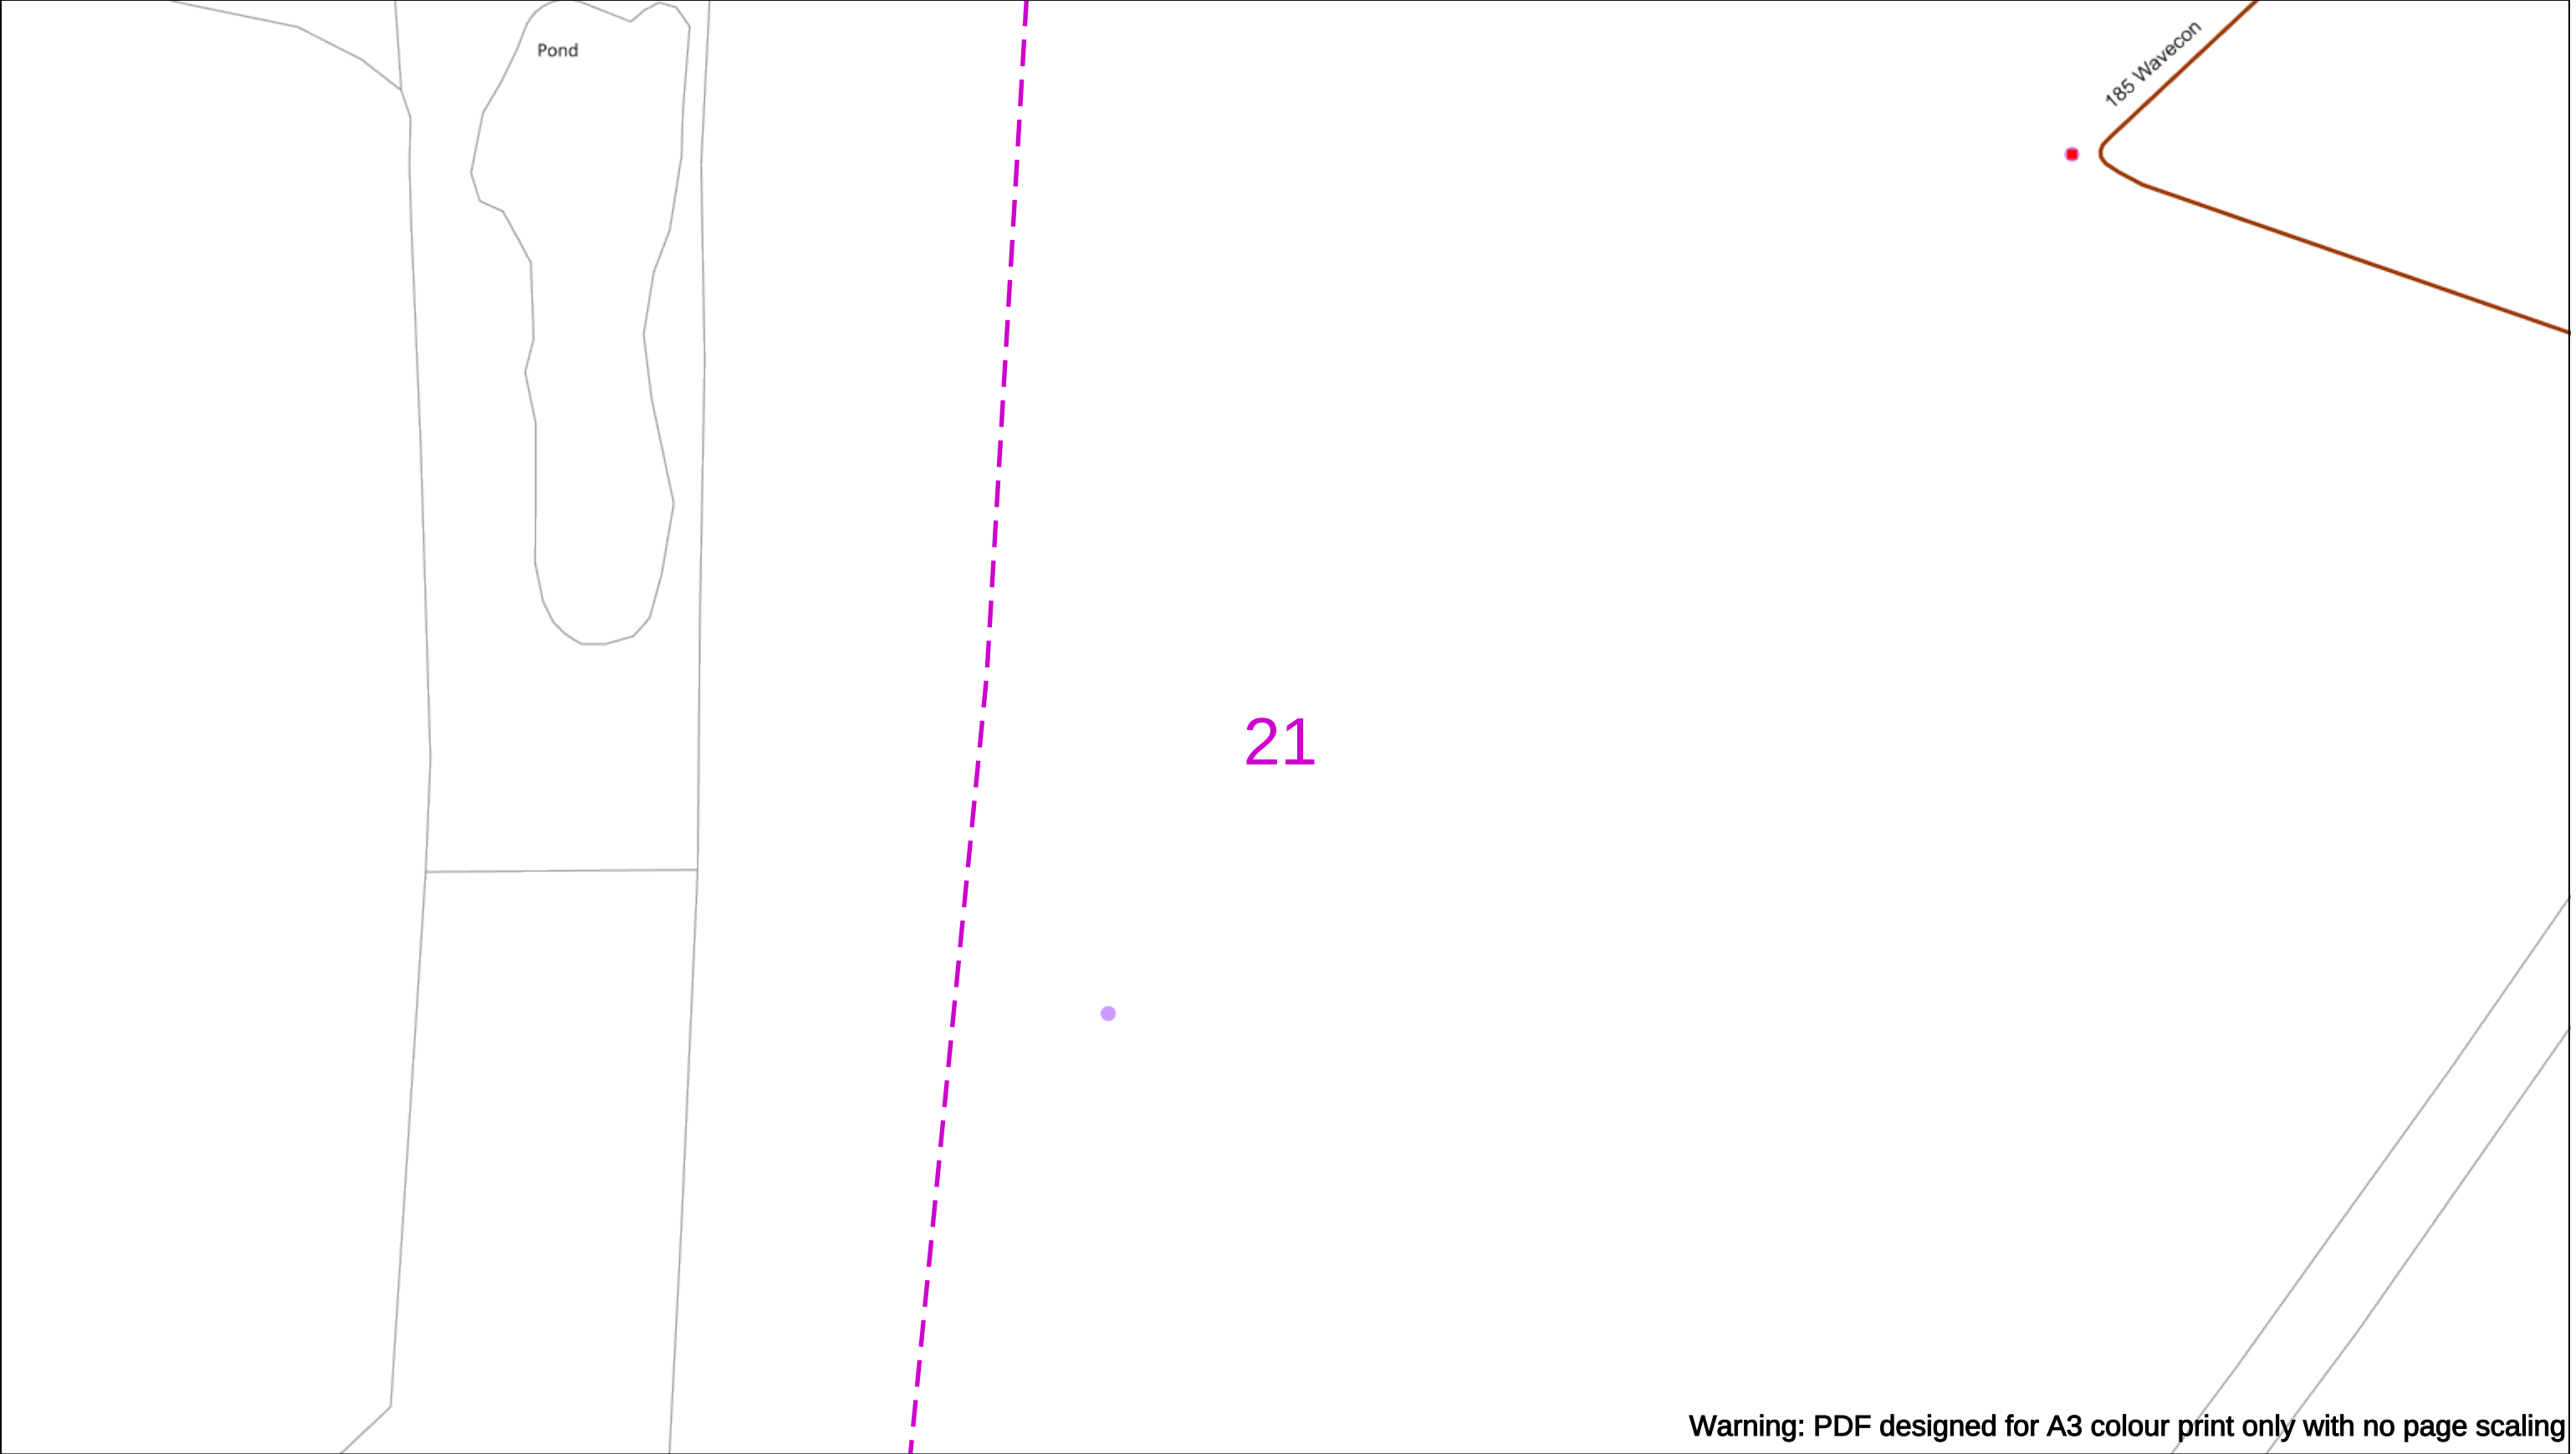

Warning: PDF designed for A3 colour print only with no page scaling

050m

Dig Sites

Area:

Line:

Date Requested: 23/11/2023

Job Reference: 31641913

Site Location: 450687 118647

Requested by:
Ms Debbie Wigston

Your Scheme/Reference: 8230679

WARNING

There may have been subsequent alteration to the surface levels. Trial holes must be undertaken to determine position and depths of cables. HS (G) 47 Booklet from the Health and Safety Executive – Avoiding Danger from Buried Cables – should be consulted before commencing excavation work.

WHEN WORKING IN THE VICINITY OF OVERHEAD LINES THE HEALTH AND SAFETY GUIDANCE NOTES GS6 SHOULD BE CONSULTED (AVAILABLE FROM THE HSE WEBSITE)

Voltages (V)				
LV (Low Voltage) and Services	Up to 1,000V			
HV (High Voltage)	Over 1,000V to 11,000V			
EHV (Extra High Voltage)	22,000V to 132,000V			
Transmission	275,000V and 400,000V			

NORMAL DEPTH TO THE TOP OF THE CABLE WHEN LAID				
	Services	LV	HV	EHV
Footpath/Unmade	0.45m	0.45m	0.6m	0.8m
Road Crossing	0.6m	0.6m	0.75m	0.9m
Agricultural	1m	1m	1m	1.1m

Legend

Service Cable

LV Mains

2 – 3.3kV

6.6kV

11kV

22kV

33kV

66kV

132kV

275kV

400kV

Fibre Optic

Pilot Cable

Distribution Structures (Electric)

Pole, Existing Location

Pole Structure, Existing Location - Single

Pole Structure, Existing Location - H

Duct Route

Cross Section Route

N

E

S

W

Scottish & Southern
Electricity Networks

Southern Electric Power Distribution plc

Registered Office: No.1 Forbury Place
43 Forbury Road Reading RG1 3JH
Registered In England & Wales No.04094290


If you're unsure & need to seek advice before commencing excavations please contact:
General Enquiries: 0800 048 3516

Subject to revision – Master held by SSEN Asset Data Team:
Asset.Data@sse.com
01256 337 294

Scale: 1:500 (When plotted at A3)

BASED UPON THE ORDNANCE SURVEY MAP WITH THE SANCTION OF THE CONTROLLER OF H.M STATIONERY OFFICE CROWN COPYRIGHT RESERVED.

This copy has been made by or with the authority of Scottish and Southern Energy Power Distribution Ltd. Pursuant to section 47 of the Copyright, Designs and Patents Act 1988 ('The Act'). Unless the Act provides a relevant exception to copyright the copy must not be copied without prior permission of the copyright owner. Plans generated by DigSAFE Pro™ software provided by LinesearchbeforeUdig.

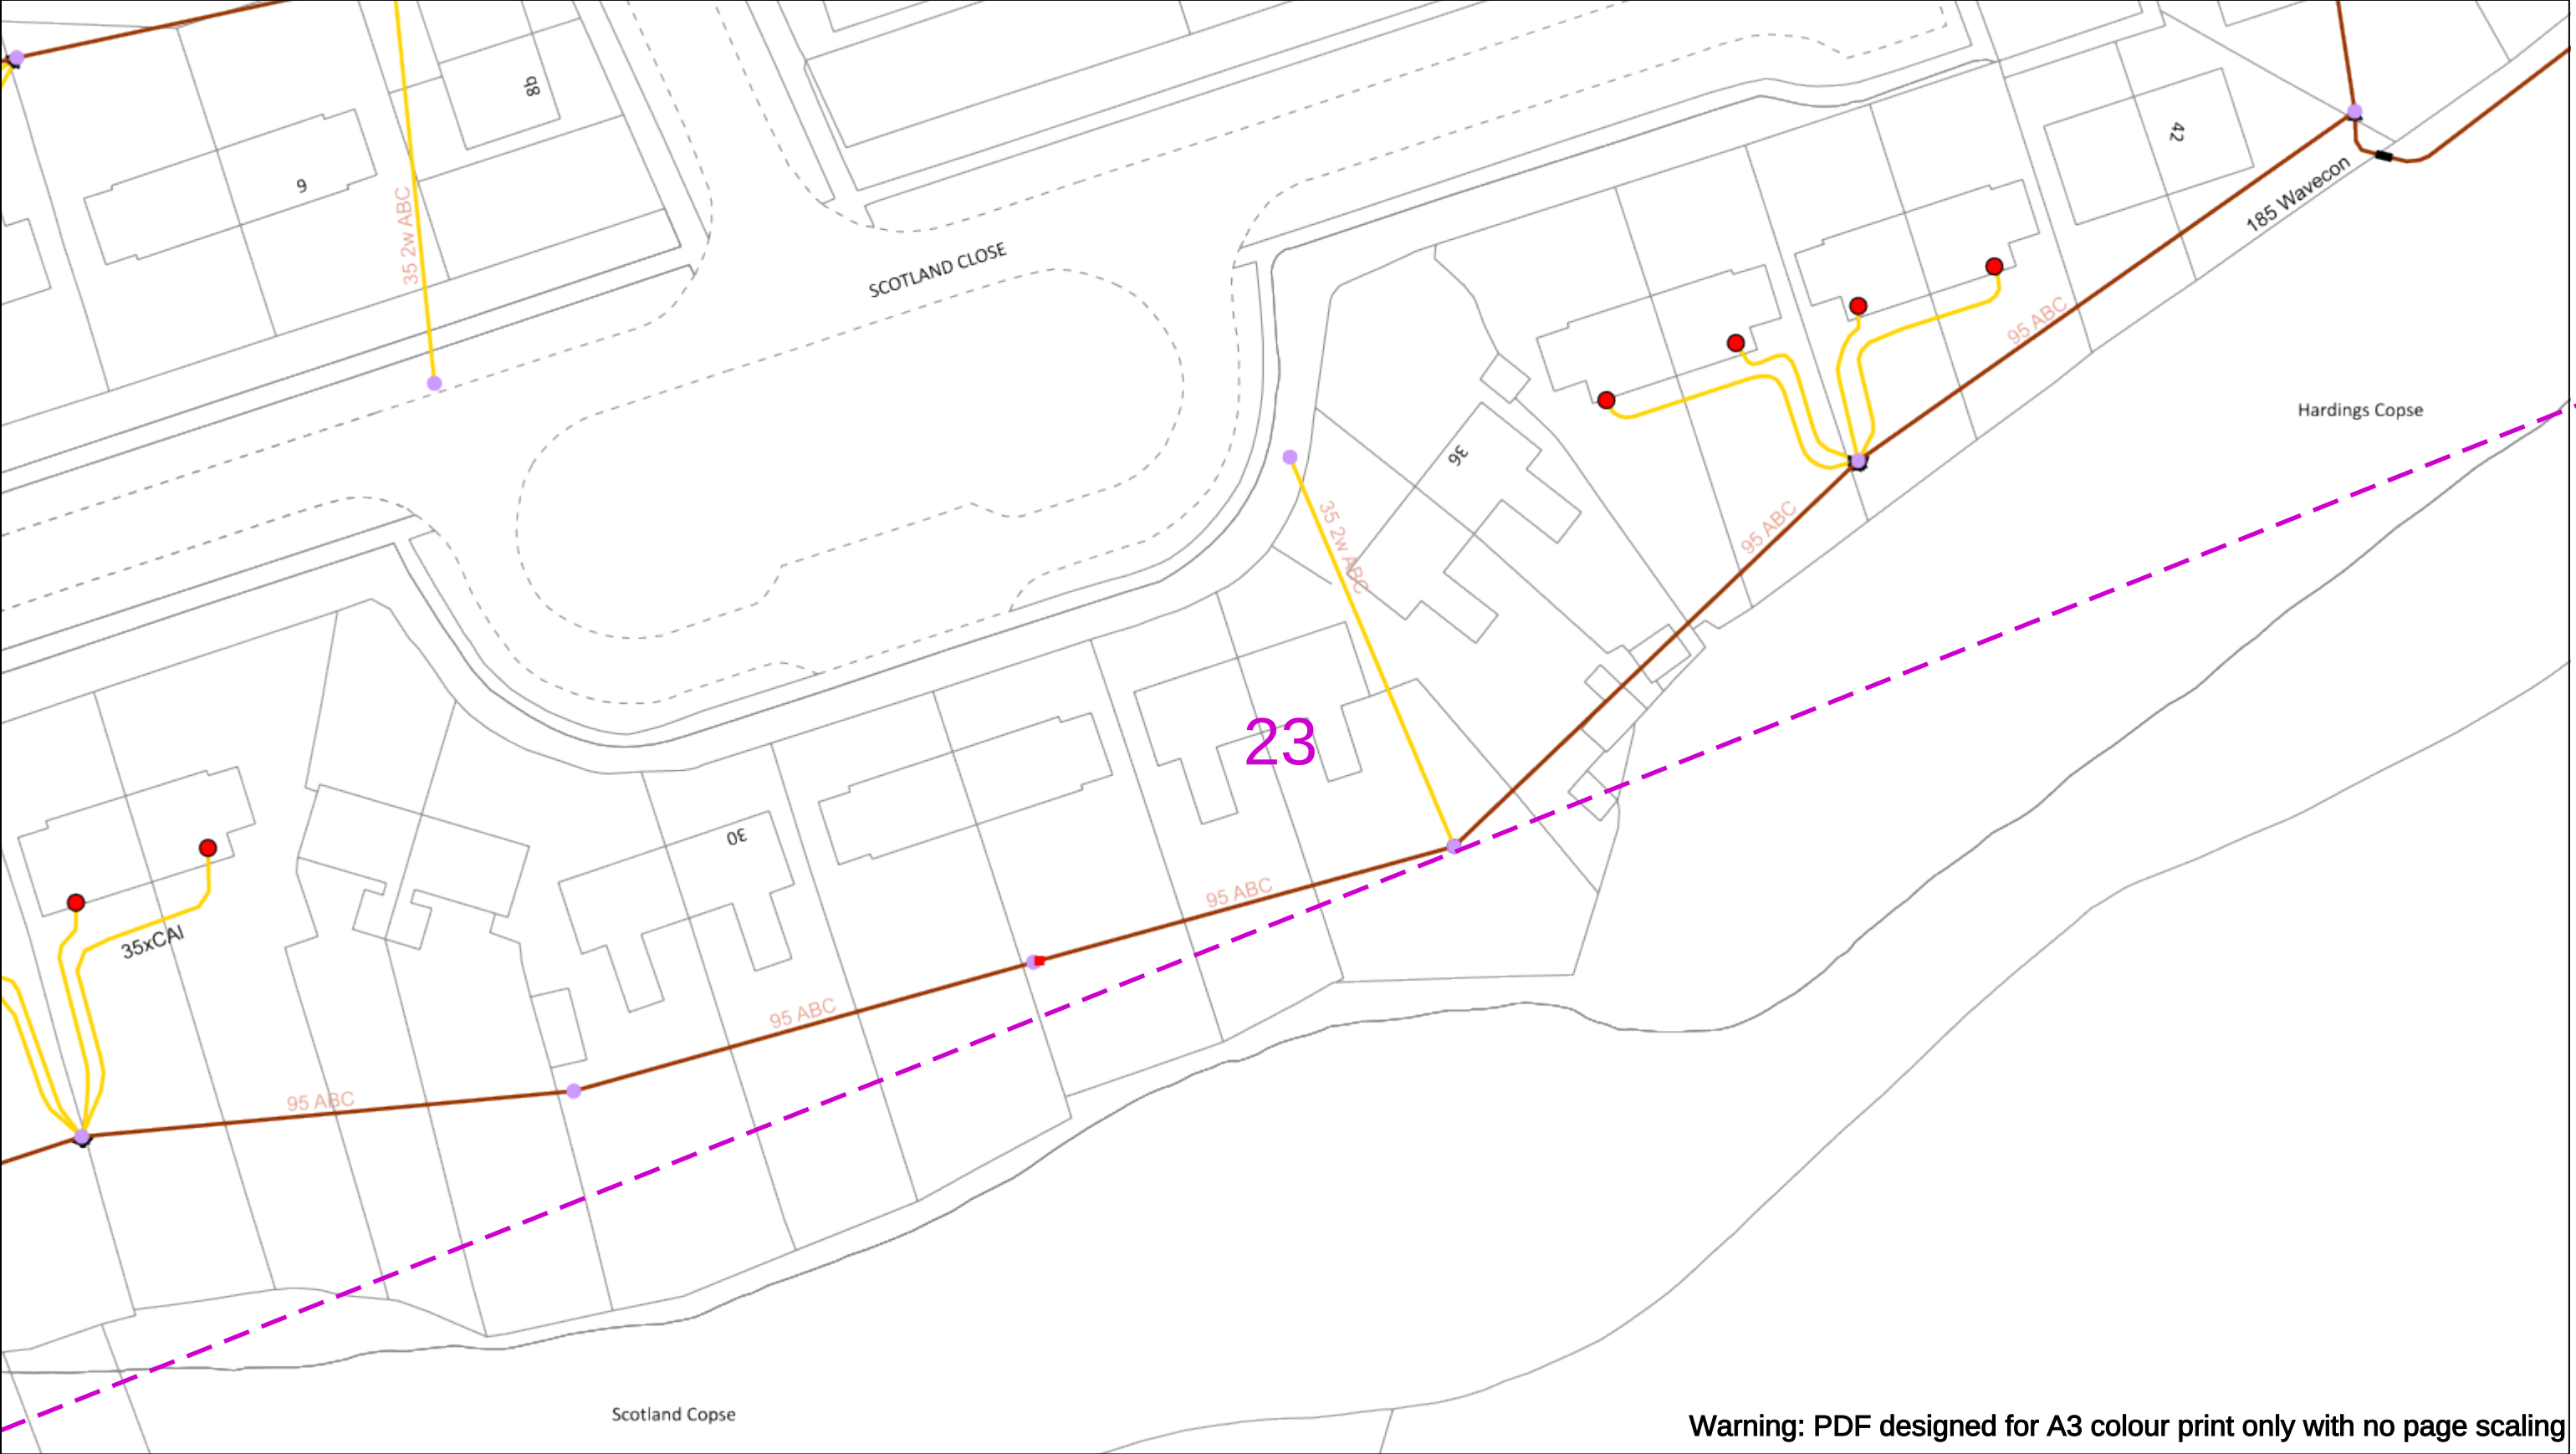

050m

Dig Sites

Area:

Line:

Date Requested: 23/11/2023

Job Reference: 31641913

Site Location: 450687 118647

Requested by: Ms Debbie Wigston

Your Scheme/Reference: 8230679

WARNING

There may have been subsequent alteration to the surface levels. Trial holes must be undertaken to determine position and depths of cables. HS (G) 47 Booklet from the Health and Safety Executive – Avoiding Danger from Buried Cables – should be consulted before commencing excavation work.

WHEN WORKING IN THE VICINITY OF OVERHEAD LINES THE HEALTH AND SAFETY GUIDANCE NOTES GS6 SHOULD BE CONSULTED (AVAILABLE FROM THE HSE WEBSITE)

Voltages (V)				
LV (Low Voltage) and Services	Up to 1,000V			
HV (High Voltage)	Over 1,000V to 11,000V			
EHV (Extra High Voltage)	22,000V to 132,000V			
Transmission	275,000V and 400,000V			

NORMAL DEPTH TO THE TOP OF THE CABLE WHEN LAID				
	Services	LV	HV	EHV
Footpath/Unmade	0.45m	0.45m	0.6m	0.8m
Road Crossing	0.6m	0.6m	0.75m	0.9m
Agricultural	1m	1m	1m	1.1m

Legend

Service Cable

LV Mains

2 – 3.3kV

6.6kV

11kV

22kV

33kV

66kV

132kV

275kV

400kV

Fibre Optic

Pilot Cable

Distribution Structures (Electric)

Pole, Existing Location

Pole Structure, Existing Location - Single

Pole Structure, Existing Location - H

Duct Route

Cross Section Route

Southern Electric Power Distribution plc

Registered Office: No.1 Forbury Place

43 Forbury Road Reading RG1 3JH

Registered In England & Wales No.04094290

If you're unsure & need to seek advice before commencing excavations please contact:

General Enquiries: 0800 048 3516


Subject to revision – Master held by SSEN Asset Data Team:

Asset.Data@sse.com

01256 337 294

BASED UPON THE ORDNANCE SURVEY MAP WITH THE SANCTION OF THE CONTROLLER OF H.M STATIONERY OFFICE CROWN COPYRIGHT RESERVED.

This copy has been made by or with the authority of Scottish and Southern Energy Power Distribution Ltd. Pursuant to section 47 of the Copyright, Designs and Patents Act 1988 ('The Act'). Unless the Act provides a relevant exception to copyright the copy must not be copied without prior permission of the copyright owner. Plans generated by DigSAFE Pro™ software provided by LinesearchbeforeUdig.

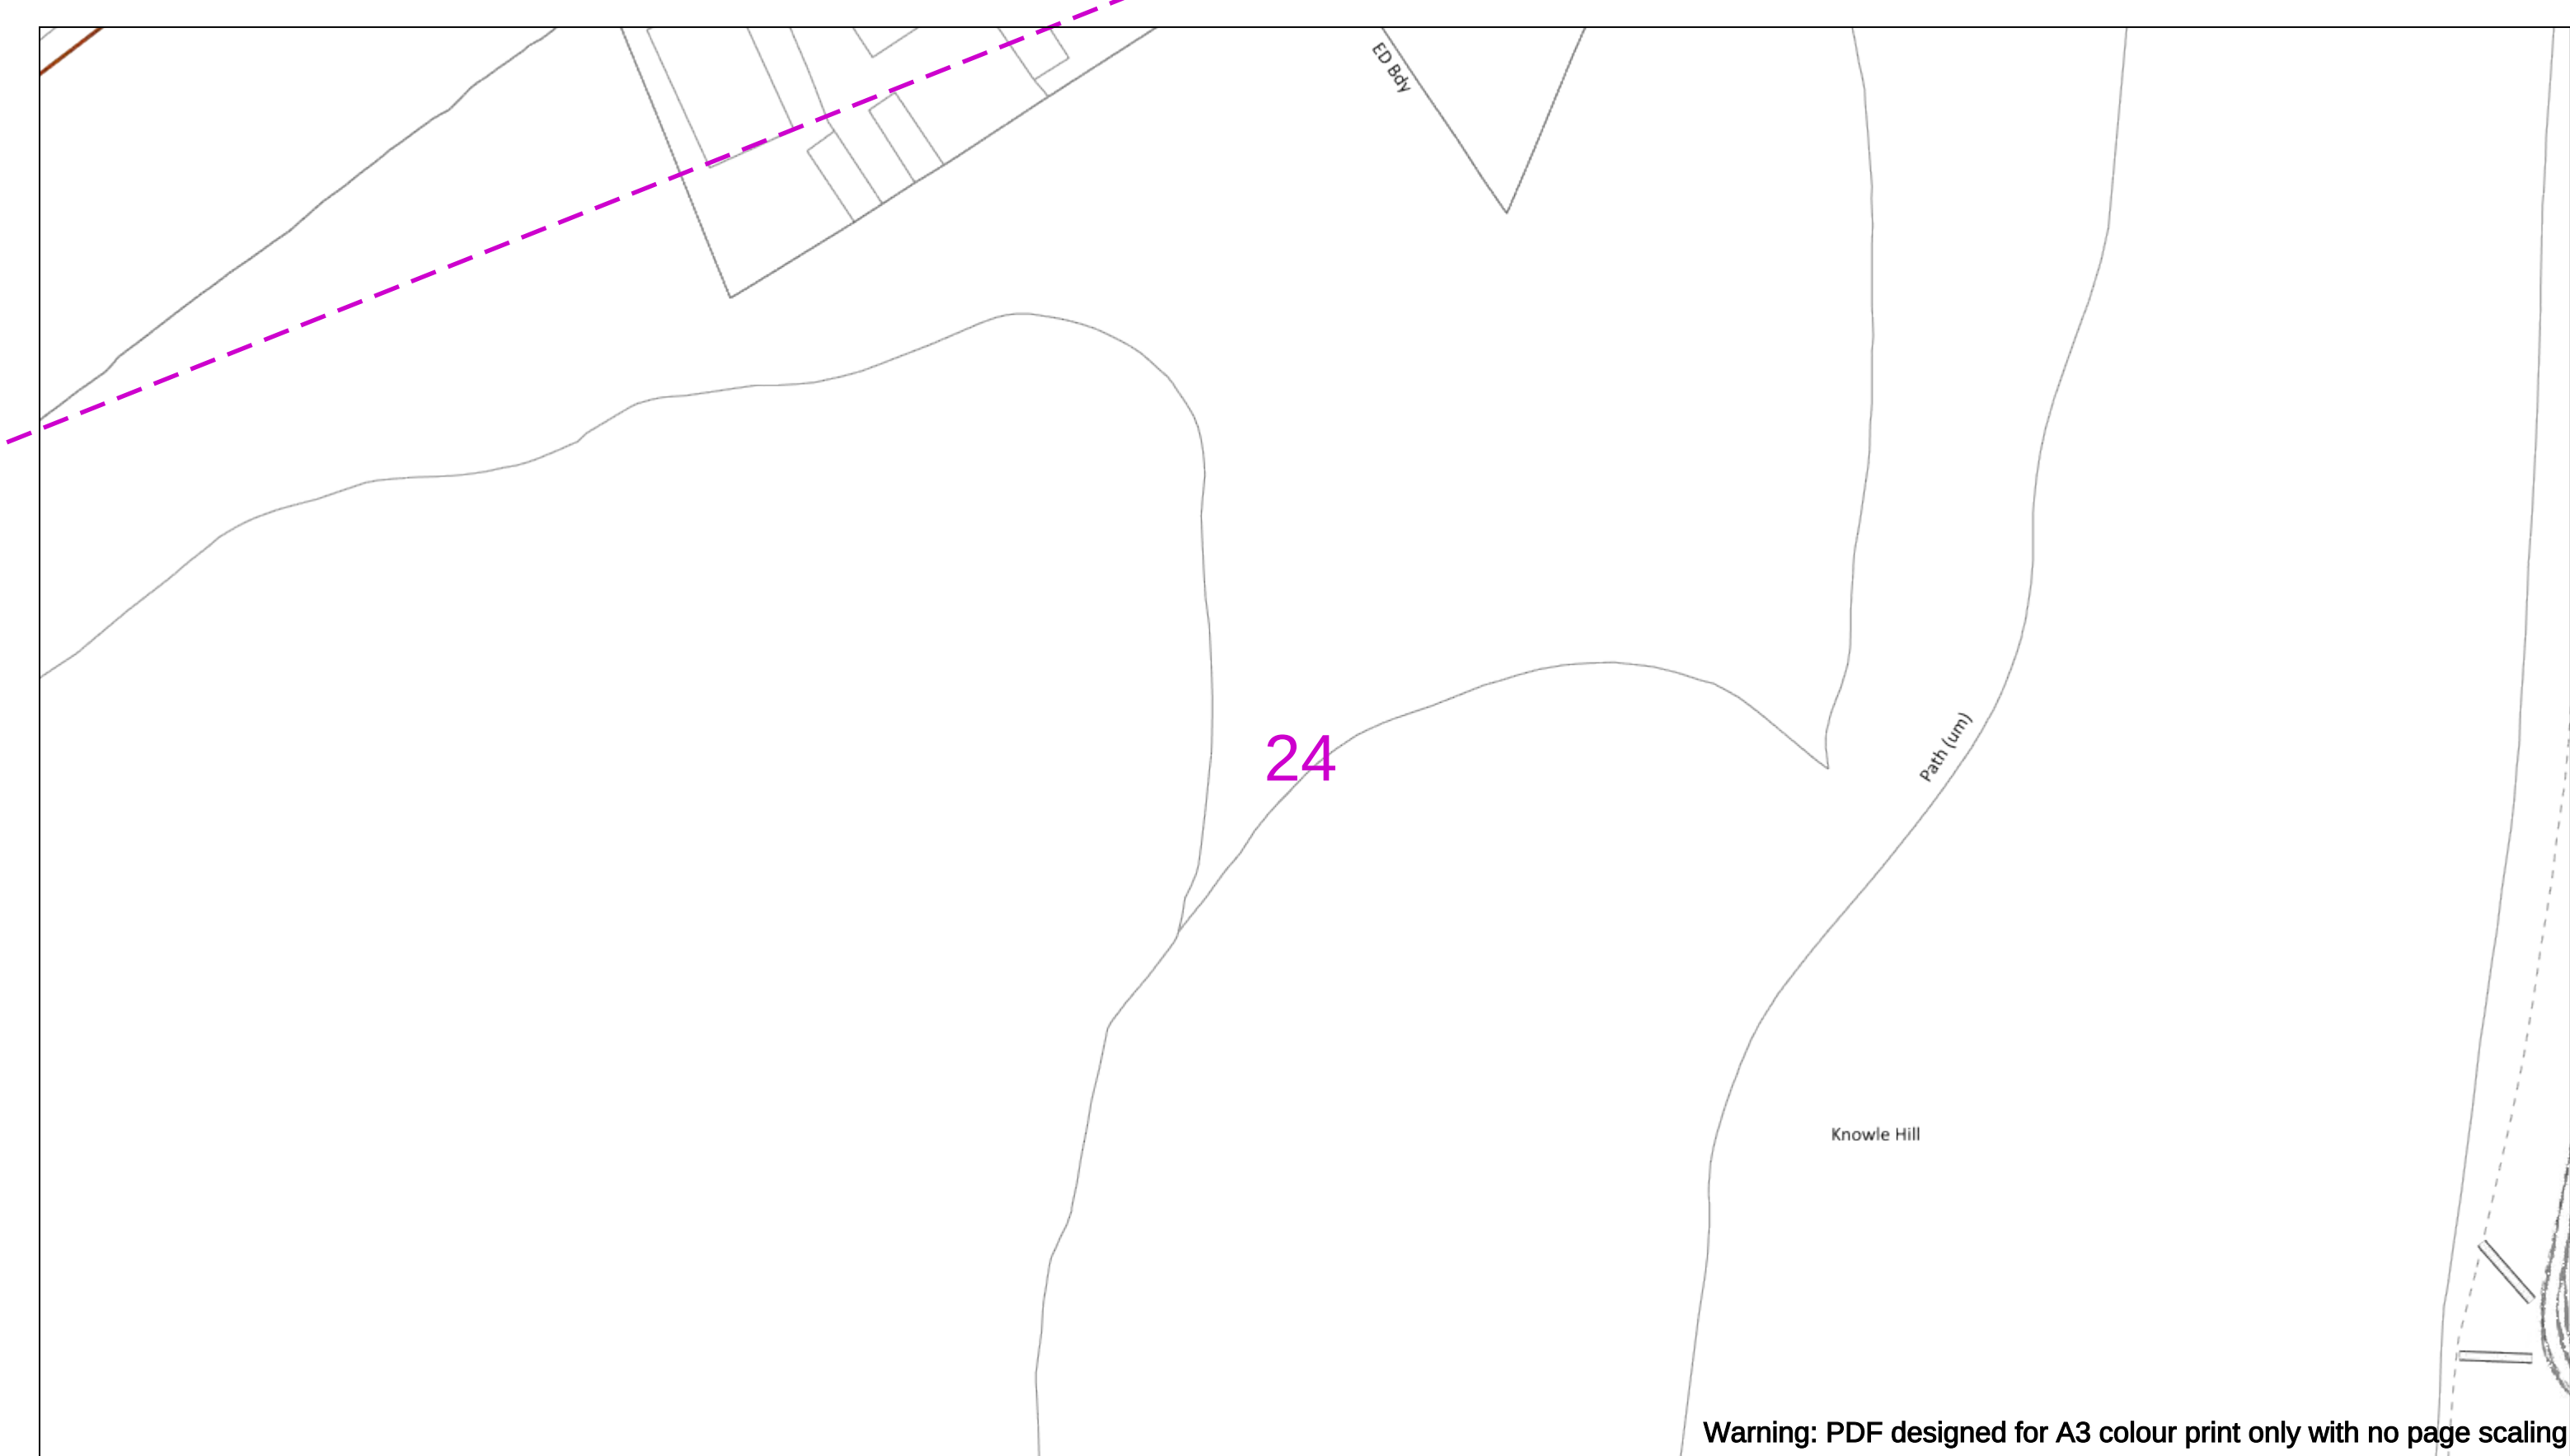

Warning: PDF designed for A3 colour print only with no page scaling



Dig Sites Area:  Line: 



Date Requested: 23/11/2023
Job Reference: 31641913
Site Location: 450687 118647
Requested by: Ms Debbie Wigston
Your Scheme/Reference: 8230679

WARNING

There may have been subsequent alteration to the surface levels. Trial holes must be undertaken to determine position and depths of cables. HS (G) 47 Booklet from the Health and Safety Executive – Avoiding Danger from Buried Cables – should be consulted before commencing excavation work.

WHEN WORKING IN THE VICINITY OF OVERHEAD LINES THE HEALTH AND SAFETY GUIDANCE NOTES GS6 SHOULD BE CONSULTED (AVAILABLE FROM THE HSE WEBSITE)

VOLTAGES (V)				
LV (Low Voltage) and Services		Up to 1,000V		
HV (High Voltage)		Over 1,000V to 11,000V		
EHV (Extra High Voltage)		22,000V to 132,000V		
Transmission		275,000V and 400,000V		
NORMAL DEPTH TO THE TOP OF THE CABLE WHEN LAID				
	Services	LV	HV	EHV
Footpath/Unmade	0.45m	0.45m	0.6m	0.9m
Road Crossing	0.6m	0.6m	0.75m	0.9m
Agricultural	1m	1m	1m	1.2m

Legend

- Service Cable
- LV Mains
- 2 - 3.3kV
- 6.6kV
- 11kV
- 22kV
- 33kV
- 66kV
- 132kV
- 275kV
- 400kV
- Fibre Optic
- Pilot Cable

Distribution Structures (Electric)

- Pole, Existing Location
- Pole Structure, Existing Location - Single
- Pole Structure, Existing Location - H
- Duct Route
- Cross Section Route

Southern Electric Power Distribution plc
Registered Office: No.1 Forbury Place
43 Forbury Road Reading RG1 3JH
Registered In England & Wales No.04094290


If you're unsure & need to seek advice before commencing excavations please contact:
General Enquiries: 0800 048 3516

Subject to revision – Master held by SSEN Asset Data Team:
Asset.Data@sse.com
 01256 337 294

Scale: 1:500 (When plotted at A3)

BASED UPON THE ORDNANCE SURVEY MAP WITH THE SANCTION OF THE CONTROLLER OF H.M STATIONERY OFFICE CROWN COPYRIGHT RESERVED.

This copy has been made by or with the authority of Scottish and Southern Energy Power Distribution Ltd. Pursuant to section 47 of the Copyright, Designs and Patents Act 1988 ('The Act'). Unless the Act provides a relevant exception to copyright the copy must not be copied without prior permission of the copyright owner. Plans generated by DigSAFE Pro™ software provided by LinesearchbeforeUdig.

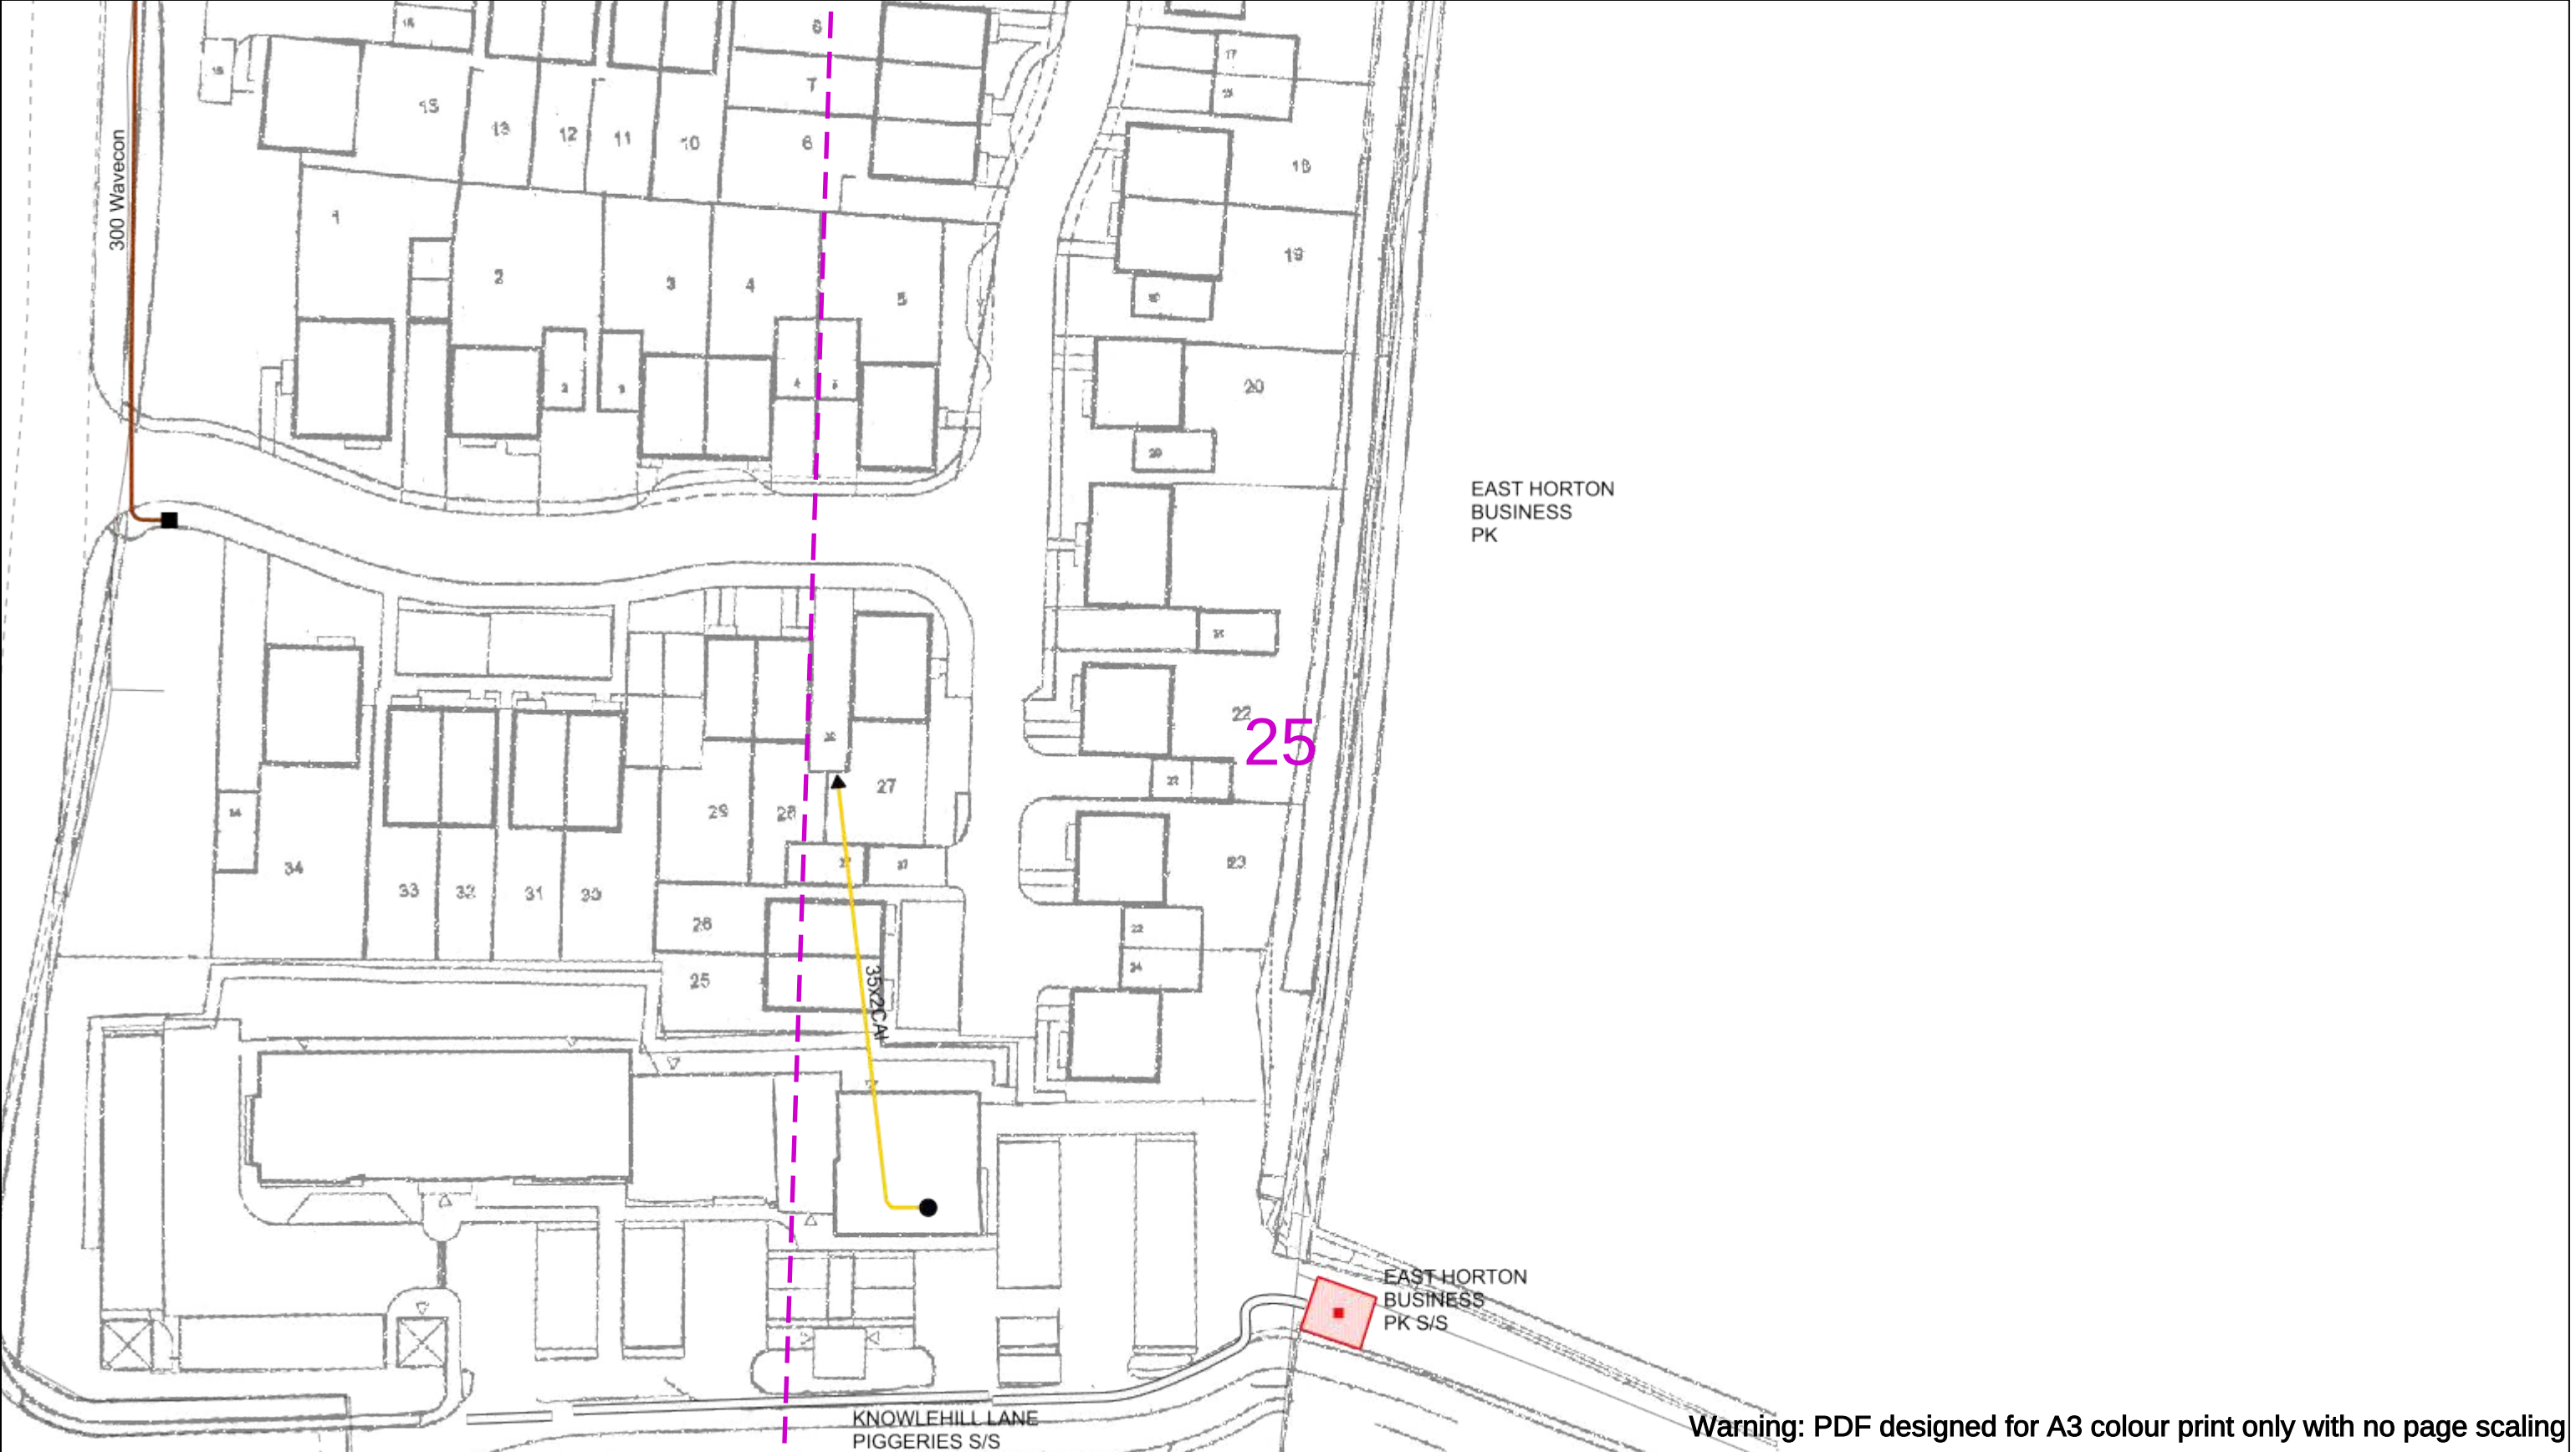

Warning: PDF designed for A3 colour print only with no page scaling

050m

Dig SitesArea:Line:

Date Requested: 23/11/2023
Job Reference: 31641913
Site Location: 450687 118647
Requested by:
Ms Debbie Wigston
Your Scheme/Reference: 8230679

WARNING

There may have been subsequent alteration to the surface levels. Trial holes must be undertaken to determine position and depths of cables. HS (G) 47 Booklet from the Health and Safety Executive – Avoiding Danger from Buried Cables – should be consulted before commencing excavation work.

WHEN WORKING IN THE VICINITY OF OVERHEAD LINES THE HEALTH AND SAFETY GUIDANCE NOTES GS6 SHOULD BE CONSULTED (AVAILABLE FROM THE HSE WEBSITE)

Scale: 1:500 (When plotted at A3)

Voltages (V)				
LV (Low Voltage) and Services	Up to 1,000V			
HV (High Voltage)	Over 1,000V to 11,000V			
EHV (Extra High Voltage)	22,000V to 132,000V			
Transmission	275,000V and 400,000V			

NORMAL DEPTH TO THE TOP OF THE CABLE WHEN LAID				
	Services	LV	HV	EHV
Footpath/Unmade	0.45m	0.45m	0.6m	0.8m
Road Crossing	0.6m	0.6m	0.75m	0.9m
Agricultural	1m	1m	1m	1.1m

Legend

Service Cable

LV Mains

2 – 3.3kV

6.6kV

11kV

22kV

33kV

66kV

132kV

275kV

400kV

Fibre Optic

Pilot Cable

Distribution Structures (Electric)

Pole, Existing Location

Pole Structure, Existing Location - Single

Pole Structure, Existing Location - H

Duct Route

Cross Section Route

Scottish & Southern
Electricity Networks

Southern Electric Power Distribution plc

Registered Office: No.1 Forbury Place
43 Forbury Road Reading RG1 3JH
Registered In England & Wales No.04094290

If you're unsure & need to seek advice before commencing excavations please contact:
General Enquiries: 0800 048 3516

Subject to revision – Master held by SSEN Asset Data Team:
Asset.Data@sse.com
01256 337 294

BASED UPON THE ORDNANCE SURVEY MAP WITH THE SANCTION OF THE CONTROLLER OF H.M STATIONERY OFFICE CROWN COPYRIGHT RESERVED.

This copy has been made by or with the authority of Scottish and Southern Energy Power Distribution Ltd. Pursuant to section 47 of the Copyright, Designs and Patents Act 1988 ('The Act'). Unless the Act provides a relevant exception to copyright the copy must not be copied without prior permission of the copyright owner. Plans generated by DigSAFE Pro™ software provided by LinesearchbeforeUdig.

Warning: PDF designed for A3 colour print only with no page scaling



Dig Sites Area:  Line: 



Date Requested: 23/11/2023
Job Reference: 31641913
Site Location: 450687 118647
Requested by: Ms Debbie Wigston
Your Scheme/Reference: 8230679

WARNING

There may have been subsequent alteration to the surface levels. Trial holes must be undertaken to determine position and depths of cables. HS (G) 47 Booklet from the Health and Safety Executive – Avoiding Danger from Buried Cables – should be consulted before commencing excavation work.

WHEN WORKING IN THE VICINITY OF OVERHEAD LINES THE HEALTH AND SAFETY GUIDANCE NOTES GS6 SHOULD BE CONSULTED (AVAILABLE FROM THE HSE WEBSITE)

Voltages (V)				
LV (Low Voltage) and Services		Up to 1,000V		
HV (High Voltage)		Over 1,000V to 11,000V		
EHV (Extra High Voltage)		22,000V to 132,000V		
Transmission		275,000V and 400,000V		
NORMAL DEPTH TO THE TOP OF THE CABLE WHEN LAID				
	Services	LV	HV	EHV
Footpath/Unmade	0.45m	0.45m	0.6m	0.6m
Road Crossing	0.6m	0.6m	0.75m	0.6m
Agricultural	1m	1m	1m	1m

Legend

- Service Cable
- LV Mains
- 2 – 3.3kV
- 6.6kV
- 11kV
- 22kV
- 33kV
- 66kV
- 132kV
- 275kV
- 400kV
- Fibre Optic
- Pilot Cable

Distribution Structures (Electric)

- Pole, Existing Location
- Pole Structure, Existing Location - Single
- Pole Structure, Existing Location - H
- Duct Route
- Cross Section Route

Southern Electric Power Distribution plc
Registered Office: No.1 Forbury Place
43 Forbury Road Reading RG1 3JH
Registered in England & Wales No.04094290


If you're unsure & need to seek advice before commencing excavations please contact:
General Enquiries: 0800 048 3516

Subject to revision – Master held by SSEN Asset Data Team:
Asset_Data@sse.com
01256 337 294

Scale: 1:500 (When plotted at A3)

BASED UPON THE ORDNANCE SURVEY MAP WITH THE SANCTION OF THE CONTROLLER OF H.M STATIONERY OFFICE CROWN COPYRIGHT RESERVED.

This copy has been made by or with the authority of Scottish and Southern Energy Power Distribution Ltd. Pursuant to section 47 of the Copyright, Designs and Patents Act 1988 ('The Act'). Unless the Act provides a relevant exception to copyright the copy must not be copied without prior permission of the copyright owner. Plans generated by DigSAFE Pro™ software provided by LinesearchbeforeUdig.

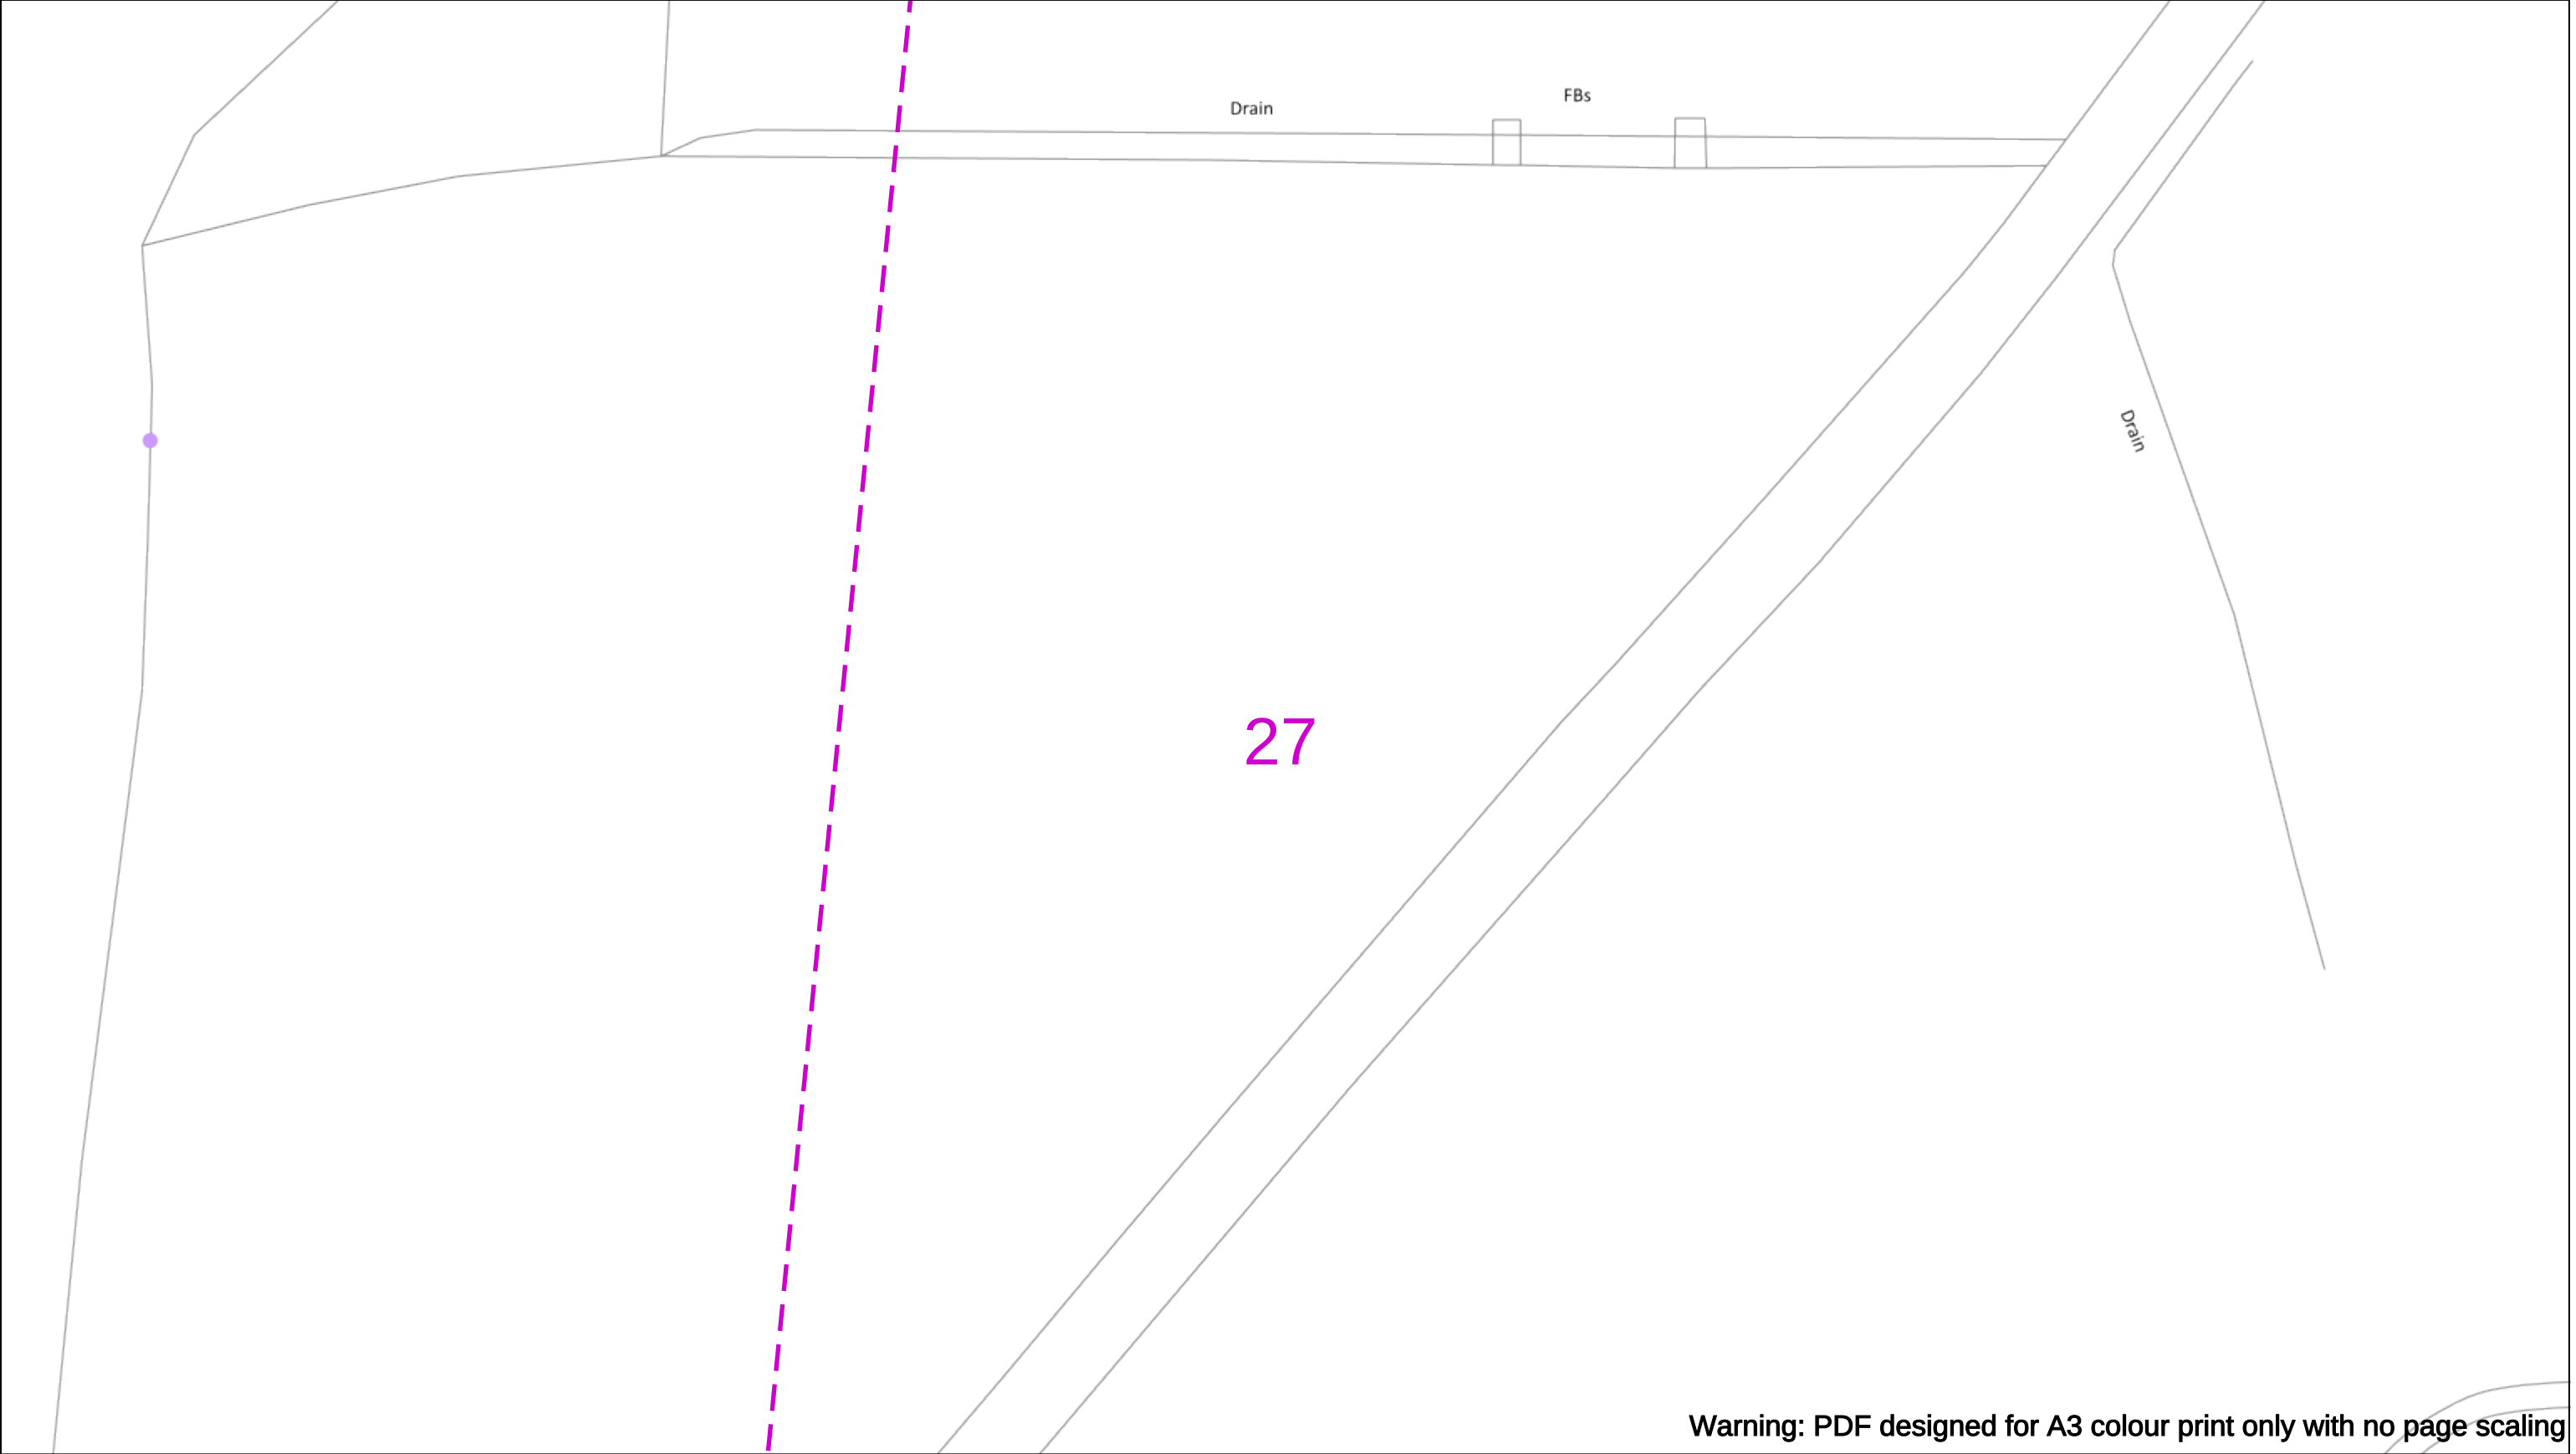

Warning: PDF designed for A3 colour print only with no page scaling

050m

Dig Sites

Area:

Line:

Date Requested: 23/11/2023

Job Reference: 31641913

Site Location: 450687 118647

Requested by:
Ms Debbie Wigston

Your Scheme/Reference: 8230679

WARNING

There may have been subsequent alteration to the surface levels. Trial holes must be undertaken to determine position and depths of cables. HS (G) 47 Booklet from the Health and Safety Executive – Avoiding Danger from Buried Cables – should be consulted before commencing excavation work.

WHEN WORKING IN THE VICINITY OF OVERHEAD LINES THE HEALTH AND SAFETY GUIDANCE NOTES GS6 SHOULD BE CONSULTED (AVAILABLE FROM THE HSE WEBSITE)

Voltages (V)				
LV (Low Voltage) and Services	Up to 1,000V			
HV (High Voltage)	Over 1,000V to 11,000V			
EHV (Extra High Voltage)	22,000V to 132,000V			
Transmission	275,000V and 400,000V			

NORMAL DEPTH TO THE TOP OF THE CABLE WHEN LAID				
	Services	LV	HV	EHV
Footpath/Unmade	0.45m	0.45m	0.6m	0.8m
Road Crossing	0.6m	0.6m	0.75m	0.9m
Agricultural	1m	1m	1m	1.1m

Legend

Service Cable

LV Mains

2 – 3.3kV

6.6kV

11kV

22kV

33kV

66kV

132kV

275kV

400kV

Fibre Optic

Pilot Cable

Distribution Structures (Electric)

Pole, Existing Location

Pole Structure, Existing Location - Single

Pole Structure, Existing Location - H

Duct Route

Cross Section Route

N

E

S

W

Scottish & Southern

Electricity Networks

Southern Electric Power Distribution plc

Registered Office: No.1 Forbury Place

43 Forbury Road Reading RG1 3JH

Registered In England & Wales No.04094290

If you're unsure & need to seek advice before commencing excavations please contact:

General Enquiries: 0800 048 3516


Subject to revision – Master held by SSEN Asset Data Team:

Asset.Data@sse.com

01256 337 294

BASED UPON THE ORDNANCE SURVEY MAP WITH THE SANCTION OF THE CONTROLLER OF H.M STATIONERY OFFICE CROWN COPYRIGHT RESERVED.

This copy has been made by or with the authority of Scottish and Southern Energy Power Distribution Ltd. Pursuant to section 47 of the Copyright, Designs and Patents Act 1988 ('The Act'). Unless the Act provides a relevant exception to copyright the copy must not be copied without prior permission of the copyright owner. Plans generated by DigSAFE Pro™ software provided by LinesearchbeforeUdig.

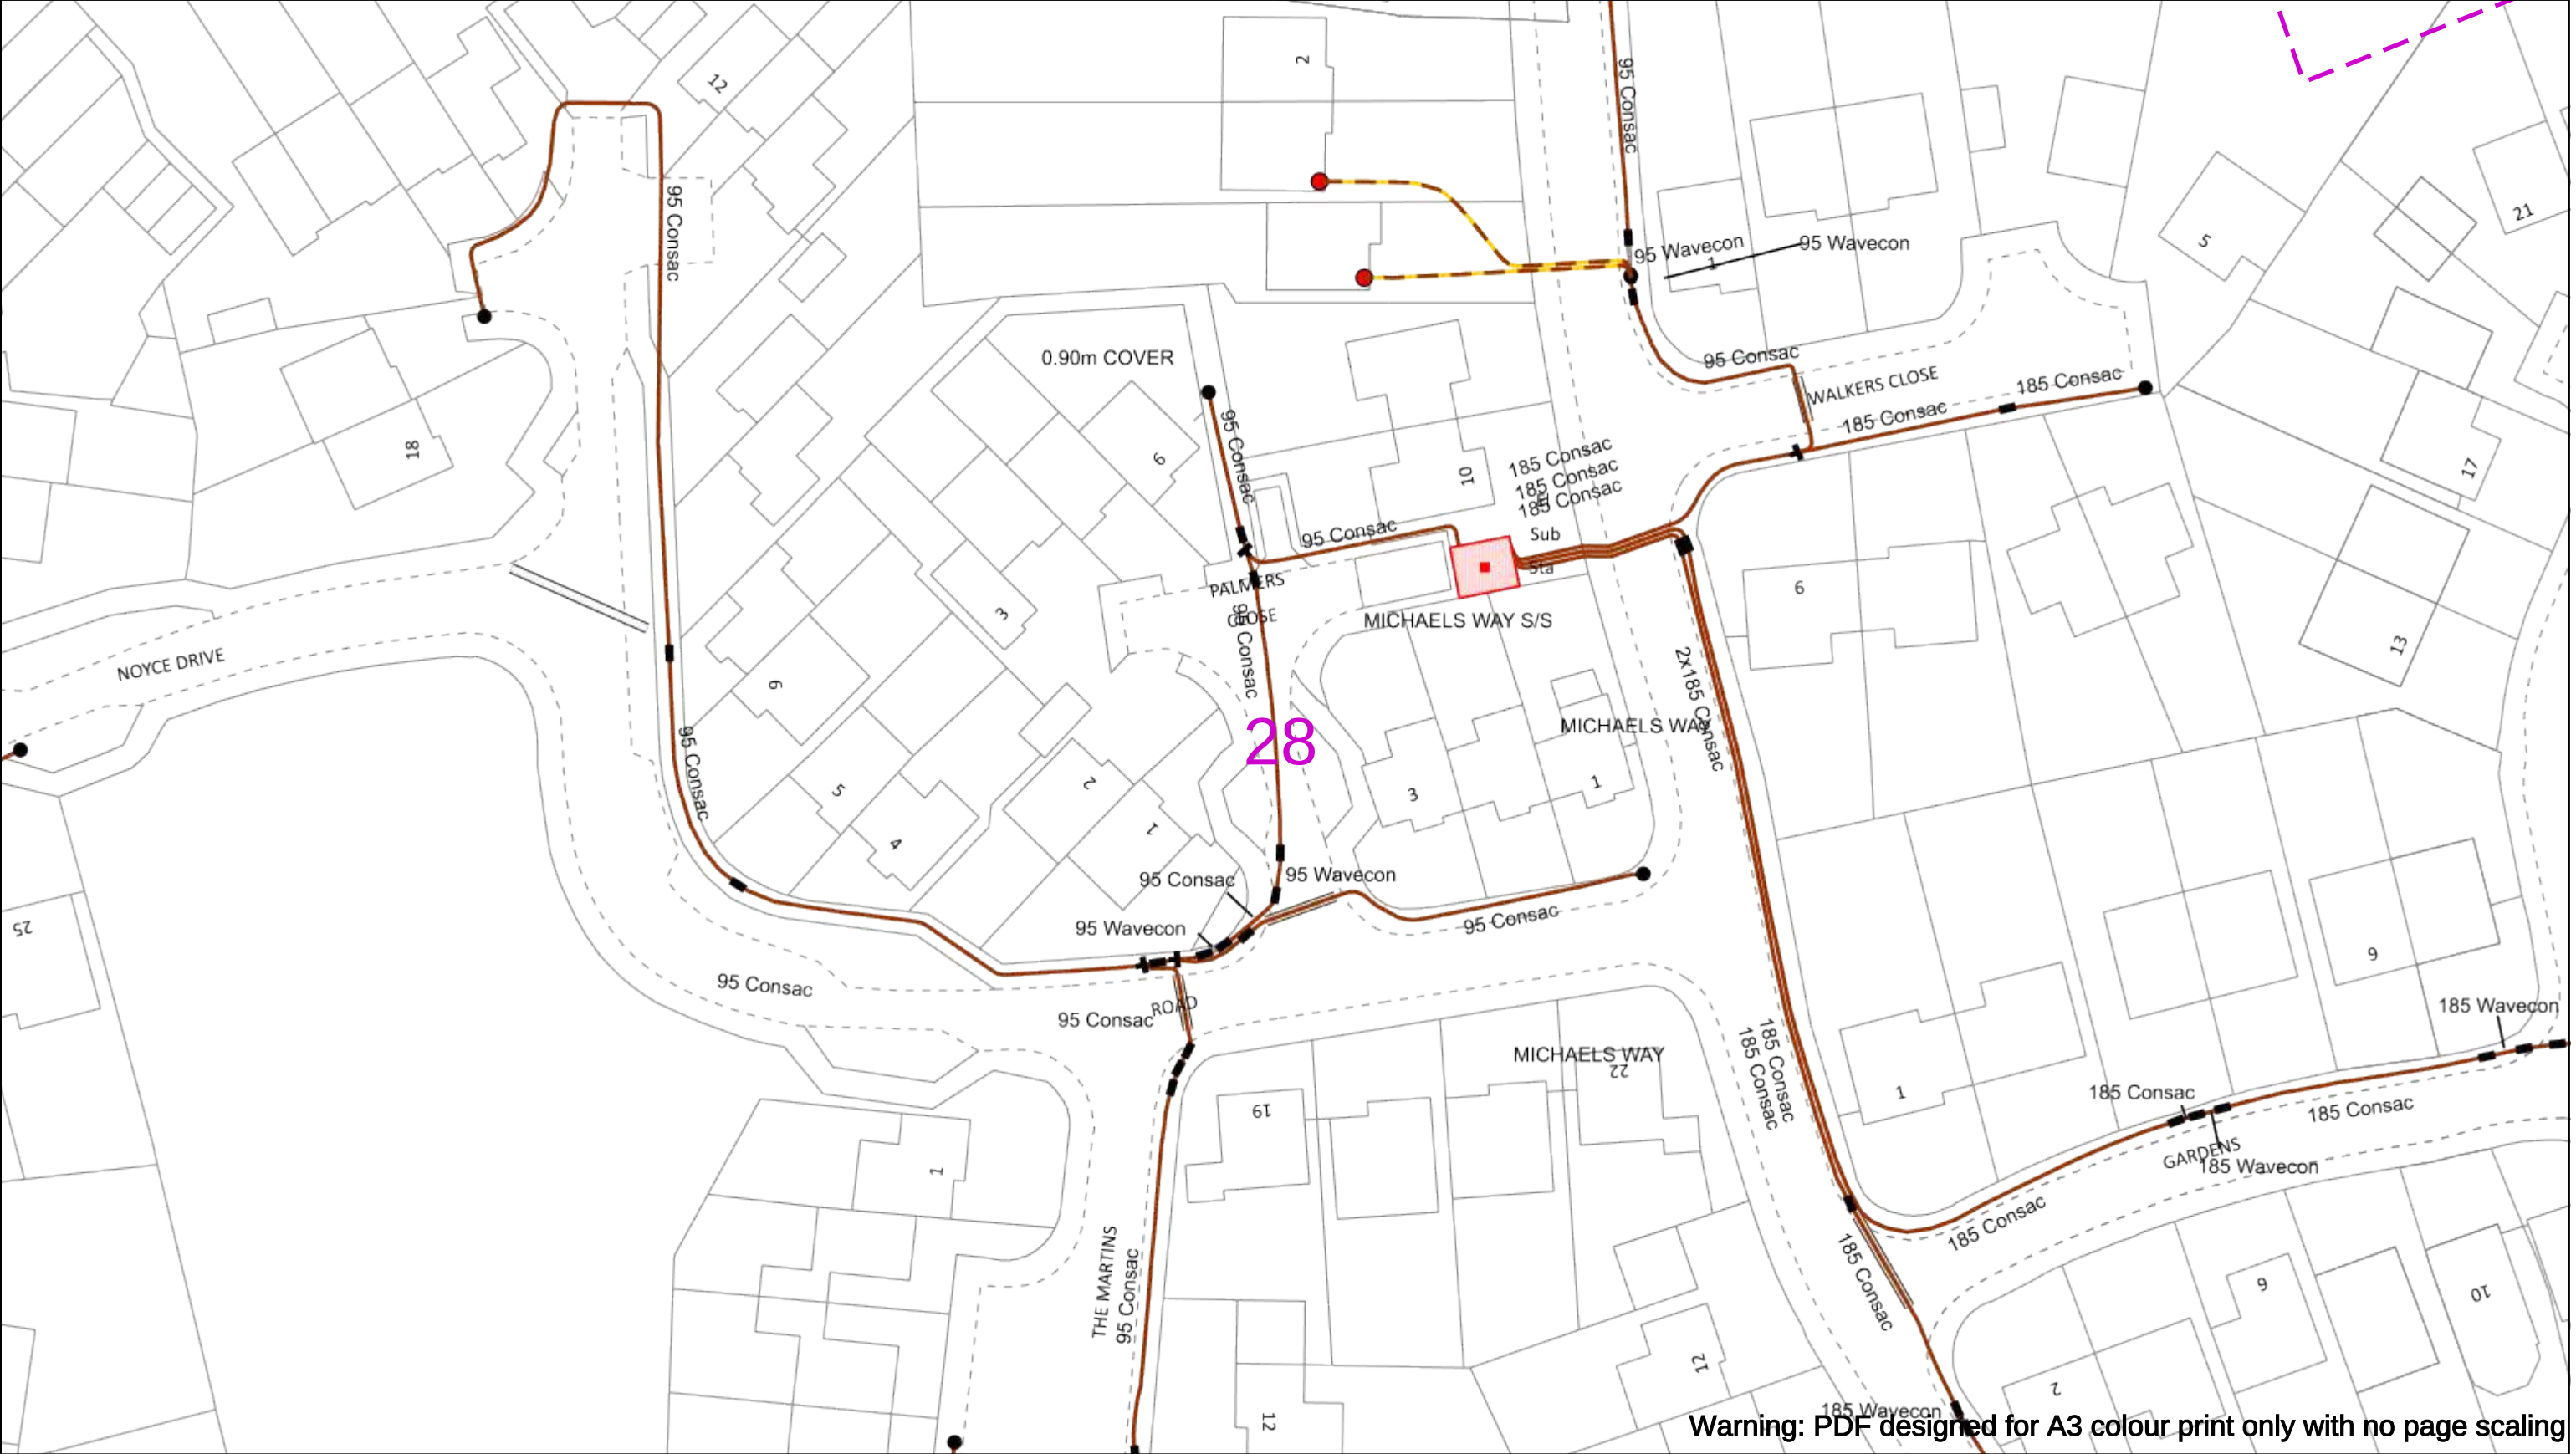

050m

Dig Sites

Area: ----

Line: ----

Date Requested: 23/11/2023

Job Reference: 31641913

Site Location: 450687 118647

Requested by:
Ms Debbie Wigston

Your Scheme/Reference: 8230679

WARNING

There may have been subsequent alteration to the surface levels. Trial holes must be undertaken to determine position and depths of cables. HS (G) 47 Booklet from the Health and Safety Executive – Avoiding Danger from Buried Cables – should be consulted before commencing excavation work.

WHEN WORKING IN THE VICINITY OF OVERHEAD LINES THE HEALTH AND SAFETY GUIDANCE NOTES GS6 SHOULD BE CONSULTED (AVAILABLE FROM THE HSE WEBSITE)

Scale: 1:500 (When plotted at A3)

Voltages (V)				
LV (Low Voltage) and Services	Up to 1,000V			
HV (High Voltage)	Over 1,000V to 11,000V			
EHV (Extra High Voltage)	22,000V to 132,000V			
Transmission	275,000V and 400,000V			

NORMAL DEPTH TO THE TOP OF THE CABLE WHEN LAID				
	Services	LV	HV	EHV
Footpath/Unmade	0.45m	0.45m	0.6m	0.8m
Road Crossing	0.6m	0.6m	0.75m	0.9m
Agricultural	1m	1m	1m	1.1m

Legend

Service Cable

LV Mains

2 – 3.3kV

6.6kV

11kV

22kV

33kV

66kV

132kV

275kV

400kV

Fibre Optic

Pilot Cable

Distribution Structures (Electric)

Pole, Existing Location

Pole Structure, Existing Location - Single

Pole Structure, Existing Location - H

Duct Route

Cross Section Route

N

E

S

W

Scottish & Southern

Electricity Networks

Southern Electric Power Distribution plc

Registered Office: No.1 Forbury Place

43 Forbury Road Reading RG1 3JH

Registered In England & Wales No.04094290

If you're unsure & need to seek advice before commencing excavations please contact:

General Enquiries: 0800 048 3516


Subject to revision – Master held by SSEN Asset Data Team:

Asset.Data@sse.com

01256 337 294

BASED UPON THE ORDNANCE SURVEY MAP WITH THE SANCTION OF THE CONTROLLER OF H.M STATIONERY OFFICE CROWN COPYRIGHT RESERVED.

This copy has been made by or with the authority of Scottish and Southern Energy Power Distribution Ltd. Pursuant to section 47 of the Copyright, Designs and Patents Act 1988 ('The Act'). Unless the Act provides a relevant exception to copyright the copy must not be copied without prior permission of the copyright owner. Plans generated by DigSAFE Pro™ software provided by LinesearchbeforeUdig.

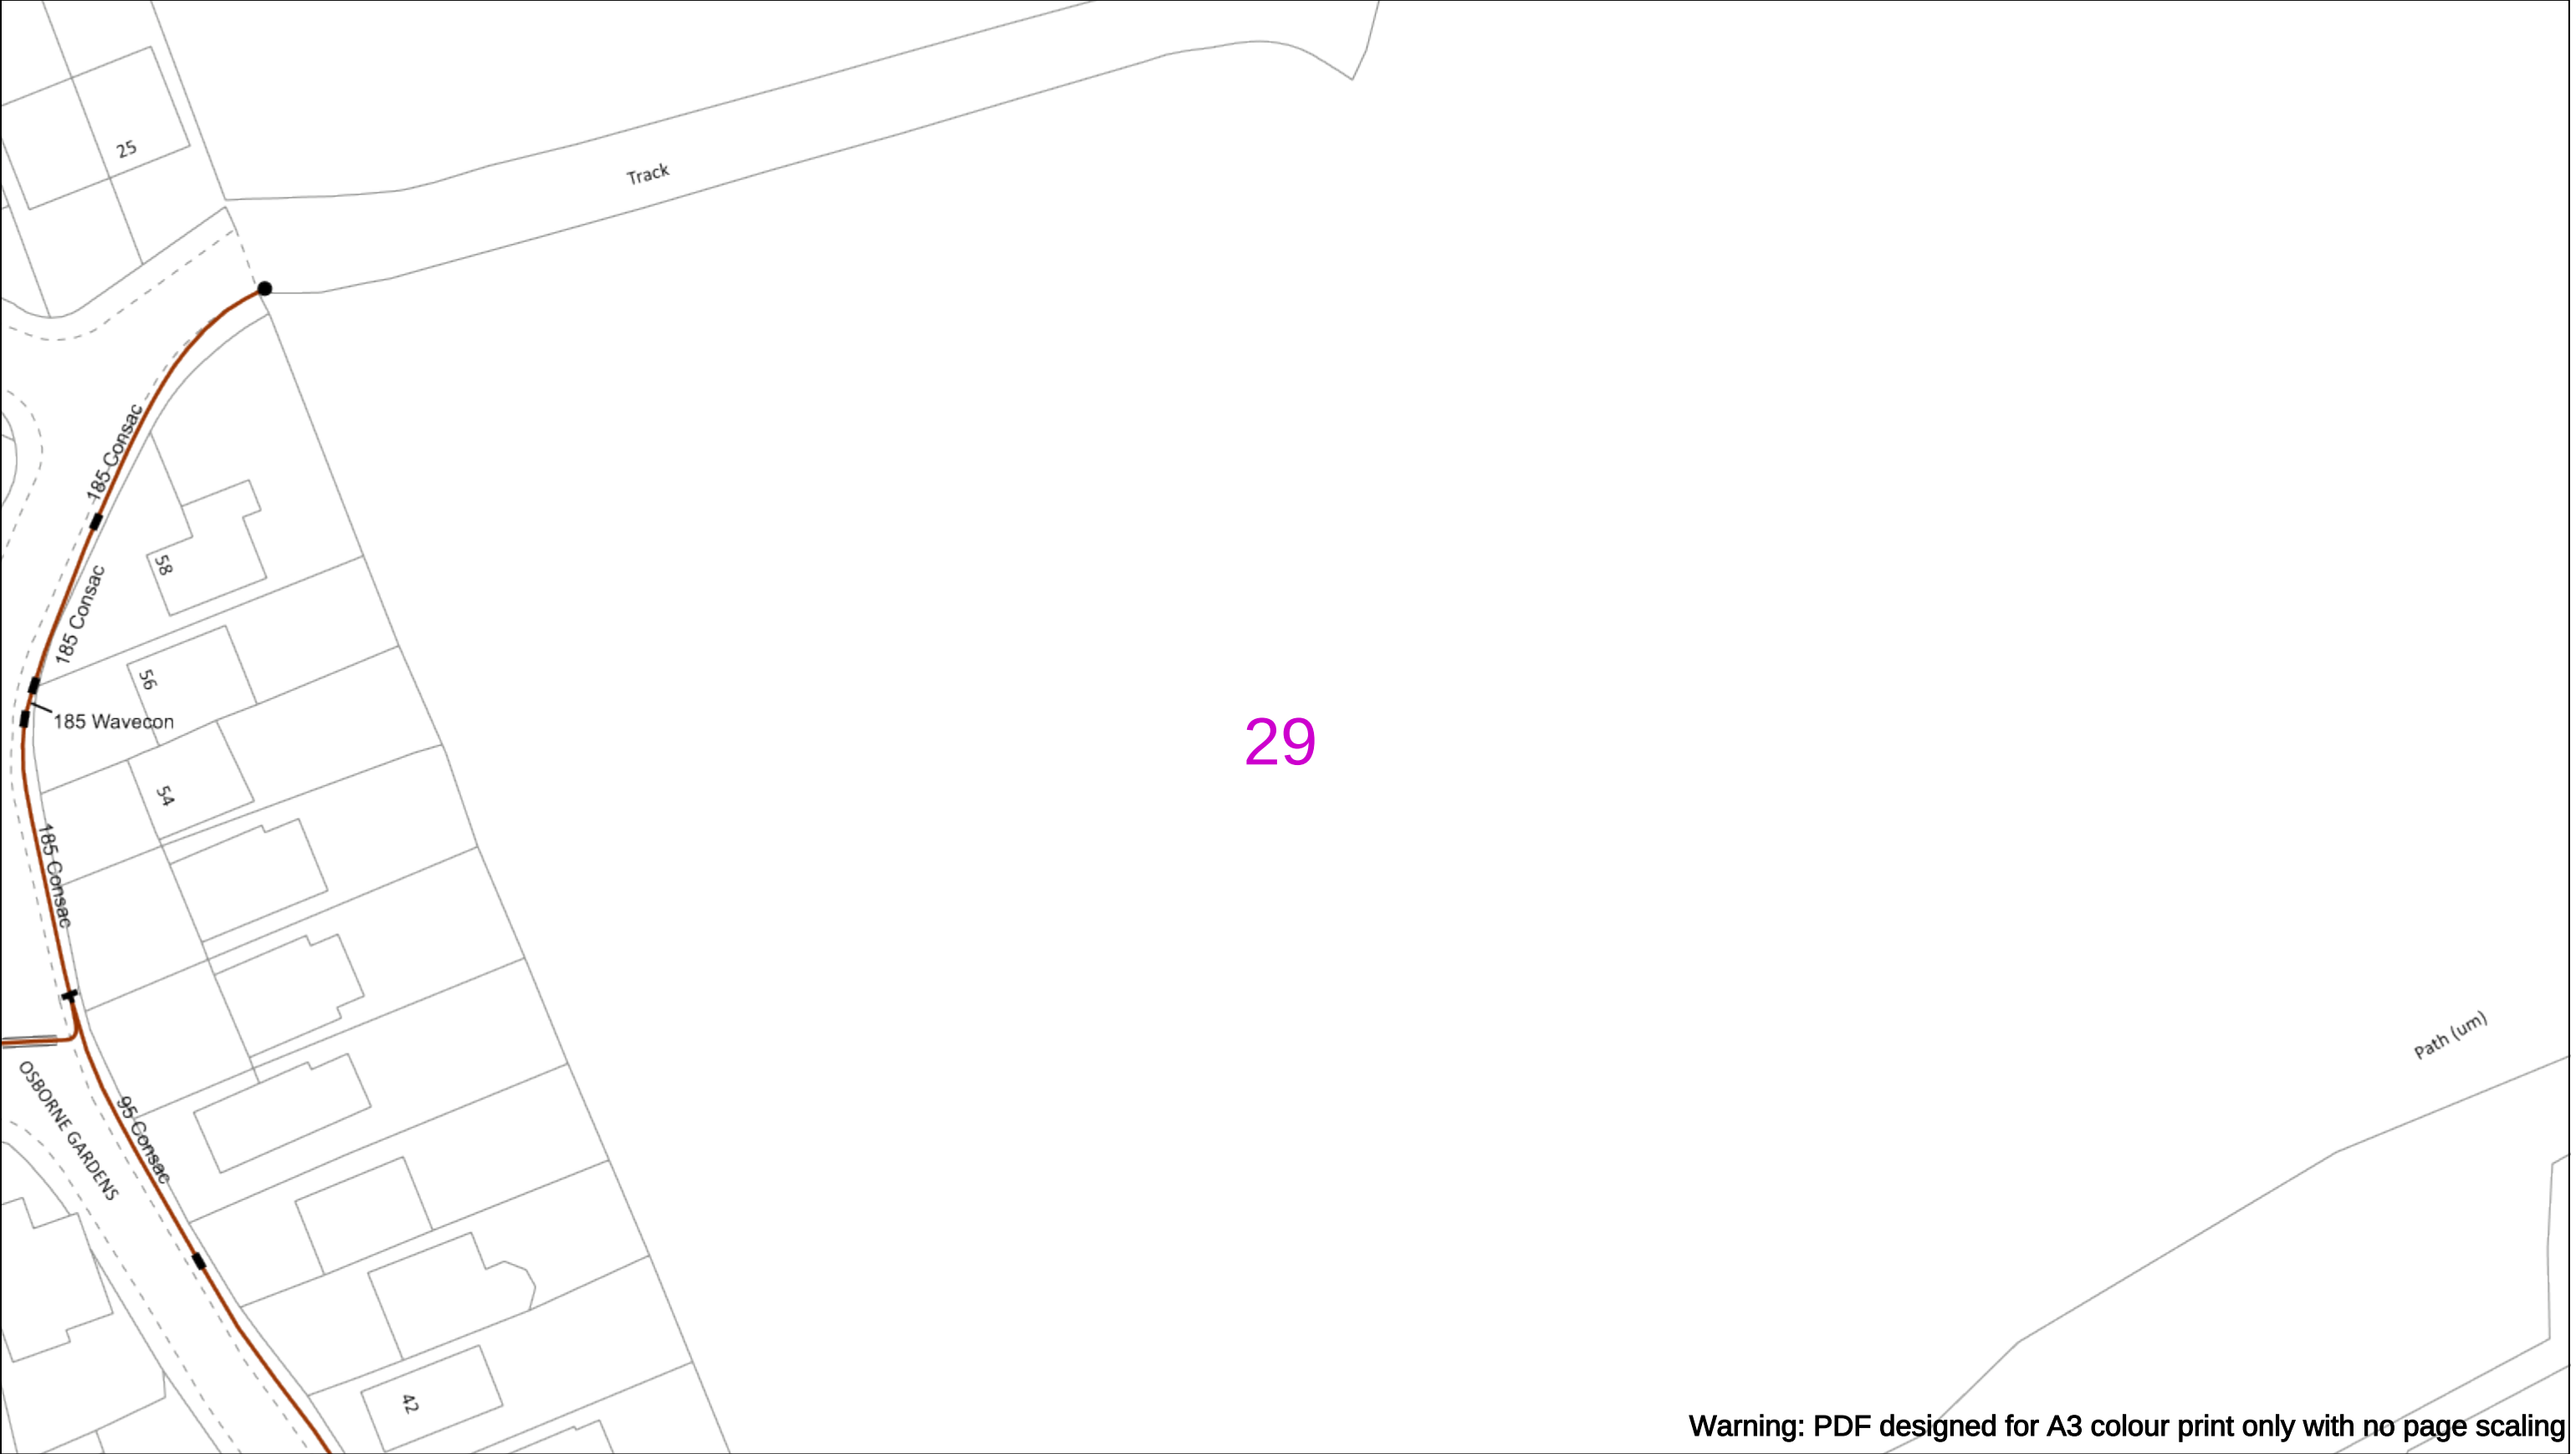

Warning: PDF designed for A3 colour print only with no page scaling

050m

Dig Sites

Area:

Line:

Date Requested: 23/11/2023

Job Reference: 31641913

Site Location: 450687 118647

Requested by:
Ms Debbie Wigston

Your Scheme/Reference: 8230679

WARNING

There may have been subsequent alteration to the surface levels. Trial holes must be undertaken to determine position and depths of cables. HS (G) 47 Booklet from the Health and Safety Executive – Avoiding Danger from Buried Cables – should be consulted before commencing excavation work.

WHEN WORKING IN THE VICINITY OF OVERHEAD LINES THE HEALTH AND SAFETY GUIDANCE NOTES GS6 SHOULD BE CONSULTED (AVAILABLE FROM THE HSE WEBSITE)

Scale: 1:500 (When plotted at A3)

Voltages (V)				
LV (Low Voltage) and Services	Up to 1,000V			
HV (High Voltage)	Over 1,000V to 11,000V			
EHV (Extra High Voltage)	22,000V to 132,000V			
Transmission	275,000V and 400,000V			

NORMAL DEPTH TO THE TOP OF THE CABLE WHEN LAID				
	Services	LV	HV	EHV
Footpath/Unmade	0.45m	0.45m	0.6m	0.8m
Road Crossing	0.6m	0.6m	0.75m	0.9m
Agricultural	1m	1m	1m	1.1m

Legend

Service Cable

LV Mains

2 – 3.3kV

6.6kV

11kV

22kV

33kV

66kV

132kV

275kV

400kV

Fibre Optic

Pilot Cable

Pole, Existing Location

Pole Structure, Existing Location - Single

Pole Structure, Existing Location - H

Duct Route

Cross Section Route

Scottish & Southern
Electricity Networks

Southern Electric Power Distribution plc
Registered Office: No.1 Forbury Place
43 Forbury Road Reading RG1 3JH
Registered In England & Wales No.04094290

If you're unsure & need to seek advice before commencing excavations please contact:
General Enquiries: 0800 048 3516

Subject to revision – Master held by SSEN Asset Data Team:
Asset.Data@sse.com
01256 337 294

BASED UPON THE ORDNANCE SURVEY MAP WITH THE SANCTION OF THE CONTROLLER OF THE STATIONERY OFFICE CROWN COPYRIGHT RESERVED.

This copy has been made by or with the authority of Scottish and Southern Energy Power Distribution Ltd. Pursuant to section 47 of the Copyright, Designs and Patents Act 1988 ('The Act'). Unless the Act provides a relevant exception to copyright the copy must not be copied without prior permission of the copyright owner. Plans generated by DigSAFE Pro™ software provided by LinesearchbeforeUdig.