


WORKS MUST COMPLY IN FULL WITH THE REQUIREMENTS SET OUT IN THE HAMPSHIRE COUNTY COUNCIL PROPERTY SERVICES STANDARD SPECIFICATIONS PART A AND PART B.
PART A: GENERAL REQUIREMENTS, CONDITIONS AND PROCEDURES
PART B: STANDARD SPECIFICATION FOR MATERIALS, WORKMANSHIP AND INSTALLATION OF ELECTRICAL SERVICES.


- A. This drawing is © copyright Hampshire County Council 2023. No unauthorised reproduction of any kind is permitted.
- B. No dimensions to be scaled from this drawing. Verify all dimensions prior to construction. Immediately report any discrepancies on the document to the Architect/Contract Administrator. This document shall be read in conjunction with associated models, specifications and related consultant's documents.
- C. Drawing to be read with all relevant Architectural, Structural, M&E, Drainage/Public Health, Landscape, Civils and Interiors drawings and specifications.
- D. This map is reproduced from Ordnance Survey material with the permission of Ordnance Survey Material on behalf of the controller of Her Majesty's Stationery Office © Crown Copyright. Unauthorised reproduction infringes Crown Copyright & may lead to prosecution or civil proceedings (10001980) 2023.
- E. Read this drawing in conjunction with all other tender and contract documentation issued for this project.
- F. The installation shall be carried out in strict accordance with the project tender drawings, electrical works brief, HCC standard specifications and the current edition of the wiring regulations (BS7671).
- G. Final positions of all equipment shall be agreed on site with the CA prior to installation.
- H. The contractor shall coordinate the works with all other trades prior to commencement.
- I. Where any of the existing installation detailed to be reused is found to be of a dubious standard, then instructions should be sought from the CA.
- J. Liaise & coordinate with all specialist contractors employed for the works.
- K. Isolate, remove and dispose any existing services to allow works to take place. All items of equipment to be removed and not reused shall be offered to the client's representative and if not required, confirmation for their disposal shall be obtained from the CA.

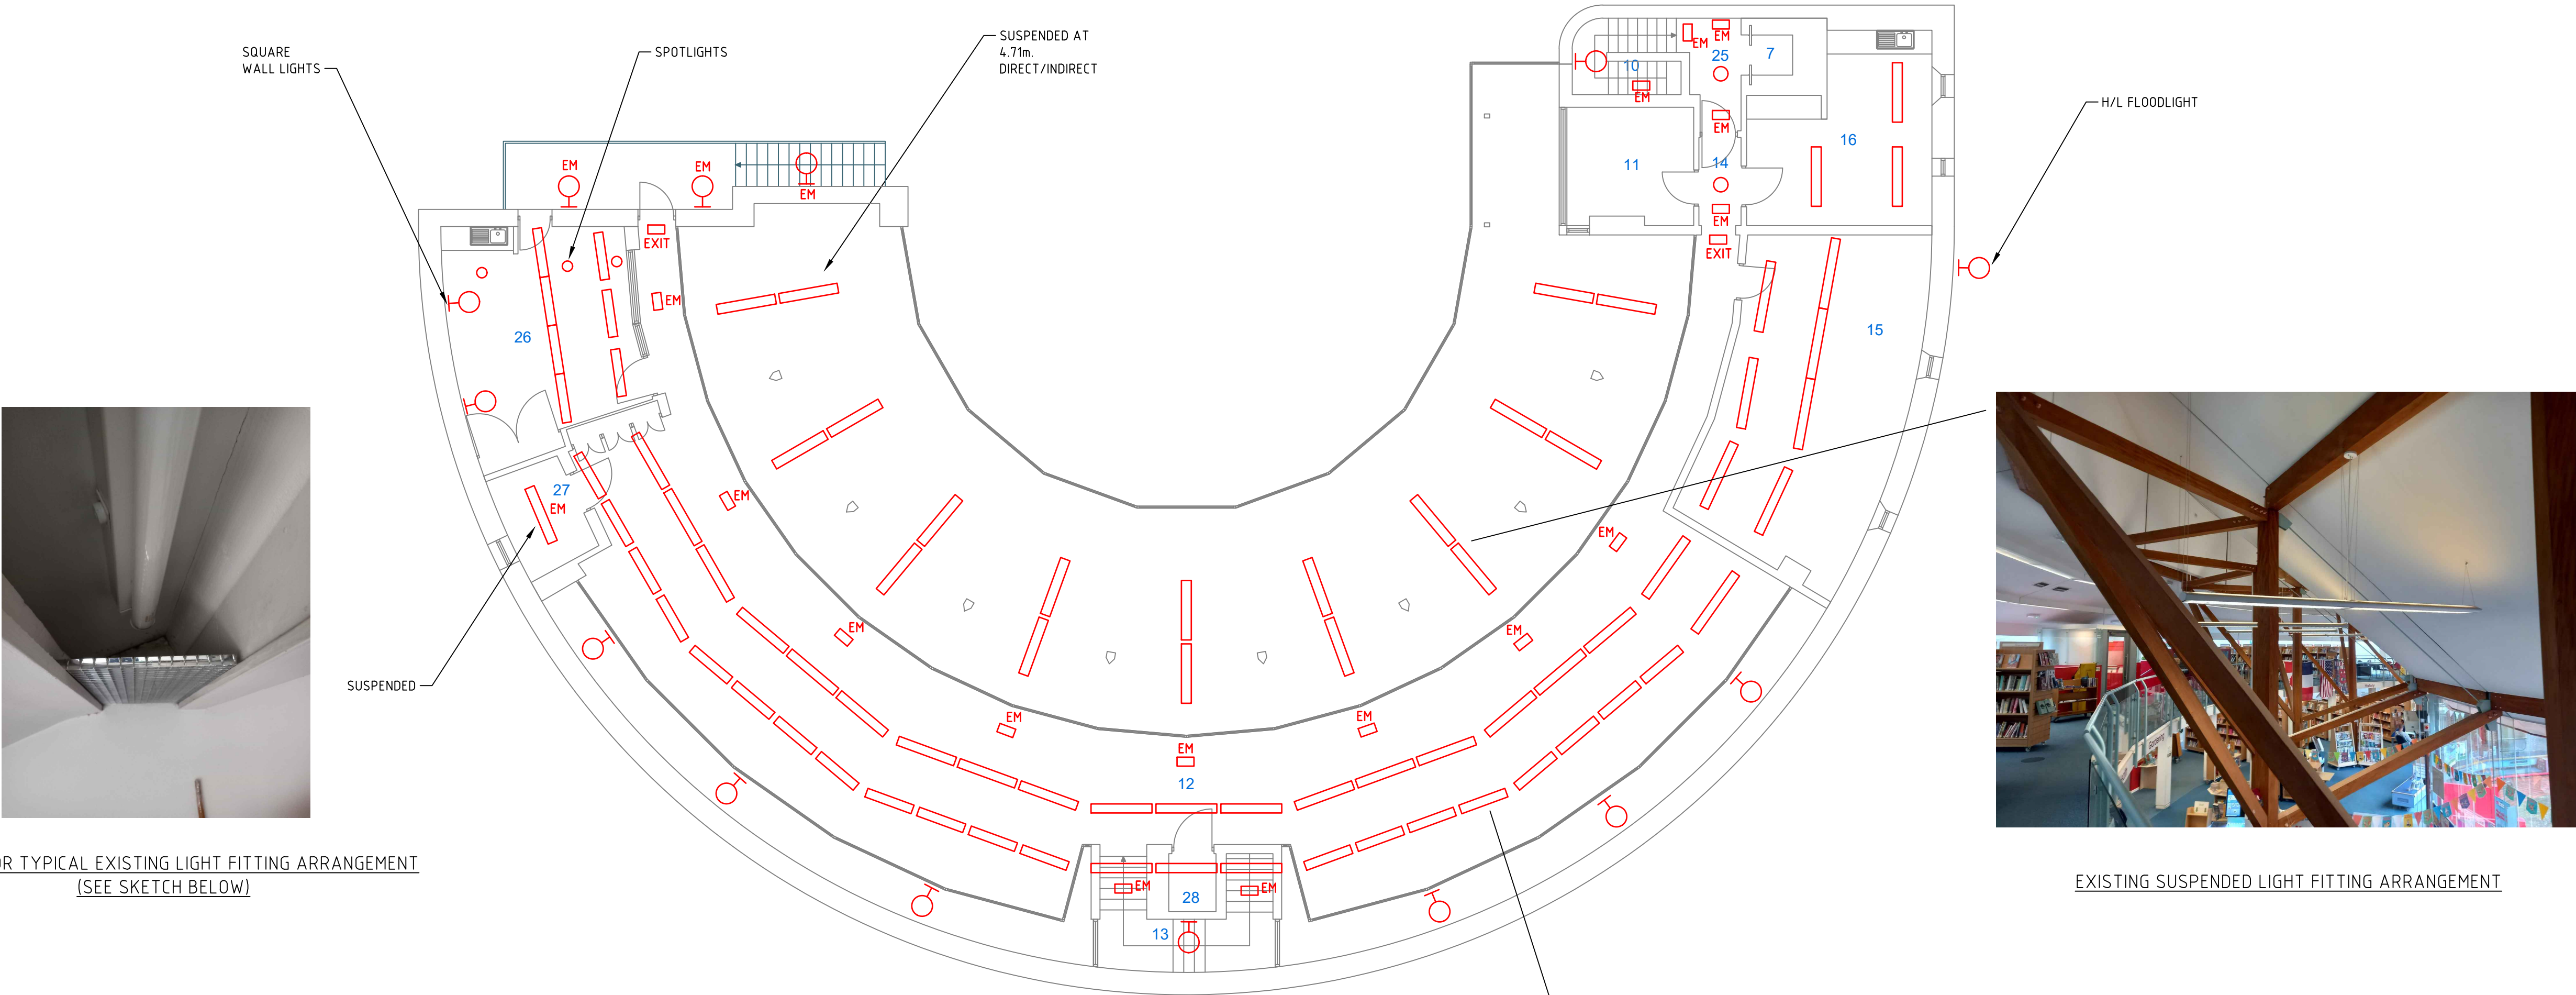


FIRST FLOOR TYPICAL EXISTING LIGHT FITTING ARRANGEMENT
(SEE SKETCH BELOW)



EXISTING SUSPENDED LIGHT FITTING ARRANGEMENT

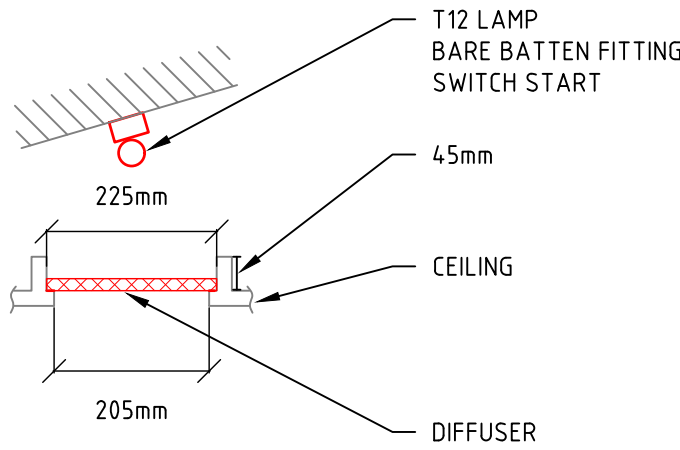

SKETCH ARRANGEMENT
NTS

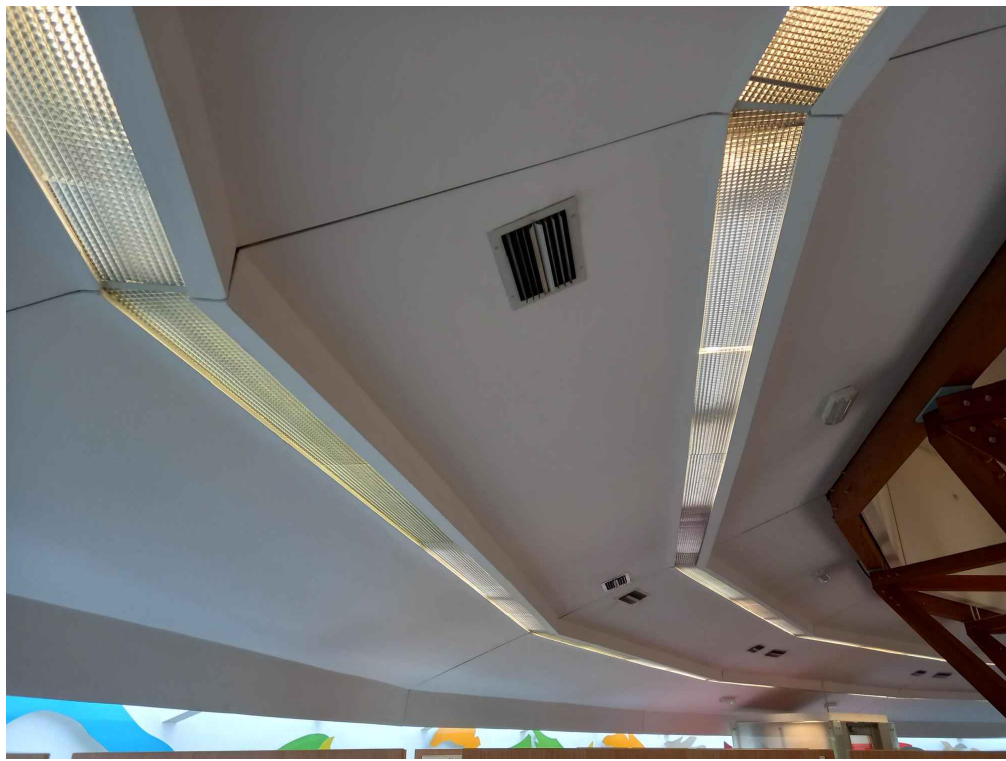

FIRST FLOOR EXISTING LIGHT FITTING ARRANGEMENT

Rev	Description	Date	By	Chkd

Universal Services,
Elizabeth II Court,
Sussex Street, Winchester SO23 8BH
Tel: (01962) 847801



Chandlers Ford Library
LED Lighting

Electrical Engineering Services
Existing Lighting Layout
First Floor

SCALE	DRAWN	CHKD	APRV
1 : 100@ A1	EM	MA	IP

DRAWING No.
project code - originator - volume - level - type - role - number revision
P14506-HCC-PS-00-DR-E-8202 T0

September, 2024
Tender Issue