


WORKS MUST COMPLY IN FULL WITH THE REQUIREMENTS SET OUT IN THE HAMPSHIRE COUNTY COUNCIL PROPERTY SERVICES STANDARD SPECIFICATIONS PART A AND PART B.
PART A: GENERAL REQUIREMENTS, CONDITIONS AND PROCEDURES
PART B: STANDARD SPECIFICATION FOR MATERIALS, WORKMANSHIP AND INSTALLATION OF ELECTRICAL SERVICES.

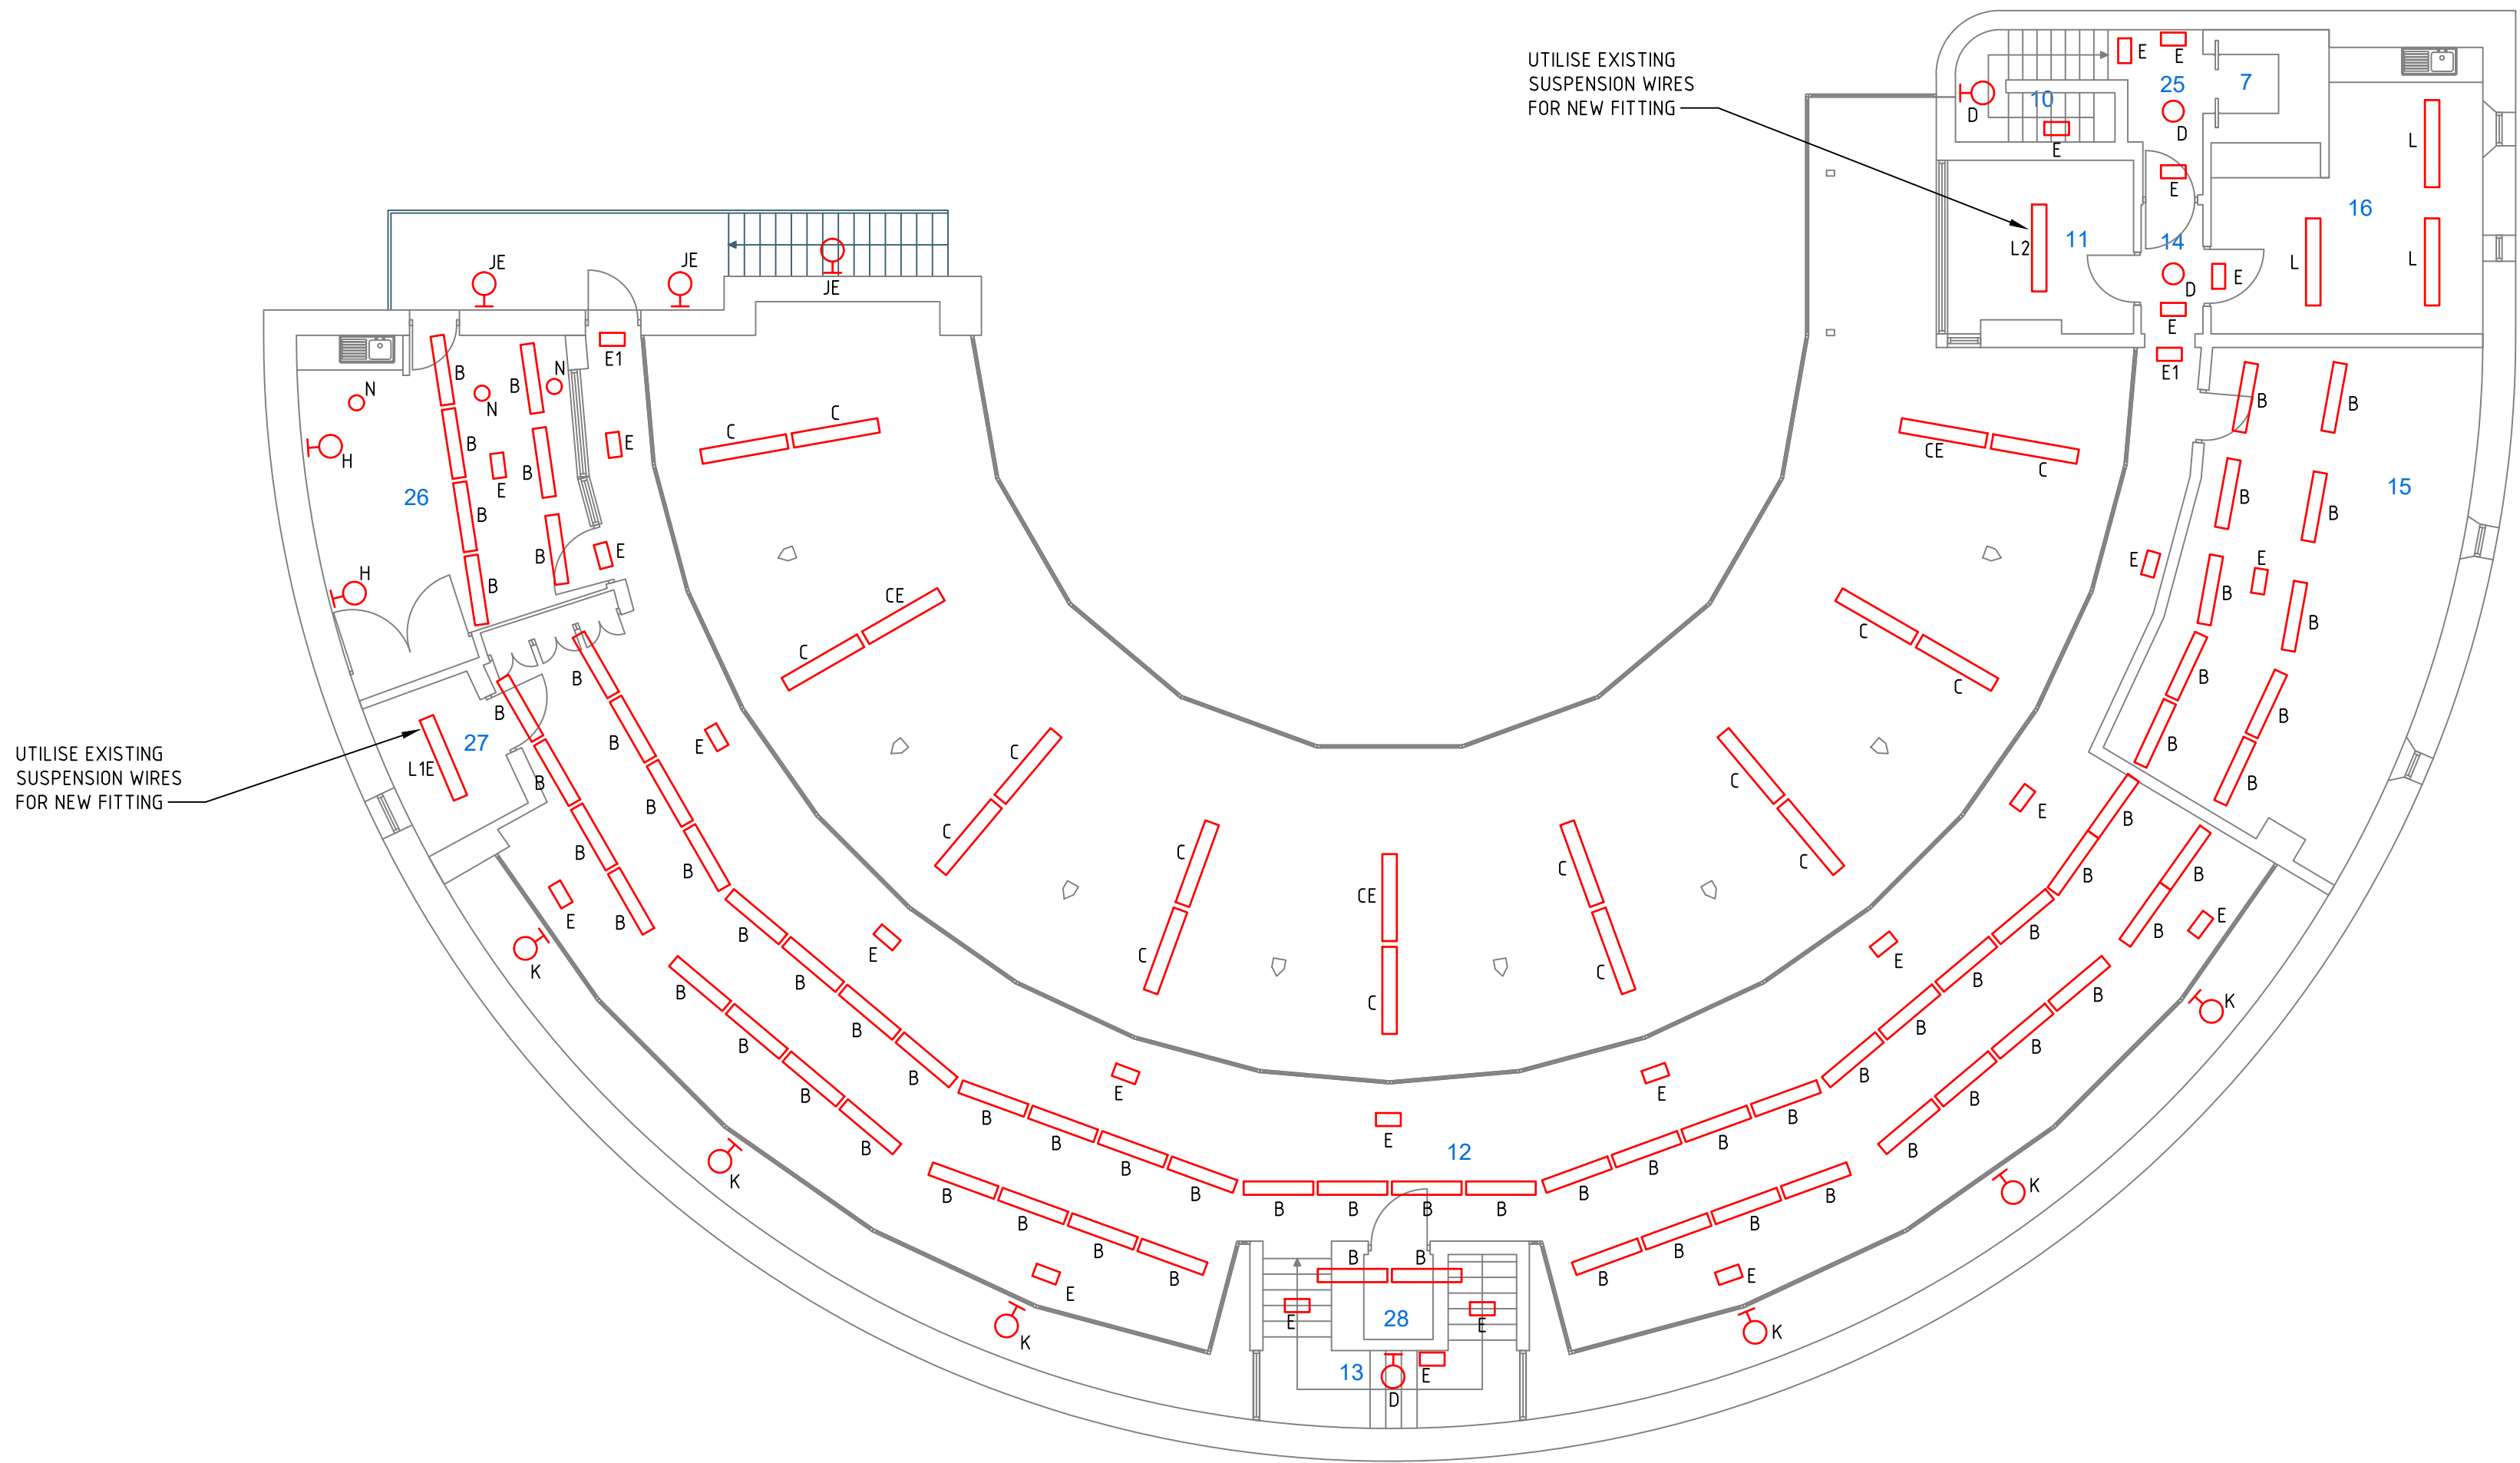

LUMINAIRE SCHEDULE			
TYPE	REFERENCE	DESCRIPTION	MANUFACTURER/RANGE
A	MODLP 151 L35	2622 LLM, 24.4W, 4000K,	DEXTRA/MODLP
B	EPK L26	2284LLM, 4000K, ECOPAK 1200	DEXTRA/ECOPAK
C	ELBD 15L68	5660LLM, 4000K / ELEMENT 1500 MICROPRISM / BI-DIRECTIONAL / SUSPENSION	DEXTRA/ELEMENT
CE	ELBD 15L68 LE3	AS ABOVE BUT 3HR EMERGENCY VERSION	DEXTRA/ELEMENT
D	AMED L30	2427LLM, 19.7W, 4000K, AMENITY DECORATIVE, WHITE OPAL	DEXTRA/AMENITY
E	AME2 NM3 LE3	AME2 NON MAINTAINED / LITHIUM E3	DEXTRA/AME2
E1	EXI3 NM3 LE3	EXI3 NON MAINTAINED / LITHIUM E3 / COMPLETE WITH 4 LEGEND PACK	DEXTRA/EXI3
E2	EXI LED M3 LE3	EXI, MAINTAINED, LITHIUM STANDARD EMERGENCY 3 HOUR. SURFACE MOUNTED	DEXTRA/EXI3
FE	MODRS L45	3484LLM 4000K, MODSLIM 600X600 LAY-IN LITHIUM E3	DEXTRA/MODSLIM

GE	SRN L38 PC	3154LLM, 4000K, SIREN 1200	DEXTRA SIREN
H	VOL L20	1376LLM, 16.8W, 4000K, VOLITO OPAL DIFFUSER, LIGHT GREY BEZEL, RECTANGULAR	DEXTRA/VOLITO
J	OPUWP L30 OA	2494LLM, 17.8W, 4000K, OPUS WALLPACK OPEN AREA, BLACK FINISH	DEXTRA/OPUS
JE	OPUWP L30 OA LE3	AS ABOVE BUT 3HR EMERGENCY VERSION	DEXTRA/OPUS WALLPACK
K	OPUS3 L20 C74	1538LLM, 4000K, OPUS 3 SMALL	DEXTRA/OPUS3
L	GRD L45 OPTPA	3703LLM, 4000K, GRADUATE 1500	DEXTRA/GRADUATE
L1E	GRD L54 LE3 OPTPA	4443LLM, 4000K, GRADUATE 1500 LITHIUM E3	DEXTRA/GRADUATE
L2	GRD L63 OPTPA	5184LLM, 4000K, GRADUATE 1500	DEXTRA/GRADUATE
M	COUS LS L30 40 GB	2102LLM, 4000K, 40°, COULIS MINI GLOBAL, WHITE	DEXTRA/COULIS
N	PTECMI L02	177 LLM, 2.9W, 4000K, PROTEC MICRO, WHITE FINISH	DEXTRA/PROTEC
OE	AMC L15 B0	1500 LLM, 13.4W, 4000K, CIRCULAR	DEXTRA/AMENITY

- A. This drawing is © copyright Hampshire County Council 2023. No unauthorised reproduction of any kind is permitted.
- B. No dimensions to be scaled from this drawing. Verify all dimensions prior to construction. Immediately report any discrepancies on the document to the Architect/Contract Administrator. This document shall be read in conjunction with associated models, specifications and related consultant's documents.
- C. Drawing to be read with all relevant Architectural, Structural, M&E, Drainage/Public Health, Landscape, Civils and Interiors drawings and specifications.
- D. This map is reproduced from Ordnance Survey material with the permission of Ordnance Survey Material on behalf of the controller of Her Majesty's Stationery Office © Crown Copyright. Unauthorised reproduction infringes Crown Copyright & may lead to prosecution or civil proceedings (10001980) 2023.
- E. Read this drawing in conjunction with all other tender and contract documentation issued for this project.
- F. The installation shall be carried out in strict accordance with the project tender drawings, electrical works brief, HCC standard specifications and the current edition of the wiring regulations (BS7671).
- G. Final positions of all equipment shall be agreed on site with the CA prior to installation.
- H. The contractor shall coordinate the works with all other trades prior to commencement.
- I. Where any of the existing installation detailed to be reused is found to be of a dubious standard, then instructions should be sought from the CA.
- J. Liaise & coordinate with all specialist contractors employed for the works.
- K. Isolate, remove and dispose any existing services to allow works to take place. All items of equipment to be removed and not reused shall be offered to the client's representative and if not required, confirmation for their disposal shall be obtained from the CA.



Rev	Description	Date	By	Chd

Universal Services,
Elizabeth II Court,
Sussex Street, Winchester SO23 8BH
Tel: (01962) 847801

Hampshire
County Council
Property Services

Chandlers Ford Library
LED Lighting

Electrical Engineering Services
Proposed New Lighting Layout
First Floor

SCALE 1 : 100@ A1

DRAWN EM

CHKD MA

APRV IP

DRAWING No.
project code - originator - volume - level - type - role - number revision

P14506-HCC-PS-00-DR-E-8203 T0

September, 2024

Tender Issue