


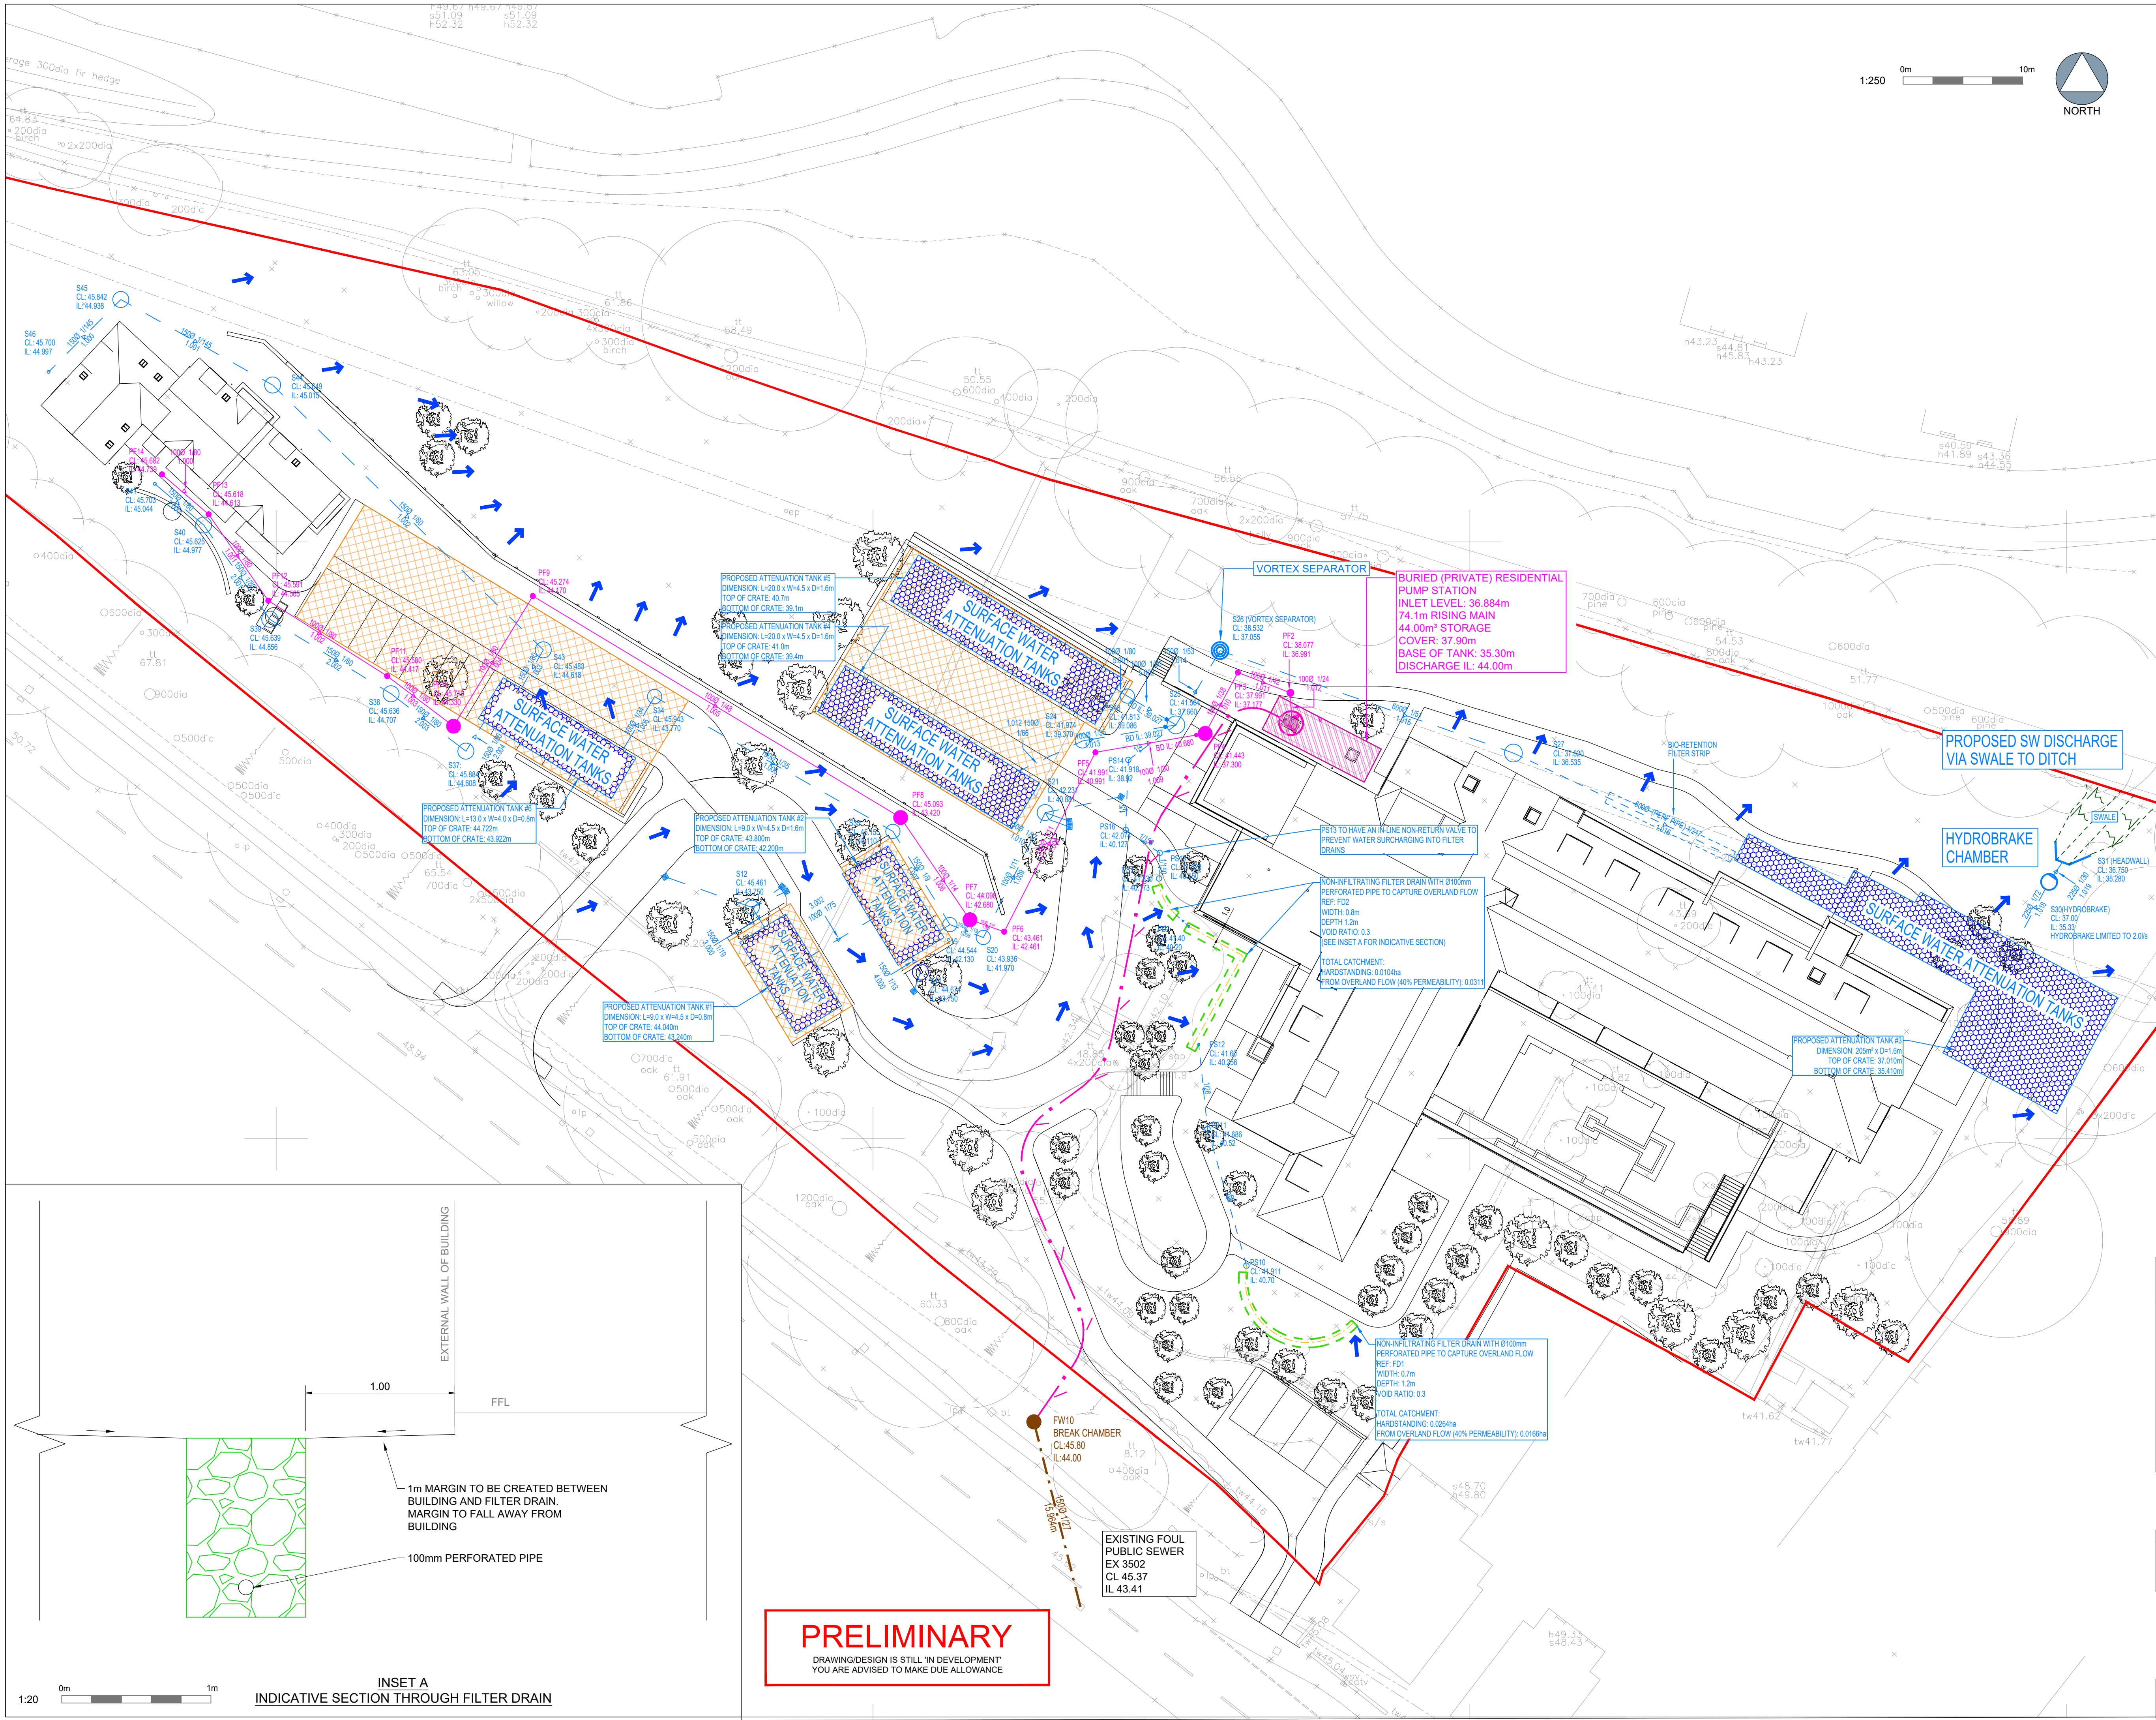

The drawings, information and data recorded in this document ("the information") is the property of Paul Basham Associates. This document and the information are solely for the use of the authorised recipient and this document may not be used, copied or reproduced in whole or part for any purposes other than which it was supplied by Paul Basham Associates. Paul Basham Associates makes no representation, undertakes no duty and accepts no responsibilities to any third party who may use or rely upon this document or the information.

GENERAL NOTES

- THIS DRAWING IS INTENDED TO BE READ IN CONJUNCTION WITH ALL RELEVANT ARCHITECTS, ENGINEERS, SERVICES AND SPECIALIST DRAWINGS, DETAILS AND SPECIFICATIONS.
- ANY VARIATIONS OR DISCREPANCIES BETWEEN THESE DRAWINGS IN TERMS OF DIMENSIONS OR DETAILS SHOULD BE DRAWN TO THE ATTENTION OF THE ARCHITECT AND/OR THE ENGINEER FOR CLARIFICATION.
- ALL FIGURED DIMENSIONS TO BE TAKEN IN PREFERENCE TO SCALED DIMENSIONS.
- PAUL BASHAM ASSOCIATES ACCEPTS NO RESPONSIBILITY FOR THE ACCURACY OF BACKGROUND INFORMATION PRODUCED BY THIRD PARTIES - THIS MUST BE TREATED AS INDICATIVE ONLY.
- THE MAIN CONTRACTOR SHALL BE RESPONSIBLE FOR THE SETTING OUT AND ACCURACY OF ALL DIMENSIONS.
- THIS DRAWING SHOULD ONLY BE USED FOR CONSTRUCTION IF THE PROJECT PHASE IN THE TITLE FRAME BELOW IS SHOWN AS "CONSTRUCTION". PAUL BASHAM ASSOCIATES TAKE NO RESPONSIBILITY FOR CONSTRUCTION WORKS UNDERTAKEN TO DRAWINGS WHICH ARE NOT MARKED UNDER THIS PHASE.
- NOTE: PROPOSED TREES ENCROACHING ATTENUATION TANKS WILL REQUIRE ROOT BARRIERS OR TREE PITS
- PAUL BASHAM ASSOCIATES ACCEPTS NO RESPONSIBILITY FOR THE ACCURACY OF BACKGROUND INFORMATION PRODUCED BY THIRD PARTIES - THIS MUST BE TREATED AS INDICATIVE ONLY.

ARCHITECTS LAYOUT MASTERPLAN RECEIVED: 18.07.24
REFER TO DRAWING 6185-WLA-22-00-DR-A-0110-1 PROPOSED SITE PLAN

LEGEND:

- SITE BOUNDARY
- ADOPTABLE FOUL WATER SEWER
- ADOPTABLE STORM WATER SEWER
- PRIVATE FOUL WATER DRAIN
- PRIVATE STORM WATER DRAIN (Ø100 U.N.O)
- FOUL WATER RISING MAIN
- ADOPTABLE FOUL WATER MANHOLE
- ADOPTABLE SURFACE WATER MANHOLE
- PRIVATE FOUL WATER CHAMBER
- PRIVATE SURFACE WATER CHAMBER / CATCHPIT
- ROAD GULLY
- FINISHED FLOOR LEVELS
- VORTEX SEPARATOR
- HYDROBRAKE CHAMBER
- HEADWALL
- SURFACE WATER ATTENUATION TANKS
- F.W. PUMPING STATION
- PERMEABLE PAVING
- SWALE
- NON-INFILTRATING FILTER DRAIN WITH PERFORATED PIPE
- PROPOSED EXCEEDANCE FLOW PATH

P06	SITE LAYOUT UPDATED, FILTER DRAIN LOCATION AMENDED AND INSET A ADDED	27.03.2025	RRD	COH
P05	FILTER DRAINS CONNECTED TO NETWORK AND AREAS ADDED	22.01.2025	NOH	DP
P04	FILTER DRAINS INCLUDED FOR OVERLAND FLOW	05.11.2024	NOH	HN
P03	UPDATED TO LATEST ARCHITECT'S LAYOUT	24.07.2024	CDA	NOH
P02	UPDATED TO LATEST ARCHITECT'S LAYOUT	05.04.2024	RL	RW
P01	FIRST ISSUE	25.03.2024	RL	RW
Rev	Description	Date	By	App'd

paulbasham associates

Paul Basham Associates Ltd
The Botley, Cambs Hall Estate, Farnham, PO16 8UT
01329 711 000
info@paulbashamassociates.com www.paulbashamassociates.com

COLTEN CARE
"Cherishing You"

Project Name:
CARE HOME, BROOKFIELD PROVIDENCE HILL, BURSLEDON

Title:
PROPOSED DRAINAGE STRATEGY LAYOUT

Project Phase:
PLANNING

Date Created	Drawn By	Approved By	Suitability Code
25.03.2024	RL	RW	-
PBA Project Number	Scale	(AT A1)	
197.5004	1:250		
PBA Drawing No:	Revision		
197.5004-0002	P06		

QMS2010V8/310723J.M