


Rev:	Date:	Description:	By:	Chk:
P01	22.05.25	First Issue	MC	SPM
P02	09.06.25	Layout updated: Desk numbers changed to client requirements, glazed screens added, large meeting rooms revised.	KS	SPM
P03	27.06.25	Windows added. Cladding added. Elevation markers shown. Meeting room repositioned. Individual offices renamed and repositioned. Desk layout amended. Locker and storage area included. Separate Universal WC added.	SPM	MC
P04	08.07.25	Exc PA Office increased. Meeting Room increased. Tea point reversed. Minor desk revisions. Departments revised	SPM	MM
P05	17.07.25	Roof access opens into stairwell. Stair door widths revised. Store 224 revised in size.	SPM	MC
P06	28.07.25	PLANNING ISSUE	SPM	MC

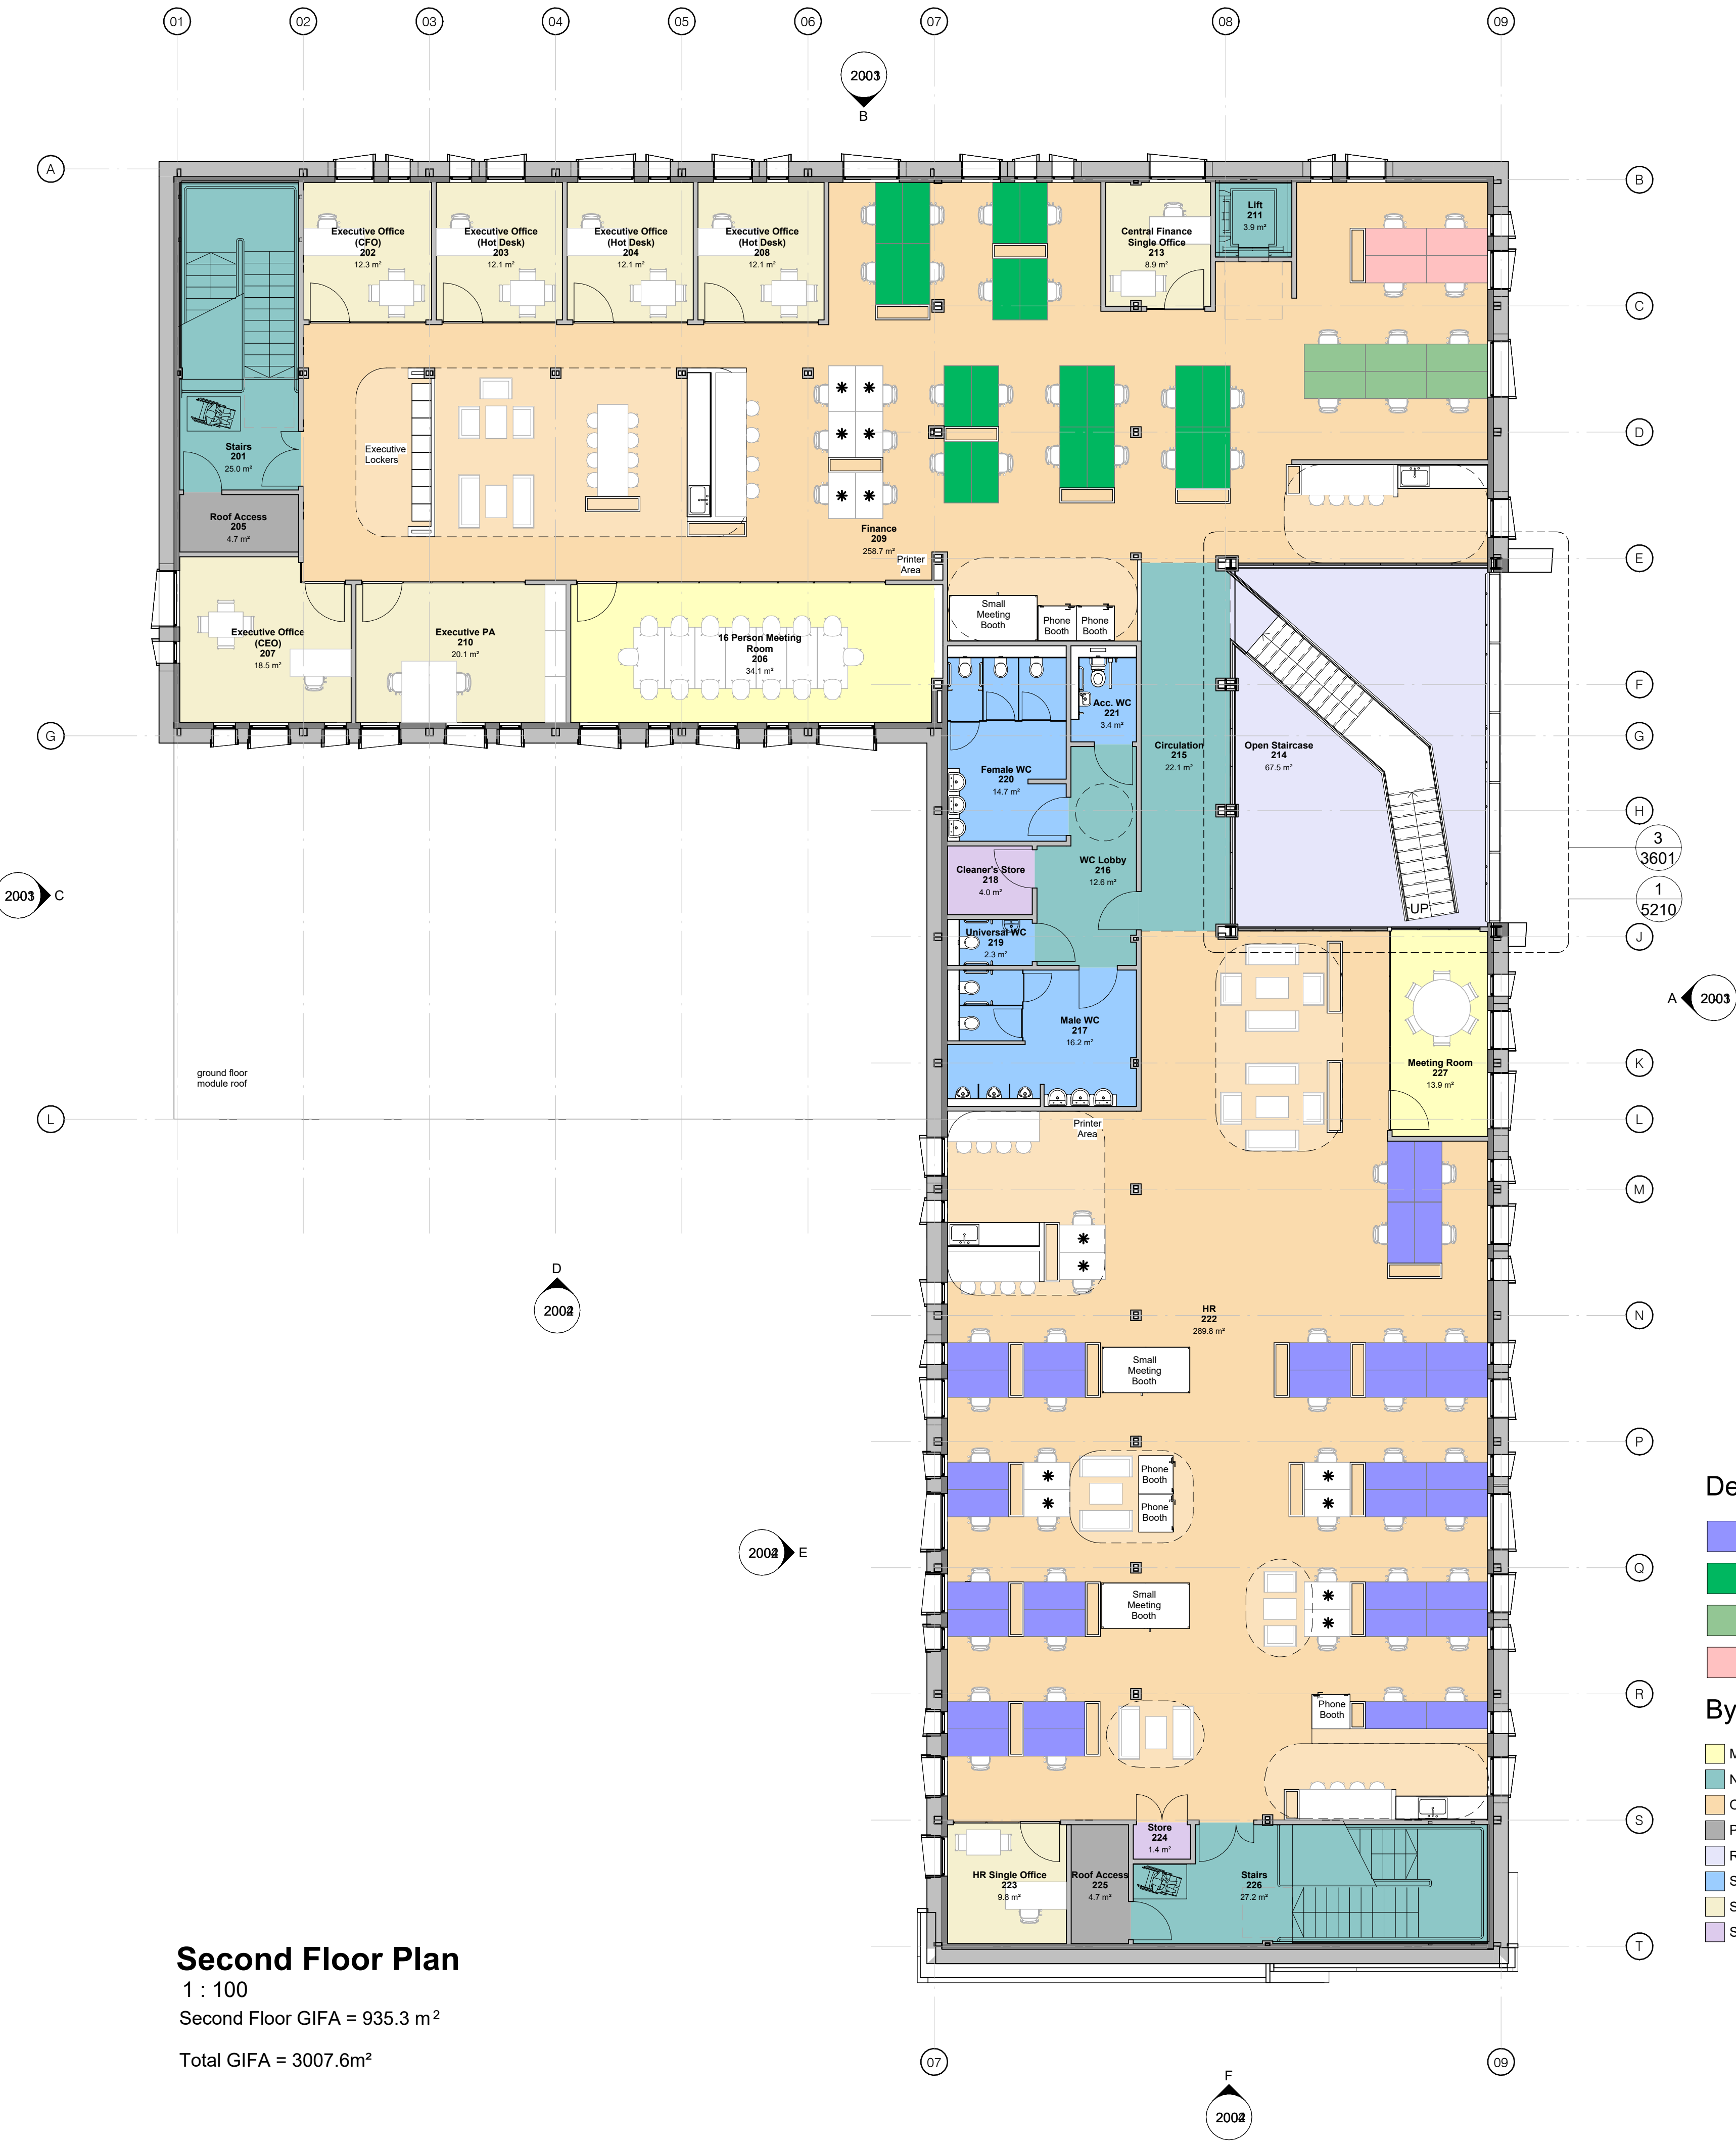

Room Schedule Second Floor			
Level	Number	Name	Area
02 FFL	201	Stairs	25.0 m ²
02 FFL	202	Executive Office (CFO)	12.3 m ²
02 FFL	203	Executive Office (Hot Desk)	12.1 m ²
02 FFL	204	Executive Office (Hot Desk)	12.1 m ²
02 FFL	205	Roof Access	4.7 m ²
02 FFL	206	16 Person Meeting Room	34.1 m ²
02 FFL	207	Executive Office (CEO)	18.5 m ²
02 FFL	208	Executive Office (Hot Desk)	12.1 m ²
02 FFL	209	Finance	258.7 m ²
02 FFL	210	Executive PA	20.1 m ²
02 FFL	211	Lift	3.9 m ²
02 FFL	213	Central Finance Single Office	8.9 m ²
02 FFL	214	Open Staircase	67.5 m ²
02 FFL	215	Circulation	22.1 m ²
02 FFL	216	WC Lobby	12.6 m ²
02 FFL	217	Male WC	16.2 m ²
02 FFL	218	Cleaner's Store	4.0 m ²
02 FFL	219	Universal WC	2.3 m ²
02 FFL	220	Female WC	14.7 m ²
02 FFL	221	Acc. WC	3.4 m ²
02 FFL	222	HR	289.8 m ²
02 FFL	223	HR Single Office	9.8 m ²
02 FFL	224	Store	1.4 m ²
02 FFL	225	Roof Access	4.7 m ²
02 FFL	226	Stairs	27.2 m ²
02 FFL	227	Meeting Room	13.9 m ²

Note: This drawing is to be used for 'G.A Floor Plan' purposes only

This drawing to be read in conjunction with Portakabin Limited drawing numbers:

16894 - PTK-A1-00-D-A-1002 - Ground Floor Plan
16894 - PTK-A1-01-D-A-1010 - First Floor Plan
16894 - PTK-A1-03-D-A-1011 - Roof Plan
16894 - PTK-A1-22-D-A-2001 - Elevations 1 of 2
16894 - PTK-A1-22-D-A-2002 - Elevations 2 of 2
16894 - PTK-A1-22-D-A-3001 - Sections AA & BB
16894 - PTK-A1-22-D-A-3002 - Sections CC & DD

Note: This drawing is to be read in conjunction with Mechanical & Electrical Sub-Contractor detail design drawings and specifications for alarm detection, emergency lighting, illuminated exit signage etc.



Status: S2
Purpose Of Issue: PLANNING ISSUE
Client:

Workdry International
Project: Headquarters Office

Title: Second Floor Plan

Scale @ A1: 1 : 100
Date: 09.05.2025
Drawn By: SPM
Checked By: MC

Opportunity Number: OPP1365735
Project Number: 16894

Document Number: PTK - A1 - 02 - D - A - 1004
Rev: P06

