





Section AA
1 : 100

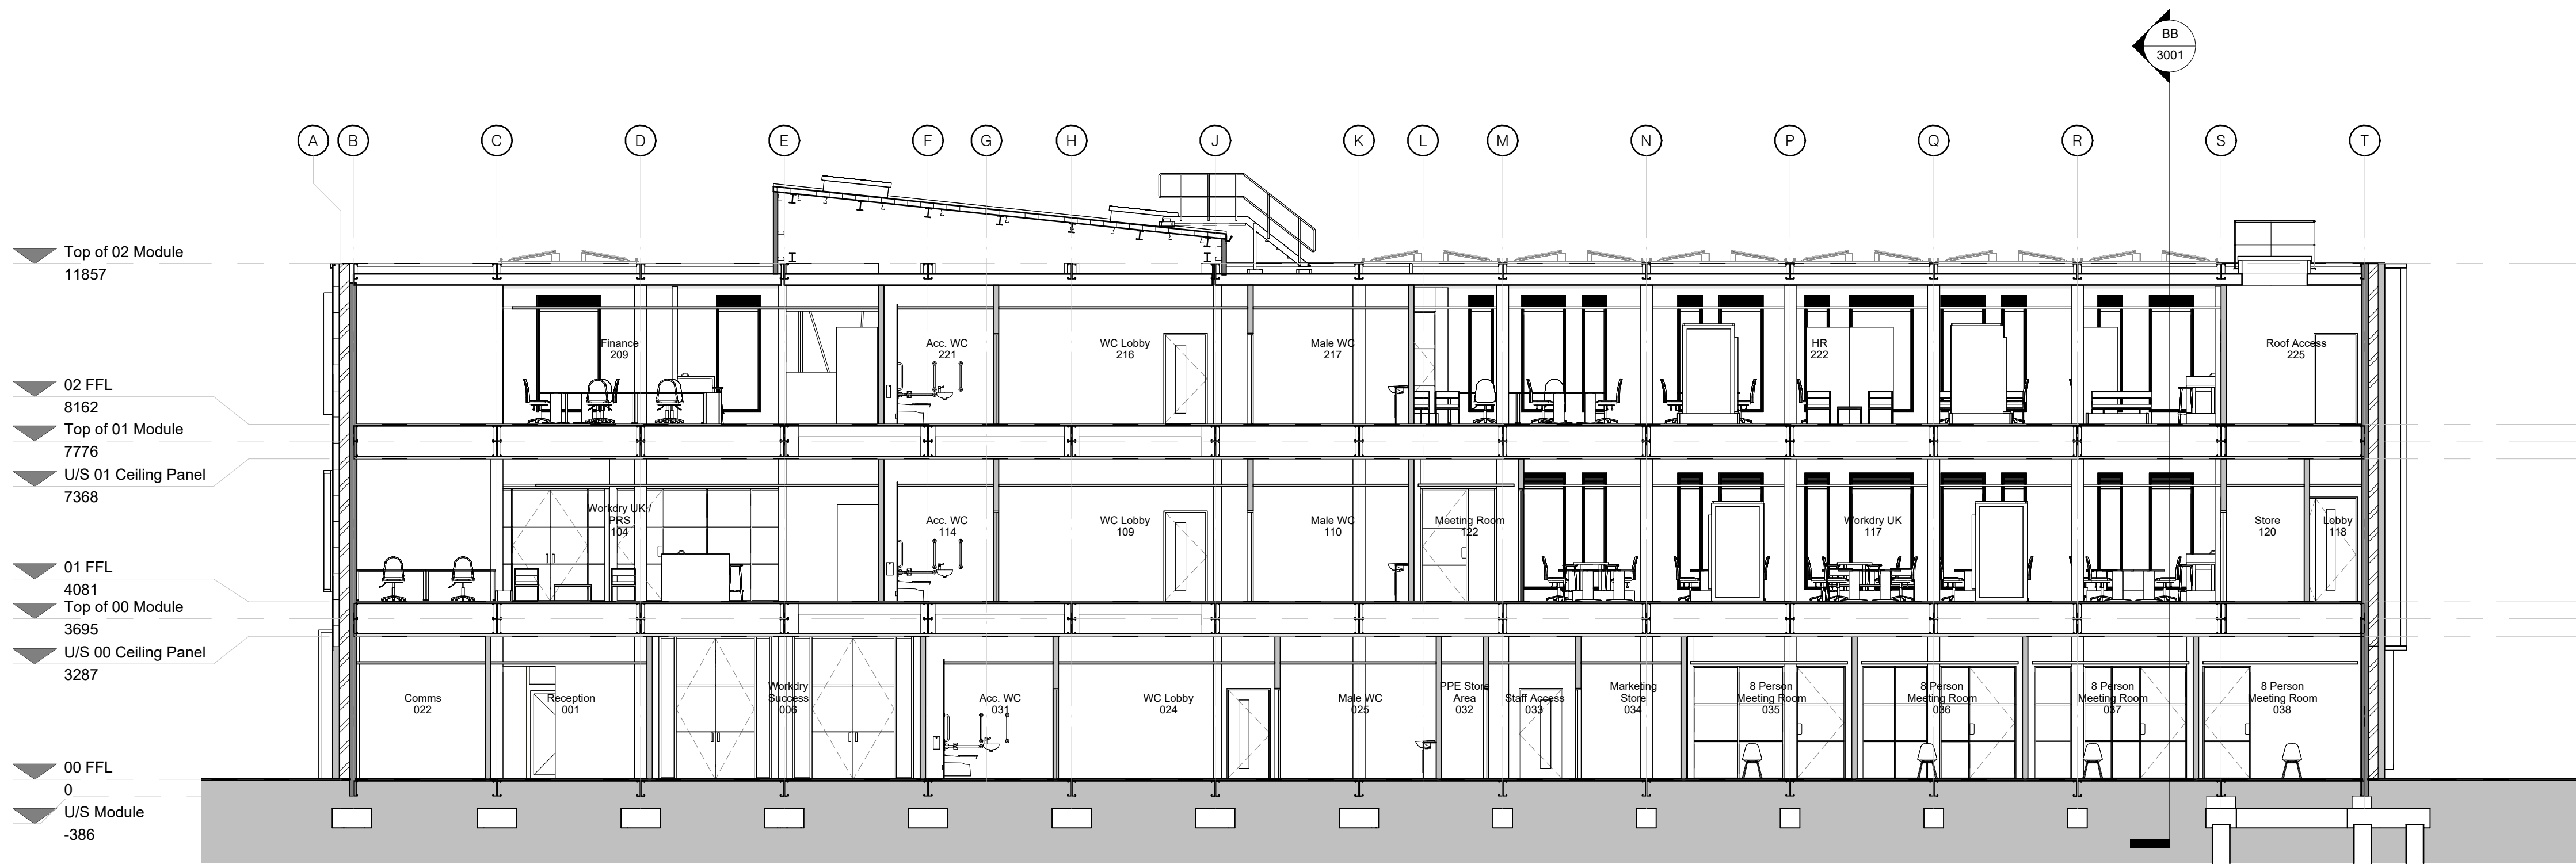

Section BB
1 : 100

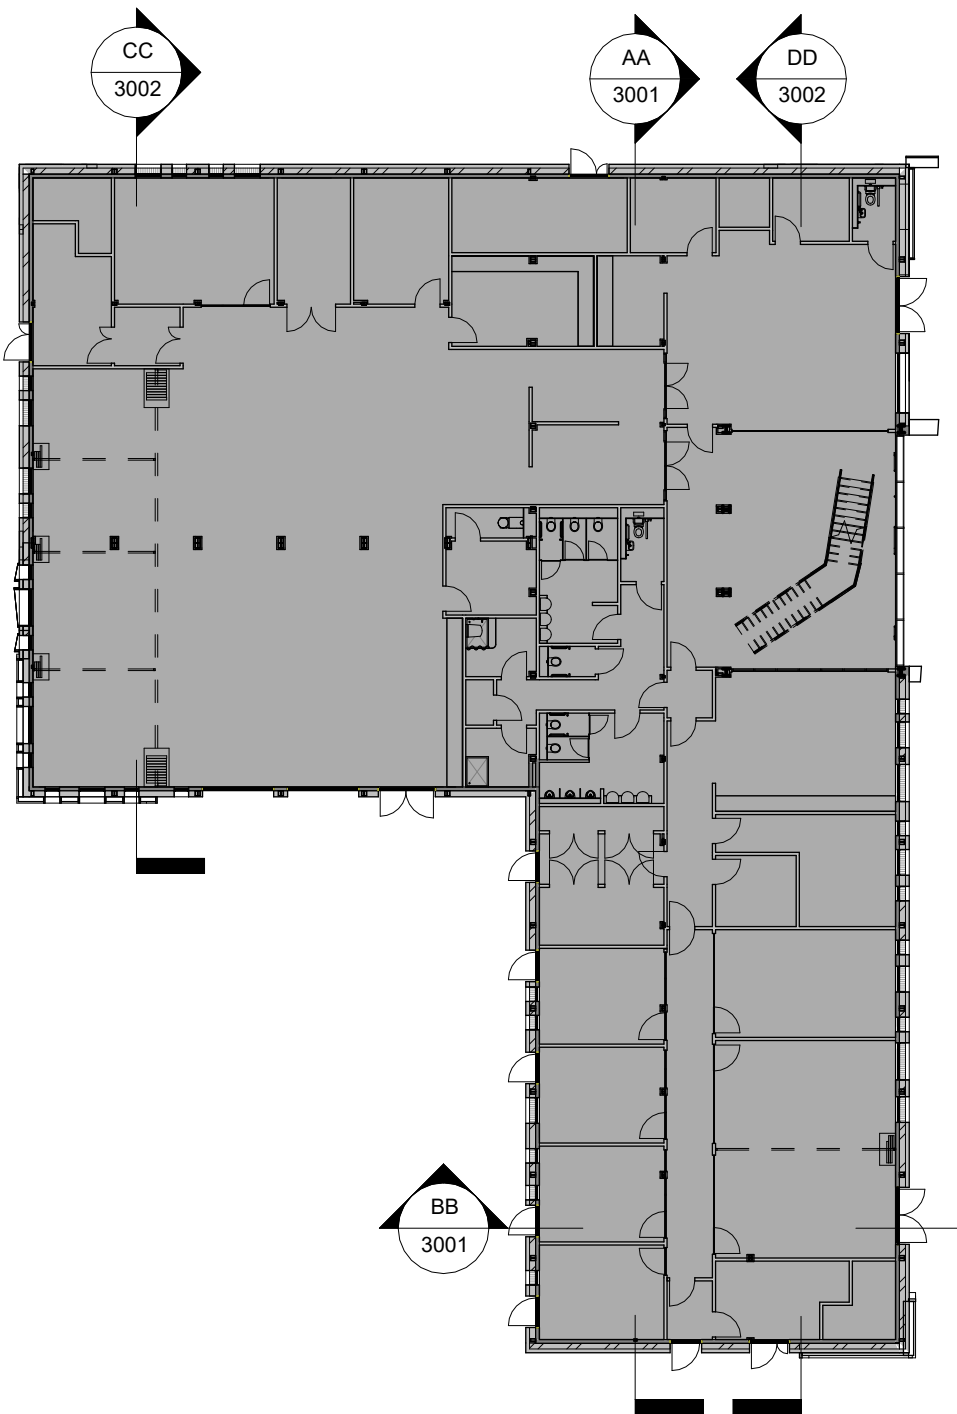

Note: This drawing is to be used for 'Section' purposes only
This drawing to be read in conjunction with Portakabin Limited drawing numbers:

16894 - PTK-A1-00-D-A-1002 - Ground Floor Plan
16894 - PTK-A1-01-D-A-1003 - First Floor Plan
16894 - PTK-A1-02-D-A-1004 - Second Floor Plan
16894 - PTK-A1-01-D-A-1010 - Roof Plan - First Floor
16894 - PTK-A1-03-D-A-1011 - Roof Plan
16894 - PTK-A1-ZZ-D-A-2001 - Elevations 1 of 2
16894 - PTK-A1-ZZ-D-A-2002 - Elevations 2 of 2
16894 - PTK-A1-ZZ-D-A-3002 - Sections CC & DD

Note: This drawing is to be read in conjunction with Mechanical & Electrical Sub-Contractor detail design drawings and specifications for alarm detection, emergency lighting, illuminated exit signage etc.



Status: S2 Purpose Of Issue: PLANNING ISSUE

Client:

Workdry International

Project:

Headquarters Office

Title:

Sections AA & BB

Scale @ A1: As indicated Date: 28.07.2025 Drawn By: SPM Checked By: MC

Opportunity Number: OPP1365735 Project Number: 16894

Document Number: PTK - A1 - ZZ - D - A - 3001 Rev: P01