

A/C Schedule

Ref	Make	Model	Location	Type	Electrical Requirement
FC1	Daikin	FCAG125	Customer seating area	Ceiling Cassette	Interconnecting
FC2	Daikin	FCAG125	Customer seating area	Ceiling Cassette	Interconnecting
FC3	Daikin	FFA35	BOH	Ceiling Cassette	Interconnecting
CU1	Daikin	RZAG125	External unit	Condenser	1ph 32A
CU2	Daikin	RZAG125	External unit	Condenser	1ph 32A
CU3	Daikin	R2AG35A	External unit	Condenser	1ph 32A

*HVAC contractor to check pipe run lengths against specified units

Extract Grille Schedule


Ref	Type	Size
E1	Air Valve	200Ø
E2	Advanced Air GC Eggcrate	595SQ
E3	Air Valve	200Ø
E4	Air Valve	200Ø
E5	Advanced Air GC Eggcrate	595SQ
E6	Advanced Air GC Eggcrate	595SQ
E7	Air Valve	100Ø
E8	Air Valve	100Ø

Door Curtain Schedule

Ref	Make	Model	Rating
DC1	Thermoscreen	C1000E RECESSED	12kW 3PHS

Fan Schedule

Ref	Make	Model	Function	Location	Controller	Electrical Req'
EF1	Soler & Palau	TD-2000/315	Back of House Extract	Void above staff room	SP5010	TBC
EF2	Soler & Palau	TD-500/150	W.C. Extract	Void above Dis W.C	N/A	TBC

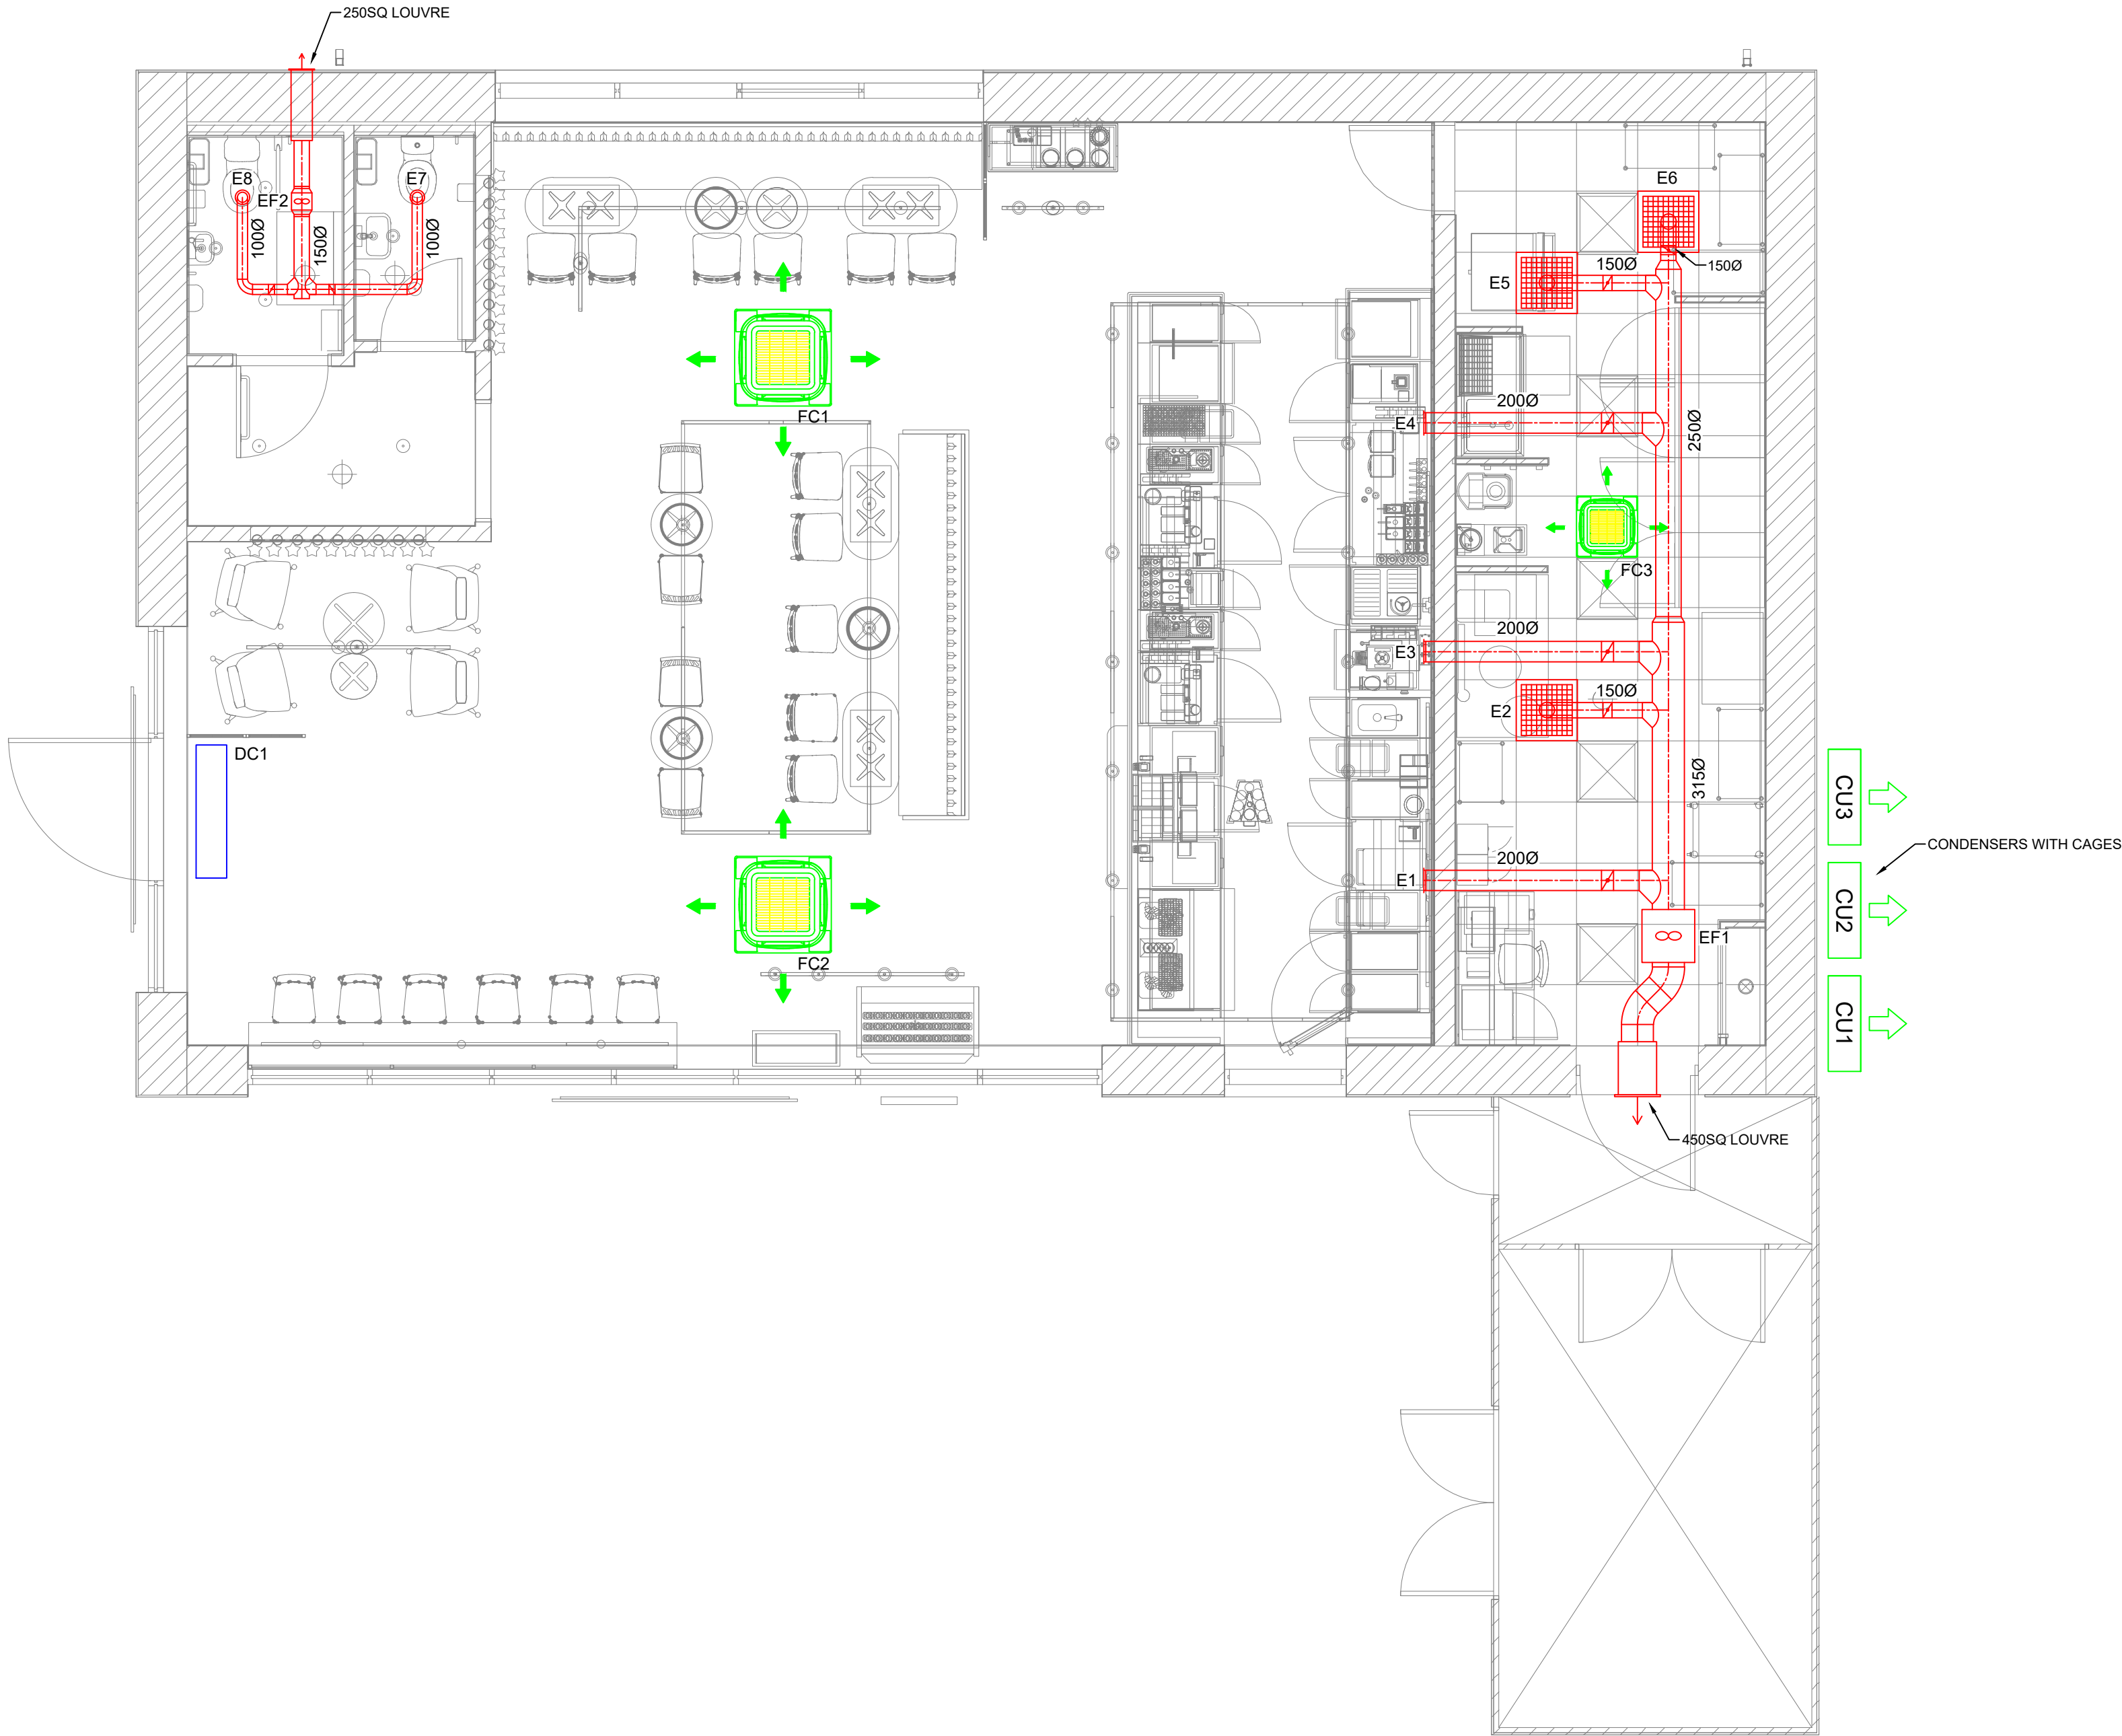

ALL RIGHTS RESERVED. THE COPYRIGHT OF THIS DRAWING IS WITH ECO CLIMATE CONTROLS LTD. NO PART OF THIS DRAWING MAY BE REPRODUCED, STORED WITHIN A RETRIEVAL SYSTEM, OR TRANSMITTED TO OTHER PARTIES, WITHOUT PRIOR WRITTEN PERMISSION FROM ECO CLIMATE CONTROLS LTD. THIS DRAWING IS OFFERED ONLY FOR THE PURPOSE OF THE SERVICES INTENDED.
ALL LEVELS AND DIMENSIONS ARE TO BE VERIFIED ON-SITE BEFORE COMMENCEMENT OF WORKS. PLEASE NOTIFY THE ORIGINATOR OF THIS DRAWING SHOULD DIFFERENCES BE NOTED. ALL DIMENSIONS ARE IN MILLIMETERS (MM) UNLESS STATED OTHERWISE. DO NOT SCALE FROM THIS DRAWING.
NO THIRD PARTY RIGHTS ARE INTENDED BY THIS DRAWING.

NOTES:



THE FOLLOWING DRAWINGS ARE USED AS BASE REFERENCES:

P1	24.06.25	Proposed HVCA Plan	MRE	MPR
Issue:	Date:	Revision details:	Drawn:	Chkd:

Scale	1:50 @ A1	Design	PM	MR	Date	June '25
-------	-----------	--------	----	----	------	----------

Eco Climate Control Ltd.



Project

STARBUCKS
HEDGE END

Title

PROPOSED MECHANICAL
LAYOUT PLAN

Drawing No. XXX/X/XXX

Rev. P1

20 Little Oxfey, West Malling
Kent, ME19 5QU
Tel/Fax: 01732-321633
www.ecoclimatecontrol.co.uk