


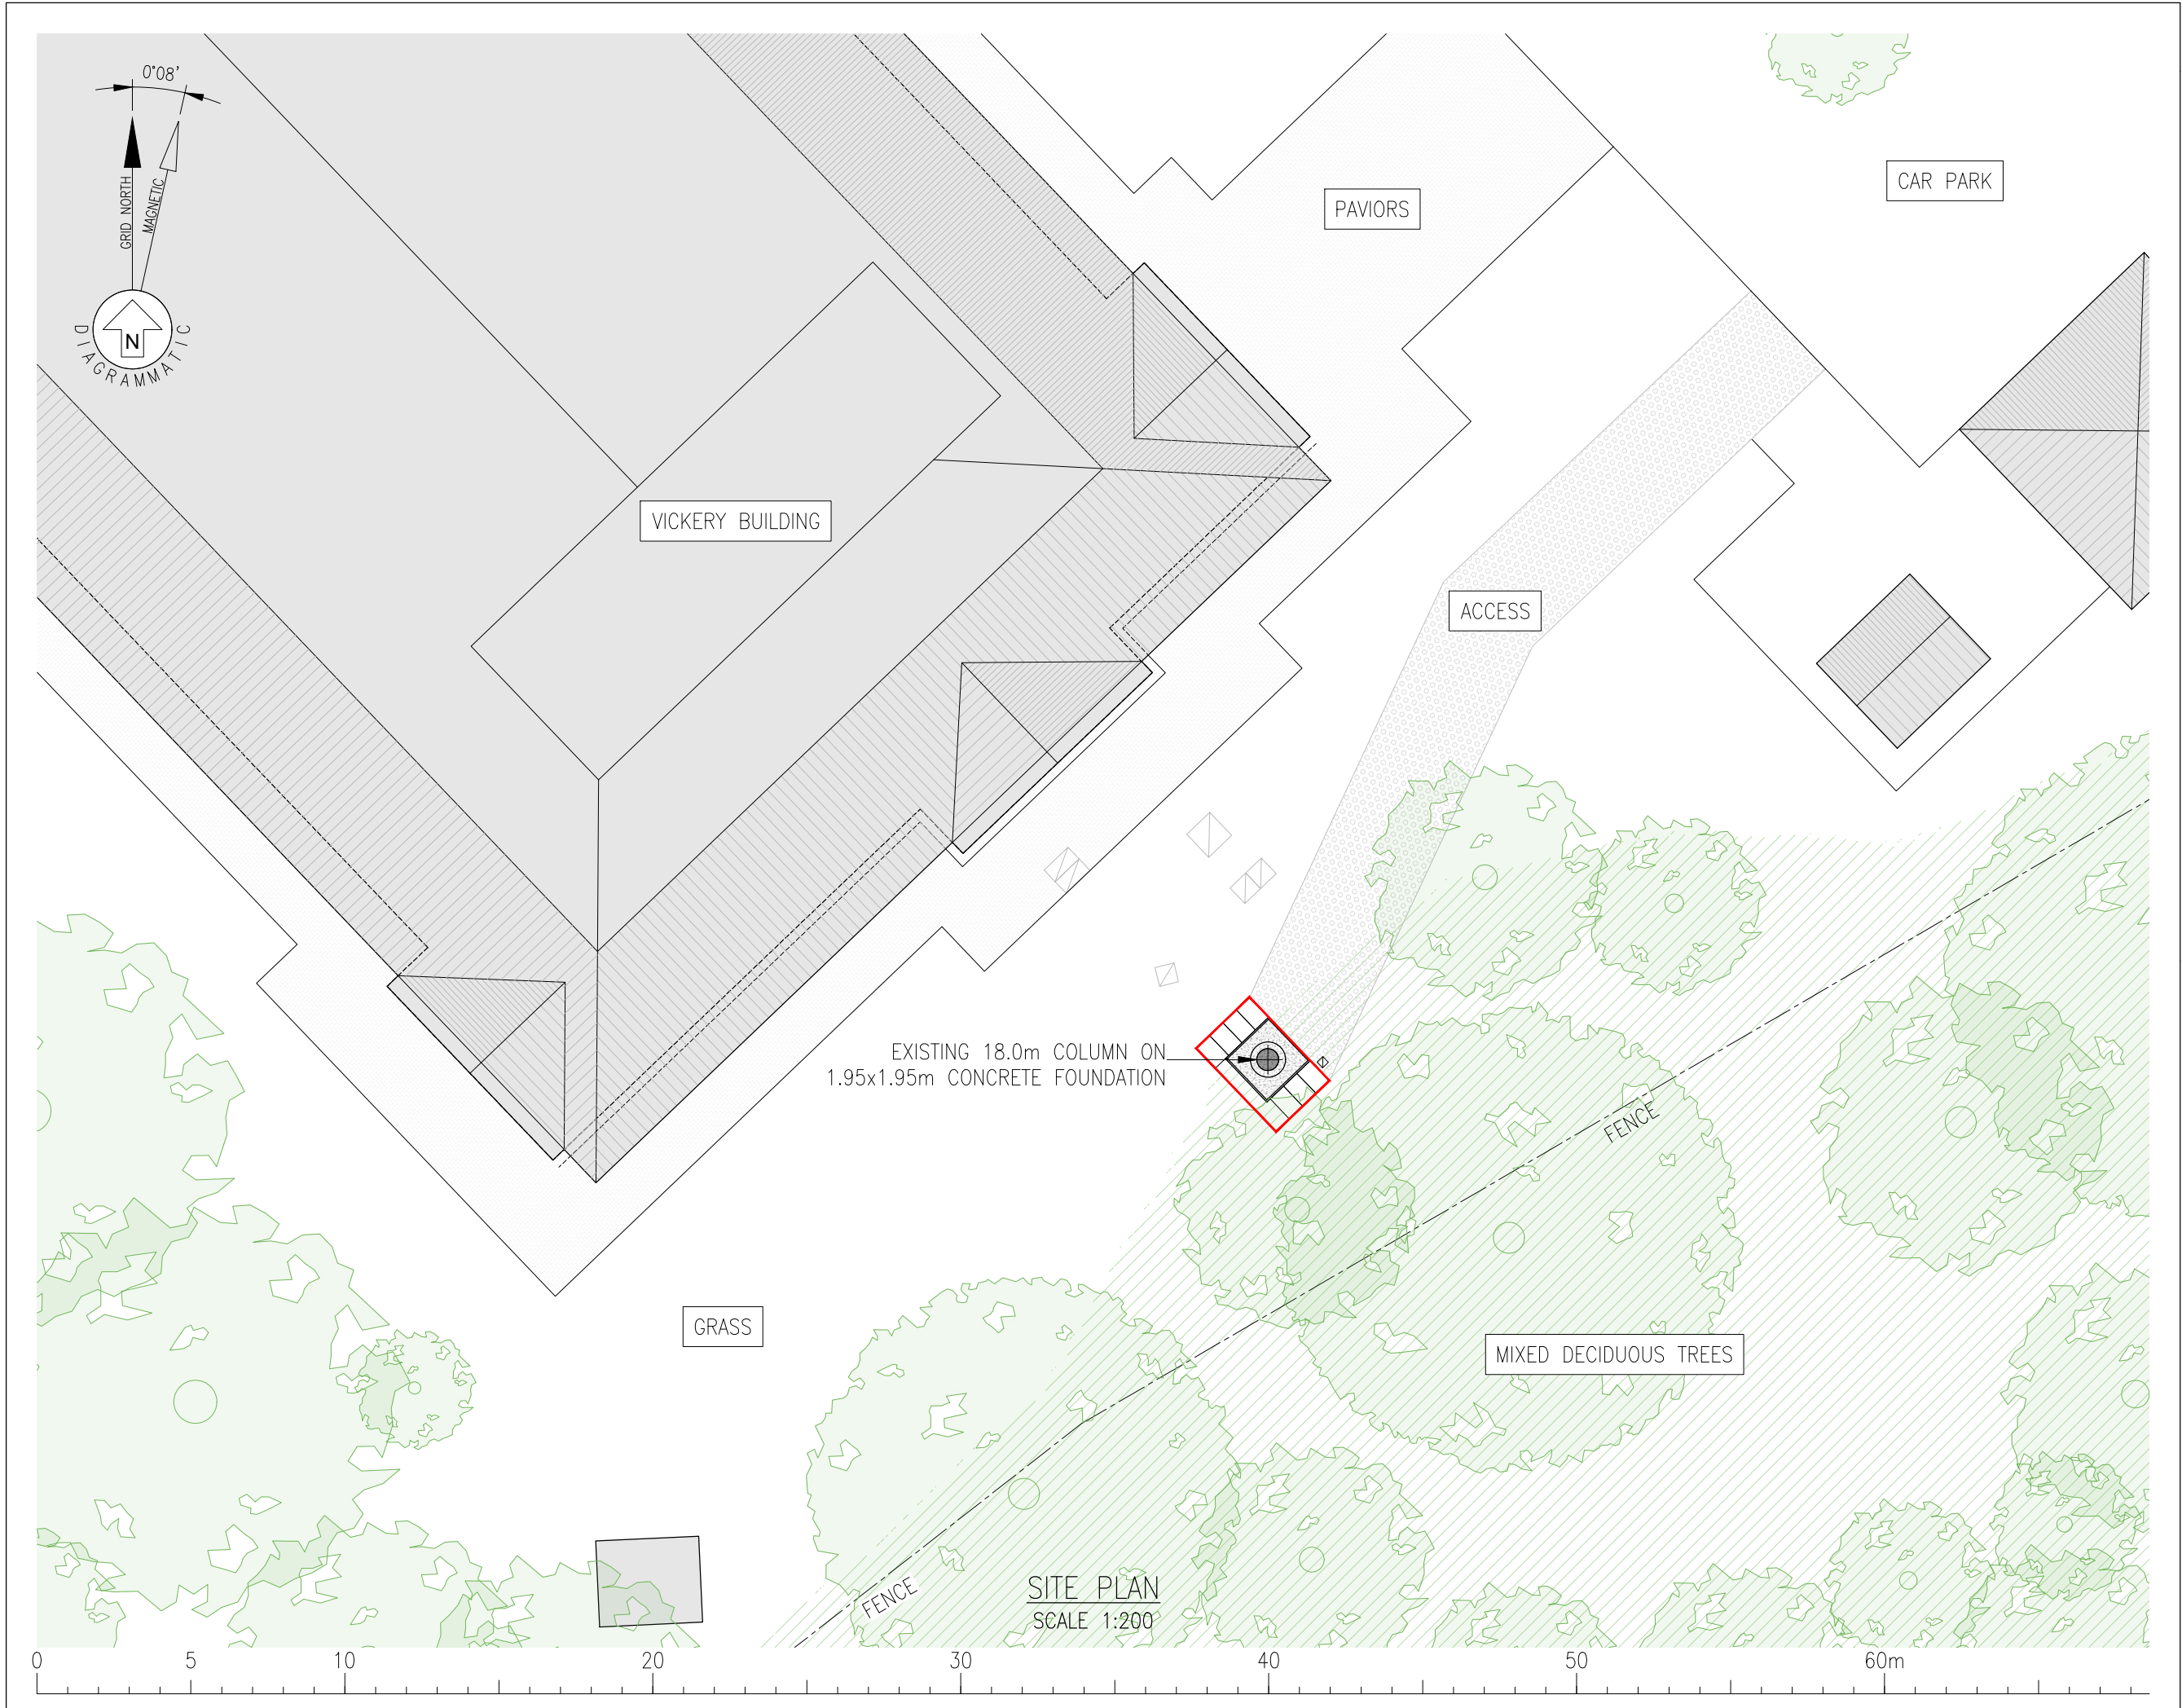

THIS DRAWING IS COPYRIGHT OF MFD COMMUNICATION INFRASTRUCTURE LTD. AND IS PRIVATE AND CONFIDENTIAL. WITHOUT THE WRITTEN CONSENT OF MFD COMMUNICATION INFRASTRUCTURE LTD. IT EXPRESSLY SHALL NOT BE USED FOR ANY UNRELATED PURPOSE, AMENDED, PARTIALLY REPRESENTED, OR COMMUNICATED TO ANY PARTY OTHER THAN THE INTENDED RECIPIENT.

NOTES

1. BEARING OF MAGNETIC NORTH TAKEN FROM BRITISH GEOLOGICAL SURVEY. INFORMATION CORRECT AS OF JULY 2025.

LIST OF DRAWING NUMBERS IN THIS SET:

3671-P1-VICK-801: SITE LOCATION PLAN (OS 50K)
3671-P2-VICK-802: SITE LOCATION PLAN (OS 1250)
3671-P2-VICK-803: SITE PLAN
3671-P3-VICK-804: EXISTING COLUMN PLAN
3671-P3-VICK-805: PROPOSED COLUMN PLAN
3671-P3-VICK-806: EXISTING COLUMN ELEVATION NW
3671-P3-VICK-807: PROPOSED COLUMN ELEVATION NW
3671-P3-VICK-808: EXISTING COLUMN ELEVATION SE
3671-P3-VICK-809: PROPOSED COLUMN ELEVATION SE
3671-P3-VICK-810: EXISTING COLUMN ELEVATION NE
3671-P3-VICK-811: PROPOSED COLUMN ELEVATION NE

REV	DATE	DESCRIPTION	DRN	APPR
A	03.12.25	ISSUED FOR PLANNING	GDH	PB



Communication Infrastructure Consultants
MFD Communication Infrastructure Limited
Studio 52, Basepoint Business Centre, Andersons Road,
Southampton, Hampshire, SO14 5FE, United Kingdom
t: +44 (0)800 058 8550

MFD CI SITE REFERENCE: 0415

CLIENT:
HAMPSHIRE POLICE

PROJECT:
POLICE TRAINING CENTRE, NETLEY ABBEY
VICKERY BUILDING RADAR INSTALLTION

TITLE:
SITE PLAN

SCALE AT A3:	1:200	DATE:	14.08.25
DESIGN/DRAWN:	GDH	REVIEW:	PB
STATUS:	FOR PLANNING		
DRAWING NUMBER:	3671-P1-VICK-803	REV:	A